


DIVISION OF ENGINEERING

GRAND LAKE ST. MARYS STATE PARK PARK OFFICE RENOVATION

DNR-250013 AUGLAIZE COUNTY, OHIO



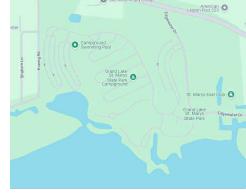

LOCATION MAP

TS1 - TITLE SHEET C1 - CIVIL COVER SHEET

C2 - PAVING NOTES AND DETAILS C3 - UTULITY NOTES AND DETAILS C4 - DEMOLITION NOTES C4 - DEMOLITION NOTES
C5 - EXISTING CHECK-IN BUILDING DEMOLITION
C6 - EXISTING SURVEY AND DEMOLITION
C7 - PROPOSED GEOMETRICS AND UTILITIES

C8 - PROPOSED GRADING AND STRIPING C9 - OVERALL SITE PLAN AND EROSION CONTROL C10 - EROSION CONTROL NOTES AND DETAILS

I 1 01 - LANDSCAPE PLAN

LS100.1 - LIFE SAFETY SHEET

A100.1 - FLOOR PLAN A100.2 - MEZZANINE PLAN AND MAINTENANCE PLATFORM PLAN A200.1 - INTERIORS PLAN A300.1 - REFLECTED CEILING PLAN

INDEX OF SHEETS

A400.1 - ROOF PLAN A400.2 - ROOF DETAILS A400.3 - ROOF DETAILS AND METAL ROOF A401.1 - ALTERNATE ROOF PLAN

A401.2 - ALTERNATE ROOF DETAILS A401.3 - ALTERNATE ROOF DETAILS A500.1 - ENLARGED PLANS A600.1 - EXTERIOR ELEVATIONS

A600.2 - EXTERIOR ELEVATIONS A600.3 - EXTERIOR RENDERINGS A700.1 - BUILDING SECTIONS A700.2 - BUILDING SECTIONS A700.3 - BUILDING SECTIONS

A800 1 - WALL SECTIONS A800.2 - WALL SECTIONS A800.3 - WALL SECTIONS A800.4 - WALL SECTION ABOO 5 - DOOR SCHEDULE

A800.6 - DOOR DETAILS A900.1 - INTERIOR RENDERINGS A900.2 - INTERIOR ELEVATIONS

A900.3 - INTERIOR ELEVATIONS A900.4 - INTERIOR ELEVATIONS A901.1 - CASEWORK DETAILS A901.2 - CASEWORK DETAILS

Glen Cobb GLEN COBB, CHIEF, Division of PARKS AND WATERCRAFT 24/09/2025 DATE

APPROVED FOR BID

9/29/2025 | BE 30 AM EDT

REVIEWED BY

Tric Moser

ERIC MOSER, PROJECT MANAGER, Division of ENGINEERING

JEREMY WENNER, P.E., CHIEF, Division of ENGINEERING

FOR OFFICIAL USE ONLY - Infrastructure Record ent is an infrastructure record pursuant to Ohio Revised Code 149 433(A). Therefore, it is not a

public record and its authorized use, copying or distribution is prohibited.

S00.1 - GENERAL NOTES AND SPECIAL INSPECTIONS \$100.1 - FOUNDATION PLAN

\$200.1 - ROOF FRAMING PLAN

S200.2 - MEZZANINE FRAMING PLAN S300.1 - FOUNDATION DETAILS

\$400.1 - STRUCTURAL SECTIONS AND MISC. DETAILS.

M100.1 - MECHANICAL PLAN M200.1 - MECHANICAL SCHEDULE AND DETAILS

ESP1 - FLECTRICAL SITE PLAN

ESP2 -ELECTRICAL SITE PLAN

F100 1 - LIGHTING PLAN

E200.1 - POWER PLAN E300.1 - SYSTEMS PLAN

E300.2 - DETAILS

E400.1 - SDL AND PANELS E500.1 - ALTERNATE LIGHTING PLANS

BEFORE YOU DIG Call 800-362-2764 (Toll Free) OHIO UTILITIES PROTECTION SERVICE NON-MEMBERS MUST BE CALLED DIRECTLY

FOR OFFICIAL USE ONLY - Infrastructure Record This document is an infrastructure record pursuant to Ohio Revised Code 149.433(A). Therefore, i is not a public record and its authorized use, copying or distribution is prohibited.



TITLE SHEET

DESIGNED BY: BUEHRER GROUP, INC.	PROJECT NUMBER: DNR-250013
DRAWN BY: BUEHRER GROUP, INC	SCALE: VARIES
CHECKED BY: -	DATE: 09/19/2025

GRAND LAKE ST. MARYS PARK OFFICE **AUGLAIZE, OHIO**







GENERAL NOTES

- VERIFY ALL DIMENSIONS AND CONDITIONS AT THE JOB SITE BEFORE WORK IS STARTED. INFORMATION ON THESE DRAWINGS ARE SHOWN FOR THE CONVENIENCE OF THE CONTRACTORS FOR BIDDING. THE CONTRACTOR SHALL BE RESPONSIBLE FOR PROPER NOTIFICATION OF ALL DISCREPANCIES. NOTIFY ARCHITECT OF ANY DISCREPANCIES.
- DO NOT DISASSEMBLE THIS SET. COVER SHEET IS A MASTER INDEX, SYMBOLS AND OTHER ITEMS MAY BE INCLUDED ON ADDITIONAL
- ALL NOTES ON ARCHITECTURAL DRAWINGS REFER TO NEW CONSTRUCTION OR MATERIALS. EXISTING MATERIALS AND CONSTRUCTION ARE SPECIFICALLY CALLED OUT AS EXISTING.
- ALL DIMENSIONS ARE FROM FACE OF MASONRY OR FACE OF DRYWALL.
- PROVIDE DRYWALL CONTROL JOINTS AT A MAXIMUM SPACING OF 30'-0" IN ANY DIRECTION.
- PROVIDE DUMPSTER AND DISPOSE OF ALL WASTE ASSOCIATED WITH THIS PROJECT UNLESS NOTED OTHERWISE ON THESE DRAWINGS.
- ALL WORK SHALL BE PERFORMED IN ACCORDANCE WITH STANDARDS OF BEST PRACTICE BY WORKERS SKILLED IN THEIR RESPECTIVE
- THESE DRAWINGS INDICATE THE GENERAL SCOPE OF THE PROJECT IN TERMS OF ARCHITECTURAL DESIGN CONCEPT, DIMENSIONS OF THE BUILDING. THE MAJOR ARCHITECTURAL ELEMENTS AND THE TYPE OF STRUCTURAL. MECHANICAL. ELECTRICAL SYSTEMS. THE CONTRACTOR SHALL FURNISH ALL ITEMS REQUIRED FOR THE PROPER EXECUTION AND COMPLETION OF THE WORK.
- SEAL ALL TOPS OF GROUND FLOOR SLAB EXPANSION JOINTS AT WALLS OR ANY OTHER THRU-FLOOR JOINT WITH POLYURETHANE CAULK BEFORE FLOOR FINISHES ARE INSTALLED. ALSO SEAL ALL PIPE, CONDUIT, OR ANY OTHER PENETRATION THROUGH THE BUILDING GROUND FLOOR SLAB. ANYTHING ABOVE A 1" DIAMETER HOLE SHALL BE GROUTED SOLID.
- PROVIDE ALL 2x BLOCKING IN WALLS FOR ALL ITEMS SUCH AS BUT NOT LIMITED TO BUILT-IN CABINETS, COUNTERTOP SUPPORTS, GRAB BARS, STORAGE SHELVING, VIDEO MONITORS, ETC. G.C. TO COORDINATE LOCATION OF BLOCKING W/ OWNER & CABINET INSTALLER. IN EXISTING WALLS WHERE BLOCKING IS REQUIRED.
- COORDINATE PLUMBING ROUGH-INS, SINK SIZES & LOCATION OF SINKS W/ CABINET INSTALLER.
- COORD. W/ MECHANICAL SUBCONTRACTOR AND PROVIDE ALL MECH. OPENINGS IN STUD WALLS (W/ STRUCT. HEADERS AS REQUIRED), JOISTS, MASONRY WALLS, ETC.

REFERENCE SYMBOLS

DETAIL NAME

SECTION NAME

-MULTIPLE DOORS

NUMBER WITH A

DOOR REQUIRED

SHALL REPEAT ROOM

POSTSCRIPT LETTER

FOR EACH ADDITIONAL

A1.1 SCALE: 1/4"=1'-0"

SCALE: 1/4"=1'-0"

ROOM NAME

- SQUARE FEET

-EXISTING DOOR

TO BE REMOVED

RM.#

IDENTIFICATION NUMBER

SAME NUMBER ON SHEET WHERE

SHEET IDENTIFICATION

SHEET NUMBER WHERE DETAIL IS

IDENTIFICATION NUMBER -

DRAWN OR REFERENCED

SAME NUMBER ON SHEET WHERE \

SHEET NUMBER WHERE SECTION IS

ROOM NAME AND NUMBER

DOOR IDENTIFICATION

ROOM NUMBER -

PLAN NAME

EXISTING DOOR

SHEET IDENTIFICATION A1.1

DRAWN OR REFERENCED

NUMBER

NUMBER

IDENTIFICATION

- NEW DOOR

DRAWN

DRAWN

- 13. ALL MECH. GRILLS ARE TO BE PAINTED.
- 14. ALL EXPOSED STEEL TO BE PAINTED.
- 15. ALL WALLS ARE TO BE SECURELY BRACED TO STRUCTURE ABOVE FOR SUPPORT.
- 16. ALL PLASTER / DRYWALL SOFFITS & BULKHEADS ARE TO BE PAINTED.
- 17. CONTRACTOR TO SEAL ALL NEW UTILITY PENETRATIONS THROUGH ALL INTERIOR WALLS.
- 18. CONCEAL ALL NEW CONDUIT, PLUMBING, ETC IN NEW WALLS OR UNDER NEW CONCRETE FLOOR SLABS.

KENT D. BUEHRER, LICENSE #1108 EXPIRATION DATE 12/31/25 SIGNATURE DATE 09/19/25

OFFICE

D Φ

REVISION SCHEDULE

ISSUE DATE: 09/19/2025

JOB NUMBER: 241224

CONSTRUCTION DOCUMENTS



GALVANIZED

HANDICAP

GENERAL CONTRACTOR

W/O

WITHOUT


SWP3 NOTICE

THIS SITE IS UNDER 1 ACRES OF DISTURBANCE (0.95 ACRES DISTURBED) AND DOES NOT REQUIRE AN OHIO EPA CONSTRUCTION STORM WATER PERMIT NOTICE OF INTENT.

ALTHOUGH AN OHIO EPA CONSTRUCTION STORM WATER PERMIT IS NOT REQUIRED FOR THIS DEMOLITION PROJECT THE CONTRACTOR SHALL BE RESPONSIBLE FOR FULL COMPLIANCE WITH THE OHIO EPA'S CONSTRUCTION STORM WATER PERMIT AS IF IT WAS REQUIRED. CONTRACTOR SHALL ASSIGN A STORM WATER POLLUTION PREVENTION PLAN (SWP3) INSPECTOR FOR THIS PROJECT AND CONDUCT INSPECTIONS AS REQUIRED PER THE PERMIT.

CONTRACTOR SHALL SUBMIT THE INSPECTION LOGS, SIGNED BY THE SWP3 INSPECTOR, TO THE OWNER WITHIN 24 HOURS AFTER THE INSPECTION HAS BEEN COMPLETED.

CONTRACTOR SHALL BE RESPONSIBLE FOR INSPECTION, REPORTING AND MAINTENANCE/REVISIONS OF EROSION CONTROL MEASURES THROUGHOUT DURÁTION OF THE DEMOLITION PROJECT..

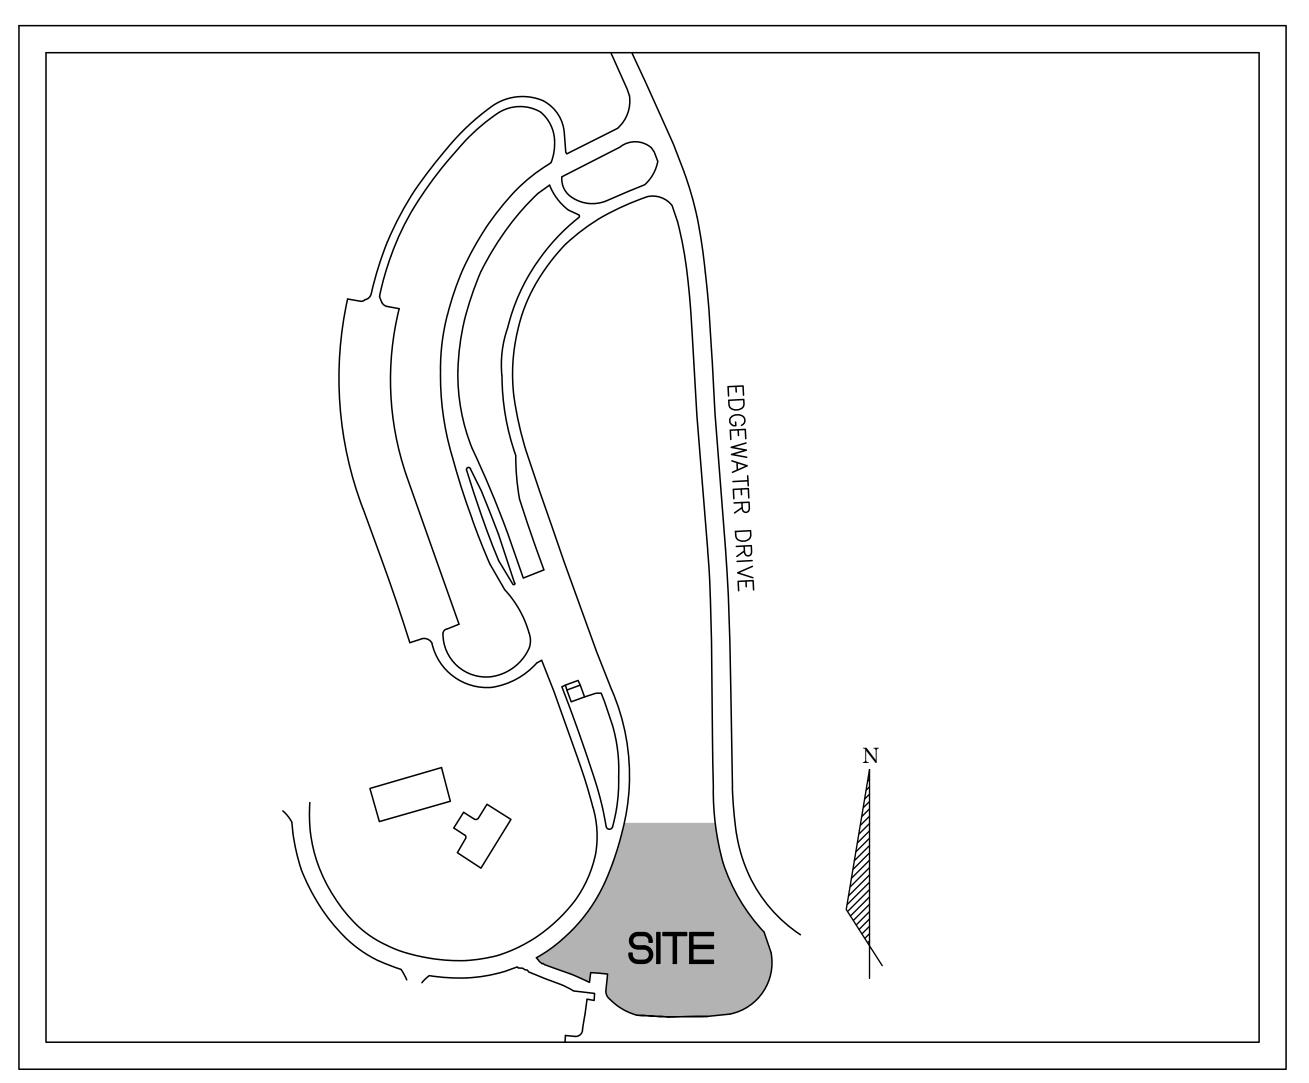

SITE MAP

NOT TO SCALE

INDEX

COVER SHEET PAVING NOTES AND DETAILS UTILITY NOTES AND DETAILS DEMOLITION NOTES EXISTING CHECK-IN BUILDING DEMOLITION EXISTING SURVEY AND DEMOLITION PROPOSED GEOMETRICS AND UTILITIES PROPOSED GRADING AND STRIPING OVERALL SITE PLAN AND EROSION CONTROL EROSION CONTROL NOTES AND DETAILS

Know what's **below**. Call before you dig.

WARNING

UNDERGROUND CONDUITS IN AREA; CONTACT THE OHIO UTILITIES PROTECTION SERVICE (OUPS) TWO WORKING DAYS PRIOR TO ANY EXCAVATION, DEMOLITION OR CONSTRUCTION......1-800-362-2764

CONTRACTOR SHALL IDENTIFY AND CONTACT ANY UTILITY COMPANIES THAT DO NOT PARTICIPATE IN THE OUPS SYSTEM.

TITLE VERDANTAS LLC HAS NOT BEEN PROVIDED A CURRENT TITLE COMMITMENT FOR THE SUBJECT LANDS. AS SUCH, ANY EASEMENTS, RIGHT-OF-WAYS, RESTRICTION OR OTHER TITLE MATTERS THAT MAY BE CONTAINED THEREIN ARE NOT SHOWN ON THIS SURVEY.

PROJECT INFORMATION

CONTRACTOR:
ADDRESS:
PHONE:
SWP3 INSPECTOR:
PHONE:
START DATE:
COMPLETION DATE:

ADDRESS

900 EDGEWATER DR SAINT MARYS, OHIO 45885 Pt. PARCEL No: LAT: 40.545794 **LONG:** -84.437514

BENCH MARK

BM#1 CROSS CUT ON SOUTH RIM OF MANHOLE LE FB 54036

OWNER / DEVELOPER

OHIO DEPARTMENT OF NATURAL RESOURCES DIVISION OF ENGINEERING ERIC MOSER PROJECT MANAGER 2045 MORSE RD. BUILDING E-3 COLUMBUS, OHIO 43229 PHONE: 614-230-9819 ERIC.MOSER@DNR.OHIO.GOV

WETLANDS

THERE ARE NO WETLANDS WITHIN 200' OF THE SITE PER THE US FISH AND WILDLIFE SERVICE NATIONAL WETLANDS INVENTORY

FLOODPLAIN

FLOOD INSURANCE STUDY TABLE 2 - SUMMARY OF ELEVATIONS
GRAND LAKE ST. MARYS WITHIN COMMUNITY ZONE AE ELEV 873 NGVD DATED 09/06/1989 AND ZONE X MAP # 39011C0080C EFFECTIVE 9/6/1989

UTILITY SURVEY LEVEL

SUBSURFACE UTILITY SURVEY HAS BEEN COMPLETED TO THE FOLLOWING INDICATED LEVEL PER THE STANDARDS OF THE AMERICAN SOCIETY OF CIVIL ENGINEERS (ASCE) CI/ASCE 38-02.

QUALITY LEVEL D — INFORMATION DERIVED FROM EXISTING RECORDS OR ORAL RECOLLECTIONS.

QUALITY LEVEL C — INFORMATION OBTAINED BY SURVEYING AND PLOTTING VISIBLE ABOVE—GROUND UTILITY FEATURES AND BY USING PROFESSIONAL JUDGMENT IN CORRELATING THIS INFORMATION TO QUALITY LEVEL D.

QUALITY LEVEL B - INFORMATION OBTAINED THROUGH THE APPLICATION OF APPROPRIATE SURFACE GEOPHYSICAL METHODS (TYPICALLY GROUND PENETRATING RADAR) TO DETERMINE THE EXISTENCE AND APPROXIMATE HORIZONTAL POSITION OF SUBSURFACE

QUALITY LEVEL A — PRECISE HORIZONTAL AND VERTICAL LOCATION OF UTILITIES OBTAINED BY THE ACTUAL EXPOSURE AND SUBSEQUENT MEASUREMENT OF SUBSURFACE UTILITIES, USUALLY AT A SPECIFIC


THE CLIENT SHALL INFORM VERDANTAS LLC IF A HIGHER LEVEL OF UTILITY LOCATION IS REQUIRED.

ENVIRONMENTAL STUDIES

AN ENVIRONMENTAL STUDY, INCLUDING FLOODPLAIN DELINEATION, WETLAND DELINEATION, PHASE 1 ENVIRONMENTAL STUDY, AND/OR HISTORICAL REVIEW, IS NOT PART OF THIS WORK. NO OBSERVABLE EVIDENCE OF AN ON-SITE CEMETERY WAS FOUND. THE CLIENT SHALL INFORM VERDANTAS LLC IF ENVIRONMENTAL, HISTORICAL OR ARCHEOLOGICAL SERVICES ARE REQUIRED.

VERDANTAS LLC HAS NOT BEEN PROVIDED A COPY OF ANY WETLAND DELINEATION FOR THIS SITE, NOR DID THE FIRM FIND ANY FIELD EVIDENCE OF MARKINGS BY A THIRD PARTY TO DENOTE THE LIMITS OF ANY POTENTIAL WETLAND.

O

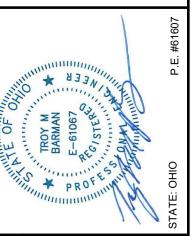

)	1	1	ST/
CHK'D BY DRAWN BY DATE	L	CHECKED BY	TMB	VEI FI OGOT	MPF		PRO IECT NO		30131
CHK'D BY DATE									
REVISION									
No.									

N O O

APPLICATION NO. DATE

09/19/2025 SCALE

SHEET

N/A

PAVEMENT NOTES:

- A. PRICE ADJUSTMENTS SHALL NOT APPLY ON THIS PROJECT INCLUDING, BUT NOT LIMITED TO, ODOT SECTION 401.20 ~ ASPHALT BINDER PRICE ADJUSTMENT
- CONTRACTOR SHALL BE RESPONSIBLE FOR CONSTRUCTION STAKING
- C. THE EARTHWORK ON THIS SITE MAY NOT BE BALANCED AND IT IS THE CONTRACTOR'S RESPONSIBILITY TO EXCAVATE AND PROPERLY DISPOSE OF EXCESS MATERIAL OFF SITE AND/OR PROVIDE, PLACE AND COMPACT SUITABLE FILL MATERIAL AS REQUIRED FOR THE PROJECT. MOUNDING OF EXCESS MATERIAL OR EXCAVATING BORROW PITS ON SITE IS NOT PERMITTED WITHOUT THE WRITTEN APPROVAL OF THE OWNER.

DESIGN THICKNESS FOR PAVEMENT CONTRACTOR SHALL CONSTRUCT ASPHALT AND CONCRETE PAVEMENTS AS INDICATED ON THE

PLANS ALONG WITH CONCRETE CURBS AND SIDEWALKS

ASPHALT PAVEMENT ODOT 441 SURFACE TYPE 1 PG 64-22 = 1.5" ODOT 441 INTERMEDIATE TYPE 1 PG 64-22 = 2.5" ODOT 304 AGGREGATE BASE SUBGRADE COMPACTION

C. EXTERIOR CONCRETE SIDEWALK ODOT ITEM 452 ~ UNREINFORCED CONCRETE 4,000 PSI CONCRETE, 3" SLUMP DOWEL JOINT PER ODOT 499 ODOT ITEM 304 ~ AGGREGATE BASE

SUBGRADE COMPACTION

D. CRUSHED CONCRETE SHALL NOT BE USED ON THIS PROJECT E. CONTRACTOR SHALL SUBMIT A CONCRETE JOINTING PLAN FOR REVIEW AND APPROVAL

TOTAL = 14"

CONCRETE NOTES:

THE MINIMUM 28-DAY COMPRESSIVE STRENGTH OF CONCRETE SHALL BE 4,000 PSI. NO LESS THAN 6 BAGS (564 POUNDS) OF CEMENT SHALL BE USED IN EACH CUBIC YARD OF CONCRETE.

THE MAXIMUM WATER CEMENT RATIO SHALL NOT EXCEED 0.44 (5 GALLONS/BAG OF CEMENT).

- B. THE CONCRETE SHALL HAVE A MAXIMUM 4" SLUMP WHEN TESTED WITH A STANDARD SLUMP CONE (ASTM C143), LATEST EDITION. IF THE ABOVE CONCRETE DEVELOPS A CONSISTENCY OF DIFFICULT WORKABILITY, THEN A SUPERPLASTICIZER ADMIXTURE MAY BE USED AFTER OWNERS APPROVAL. DO NOT ADD WATER TO INCREASE SLUMP.
- ALL CONCRETE TO BE FINISHED INCLUDING WALKS, PAVEMENT AND CURBS SHALL BE AIR-ENTRAINED. ENTRAINED AIR IN CONCRETE SHALL BE A MINIMUM OF 5% AND A MAXIMUM OF 7% BY VOLUME. THE AIR CONTENT SHALL BE MEASURED AT POINT OF DISCHARGE INTO
- CONCRETE TO BE FINISHED FOR PAVEMENT/APPROACHES/PADS SHALL HAVE MACRO-SYNTHETIC FIBROUS REINFORCEMENT. MACRO-SYNTHETIC FIBROUS REINFORCEMENT
- SHALL COMPLY WITH THE FOLLOWING FIBER CHARACTERISTICS: 1. CONFIGURATION - FIBER SHALL BE A SYNERGISTIC COMBINATION OF A TWISTED-BUNDLE NON-FIBRILLATING MONOFILAMENT AND A FIBRILLATING NETWORK FIBER SYSTEM.
- 2. CHEMISTRY FIBER SHALL BE MADE OF 100% VIRGIN MATERIALS IN THE FORM OF FULLY-ORIENTED COPOLYMER/POLYPROPYLENE, GRAY IN COLOR.
- 3. CONTENTS FIBER SHALL BE USED AT A DOSAGE RATE OF 3 LBS. PER CUBIC YARD.
- 4. CORRECT LENGTH FIBER LENGTH SHALL BE 2.25".
- COMPLIANCE: FIBERS SHALL COMPLY WITH A.S.T.M. C-1116 "STANDARD SPECIFICATION FOR FIBER REINFORCED CONCRETE AND SHOTCRETE". THE APPROVED PRODUCT IS FORTA-FERRO® STRUCTURAL FIBER AS MANUFACTURED BY FORTA CORPORATION, GROVE CITY, PA, U.S.A. PHONE: 1-800-245-0306 OR 1-724-458-5221; FAX: 1-724-458-8331
- CONTRACTOR SHALL SUBMIT A MIX DESIGN FOR APPROVAL BY OWNER AT LEAST TWO WEEKS BEFORE CONCRETE WORK BEGINS. DESIGN SHALL DETAIL ALL CONSTITUENTS AND GRADATION. THE CONCRETE SHALL CONFORM TO "STANDARD SPECIFICATION FOR READY-MIXED CONCRETE (ASTM C94), LATEST EDITION.
- CONTRACTOR SHALL ASSURE THE OWNER THAT THE CONCRETE MEETS SPECIFICATIONS BY FURNISHING BATCH TICKETS WHEN THE CONCRETE IS DELIVERED TO THE SITE.

1.04 MIXING AND PLACING CONCRETE:

- A. MIXING AND PLACING CONCRETE SHALL CONFORM TO "BUILDING CODE REQUIREMENTS FOR REINFORCED CONCRETE" (ACI 318), LATEST EDITION & LOCAL BUILDING CODES.
- B. CONVEYING: CONCRETE SHALL BE CONVEYED FROM THE MIXER TO THE PLACE OF FINAL DEPOSIT BY METHODS WHICH WILL PREVENT THE SEPARATION OR LOSS OF MATERIALS.
- - 1. THE SUBGRADE OR SUBBASE SHALL BE SPRINKLED AT SUCH TIMES AND IN SUCH MANNER AS DIRECTED BY THE ENGINEER SO THAT IT WILL BE IN A THOROUGHLY MOISTENED CONDITION WHEN THE CONCRETE IS DEPOSITED THEREON. SUBGRADE SHOULD ALSO BE UNDISTURBED OR COMPACTED TO MAXIMUM DRY DENSITY IN ACCORDANCE WITH SOIL REPORT PREPARED BY A LICENSED TESTING FIRM.
 - 2. CONCRETE SHALL BE DEPOSITED AS NEARLY AS PRACTICABLE IN ITS FINAL POSITION TO AVOID SEGREGATION DUE TO REHANDLING OR FLOWING. USE CHUTES, BOTTOM DUMP BUCKETS, OR OTHER METHOD APPROVED BY OWNER. CONCRETE SHALL NOT BE SPREAD HORIZONTALLY USING VIBRATING EQUIPMENT.
 - 3. THE CONCRETING SHALL BE CARRIED ON AT SUCH A RATE THAT THE CONCRETE IS AT ALL TIMES PLASTIC AND FLOWS READILY INTO THE SPACES BETWEEN REINFORCING BARS. NO CONCRETE THAT HAS PARTIALLY HARDENED OR BEEN CONTAMINATED BY FOREIGN MATERIALS SHALL BE DEPOSITED IN THE STRUCTURE, NOR SHALL RETEMPERED CONCRETE
- 4. ONCE CONCRETE WORK HAS BEGUN, IT SHALL BE CARRIED ON AS A CONTINUOUS OPERATION UNTIL THE PLACING OF THE PANEL OR SECTION IS COMPLETED.
- 5. ALL CONCRETE SHALL BE THOROUGHLY CONSOLIDATED BY SUITABLE MEANS DURING PLACEMENT, SHALL BE THOROUGHLY WORKED AROUND THE REINFORCEMENT AND EMBEDDED FIXTURES AND INTO THE CORNERS OF THE FORMS.
- 6. CONCRETE SHALL BE DEPOSITED AS NEAR TO EXPANSION AND CONTRACTION JOINTS AS POSSIBLE WITHOUT DISTURBING THEM, BUT SHALL NOT BE DUMPED FROM THE DISCHARGE BUCKET OR HOPPER ONTO A JOINT ASSEMBLY UNLESS HOPPER IS WELL CENTERED ON THE ASSEMBLY. CONCRETE SHALL BE CONSOLIDATED AROUND EXPANSION AND CONSTRUCTION JOINTS BY MEANS OF INTERNAL VIBRATION.

1.05 COLD WEATHER REQUIREMENTS

ADEQUATE EQUIPMENT SHALL BE PROVIDED FOR HEATING THE CONCRETE MATERIALS AND PROTECTING THE CONCRETE DURING FREEZING OR NEAR-FREEZING WEATHER. ALL CONCRETE MATERIALS AND ALL REINFORCEMENT, FORMS, FILLERS, AND GROUND WHICH CONTACT THE CONCRETE SHALL BE FREE FROM FROST. NO FROZEN MATERIALS OR MATERIALS CONTAINING

ICE SHALL BE USED. B. CONCRETE DELIVERED IN COLD WEATHER SHALL HAVE THE APPLICABLE MINIMUM TEMPERATURE AS FOLLOWS:

AIR TEMPERATURE MINIMUM CONCRETE TEMPERATURE *F 30 - 45 BELOW C

- CONCRETE SHALL BE MAINTAINED ABOVE 50 F AND IN A MOISTURE CONDITION FOR AT LEAST THE FIRST SEVEN (7) DAYS AFTER PLACING.
- THE MAXIMUM TEMPERATURE OF CONCRETE PRODUCED WITH HEATED AGGREGATES, HEATED WATER, OR BOTH, SHALL AT NO TIME DURING ITS PRODUCTION OR TRANSPORTATION, EXCEED

1.06 HOT WEATHER REQUIREMENTS: A. FOLLOW REQUIREMENTS OF ACI 305, LATEST EDITION.

DURING HOT WEATHER, STEPS SHALL BE TAKEN TO REDUCE CONCRETE TEMPERATURE AND WATER EVAPORATION BY PROPER ATTENTION TO INGREDIENTS, PRODUCTION METHODS, HANDLING, PLACING, PROTECTION, AND CURING. THE PREFERRED PROTECTION IS A COVERING OF KRAFT PAPER (ASTM C171) FOR A PERIOD OF TWENTY-FOUR HOURS AFTER PLACING.

- FORMS FOR ALL CONTACT FACES SHALL BE DRESSED LUMBER OR MANUFACTURED FORMS. THEY SHALL CONFORM TO THE SHAPE, LINES AND DIMENSIONS OF THE MEMBER AS SPECIFIED ON THE
- B. ALL FORMS SHALL BE SET WITH REASONABLE CONFORMANCE TO THE REQUIRED GRADE AND ALIGNMENT AND BE SUPPORTED ON THOROUGHLY COMPACTED MATERIAL FOR THEIR ENTIRE LENGTH DURING THE ENTIRE OPERATION OF PLACING AND FINISHING OF THE CONCRETE. AFTER THE SETTING OF SIDE FORMS THE TOP FACE OF THE FORM SHALL NOT VARY FROM A TRUE PLANE MORE THAN 1/8 INCH IN 10 FEET, AND THE VERTICAL FACE SHALL NOT VARY MORE THAN 1/4 INCH IN 10 FEET, AND THEY SHALL BE TESTED BY THE CONTRACTOR AND VARIATIONS FROM THE ABOVE REQUIREMENTS SHALL BE ELIMINATED BY RESETTING THE FORMS. SHIMMING WITH LOOSE EARTH, PEBBLES, ETC., WILL NOT BE PERMITTED.
- FORMS SHALL BE SUBSTANTIAL AND SUFFICIENTLY TIGHT TO PREVENT LEAKS. THEY SHALL BE PROPERLY BRACED OR TIED TOGETHER TO MAINTAIN POSITION AND SHAPE.
- PRIOR TO POURING THE CONCRETE, ALL DEBRIS SHALL BE REMOVED FROM WITHIN THE FORMWORK AND THE FORMS SHALL BE WET DOWN. NO CONCRETE SHALL BE POURED IF THE SUBGRADE HAS STANDING WATER OR IS MUDDY.
- FORMS SHALL BE REMOVED IN SUCH MANNER AS TO ENSURE THE COMPLETE SAFETY OF THE STRUCTURE. WHERE THE STRUCTURE AS A WHOLE IS ADEQUATELY SUPPORTED, THE FORMS MAY BE REMOVED AFTER 24 HOURS PROVIDED THE CONCRETE IS SUFFICIENTLY STRONG TO CARRY ITS OWN WEIGHT AND ALL OTHER CONSTRUCTION LOADS WHICH MAY OCCUR.

1.08 WALKS, PAVING AND CURBS

- THE SUBGRADE OR BASE SHALL BE SPRINKLED AND THOROUGHLY MOISTENED PRIOR TO CONCRETE PLACEMENT. NO CONCRETE SHALL BE POURED IF THE SUBGRADE HAS STANDING
- CONCRETE SHALL BE POURED MONOLITHICALLY WITHIN LIMITS OF EXPANSION JOINTS SHOWN ON
- ALL WALKS AND PAVING SHALL BE WOOD FLOATED, WOOD TROWELED AND THEN LIGHTLY STEEL TROWELED TO SECURE A SEMI-SMOOTH SURFACE. SURFACE SHALL THEN BE BROOM FINISHED TO MATCH APPROVED SAMPLE.
- EXPOSED SURFACES OF CURBS AND RETAINING WALLS SHALL HAVE A SMOOTH FINISH. REMOVE FINS AND PROJECTIONS, PATCH DEFECTIVE AREAS WITH CEMENT GROUT, AND RUB WITH CARBORUNDUM BRICK AND CEMENT MORTAR TO A SMOOTH UNIFORM TEXTURE.
- ALL CROSSWALKS SHALL HAVE "BARRIER-FREE" ACCESS PER THE AMERICANS WITH DISABILITIES ACT REQUIREMENTS.

.09 REPAIR OF DEFECTIVE CONCRETE SURFACES:

- CONTRACTOR SHALL BE RESPONSIBLE FOR SECURING AND PROTECTING ALL NEW CONCRETE FROM BEING DISTURBED. CONCRETE IN WHICH THE FINISH HAS BEEN DISTURBED SHALL BE REMOVED AND REPLACED BY THE CONTRACTOR AT THE CONTRACTOR'S COST. ANY SECTIONS OF PAVEMENT THAT REQUIRE REMOVAL AND REPLACEMENT SHALL BE DOWELED INTO THE ADJACENT
- DO NOT PATCH DEFECTIVE CONCRETE UNTIL EXAMINED AND APPROVED BY THE OWNER. WHERE SO APPROVED, MAKE REPAIRS IN ACCORDANCE WITH DETAILED INSTRUCTIONS GIVEN BY THE

A. LIQUID MEMBRANE-FORMING COMPOUNDS FOR CURING CONCRETE. FURNISH LIQUID MEMBRANE-FORMING COMPOUNDS CONFORMING TO ASTM C 309, WITH THE FOLLOWING

8.1 EQUIP THE CONTAINERS FOR TYPE 2 WHITE PIGMENTED LIQUID MEMBRANE-FORMING COMPOUNDS WITH MECHANICAL AGITATORS. ASSIGN EACH CONTAINER IN ANY BATCH OR LOT. A NUMBER AS THE CONTAINER IS BEING FILLED

STRUCTURE IS NOT IMPAIRED.

- CONTRACTOR SHALL PROVIDE CONSTRUCTION, EXPANSION AND CONTROL JOINTS AS INDICATED OR
- CONSTRUCTION JOINTS SHALL BE USED WHENEVER PLACING OPERATIONS ARE INTERRUPTED. THESE JOINTS SHALL BE KEYED AND LOCATED SO THE STRENGTH AND APPEARANCE OF THE
- EXPANSION JOINTS SHALL BE INSTALLED AS INDICATED ON THE DRAWINGS. FLEXIBLE JOINT FILLER SHALL BE MINIMUM 1/2 INCH THICK PREFORMED SPONGE RUBBER (ASTM D1752) OR APPROVED EQUAL. JOINT FILLER SHALL EXTEND FULL DEPTH OF SLAB.

ASPHALT PAVEMENT NOTES:

PART 2 - GENERAL 2.01 GENERAL

PRICE ADJUSTMENTS SHALL NOT APPLY ON THIS PROJECT INCLUDING, BUT NOT LIMITED TO, ODOT SECTION 401.20 ~ ASPHALT BINDER PRICE ADJUSTMENT.

PART 3 - PRODUCTS 3.01 BASE COURSE

- THE AGGREGATE SHALL BE CLEAN, TOUGH DURABLE CRUSHED LIMESTONE FROM A MINIMUM SIZE NOT LESS THAN ONE (1) INCH TO THE MAXIMUM SIZE NOT MORE THAN TWO (2) INCHES, WITH A SIEVE ANALYSIS TOLERANCE OF TEN (10) PERCENT ON BOTH MAXIMUM AND MINIMUM SIZES. AGGREGATE SHALL WEIGH NOT LESS THAN 90 POUNDS PER CUBIC FOOT FOR LIMESTONE.
- THE SCREENINGS SHALL CONSIST OF THE SAME MATERIALS AS SPECIFIED ABOVE FOR COARSE MATERIAL, FREE FROM DIRT OR OTHER FOREIGN SUBSTANCES. THIS MATERIAL SHALL NOT EXCEED A MAXIMUM SIZE OF ONE-HALF (1/2) INCH AND ALL SMALLER SIZES DOWN TO AND INCLUDING

THE TACK COAT SHALL CONSIST OF ONE PART WATER TO ONE PART SS-1 ASPHALT EMULSION. IT SHALL BE APPLIED AT A RATE OF 0.05 TO 0.15 GALLONS/SQ. YARD.

EQUAL. COLOR SHALL BE SELECTED BY OWNER.

3.03 TRAFFIC MARKING PAINT:

GLIDDEN "TRAFFIC ZONE PAINT", SHERWIN-WILLIAMS "PRO MAR" SERIES B36, OR APPROVED

PART 4 - EXECUTION 4.01 EQUIPMENT:

EQUIPMENT USED SHALL BE OF TYPE, SIZE, WEIGHT AND SHAPE BEST SUITED TO OBTAIN UNIFORMITY, DENSITY AND SHAPING AS REQUIRED BY THE PLANS AND SPECIFICATIONS.

4.02 WEATHER LIMITATIONS:

NO PAVEMENT SHALL BE INSTALLED WHEN THE TEMPERATURE IS BELOW 50° F OR WHEN THE SURFACES CONTAIN FROST OR AN EXCESS OF MOISTURE, OR WHEN WEATHER CONDITIONS PREVENT PROPER SPREADING, FINISH, OR COMPACTION. UNDER NO CIRCUMSTANCES SHALL ANY MIXTURE BE DEPOSITED OR SPREAD ON AN UNDERLYING ASPHALTIC CONCRETE COURSE WHERE A DEPOSIT OF LEAVES, LOOSE AGGREGATE, CLAY OR LOAM REMAINS.

- THE SUBGRADE SHALL BE PROPERLY PREPARED AND ROLLED OVER THE FULL WIDTH A ROLLER OF SUITABLE WEIGHT (PREFERABLY A THREE-WHEEL ROLLER WEIGHING 10 TONS) BEFORE PLACING THE BASE COURSE. CHECK FOR UNSTABLE AREAS AND AREAS REQUIRING ADDITIONAL COMPACTION. REPLACE UNACCEPTABLE AREAS WITH NEW MATERIAL AS SPECIFIED IN EARTHWORK SPECIFICATION.
- B. ALL DEBRIS, VEGETATION OR OTHER PERISHABLE MATERIALS SHALL BE REMOVED FROM AREAS TO BE PAVED. THE SITE TO BE PAVED SHALL BE GRADED TO THE REQUIRED SECTION AND ALL EXCESS MATERIAL REMOVED FROM THE LOCATION OF WORK. (MATERIAL IN SOFT SPOTS SHALL BE REMOVED TO A DEPTH EQUAL TO THE BEST SUBGRADE MATERIAL ON SITE). THE SUBGRADE SHALL BE COMPACTED WITH A ROLLER WEIGHING AT LEAST EIGHT (8) TONS TO A DENSITY OF BETWEEN 95 AND 100% STANDARD PROCTOR MAXIMUM DRY UNIT WEIGHT (ASTM D 6980) AT OPTIMUM TO PLUS 4% OVER OPTIMUM. THE SURFACES OF THE SUBGRADE AFTER COMPACTION SHALL BE HARD, UNIFORM, SMOOTH, AND TRUE TO GRADE AND CROSS SECTION.
- ADJACENT ABUTTING VERTICAL CONSTRUCTION, SUCH AS BUILDING WALLS OR RAISED CURBS, SHOULD BE THOROUGHLY PAINTED WITH A HOT ASPHALT CEMENT OR ASPHALT EMULSION TO A DEPTH EQUAL TO THE THICKNESS OF THE BASE AND SURFACE COURSE.
- IN AREAS TOO SMALL FOR A ROLLER, A VIBRATING PLATE COMPACTOR, OR HAND TAMPER SHALL BE USED TO ACHIEVE THOROUGH COMPACTION.
- WHEN ABUTTING EXISTING PAVING, A JOINT SHALL BE SAW-CUT TO A SUFFICIENT DEPTH SO A STRAIGHT, SQUARE EDGE IS FORMED. SAID JOINT SHALL BE RELIEVED AND SEALED.
- THE COARSE AGGREGATE OF THE BASE COURSE SHALL BE SPREAD EVENLY UPON THE PREPARED SUBGRADE AND COMPACTED. THIS COURSE SHALL BE ROLLED WITH A THREE-WHEEL POWER ROLLER WEIGHING NOT LESS THAN EIGHT (8) TONS. ROLLING SHALL CONTINUE UNTIL THE STONE IS LOCKED AND DOES NOT CREEP OR WAVE AHEAD OF THE WHEELS. SUFFICIENT SCREENINGS SHALL THEN BE APPLIED TO COMPLETELY FILL THE VOIDS AND THE BASE COURSE AGAIN ROLLED, ADDING SCREENINGS AS REQUIRED. ROLLING SHALL CONTINUE AND ADDITIONAL SCREENING SHALL BE APPLIED WHERE NECESSARY UNTIL THE COARSE MATERIAL IS WELL BONDED AND FIRMLY SET TO PRODUCE A ROUGH GRANULAR SURFACE.

IF THE ASPHALT INTERMEDIATE COURSE HAS BEEN USED BY TRAFFIC AND IS IN A WORN CONDITION, THEN IT SHALL BE CLEANED AND COATED WITH A TACK COAT BEFORE APPLYING THE ASPHALT SURFACE COURSE. OVER SPRAY ON ANY CONCRETE SURFACES WILL NOT BE ACCEPTED. THE COST OF TACK COAT SHALL BE INCLUDED IN THE COST OF THE INTERMEDIATE

4.06 ASPHALT CONCRETE COURSE

THE PREPARED BASE COURSE SHALL BE CLEANED OF ALL FOREIGN SUBSTANCES BEFORE APPLYING THE ASPHALT CONCRETE COURSES. EACH PREMIXED ASPHALT CONCRETE COURSE SHALL BE SPREAD TO A UNIFORM LOOSE-FILL THICKNESS AND ROLLED WITH A 10-TON, THREE—WHEEL POWER ROLLER. THE FINISHED SURFACE SHALL BE UNIFORM, FREE FROM RUTS OR IRREGULARITIES IN CONTOUR, AND TRUE TO THE ESTABLISHED GRADE. IT MUST PRESENT A SMOOTH RIDING SURFACE.

- 4.07 QUALITY ASSURANCE:

 A. THE PAVEMENT SURFACE SHALL BE CONSTRUCTED SUCH THAT ADEQUATE DRAINAGE IS ACHIEVED. THE CONTRACTOR SHALL UPON COMPLETION OF EACH SECTION OF PAVING, MAKE A WATER TEST FOR DRAINAGE AT THE DISCRETION OF THE OWNER. ANY PORTION WHERE WATER STANDS SHALL BE REWORKED EVEN TO THE POINT OF REPLACEMENT SO THAT IT DRAINS PROPERLY TO THE SATISFACTION OF THE GENERAL CONTRACTOR.
- THE SURFACE OF THE COMPLETED WORK, WHEN TESTED WITH A TEN-FOOT STRAIGHTEDGE, SHALL NOT CONTAIN IRREGULARITIES IN EXCESS OF 1/4 INCH. DEFECTIVE PAVING SHALL BE REPLACED.
- CARE SHALL BE EXERCISED BY THE CONTRACTOR TO SECURE A TRUE AND UNIFORM ALIGNMENT ALONG OUTSIDE EDGES.
- A 20-LB. SAMPLE OF HOT MIX TO BE USED SHALL BE MADE AVAILABLE TO THE GENERAL CONTRACTOR'S REPRESENTATIVE AT LEAST ONE WEEK BEFORE PAVING IS BEGUN. THE GENERAL CONTRACTOR'S REPRESENTATIVE RESERVES THE RIGHT TO CORE THE PAVEMENT TO CHECK THE MIX, COMPACTION, AND THICKNESS

CLEAN SURFACE TO REMOVE LOOSE MATERIAL AND DIRT. APPLY 4-INCH WIDE PAINT STRIPES WITH MECHANICAL EQUIPMENT TO PRODUCE UNIFORM STRAIGHT EDGES. APPLY 2 COATS AT MANUFACTURER'S RECOMMENDED RATES. MARKING OF NEW ASPHALT SHALL NOT BE DONE FOR 6 MONTHS, UNTIL ASPHALT HAS CURED, OR WHEN DIRECTED BY OWNER.

- 4.09 PROTECTION:

 A. PROTECT EXPOSED FINISHED SURFACES ADJACENT TO PAVING WORK FROM BECOMING DISFIGURED DURING APPLICATION OF PAVING MATERIALS AND FROM PHYSICAL DAMAGE RESULTING FROM CONTACT WITH PAVING EQUIPMENT. SURFACES DAMAGED DURING THE COURSE OF THIS WORK SHALL BE CLEANED, REPAIRED OR REPLACED BY THE CONTRACTOR AT NO ADDITIONAL EXPENSE TO THE GENERAL CONTRACTOR.
- PROVIDE TEMPORARY BARRICADES TO KEEP TRAFFIC OFF COMPLETED PAVING WORK BARRICADES SHALL BE LEFT IN PLACE A MINIMUM OF THREE DAYS AFTER PAVING WORK IS

IMMEDIATELY PRIOR TO TURNING OVER TO GENERAL CONTRACTOR, REMOVE ALL TRASH, TEMPORARY WOOD FORMS, AND OTHER DEBRIS. DISPOSE OF ALL EXCESS MATERIAL AND RAKE ENTIRE AREA SMOOTH AND CLEAN.

EARTHWORK NOTES:

- CONTRACTOR SHALL VERIFY EXISTING CONDITIONS, INCLUDING BUT NOT LIMITED TO, GRADES, CONTOURS. IMPROVEMENTS AND UTILITIES PRIOR TO SUBMITTING A BID FOR THE PROJECT. CONTRACTOR SHALL NOTIFY THE ENGINEER OF ANY APPARENT DISCREPANCIES.
- CONTRACTOR SHALL TAPER ALL LAWN AREAS AT A MAXIMUM SLOPE OF 5' HORIZONTAL TO 1' VERTICAL FROM PROPOSED CONSTRUCTION TO MATCH EXISTING LAWN GRADES.
- PROVIDE SHORING, BARRIERS AND RAILINGS AS REQUIRED BY LAW OR REGULATIONS FOR THE
- PROTECTION OF EMPLOYEES, THE PUBLIC AND ADJACENT PROPERTY. CLOSE OPEN ENDS OF ABANDONED UNDERGROUND UTILITIES WHICH ARE INDICATED TO REMAIN IN PLACE. PROVIDE SUFFICIENTLY STRONG CLOSURES TO WITHSTAND ANY HYDROSTATIC OR EARTH
- PRESSURE WHICH MAY RESULT AFTER ENDS OF ABANDONED UTILITIES HAVE BEEN CLOSED. PROPERLY BARRICADE, PROTECT AND MAINTAIN ANY OPEN TRENCH OR EXCAVATION TO PREVENT ACCIDENTAL OR UNAUTHORIZED ENTRANCE.
- MOISTURE-DENSITY RELATIONS OF SOILS USING 5.5-LB HAMMER AND 12-IN ASTM D698 DENSITY OF SOIL IN PLACE BY THE SAND-CONE METHOD.

RELATIVE DENSITY OF COHESIONLESS SOILS.

ASTM D2167

SITE SHALL BE CLEARED OF ANY IMPROVEMENTS OR OBSTRUCTIONS WITHIN THE ENTIRE AREA TO BE DEVELOPED OR AS SHOWN ON THE DRAWINGS. FOR EXAMPLE, FOUNDATIONS OR ANY OTHER SIMILAR MATERIAL, SHALL BE REMOVED TO A MINIMUM OF THREE FEET BELOW GRADE. TREES UP TO 24" DIAMETER SHALL BE GRUBBED TO A MINIMUM OF TWO FEET BELOW GRADE; TREES EXCEEDING 24" DIAMETER SHALL BE BE GRUBBED TO A MINIMUM OF THREE FEET BELOW GRADE. ALL TRASH AND DEBRIS SHALL BE REMOVED FROM THE SITE PRIOR TO PLACING ANY FILL, CONCRETE OR PAVING.

DENSITY OF SOIL IN PLACE BY THE RUBBER-BALLOON METHOD.

- PRIOR TO REMOVING TOPSOIL, ALL VEGETATION OF A HEIGHT GREATER THAN ONE FOOT SHALL BE REDUCED TO A HEIGHT OF SIX (6) INCHES. ALL SUCH VEGETATION AND ALL BRUSH, ROCKS AND ANY OTHER OBJECTIONABLE LITTER OR FOREIGN MATERIAL SHALL BE REMOVED AND DISPOSED OF BY THE CONTRACTOR.
- THE CONTRACTOR IS RESPONSIBLE FOR LOCATING ALL UNDERGROUND PLUMBING OR ELECTRICAL LINES. COOPERATE WITH UTILITY COMPANIES TO MAINTAIN UTILITY LINES IN CONTINUOUS OPERATION. NO DISRUPTION OF UTILITY SERVICES SHALL BE ALLOWED WITHOUT GENERAL CONTRACTOR AND UTILITY COMPANY APPROVAL.
- ANY EXISTING UTILITY SERVICES OR UNDERGROUND LINES EXPOSED BY EXCAVATION OR GRADING
- SHALL BE PROTECTED AND THE PROPER UTILITY COMPANY NOTIFIED. DEMOLISH AND COMPLETELY REMOVE FROM THE SITE ANY EXISTING UNDERGROUND UTILITIES WHICH ARE INDICATED TO BE REMOVED. COORDINATE WITH UTILITY COMPANIES FOR SHUT-OFF OF SERVICES IF LINES ARE ACTIVE.

- IN PERFORMING THE EXCAVATION, THE CONTRACTOR SHALL RETAIN SUFFICIENT CLEAN EARTH FOR ALL BACKFILLING OR GRADING.
- EXCAVATIONS FOR FOUNDATIONS SHALL BE CARRIED TO THE DEPTH SHOWN ON DRAWINGS OR DEEPER, IF NECESSARY, TO ATTAIN PROPER SOIL BEARING VALUE. DEEPER FOUNDATIONS SHALL BE APPROVED IN WRITING BY THE GENERAL CONTRACTOR AND SHALL CONFORM TO ALL GOVERNING CODES.
- THE CONTRACTOR SHALL AT ALL TIMES DURING THE CONSTRUCTION OF THE WORK, AND AT ITS COMPLETION FOR FINAL INSPECTION, PROVIDE AND MAINTAIN AMPLE MEANS AND EQUIPMENT WITH WHICH TO PROPERLY REMOVE AND DISPOSE OF ALL WATER ENTERING THE EXCAVATION, OR OTHER PARTS OF THE WORK. AND KEEP SUCH EXCAVATIONS DRY UNTIL THE STRUCTURES TO BE BUILT THEREIN HAVE BEEN COMPLETED. ALL WATER PUMPED OR DRAINED FROM THE WORK HEREUNDER SHALL BE DISPOSED OF IN A SUITABLE MANNER WITHOUT DAMAGE TO THE ADJACENT DRAINS, OR WATER—COURSES ENCOUNTERED ON THE WORK, AND IN GUTTERS PROPERTY OR OTHER WORK UNDER CONSTRUCTION. THE FLOW OF ALL SEWERS, ALONG THE SIDES, OR ACROSS THE WORK, SHALL BE ADEQUATELY MAINTAINED BY THE CONTRACTOR AT HIS OWN EXPENSE, BOTH TEMPORARILY AND PERMANENTLY AS REQUIRED, EXCEPT AS SPECIFICALLY PROVIDED FOR OTHERWISE.
- EXCAVATIONS FOR PIPING SHALL CONFORM TO LIMITS, DEPTHS AND MATERIALS SHOWN ON THE DRAWINGS AND TO GOVERNING CODES AND REGULATIONS.
- SHEETING, SHORING, OR BRACING AT ANY OPEN TRENCH SHALL BE PROVIDED BY THE CONTRACTOR. CONTRACTOR SHALL SUBMIT DESIGN TO THE GENERAL CONTRACTOR SEALED BY A REGISTERED ENGINEER.
- IN CUT AREAS LOCATED UNDER PAVEMENT AND FOUNDATIONS, CONTRACTOR SHALL SCARIFY EXISTING SOIL TO A MINIMUM DEPTH OF FOUR INCHES AND THEN RECOMPACT AS BACKFILL PER
- CONTRACTOR SHALL REMOVE EXISTING TOPSOIL FROM AREA TO RECEIVE PAVING AND FOUNDATION WORK UNLESS THESE AREAS ARE INDICATED TO RECEIVE MORE THAN THREE FEET OF FILL. IN NO CASE SHALL THE CONTRACTOR USE UNTREATED OR UNSTABILIZED TOPSOIL AS COMPACTED SUBGRADE MATERIAL UNDER PAVING OR FOUNDATION STRUCTURES. TOPSOIL SHALL BE STOCKPILED FOR RE-USE IN LANDSCAPE AREAS. APPROPRIATE SOIL CONSERVATION MEASURES
- SHALL BE TAKEN. IF IN THE OPINION OF THE GENERAL CONTRACTOR, UNSATISFACTORY SOIL MATERIALS EXIST ON THE SITE, THE CONTRACTOR SHALL REMOVE SUCH MATERIALS AFTER WRITTEN APPROVAL FROM THE GENERAL CONTRACTOR. THE CONTRACTOR SHALL REPLACE THESE UNSATISFACTORY SOILS WITH STRUCTURAL FILL APPROVED BY THE ENGINEER.
- IT SHALL BE THE RESPONSIBILITY OF THE CONTRACTOR TO PREVENT AIR AND WATER POLLUTION THROUGH DUST AND DIRT CONTROL TO THE SATISFACTION OF THE LOCAL MUNICIPALITY OR THEIR ENGINEER IN THE FOLLOWING AREAS:
 - 2. ANY HAUL ROADS LEADING TO OR AWAY FROM THE PROJECT THAT ARE USED BY THE CONTRACTOR. 3. TAKE ALL NECESSARY STEPS TO PREVENT SOIL ERODING ONTO ALL PAVED AREAS AND INTO ALL NATURAL WATER-COURSES, DITCHES, AND THE PUBLIC SEWER SYSTEM AND

NEIGHBORING LOTS.

1. IN THE STREETS, SIDEWALKS, AND DRIVES WITHIN THE LIMITS OF THE CONTRACT.

COMPLIANCE, INCLUDING RETESTING.

AREAS UNDER PAVING AND BUILDINGS SHALL BE ROLLED WITH A SHEEPS-FOOT ROLLER FOR SOILS CONTAINING CLAY OR SILT (I.E.: COHESIVE SOILS), AND WITH EITHER A 3-WHEEL 10-TON VIBRATORY ROLLER OR 7-TON TRACTOR FOR SAND AND GRAVEL SOILS (I.E.: COHESIONLESS SOILS). FILL WITH COHESIVE SOILS SHALL BE COMPACTED TO A DENSITY EQUAL TO 95% OF MODIFIED PROCTOR DENSITY AS DETERMINED BY ASTM D1557. FILL WITH COHESIONLESS SOILS SHALL BE COMPACTED TO A DENSITY EQUAL TO 65% OF RELATIVE DENSITY AS DETERMINED BY ASTM D2049 SEE ASPHALT PAVEMENT NOTES FOR ADDITIONAL REQUIREMENTS.


COHESIVE STRUCTURAL FILL SHALL BE COMPACTED TO 90% OF THE MODIFIED PROCTOR MAXIMUM DRY DENSITY. GRANULAR STRUCTURAL FILL SHALL BE COMPACTED TO 90% OF THE SAME STANDARD, EXCEPT FOR FINE SAND, WHICH SHALL BE COMPACTED TO 95% OF THE MODIFIED PROCTOR DRY DENSITY.

- THE GENERAL CONTRACTOR MAY EMPLOY AN INDEPENDENT TESTING LABORATORY TO MAKE ANY TEST OR INSPECTION TO SHOW COMPLIANCE WITH THESE SPECIFICATIONS. IF SUCH SPECIAL TESTING REVEALS A FAILURE OF THE WORK TO COMPLY WITH THE REQUIREMENTS OF THE CONTRACT DOCUMENTS, THEN THE CONTRACTOR SHALL BEAR ALL COSTS, OTHERWISE THE GENERAL CONTRACTOR SHALL BEAR SUCH COSTS NECESSARY TO BRING THE WORK INTO
- B. BEFORE COMPACTION, MOISTEN OR AERATE EACH LAYER OF BACKFILL AS NECESSARY TO PROVIDE OPTIMUM MOISTURE CONTENT.
- NO CINDERS, ASHES, SLAG, ORGANIC MATTER, OR RUBBISH WILL BE PERMITTED. FILL SHALL BE PLACED IN LAYERS NOT MORE THAN EIGHT (8) INCHES IN LOOSE DEPTH.
- CONTRACTOR SHALL NOT BACKFILL TRENCHES UNTIL ALL TESTING REQUIRED BY APPLICABLE CODES IS CONDUCTED AND APPROVED.
- POTABLE WATER PIPING SHALL BE LAID ON A 4" COMPACTED BEDDING OF CLEAN SAND. THE SAND BACKFILL SHALL CONTINUE TO A DEPTH OF 4" ABOVE THE TOP OF THE PIPE, OR TO A DEPTH REQUIRED BELOW FROST LEVEL PER LOCAL STANDARDS.
- BACKFILL MATERIAL SHALL BE FREE OF STONES LARGER THAN 3 INCHES IN DIAMETER. NON-CORROSIVE AND NON-ORGANIC IN NATURE. MATERIAL SHALL BE GRANULAR AND EXCLUDE ALL CINDERS, BUILDING MATERIALS, SLAG, WASTE AND RUBBISH. DO NOT USE FROZEN OR SEMI-FROZEN BACKFILL MATERIAL
- THE CONTRACTOR SHALL REMOVE ALL DEBRIS FROM LANDSCAPE AREAS TO A DEPTH OF TWO FEET AND THE BACKFILL WITH CLEAN SOIL. THESE AREAS SHALL BE BACKFILLED TO PROPOSED BOTTOM OF TOPSOIL GRADE.

UNIFORMLY COMPACT BACKFILL AND GRADE AREAS TO INDICATE SLOPE WITH A TOLERANCE OF 1/2 INCH ABOVE OR BELOW REQUIRED ELEVATION.

PROTECT NEWLY GRADED AREAS FROM TRAFFIC AND EROSION. REPAIR, REGRADE AND RECOMPACT GRADES IN SETTLED, ERODED AND RUTTED AREAS TO THE SPECIFIED TOLERANCE.

O O

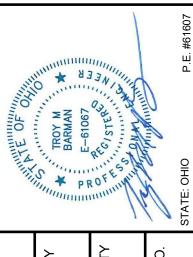

§ **≥** ≥ (5)

APPLICATION NO.

SCALE

SHEET

B. CONTRACTOR SHALL BE RESPONSIBLE FOR CONSTRUCTION STAKING

- C. THE LOCATION OF ALL EXISTING UTILITIES AS SHOWN ON THESE PLANS ARE APPROXIMATE. DETERMINATION OF THE EXACT LOCATION OF EXISTING UTILITIES SHALL BE THE RESPONSIBILITY OF THE CONTRACTOR. THE CONTRACTOR SHALL NOTIFY EACH REPRESENTATIVE UTILITY COMPANY PRIOR TO THE TIME OF CONSTRUCTION. THE CONTRACTOR SHALL BE RESPONSIBLE FOR ANY AND ALL DAMAGES TO EXISTING UTILITIES CAUSED BY HIS OPERATIONS. PROOF OF INSURANCE, CARRIER, LIMIT & DEDUCTIBLE REQUIRED.
- D. THERE ARE EXISTING NUMEROUS UNDERGROUND CONDUITS IN THE AREA. THE CONTRACTOR MUST OBTAIN THE SERVICE OF THE UTILITY PROTECTION SERVICE PRIOR TO ANY EXCAVATION, DEMOLITION OR CONSTRUCTION. TWO (2) WORKING DAYS BEFORE YOU DIG, CALL OHIO UTILITIES PROTECTION SERVICE (OUPS) AT 1-800-362-2764. NON-MEMBERS MUST BE CALLED DIRECTLY.
- E. ALL UTILITY COMPANIES, BOTH PUBLIC & PRIVATE, & THE LOCAL GOVERNING AGENCY SHALL BE NOTIFIED IN WRITING, AT LEAST SEVEN (7) WORKING DAYS PRIOR TO CONSTRUCTION.
- F. IN AREAS WHERE THE NEW CONSTRUCTION MIGHT BE IN CONFLICT WITH EXISTING UTILITIES, EITHER IN ALIGNMENT OR GRADE, EXCAVATION SHALL CAREFULLY BE DONE, BY HAND IF NECESSARY, TO EXPOSE THE EXISTING CABLES OR CONDUITS. IF THERE IS A CONFLICT, NOTIFY OWNER'S ENGINEER PRIOR TO MAKING ANY ADJUSTMENTS.
- G. REQUIRED PERMITS SHALL BE OBTAINED BY THE CONTRACTOR PRIOR TO COMMENCING ANY WORK.
- H. THE CONTRACTOR SHALL AT ALL TIMES DURING THE CONSTRUCTION OF THE WORK, AND AT ITS COMPLETION FOR FINAL INSPECTION, PROVIDE AND MAINTAIN AMPLE MEANS AND EQUIPMENT WITH WHICH TO PROPERLY REMOVE AND DISPOSE OF ALL WATER ENTERING THE EXCAVATION, OR OTHER PARTS OF THE WORK, AND KEEP SUCH EXCAVATIONS DRY UNTIL THE STRUCTURES TO BE BUILT THEREIN HAVE BEEN COMPLETED. ALL WATER PUMPED OR DRAINED FROM THE WORK HEREUNDER SHALL BE DISPOSED OF IN A SUITABLE MANNER WITHOUT DAMAGE TO ADJACENT PROPERTY OR OTHER WORK UNDER CONSTRUCTION, THE FLOW OF ALL SEWERS, DRAINS OR WATER—COURSES ENCOUNTERED ON THE WORK, AND IN GUTTERS ALONG THE SIDES OF OR ACROSS THE WORK, SHALL BE ADEQUATELY PROVIDED BY THE CONTRACTOR AT HIS OWN EXPENSE, BOTH TEMPORARILY AND PERMANENTLY AS REQUIRED, EXCEPT AS SPECIFICALLY PROVIDED FOR OTHERWISE.
- I. IT SHALL BE THE RESPONSIBILITY OF THE CONTRACTOR TO PREVENT AIR AND WATER POLLUTION THROUGH DUST AND DIRT CONTROL TO THE SATISFACTION OF THE TOWNSHIP AND COUNTY IN THE FOLLOWING AREAS:
- 1. IN THE STREET, SIDEWALKS AND DRIVES WITHIN THE LIMITS OF THE CONTRACT.
 - ANY HAUL ROADS LEADING TO OR AWAY FROM THE PROJECT THAT ARE USED BY THE CONTRACTOR.
 TAKE ALL NECESSARY STEPS TO PREVENT SOIL ERODING ONTO ALL PAVED AREAS AND INTO ALL NATURAL WATER—COURSES, DITCHES AND THE PUBLIC SEWER SYSTEM.
- J. WHERE ANY PAVEMENTS, DRIVEWAYS, PARKING AREAS, CURBS, GUTTERS, BERM STONE, SIDEWALKS, WATER LINES, GAS LINES, SEWERS, CATCH BASINS, DRAINS, FIELD TILE, CONDUIT PIPES, CABLES OR OTHER EXISTING FACILITIES ARE REMOVED OR OTHERWISE DISTURBED IN CARRYING OUT THIS CONTRACT, THEY SHALL BE REPLACED IN AS GOOD A CONDITION AS FOUND AT THE EXPENSE OF THE CONTRACTOR AND TO THE APPROVAL OF THE FACILITY'S OWNER OR THE COUNTY. AS APPLICABLE. ANY SUCH MATERIAL BROKEN OR DISTURBED TO SUCH AN EXTENT AS TO REQUIRE REPLACEMENT, SHALL BE REPLACED WITH NEW MATERIALS AT THE EXPENSE OF THE CONTRACTOR.
- K. TRAFFIC SHALL BE MAINTAINED ON NAVARRE AVE. AT ALL TIMES. ALL TRAFFIC CONTROL DEVICES AND MAINTENANCE OF TRAFFIC METHODS SHALL BE IN ACCORDANCE WITH THE OHIO MANUAL OF UNIFORM TRAFFIC CONTROL DEVICES (OMUTCD), LATEST EDITION IF NECESSITATED BY CONSTRUCTION. LANE CLOSURES MUST BY APPROVED BY THE TOWNSHIP AND/OT COUNTY A MINIMUM OF 7 DAYS IN ADVANCE.

PART 2 - MATERIALS 2.01 PIPE AND FITTINGS:

- 1. PIPE SHALL MEET THE FOLLOWING SPECIFICATIONS AND AS PERMITTED BY THE LOCAL JURISDICTION.
- FURNISH ELLS, TEES, WYES, COUPLINGS, END CAPS, AND OTHER FITTINGS OF THE SAME TYPE AND CLASS OF MATERIAL AS THE PIPE.
- 3. DRAINAGE STRUCTURES SUCH AS CATCH BASINS AND TRENCH DRAINS ARE SPECIFIED ON THE DRAWINGS.
- B. POLYVINYL CHLORIDE PIPE: ASTM D3034. STANDARD DIMENSION RATION (SDR) SHALL NOT EXCEED 35. JOINTS SHALL BE BELL AND SPIGOT TYPE WITH NEOPRENE RUBBER GASKETS CONFORMING TO ASTM D3212.
- C. CORRUGATED, SMOOTH INTERIOR HIGH DENSITY POLYETHYLENE (HDPE) PROFILE WALL PIPE: ASTM F2306; MATERIALS PER ASTM D3350 435400C; JOINTS SHALL BE INTEGRAL BELL AND GASKETED SPIGOT TYPE SOIL—TIGHT PER ASTM F477; FITTINGS PER ASTM F2306; COVER PER ASTM F2648 (AASHTO H—25 FOR MINIMUM); INSTALLATION PER ASTM D2321 AND MANUFACTURER'S RECOMMENDATIONS.
- D. REINFORCED CONCRETE PIPE: ASTM C76, CLASS III. JOINTS SHALL BE MODIFIED TONGUE AND GROOVE TYPE WITH RUBBER GASKETS COMPLYING WITH ASTM

E. POLYETHYLENE PIPE (SERVICE CONNECTIONS ONLY):1. PIPE: PE34544C, ASTM F714.

- A. CONTRACTOR SHALL DETERMINE PIPE DR BASED ON THE PROPOSED INSTALLATION, BUT IN NO CASE SHALL IT BE OTHER THAN THAT REQUIRED TO LIMIT TANGENTIAL SURFACE STRAIN TO 0.01, OR TO LIMIT MAXIMUM RING DEFLECTION TO 5 PERCENT, WHICHEVER YIELDS THE LOWER DR VALUE (THICKER—WALLED) PIPE.

 2. JOINTS: BUTT FUSION BETWEEN PLAIN ENDS OF POLYETHYLENE PIPE; RESTRAINED MECHANICAL FOR TRANSITION BETWEEN PIPE. FITTINGS. ETC.. OF DIFFERING MATERIALS AS APPROVED BY ENGINEER.
- 3. COUPLING: DESIGNED TO TRANSITION FROM IPS PIPE TO ASTM D3034 PIPE.

 A. MANUFACTURER: GPK PRODUCTS, FARGO, ND; 6 INCH GPK G332-0006, 8 INCH GPK G332-0008. OR

PART 3 - EXECUTIO

- 3.01 PIPE PREPARATION AND HANDLING:

 A. INSPECT ALL PIPE AND FITTINGS PRIOR TO LOWERING INTO TRENCH TO ENSURE NO CRACKED, BROKEN, OR OTHERWISE DEFECTIVE MATERIALS ARE BEING USED. CLEAN ENDS OF PIPE THOROUGHLY. REMOVE FOREIGN MATTER AND DIRT FROM INSIDE OF PIPE AND KEEP CLEAN DURING AND AFTER LAYING.
- B. USE PROPER IMPLEMENTS, TOOLS, AND FACILITIES FOR THE SAFE AND PROPER PROTECTION OF THE WORK. LOWER PIPE INTO THE TRENCH IN SUCH A MANNER AS TO AVOID ANY PHYSICAL DAMAGE TO THE PIPE. REMOVE ALL DAMAGED PIPE FROM THE JOB SITE. DO NOT DROP OR DUMP PIPE INTO TRENCHES UNDER ANY CIRCUMSTANCES.

3.02 INSTALLATION OF PIPE AND FITTINGS:

- A. INSTALL PIPE AND FITTINGS IN ACCORDANCE WITH GOVERNING AUTHORITIES HAVING JURISDICTION, EXCEPT WHERE MORE STRINGENT REQUIREMENTS ARE INDICATED IN THE CONTRACT DOCUMENTS.
- B. START PIPE LAYING BY PROCEEDING UPGRADE WITH SPIGOT ENDS POINTING IN DIRECTION OF FLOW. LAY PIPES UNIFORMLY TO LINE AND GRADE SO THAT FINISHED SEWER WILL PRESENT A UNIFORM BORE. ALL CHANGES OF DIRECTIONS SHALL BE MADE BY USE OF PROPER FITTINGS OR MANHOLES. NO JOINT DEFLECTION ALLOWED. INSTALL ALL SEWERS AT UNIFORM GRADE BETWEEN MANHOLES AND OTHER DRAINAGE STRUCTURES UNLESS SHOWN OTHERWISE.
- C. CHECK PIPE FOR ALIGNMENT AND GRADE AFTER JOINT HAS BEEN MADE. ENSURE PIPE BEDDING FORMS A CONTINUOUS AND UNIFORM SUPPORT FOR THE PIPE BARREL BETWEEN JOINTS. APPLY SUFFICIENT PRESSURE IN MAKING THE JOINT TO ASSURE THE JOINT IS SEATED AS DEFINED IN MANUFACTURER'S STANDARD INSTALLATION INSTRUCTIONS. PLACE SUFFICIENT PIPE COVER MATERIAL TO SECURE PIPE FROM MOVEMENT BEFORE NEXT JOINT IS INSTALLED TO ASSURE PROPER PIPE ALIGNMENT AND JOINT MAKEUP.
- D. PREVENT EXCAVATED OR OTHER FOREIGN MATERIALS FROM GETTING INTO THE PIPE DURING THE LAYING OPERATION.
 CLOSE AND BLOCK THE OPEN END OF THE LAST LAID SECTION OF PIPE TO PREVENT ENTRY OF FOREIGN MATERIAL OR
 CREEP OF THE GASKETED JOINTS WHEN LAYING OPERATIONS ARE NOT IN PROGRESS. ALSO CLOSE OFF PIPES WHICH ARE
 STUBBED OFF FOR CATCH BASIN CONSTRUCTION OR OTHER DRAINAGE STRUCTURES.
- E. EMPLOY SUCH MEANS AS WELL POINTING, DITCHING PUMPING OR BAILING TO PREVENT WATER FROM ENTERING THE TRENCH DURING THE LAYING OPERATION AND ALLOW FOR PROPER CONSTRUCTION OF THE BACKFILL IN PIPE ZONE. DO NOT LAY PIPE IN WATER.
- F. CLEAR DIRT AND OTHER SUPERFLUOUS MATERIAL FROM THE INTERIOR OF SEWERS AS THE WORK PROGRESSES. MAINTAIN A SWAB OR DRAG IN THE LINE AND PULL PAST EACH JOINT AS IT IS COMPLETED.
- G. BEDDING THE TRENCH SHALL BE EXCAVATED TO A DEPTH OF AT LEAST SIX (6) INCHES BELOW THE OUTSIDE BOTTOM OF THE PIPE BARREL (AND BELL) AND REPLACED WITH STONE TO FORM THE BEDDING FOR THE PIPE.
- H. AFTER THE PIPE HAS BEEN LAID AND THE JOINT MADE, THE FULL LENGTH OF EACH PIPE SHALL BE THOROUGHLY BEDDED BY TAMPING FINE EXCAVATED MATERIAL UNDER, AROUND AND OVER THE PIPE FOR A DISTANCE OF SIX (6) INCHES ABOVE THE TOP OF THE PIPE BARREL. THE MATERIAL SHALL BE PLACED IN LAYERS NOT EXCEEDING SIX (6) INCHES IN THICKNESS, AND SECURELY COMPACTED BY HAND OR MECHANICAL TAMPING O SECURE GOOD COMPACTION WHILE TAKING CARE NOT TO DISPLACE OR DAMAGE THE PIPE OR JOINTS.
- I. BACKFILL SHALL INCLUDE THE MATERIAL PLACED ABOVE THE TOP OF THE PIPE BARREL. TRENCHES COMING WITHIN 5 FT. OF EXISTING PAVEMENT OR STONED STREETS, ALLEYS, DRIVEWAYS AND PARKING AREAS OR WITHIN PROPOSED PAVEMENTS SHALL BE BACKFILLED WITH GRANULAR MATERIAL MEETING THE REQUIREMENTS OF O.D.O.T ITEM 204.03 AND 603.09 OR EQUIVALENT.
- J. THE CONTRACTOR SHALL BE REQUIRED TO SEED ALL GRASS AREAS DISTURBED BY OPEN TRENCH CONSTRUCTION OR ANY OPERATIONS CONNECTED WITH WORK ON THE PROJECT.
- K. BACKFILL FOR ALL CONDUITS AND STRUCTURES WITHIN FIVE FEET (5') OF EDGE OF PAVEMENT SHALL MEET O.D.O.T. SPEC. 603.08 MATERIAL WITH COMPACTION.
- L. ALL PRECAST CONCRETE MANHOLES SHALL CONFORM TO ASTM SPECIFICATIONS C-478 WITH C-443 JOINTS AND BOOTS.
- M. MANHOLE FRAME AND COVER SHALL BE SOLID AND WEIGH NO LESS THAN 475 LBS. AND SHALL PROVIDE 5" MIN. TO 12" MAX. OF ADJUSTING RING ON CONE SECTION.
- N. ROOF DRAINS, FOUNDATION DRAINS, AND ALL OTHER CLEAN WATER CONNECTIONS TO THE SANITARY SEWER ARE
- ALL CONDUITS SHALL CONFORM TO SPEC 3034 SDR 35 (CELL CLASSIFICATION 12454-B) BEFORE ANY SANITARY SEWER CONSTRUCTED USING PVC PIPE IS ACCEPTED AND PLACED INTO SERVICE. IT SHALL BE TESTED FOR RING DEFLECTION, WHICH SHALL NOT EXCEED FIVE PERCENT (5%). THE COST OF ALL TESTING MATERIAL, EQUIPMENT AND LABOR, AND ALL INCIDENTALS NECESSARY FOR MAKING ANY REQUIRED CORRECTIONS OR REPLACEMENTS SHALL BE AT THE EXPENSE OF THE CONTRACTOR.

SANITARY NOTES

- A. ALL CONSTRUCTION AND MATERIALS SHALL CONFORM TO THE STANDARDS OF THE OHIO DEPARTMENT OF TRANSPORTATION CURRENT ADDITION. SUBJECT TO ADDENDA BY THE LOCAL UTILITY AUTHORITY.
- B. ALL PVC SANITARY SEWER CONDUIT SHALL BE ASTM D-3034, SDR-35, WITH CELL CLASSIFICATION 12454-B OR APPROVED EQUAL.
- C. ALL SANITARY SEWER CONDUIT SHALL CONTAIN PREMIUM JOINTS PER ASTM D-3212.
- D. ROOF DRAINS, FOUNDATION DRAINS, AND OTHER CLEAN WATER CONNECTIONS TO THE SANITARY SEWER ARE PROHIBITED.
- E. GRANULAR MATERIAL SHALL CONFORM TO THE REQUIREMENTS OF ODOT ITEM 603.
- F. SEWER TESTING:
- 1. ALL RUNS OF THE SANITARY SEWER SHALL BE TESTED FOR EXFILITRATION OR INFILTRATION BY AN INDEPENDENT TESTING LABORATORY PER ASTM C969 (AIR TESTING ASTM F1417). IF ANY PART OF THE SYSTEM SHOWS EXCESSIVE INFILTRATION, IT SHALL BE THE CONTRACTORS RESPONSIBILITY TO PROVIDE TELEVISION INSPECTION AND TO MAKE ALL NECESSARY CORRECTIONS. THE COST OF ALL MATERIAL, EQUIPMENT, LABOR AND INCIDENTALS NECESSARY FOR PERFORMING THE TESTS AND MAKING ANY NECESSARY CORRECTIONS AND REPLACEMENTS SHALL BE THE CONTRACTOR'S RESPONSIBILITY. THE AIR TEST FOR THE TEST SECTION SHALL BE CONSIDERED ACCEPTABLE IF THE TIME ELAPSED FOR THE 1.0 PSI PRESSURE DROP IS EQUAL TO OR GREATER THAN THE TIME IN MINUTES INDICATED IN THE FOLLOWING

LENGTH OF MAIN TEST

		SPECIF	TED MINIM	IUM LENG	TH (L) SC	WN (MIN:	SEC)	
PIPE DIA.	100'	150'	200'	250	300'	350'	400'	450'
8" 10" 12" 15" 18" 21"	7: 34 9: 26 11: 20 14: 10 17: 00 19: 50	7: 34 9: 26 11: 20 14: 10 19: 13 26: 10	7: 34 9: 53 11: 24 17: 48 25: 38 35: 54	7: 34 9: 53 14: 15 22: 15 32: 03 43: 37	7: 36 11: 52 17: 05 26: 42 28: 27 52: 21	8: 52 13: 51 19: 56 31: 09 44: 52 61: 00	10: 08 15: 49 22: 47 35: 36 51: 16 69: 48	11: 24 17: 48 25: 38 40: 04 57: 41 78: 31

- THE AIR TEST SHALL BE UNACCEPTABLE IF THE ELAPSED TIME IS LESS THAN THE STATED PERIOD.
- 2. ALL NEW MANHOLES SHALL BE VACUUM TESTED PER ASTM C-1244.
- 3. PVC PIPE SECTIONS BETWEEN MANHOLES SHALL BE TESTED FOR RING DEFLECTION, WHICH SHALL NOT EXCEED FIVE PERCENT (5%). TESTING SHALL BE DONE AT LEAST 30 DAYS AFTER PIPE IS INSTALLED.
- 4. SHOULD ANY SECTION OF THE CONDUIT FAIL TO MEET THE TEST REQUIREMENTS. IT SHALL BE THE CONTRACTOR'S RESPONSIBILITY TO PROVIDE TELEVISION INSPECTION AND TO MAKE ALL NECESSARY CORRECTIONS. THE COST OF ALL MATERIALS, EQUIPMENT, LABOR, AND INCIDENTALS NECESSARY FOR PERFORMING THE TESTS AND MAKING ANY NECESSARY CORRECTIONS AND REPLACEMENTS SHALL BE THE CONTRACTOR'S RESPONSIBILITY.
- G. THE LOCATION OF ALL EXISTING UTILITIES AS SHOWN ON THESE PLANS ARE APPROXIMATE. DETERMINATION OF THE EXACT LOCATION OF EXISTING UTILITIES SHALL BE THE RESPONSIBILITY OF THE CONTRACTOR. THE CONTRACTOR SHALL NOTIFY EACH REPRESENTATIVE UTILITY COMPANY PRIOR TO THE TIME OF CONSTRUCTION. THE CONTRACTOR SHALL BE RESPONSIBLE FOR ANY AND ALL DAMAGES TO EXISTING UTILITIES CAUSED BY HIS OPERATIONS. PROOF OF INSURANCE, CARRIER, LIMIT & DEDUCTIBLE REQUIRED.
- H. THERE ARE EXISTING NUMEROUS UNDERGROUND CONDUITS IN THE AREA. THE CONTRACTOR MUST OBTAIN THE SERVICE OF THE UTILITY PROTECTION SERVICE PRIOR TO ANY EXCAVATION, DEMOLITION OR CONSTRUCTION. TWO (2) WORKING DAYS BEFORE YOU DIG, CALL OHIO UTILITIES PROTECTION SERVICE (OUPS) AT 1-800-362-2764. NON-MEMBERS MUST BE CALLED DIRECTLY.
- ALL UTILITY COMPANIES, BOTH PUBLIC & PRIVATE, & THE LOCAL GOVERNING AGENCY SHALL BE NOTIFIED IN WRITING, AT LEAST SEVEN (7) WORKING DAYS PRIOR TO CONSTRUCTION.
- J. IN AREAS WHERE THE NEW CONSTRUCTION MIGHT BE IN CONFLICT WITH EXISTING UTILITIES, EITHER IN ALIGNMENT OR GRADE, EXCAVATION SHALL CAREFULLY BE DONE, BY HAND IF NECESSARY, TO EXPOSE THE EXISTING CABLES OR CONDUITS. IF THERE IS A CONFLICT, NOTIFY OWNER'S ENGINEER PRIOR TO MAKING ANY ADJUSTMENTS.
- K. REQUIRED PERMITS SHALL BE OBTAINED BY THE CONTRACTOR PRIOR TO COMMENCING ANY WORK.
- L. SAFETY REQUIREMENTS THE CONTRACTOR SHALL AT ALL TIMES FOLLOW STATE AND LOCAL SAFETY REQUIREMENTS DURING CONSTRUCTION OF THIS PROJECT. SPECIAL CARE SHALL BE TAKEN DURING ALL TRENCHING OPERATIONS. SHEETING, BRACING, CRIBBING, ETC. SHALL BE INSTALLED AS REQUIRED TO PROVIDE MAXIMUM SAFETY TO THE WORKERS IN FULL COMPLIANCE WITH OCCUPATIONAL SAFETY AND HEALTH ADMINISTRATION (OSHA) REQUIREMENTS.
- M. THE CONTRACTOR SHALL AT ALL TIMES DURING THE CONSTRUCTION OF THE WORK, AND AT ITS COMPLETION FOR FINAL INSPECTION, PROVIDE AND MAINTAIN AMPLE MEANS AND EQUIPMENT WITH WHICH TO PROPERLY REMOVE AND DISPOSE OF ALL WATER ENTERING THE EXCAVATION, OR OTHER PARTS OF THE WORK, AND KEEP SUCH EXCAVATIONS DRY UNTIL THE STRUCTURES TO BE BUILT THEREIN HAVE BEEN COMPLETED. ALL WATER PUMPED OR DRAINED FROM THE WORK HEREUNDER SHALL BE DISPOSED OF IN A SUITABLE MANNER WITHOUT DAMAGE TO ADJACENT PROPERTY OR OTHER WORK UNDER CONSTRUCTION, THE FLOW OF ALL SEWERS, DRAINS OR WATER—COURSES ENCOUNTERED ON THE WORK, AND IN GUTTERS ALONG THE SIDES OF OR ACROSS THE WORK, SHALL BE ADEQUATELY PROVIDED BY THE CONTRACTOR AT HIS OWN EXPENSE, BOTH TEMPORARILY AND PERMANENTLY AS REQUIRED, EXCEPT AS SPECIFICALLY PROVIDED FOR OTHERWISE.
- N. IT SHALL BE THE RESPONSIBILITY OF THE CONTRACTOR TO PREVENT AIR AND WATER POLLUTION THROUGH DUST AND DIRT CONTROL TO THE SATISFACTION OF THE TOWNSHIP AND/OR COUNTY IN THE FOLLOWING AREAS:
 A. IN THE STREET AND DRIVES WITHIN THE LIMITS OF THE CONTRACT.
 B. ANY HAUL ROADS LEADING TO OR AWAY FROM THE PROJECT THAT ARE USED BY THE CONTRACTOR
 C. TAKE ALL NECESSARY STEPS TO PREVENT SOIL ERODING ONTO ALL PAVED AREAS AND INTO ALL NATURAL WATER—COURSES, DITCHES AND THE PUBLIC SEWER SYSTEM.
- WHERE ANY PAVEMENTS, DRIVEWAYS, PARKING AREAS, CURBS, GUTTERS, BERM STONE, SIDEWALKS, WATER LINES, GAS LINES, SEWERS, CATCH BASINS, DRAINS, FIELD TILE, CONDUIT PIPES, CABLES OR OTHER EXISTING FACILITIES ARE REMOVED OR OTHERWISE DISTURBED IN CARRYING OUT THIS CONTRACT, THEY SHALL BE REPLACED IN AS GOOD A CONDITION AS FOUND AT THE EXPENSE OF THE CONTRACTOR AND TO THE APPROVAL OF THE FACILITY'S OWNER, THE TOWNSHIP AND COUNTY. AS APPLICABLE. ANY SUCH MATERIAL BROKEN OR DISTURBED TO SUCH AN EXTENT AS TO REQUIRE REPLACEMENT, SHALL BE REPLACED WITH NEW MATERIALS AT THE EXPENSE OF THE CONTRACTOR.
- P. PRIOR TO FINAL ACCEPTANCE OF THE PROJECT BY THE OWNER, ALL STORM SEWERS SHALL BE THOROUGH CLEANED AND FLUSHED WITH WATER. ALL NEW INLETS AND MANHOLES CONSTRUCTED AS PART OF THE PROJECT SHALL BE FREE OF ALL FOREIGN MATTER AND IN A CLEAN CONDITION BEFORE THE PROJECT SHALL BE ACCEPTED BY THE OWNER.

MANHOLE FRAME AND COVERS:

ALL MANHOLE FRAME AND COVERS SHALL BE GRAY IRON CASTINGS CONFORMING TO ASTM A48, HEAVY DUTY SOLID COVER. BOTH THE UNDERSIDE OF THE LID AND THE UPPER SURFACE OF THE LEDGE UPON WHICH THE LID REST SHALL BE MACHINED SO AS TO PREVENT THE ROCKING OF THE LID ON ITS SUPPORTING SURFACE. CASTINGS SHALL BE CLEANED AND DIPPED IN COLD TAR PITCH VARNISH AT THE FACTORY.

MANHOLE FRAMES AND COVERS SHALL WEIGH NOT LESS THAN 375 POUNDS. THE FRAMES SHALL HAVE A CLEAR OPENING OF NO LESS THAN 24-INCHES IN DIAMETER AND A HEIGHT OF 7-INCHES. COVERS SHALL HAVE STRENGTHENING RIBS ON THE UNDERSIDE AND SHALL HAVE THE WORDS "SANITARY SEWER" CAST INTO THE TOP,

AFTER INSTALLATION, THE TOPS OF THE FRAMES AND COVERS SHALL BE PAINTED WITH ONE COAT OF ASPHALTUM PAINT.

FRAME AND COVER INSTALLATION:

THE MANHOLE FRAMES SHALL BE FIRMLY SET ON TOP OF THE ADJUSTING RING WITH A FULL LEVELING BED OF 1:1 CEMENT MORTAR. WHERE MANHOLES ARE LOCATED IN PAVED AREAS, THE SURFACE OF THE COVER SHALL BE MADE FLUSH WITH THE PAVEMENT SURFACE. IN UNPAVED STREETS AND ALLEYS AREAS, THE COVER SHALL BE SET NOT TO EXCEED 1—INCH ABOVE THE GROUND SURFACE. ON RIGHT—OF—WAY AND IN DITCHES, COVER ELEVATIONS SHALL BE AS APPROVED BY THE TOWNSHIP AND/OR COUNTY OR THEIR ENGINEER.

AFTER THE FRAME IS INSTALLED IN ITS FINAL POSITION, A MINIMUM 48-INCH DIAMETER STEEL CASTING RING SHALL BE PLACED, CENTERED AROUND THE FRAME, AND THE SPACE BETWEEN THE FRAME AND RING SHALL BE FILLED WITH CLASS I CONCRETE. THE STEEL CASING RING SHALL HAVE A HEIGHT SUCH THAT IT SHALL REST ON THE ECCENTRIC CANE SECTION AND EXTEND TO THE MID-POINT OF THE FRAME.

GENERAL WATER NOTES: SPECIFICATIONS FOR MATERIALS:

- 1. THE SPECIFICATIONS OF THE AMERICAN NATIONAL STANDARDS INSTITUTE (AMERICAN WATER WORKS ASSOCIATION) AND THE AMERICAN SOCIETY FOR TESTING AND MATERIALS HEREIN REFERRED TO, UNLESS OTHERWISE NOTED SHALL BE THE LATEST SPECIFICATIONS OF THE RESPECTIVE ORGANIZATIONS AND MANUFACTURED IN THE UNITED STATES.
- 2. PIPE SHALL BE ANSI-A21.51 (AWWA C151) DUCTILE CAST IRON WITH A MINIMUM WALL THICKNESS MEETING THE REQUIREMENTS OF ANSI A21.51, TABLE 51.4 (THICKNESS CLASS 52 FOR 4 INCH THROUGH 12 INCH) AND WRAPPED PER PRESSURE PIPE AND FITTTINGS SPECIFICATION NUMBER 3. ALL PIPE SHALL BE WRAPPED IN 8 MM POLYWRAP.
- 3. FITTINGS SHALL BE GRAY OR DUCTILE CAST IRON CONFORMING TO ANSI-A21.4 (AWWA C110) WITH A MINIMUM CLASS OF 250 OR ANSI-A21.53 (AWWA C153) AND HAVE MECHANICAL JOINT ENDS AS SPECIFIED IN ANSI-A21.11 (AWWA C111) RESTRAINT TYPE.
- 4. ALL PIPE AND FITTINGS SHALL HAVE A CEMENT MORTAR LINING, CONFORMING TO ANSI-A21.4 (AWWA C104) AND PETROLEUM-ASPHALTIC OUTSIDE COATING.
- 5. ALL DUCTILE IRON PIPE AND FITTINGS SHALL BE LAID WITH A POLYETHYLENE ENCASEMENT. PIPE AND POLYETHYLENE ENCASEMENT SHALL BE INSTALLED IN ACCORDANCE WITH ANSI—A21.5 (AWWA C105).
- 6. ALL VALVES SHALL BE OPEN LEFT VALVES.
- 7. HYDRANTS SHALL BE LIMITED TO AMERICAN DARLING, KENNEDY OR MUELLER, MEETING AWWA SPECIFICATION C502 AND MEETING THE LOCAL FIRE DEPARTMENT SPECIFICATIONS AND STANDARDS. ALL HYDRANTS SHALL HAVE A HARRINGTON STORTZ STYLE 5" STEAMER CONNECTION ADAPTER. INSTALLATION AND PRESSURE TESTING SHALL BE AS PER AWWA C-600. DISINFECTION SHALL MEET OR EXCEED AWWA-C651.
- 8. NO DEVIATIONS FROM THE ABOVE SPECIFICATIONS WILL BE PERMITTED.
 DETAILED SPECIFICATIONS CAN BE OBTAINED FROM THE WATER DEPARTMENT.

NOTE: THE OHIO ENVIRONMENTAL PROTECTION AGENCY REQUIRES A CONFORMANCE TO THE 2003 EDITION OF "TEN STATES STANDARDS". THIS STANDARD SHALL BE EQUALED OR EXCEEDED FOR WATER LINES. SPECIAL ATTENTION SHALL BE GIVEN TO THE FOLLOWING SECTIONS OF PART 8:

MATERIALS CONFORM TO AWWA STANDARDS
MINIMUM 6" DIA. FIRE PROTECTION
MINIMUM 5' GROUND COVER
PRESSURE TESTING AWWA C-600 OR N.F.P.A. 24 *
DISINFECTION AWWA C-651 *
10' HORIZONTAL SEPARATION WATER MAIN/SEWER
18" VERTICAL SEPARATION WATER MAIN/SEWER
NO ENTRY AND/OR CONTACT WITH SEWER MANHOLE

ANY DEVIATION FROM THE ABOVE WILL NOT BE PERMITTED UNLESS SPECIFICALLY INCLUDED IN THE GENERAL NOTES OR OTHERWISE SHOWN ON THESE PLANS

<u>*NOTE:</u> IT SHALL BE THE CONTRACTOR'S RESPONSIBILITY TO PERFORM THIS TEST PROPERLY AND THE RESPONSIBILITY FOR ADEQUATE SUPERVISION AND APPROVAL RESTS WITH THE APPROPRIATE GOVERNMENTAL AGENCY.

- 9. ALL PIPES, FITTINGS, ETC. SHALL BE APPROPRIATELY MARKED FOR PURPOSES OF IDENTIFICATION.
- 10. THE MANUFACTURER SHALL FURNISH AN AFFIDAVIT INDICATING THAT THE PIPE FITTINGS AND APPURTENANCES HAVE BEEN MANUFACTURED AND TESTED IN ACCORDANCE WITH ALL REQUIREMENTS OF THE APPLICABLE REFERENCED STANDARDS. A COPY OF THE AFFIDAVIT, INDICATING THE PROJECT ON WHICH THE MATERIAL IS TO BE USED, SHALL BE FORWARDED TO THE OWNER OR THEIR ENGINEER.
- 11. REINFORCED CONCRETE ANCHORS AND SUPPORTS (THRUST BLOCKS) SHALL BE PROVIDED AT ALL FITTINGS, VALVES OR CHANGES IN DIRECTION OF THE PIPE. THEY SHALL BE CONSTRUCTED OF CLASS 1 CONCRETE AND SHALL BE PLACED AGAINST FIRM UNDISTURBED SOIL. ALL PLUGS OR CAPS SHALL BE SECURELY STRAPPED OR BLOCKED.
- 12. ALL PIPE INTERIORS SHALL BE CLEANED BEFORE LAYING AND SHALL BE CLEAN THEREAFTER. AFTER A MAIN HAS BEEN COMPLETED IT SHALL BE DISINFECTED IN ACCORDANCE WITH AWWA C651-86, "DISINFECTING WATER MAINS", USING THE TABLET OR CONTINUOUS FEED METHOD.
- 13. TRENCHES WITHIN FIVE (5) FEET OF THE EDGE OF OR UNDER EXISTING OR PROPOSED PAVEMENT SHALL BE BACKFILLED WITH APPROVED GRANULAR MATERIAL TO SUBGRADE. GRANULAR MATERIAL SHALL MEET THE GRADING REQUIREMENTS OF ITEM 304, O.D.O.T. SPECIFICATION. PIPE OUTSIDE THE LIMITS OF FIVE (5) FEET FROM THE EDGE OF THE EXISTING OR PROPOSED PAVEMENT SHALL BE BACKFILLED WITH SUITABLE EXCAVATED MATERIAL.

Verdan Verdig Eppe STBEET

O

APPLICATION NO.

SCALE

SHEET

OF 10

1.02 SUMMARY A. SITE DEMOLITION WORK SHALL INCLUDE THE FOLLOWING:

1. UNLESS PROVIDED BY THE OWNER THE CONTRACTOR SHALL CONDUCT INSPECTIONS OF THE SITE AND BUILDING(S) FOR HAZARDOUS MATERIALS AS REQUIRED BY STATE, LOCAL AND FEDERAL LAWS AND CODES. CONTRACTOR SHALL ÓBTAIN ALL PERMITS AS NECESSARY FOR REMOVAL AND DISPOSAL OF HAZARDOUS MATERIALS. HAZARDOUS MATERIALS SHALL BE REMOVED AND DISPOSED OF PER FEDERAL, STATE AND LOCAL REQUIREMENTS.

EROSION CONTROL INSTALLATION AS REQUIRED BY LOCAL, STATE AND FEDERAL REGULATIONS.
 MAINTENANCE OF VEHICULAR AND PEDESTRIAN TRAFFIC PER CITY, COUNTY AND STATE REGULATIONS.

4. PERIMETER CONSTRUCTION FENCE (6' HIGH CHAIN LINK MINIMUM OR AS REQUIRED BY LOCAL, STATE AND FEDERAL REGULATIONS) INSTALLATION AND MAINTENANCE. CONTRACTOR SHALL PROVIDE THE OWNER WITH A KEY TO THE SITE.

5. DEMOLITION, REMOVAL AND BACKFILLING TO GRADE OF ALL (EXCEPT AS NOTED ON THE PLANS) EXISTING IMPROVEMENTS WITHIN THE DEMOLITION AREA

6. PAY ALL FEES ASSOCIATED WITH THE DEMOLITION PERMIT, PAY ALL COSTS TO UTILITY COMPANIES RELATING TO CAPPING AND REMOVING SERVICE. PROVIDE ALL REQUIRED DOCUMENTATION FOR PERMITS AND UTILITY KILLS. 7. BACKFILL WITH COMPACTED ENGINEERED MATERIAL (ODOT 304 OR APPROVED EQUAL) TO FILL IN LOW AREAS CREATED BY DEMOLITION AND SITE IS GRADED TO DRAIN

CAREFUL REMOVAL FOR SALVAGE AND RE-USE, CRATING, PROTECTION AND STORE HISTORIC BUILDING ELEMENTS UNTIL READY C. PROCEDURES AND MEANS OF WORK SHOWN HEREON ARE MINIMUM STANDARDS, CONTRACTOR SHALL COMPLY WITH ALL FEDERAL, STATE AND LOCAL REGULATIONS REGARDING DEMOLITION, DISPOSAL ALONG WITH SAFETY FOR WORKERS AND THE

DEFINITIONS

REMOVE: DETACH ITEMS FROM EXISTING CONSTRUCTION AND LEGALLY DISPOSE OF THEM OFF-SITE UNLESS INDICATED TO BE REMOVED AND SALVAGED OR RECYCLED.

REMOVE AND SALVAGE: DETACH ITEMS FROM EXISTING CONSTRUCTION AND DELIVER THEM TO OWNER. EXISTING TO REMAIN: EXISTING ITEMS OF CONSTRUCTION THAT ARE NOT TO BE REMOVED AND THAT ARE NOT OTHERWISE

INDICATED TO BE REMOVED, REMOVED AND SALVAGED, OR RECYCLED.

1.04 MATERIAL OWNERSHIP A. HISTORIC ITEMS, RELICS, AND SIMILAR OBJECTS INCLUDING, BUT NOT LIMITED TO, CORNERSTONES AND THEIR CONTENTS, COMMEMORATIVE PLAQUES AND TABLETS, AND OTHER ITEMS OF INTEREST OR VALUE TO OWNER THAT MAY BE ENCOUNTERED DURING BUILDING DEMOLITION REMAIN OWNER'S PROPERTY. CAREFULLY REMOVE AND SALVAGE EACH ITEM OR OBJECT IN A MANNER TO PREVENT DAMAGE AND DELIVER PROMPTLY TO OWNER. WHEN IN DOUBT CHECK WITH OWNER BEFORE PROCEEDING WITH REMOVAL.

A. QUALIFICATION DATA: FOR DEMOLITION FIRM. PROPOSED DUST-CONTROL AND NOISE-CONTROL MEASURES: SUBMIT STATEMENT OR DRAWING THAT INDICATES THE MEASURES PROPOSED FOR USE, PROPOSED LOCATIONS, AND PROPOSED TIME FRAME FOR THEIR OPERATION. IDENTIFY OPTIONS IF PROPOSED MEASURES ARE LATER DETERMINED TO BE INADEQUATE.

SCHEDULE OF BUILDING DEMOLITION ACTIVITIES: INDICATE THE FOLLOWING: 1. DETAILED SEQUENCE OF DEMOLITION AND REMOVAL WORK, WITH STARTING AND ENDING DATES FOR EACH ACTIVITY.

. INTERRUPTION OF UTILITY SERVICES. 3. COORDINATION FOR SHUTOFF, CAPPING, AND CONTINUATION OF UTILITY SERVICES.

4. LOCATIONS OF TEMPORARY PROTECTION. INVENTORY: AFTER BUILDING DEMOLITION IS COMPLETE, SUBMIT A LIST OF ITEMS THAT HAVE BEEN REMOVED AND SALVAGED. PROVIDE DRAWING INDICATING WHERE ITEMS ARE STOCKPILED AND IDENTIFICATION OF EACH CRATE. I. SALVAGE FOR OWNER'S USE: NOT APPLICABLE

PREDEMOLITON PHOTOGRAPHS: CAREFULLY SHOW EXTERIOR, EXISTING CONDITIONS FROM DIFFERENT VANTAGE POINTS OF ADJOINING SITE IMPROVEMENTS INCLUDING THOSE ACROSS THE STREETS, INCLUDING FINISH SURFACES THAT MIGHT BE MISCONSTRUED AS DAMAGE CAUSED BY BUILDING DEMOLITION OPERATIONS.

1.06 QUALITY ASSURANCE
A. DEMOLITION FIRM QUALIFICATIONS: AN EXPERIENCED FIRM THAT HAS SPECIALIZED IN DEMOLITION WORK SIMILAR IN MATERIAL AND EXTENT TO THAT INDICATED FOR THIS PROJECT.

REGULATORY REQUIREMENTS: COMPLY WITH COVERING EPA NOTIFICATION REGULATIONS BEFORE BEGINNING DEMOLITION. COMPLY WITH HAULING AND DISPOSAL REGULATIONS OF AUTHORITIES HAVING JURISDICTION. COMPLY WITH INDUSTRY SAFETY ORDERS OF THE STATE OF OHIO AND OF OSHA.

STANDARDS: COMPLY WITH ANSI A10.6 AND NFPA 241 AND ALL FEDERAL, STATE AND LOCAL REGULATUIONS UTILITIES: COMPLY WITH REGULATIONS BY LOCAL UTILITIES FOR SHUT-OFF, CAPPING AND REMOVAL OF SERVICE LINES.

PREDEMOLITION CONFERENCE: DEMOLITION CONTRACTOR TO CONDUCT CONFERENCE AT PROJECT SITE WITH OWNER, ARCHITECT AND ENGINEER BEFORE PROCEEDING.

. INSPECT AND DISCUSS CONDITION OF CONSTRUCTION TO BE DEMOLISHED. . REVIEW TRAFFIC PATTERNS AND CONTROLS.

3. REVIEW AND FINALIZE BUILDING DEMOLITION SCHEDULE AND VERIFY AVAILABILITY OF DEMOLITION PERSONNEL, EQUIPMENT, AND FACILITIES NEEDED TO MAKE PROGRESS AND AVOID DELAYS.

4. REVIEW AND FINALIZE PROTECTION REQUIREMENTS

5. REVIEW PROCEDURE AND SCHEDULES FOR UTILITY REMOVALS. 6. REVIEW SALVAGE PROCEDURES, PACKAGING, TRANSPORTING AND STORAGE SPACES.

OWNER ASSUMES NO RESPONSIBILITY FOR BUILDINGS TO BE DEMOLISHED. 1. CONDITIONS EXISTING AT TIME OF INSPECTION FOR BIDDING PURPOSE WILL BE MAINTAINED BY OWNER AS FAR AS

BEFORE BUILDING DEMOLITION, THE OWNER OR OTHER CONTRACTOR WILL REMOVE ITEMS LISTED BELOW:

1. NOT APPLICABLE C. HAZARDOUS MATERIALS:

1. CONTRACTOR TO DETERMINE HAZARDOUS MATERIALS ON SITE AND THE PROPER DEMOLITION PRACTICES REQUIRED TO

HANDLE AND DISPOSE OF THE MATERIALS. 2. CONTRACTOR TO DETERMINE EXISTING LEAD PAINT LEVEL WITHIN PROPOSED DEMOLITION SITE AND AN APPROPRIATE LEVEL OF LEAD AWARENESS TRAINING PER OSHA REGULATIONS. DEMOLITION CONTRACTOR SHALL TAKE APPROPRIATE MEASURES REGARDING THIS BIOLOGICAL HAZARD.

STORAGE OR SALE OF REMOVED ITEMS OR MATERIALS ON-SITE IS NOT PERMITTED

CONTRACTOR SHALL NOTIFY ENGINEER AND OWNER A MINIMUM OF 2 WEEKS PRIOR TO COMMENCING WORK OF REQUIRED OUTSIDE OF THE DEMOLITION LIMITS THAT NEED TO BE FENCED OFF FOR SAFETY OF THE DEMOLITION WORK. CONTRACTOR SHALL FENCE AREA OFF AS NECESSARY AND REMOVE FENCE WHEN AREA IS NO LONGER NEEDED.

PART 2 - PRODUCTS 2.01 SOIL MATERIALS

GENERAL: PROVIDE BORROW SOIL MATERIALS WHEN SUFFICIENT SATISFACTORY SOIL MATERIALS ARE NOT AVAILABLE FROM

SATISFACTORY SOILS: FILL TO CONSIST OF ANY NON-ORGANIC OR NON-EXPANSIVE SOILS. SOILS FREE OF ORGANIC MATTER, EXCESSIVE MOISTURE, CONTAMINATION AND ROCK OR STONE FRAGMENTS WITH TOP SIZE OF 3" MAY BE UTILIZED IN THE FILL. UNSATISFACTORY SOILS: SOIL CLASSIFICATION GROUPS GC, SC, CL, ML, OL, CH, MH, OH, AND PT ACCORDING TO ASTM D

2487, OR A COMBINATION OF THESE GROUPS. 1. UNSATISFACTORY SOILS ALSO INCLUDE SATISFACTORY SOILS NOT MAINTAINED WITHIN 2 PERCENT OF OPTIMUM MOISTURE CONTENT AT TIME OF COMPACTION.

D. ENGINEERED FILL: FILL SHALL BE IMPORTED BORROW OR QUARRY PROCESSED AGGREGATE, ODOT 304 LIMESTONE SCREENINGS OR BANK RUN GRAVEL WITH SIMILAR (304) GRADATION. CRUSHED CONCRETE SHALL NOT BE USED. 1. ALL BACKFILL TO BE STRUCTURAL (TO MINUS ONE FOOT OF PROPOSED GRADES) TO ALLOW FOR FUTURE BUILDABLE SITE. TOP ONE FOOT TO CONSIST OF NINE INCHES OF CLEAN SOIL AND THREE INCHES OF TOPSOIL.

PART 3 - EXECUTION

3.01 EXAMINATION A. SURVEY EXISTING CONDITIONS AND CORRELATE WITH REQUIREMENTS INDICATED TO DETERMINE EXTENT OF BUILDING DEMOLITION REQUIRED. STUDY METHOD FOR SAFE REMOVAL OF SALVAGE ITEMS AS REQUIRED.

B. REVIEW PROJECT DOCUMENTS OF EXISTING CONSTRUCTION. OWNER DOES NOT GUARANTEE THAT EXISTING CONDITIONS ARE THE SAME AS THOSE INDICATED IN PROJECT DOCUMENTS.

C. THE CONTRACTOR SHALL PERFORM AN ENGINEERING SURVEY OF CONDITION OF BUILDING TO DETERMINE WHETHER REMOVING ANY ELEMENT MIGHT RESULT IN STRUCTURAL DEFICIENCY OR UNPLANNED COLLAPSE OF ANY PORTION OF STRUCTURE DURING BUILDING DEMOLITION OPERATIONS.

D. VERIFY THAT HAZARDOUS MATERIALS HANDLING AND REQUIRED DEMOLITION PROCEDURES BEFORE PROCEEDING WITH BUILDING

E. INVENTORY AND RECORD THE CONDITION OF ITEMS TO BE REMOVED AND SALVAGED. ITEMS NOT LISTED HEREIN AND REQUIRED BY OWNER TO BE SALVAGED SHALL BE TAGGED BY OWNER PRIOR TO DEMOLITION.

3.02 PREPARATION

A. EXISTING UTILITIES: LOCATE, IDENTIFY, DISCONNECT, AND SEAL OR CAP OFF INDICATED UTILITIES SERVING BUILDINGS AND STRUCTURES TO BE DEMOLISHED. ARRANGE TO SHUT OFF INDICATED UTILITIES WITH UTILITY COMPANIES AND FOLLOW ALL COMPANY OR AGENCY

2. IF UTILITY SERVICES ARE REQUIRED TO BE REMOVED, RELOCATED, OR ABANDONED, BEFORE PROCEEDING WITH BUILDING DEMOLITION PROVIDE TEMPORARY UTILITIES THAT BYPASS BUILDINGS AND STRUCTURES TO BE DEMOLISHED AND THAT

MAINTAIN CONTINUITY OF SERVICES TO OTHER BUILDINGS AND STRUCTURES. ALL UNDERGROUND UTILITIES SHALL BE COMPLETELY REMOVED. ALL WIRE REMOVED FROM CONDUIT 4. DO NOT START DEMOLITION WORK UNTIL UTILITY DISCONNECTING AND SEALING HAVE BEEN COMPLETED AND VERIFIED IN

B. TEMPORARY SHORING: PROVIDE AND MAINTAIN INTERIOR AND EXTERIOR SHORING, BRACING, OR STRUCTURAL SUPPORT TO PRESERVE STABILITY AND PREVENT UNEXPECTED MOVEMENT OR COLLAPSE OF BUILDING BEING DEMOLISHED. 1. STRENGTHEN OR ADD NEW SUPPORTS WHEN REQUIRED DURING PROGRESS OF DEMOLITION

C. PEST CONTROL: BEFORE DEMOLITION WORK IS STARTED, RETAIN A LOCAL EXTERMINATOR OR PEST-CONTROL COMPANY TO RECOMMEND PRACTICES TO MINIMIZE ATTRACTION AND HARBORING OF RODENTS, ROACHES, AND OTHER PESTS AND THEIR RESIDUES. ENGAGE THIS PEST—CONTROL SERVICE TO PERFORM EXTERMINATION AND CONTROL PROCEDURES BEFORE START UP AND AS NEEDED DURING DEMOLITION SO PROJECT WILL BE FREE OF PESTS AND THEIR RESIDUES TO DEMOLITION COMPLETION. PERFORM CONTROL OPERATIONS LAWFULLY, USING ENVIRONMENTALLY SAFE MATERIALS.

D. SITE ENCLOSURE FENCE: THE DEMOLITION CONTRACTOR SHALL INSTALL A 6' TEMPORARY ENCLOSURE FENCE WITH APPROPRIATELY SIZED, LOCKABLE, ACCESS GATES. THE TEMPORARY FENCE TO BE ERECTED AROUND LIMITS OF DEMOLITION, OR AS REQUIRED. PROVIDE SIGNAGE AS NEEDED INDICATING SIDEWALK IS CLOSED AND DIRECTING PEDESTRIANS TO OPPOSITE SIDEWALK. DEMOLITION CONTRACTOR SHALL INSPECT AND MAINTAIN TEMPORARY FENCING WHILE UNDER CONTRACT WITH THE 1. MAINTAIN SECURITY BY LIMITING NUMBER OF KEYS AND RESTRICTING DISTRIBUTION TO AUTHORIZED PERSONNEL.

E. STORMWATER CONTROL: PROVIDE PROPERLY INSTALLED SILT FENCING BARRIERS IN AND AROUND EXCAVATIONS AND SUBGRADE DEMOLITION, SUFFICIENT TO PREVENT RUNOFF OF DEBRIS IN STORMWATER FROM HEAVY RAINS. INSTALL NEXT TO BUT SEPARATE FROM PERIMETER FENCING.

A. EXISTING FACILITIES: PROTECT ADJACENT STREETS, WALKWAYS, FENCES AND OTHER BUILDING FACILITIES DURING DEMOLITION

PROVIDE THE OWNER WITH ONE SET OF KEYS FOR THE CONTRACTOR'S PADLOCKS.

B. EXISTING UTILITIES: MAINTAIN UTILITY SERVICES INDICATED TO REMAIN AND PROTECT THEM AGAINST DAMAGE DURING DEMOLITION OPERATIONS. 1. DO NOT INTERRUPT EXISTING UTILITIES SERVING ADJACENT PROPERTIES UNLESS AUTHORIZED IN WRITING BY OWNER AND AUTHORITIES HAVING JURISDICTION. PROTECT EXISTING STORM, SANITARY AND WATER AND UTILITY LINES, INCLUDING MANHOLE STRUCTURES AND VALVES AND STRUCTURES WITHIN THE ADJACENT RIGHT-OF-WAY, ALLEY AND/OR

UTILITIES THAT ARE TO REMAIN DURING DEMOLITION OPERATIONS. 2. COMPLY WITH OEPA AND LOCAL JURISDICTION REQUIREMENTS FOR EROSION AND SEDIMENT CONTROL FOR ALL EXISTING STORM CATCH BASINS THAT REMAIN LOCATED ON OR ADJACENT TO SITE THAT MAY BE AFFECTED BY DEMOLITION

EASEMENTS AS APPLICABLE DURING DEMOLITION OPERATIONS. IMMEDIATELY REPAIR ANY DAMAGE TO THESE EXISTING

OPERATIONS. MAINTAIN CONTROLS DURING ALL DEMOLITION OPERATIONS. 3. PROVIDE TEMPORARY SERVICES DURING INTERRUPTIONS TO EXISTING UTILITIES, AS ACCEPTABLE TO OWNER AND TO AUTHORITIES HAVING JURISDICTION.

C. TEMPORARY PROTECTION: ERECT TEMPORARY PROTECTION, SUCH AS WALKS, FENCES, RAILINGS, WHERE REQUIRED BY AUTHORITIES HAVING JURISDICTION OR IF INDICATED.

PROTECT EXISTING SITE IMPROVEMENTS, APPURTENANCES, AND LANDSCAPING TO REMAIN. ERECT A PLAINLY VISIBLE FENCE AROUND DRIP LINE OF INDIVIDUAL TREES OR AROUND PERIMETER DRIP LINE OF GROUPS

3. PROVIDE TEMPORARY BARRICADES AND OTHER PROTECTION REQUIRED TO PREVENT INJURY TO PEOPLE AND DAMAGE TO

ADJACENT BUILDINGS AND FACILITIES TO REMAIN. 4. PROVIDE PROTECTION TO ENSURE SAFE PASSAGE OF PEDESTRIANS AND VEHICLES AROUND DEMOLITION AREA.

3.04 DEMOLITION, GENERAL

GENERAL: DEMOLISH INDICATED BUILDING AND SITE IMPROVEMENTS COMPLETELY. USE METHODS REQUIRED TO COMPLETE THE WORK WITHIN LIMITATIONS OF GOVERNING REGULATIONS AND AS FOLLOWS: 1. DO NOT USE CUTTING TORCHES UNTIL WORK AREA IS CLEARED OF FLAMMABLE MATERIALS. MAINTAIN PORTABLE

FIRE-SUPPRESSION DEVICES DURING FLAME-CUTTING OPERATIONS. MAINTAIN ADEQUATE VENTILATION WHEN USING CUTTING TORCHES.

LOCATE BUILDING DEMOLITION EQUIPMENT AND REMOVE DEBRIS AND MATERIALS SO AS NOT TO IMPOSE EXCESSIVE LOADS ON SUPPORTING WALLS, FLOORS, OR FRAMING.

B. ENGINEERING SURVEYS: PERFORM SURVEYS AS THE WORK PROGRESSES TO DETECT HAZARDS THAT MAY RESULT FROM BUILDING DEMOLITION ACTIVITIES.

SITE ACCESS AND TEMPORARY CONTROLS: CONDUCT BUILDING DEMOLITION AND DEBRIS-REMOVAL OPERATIONS TO ENSURE MINIMUM INTERFERENCE WITH ROADS, STREETS, WALKS, WALKWAYS, AND OTHER ADJACENT OCCUPIED AND USED FACILITIES. DO NOT CLOSE OR OBSTRUCT STREETS, WALKS, WALKWAYS, OR OTHER ADJACENT OCCUPIED OR USED FACILITIES WITHOUT PERMISSION FROM OWNER AND AUTHORITIES HAVING JURISDICTION. NOTIFY LOCAL JURISDICTION, IN WRITING, WITH ADVANCE NOTICE AS REQUIRED BY THE LOCAL AUTHORITY OF REQUIRED LANE CLOSURES AND 2 WEEKS IN ADVANCE OF REQUIRED STREET CLOSURES. PROVIDE ALTERNATE ROUTES AROUND CLOSED OR OBSTRUCTED TRAFFIC WAYS IF REQUIRED BY AUTHORITIES HAVING JURISDICTION.

USE WATER MIST AND OTHER SUITABLE METHODS TO LIMIT SPREAD OF DUST AND DIRT DURING BOTH THE DEMOLITION OPERATIONS AND THE BACKFILL AND GRADING OPERATIONS. COMPLY WITH GOVERNING ENVIROMENTAL-PROTECTION REGULATIONS. DO NOT USE WATER WHEN IT MAY DAMAGE ADJACENT CONSTRUCTION OR CREATE HAZARDOUS OR OBJECTIONABLE CONDITIONS, SUCH AS ICE, FLOODING, AND POLLUTION. CONTRACTOR TO MAKE ARRAIGNMENTS WITH LOCAL WATER UTILITY OWNER FOR USE OF WATER HYDRANT, CONTRACTOR SHALL BE RESPONSIBLE FOR ALL FEES ASSOCIATED WITH HYDRANT WATER USE.

3. IF WATER MIST OR OTHER DUST CONTROL MEASURES FAIL TO KEEP DUST CONTAINED DUE TO WIND AND WIND GUSTS, CEASE DUST PRODUCING DEMOLITION OPERATIONS UNTIL FAVORABLE WIND CONDITIONS ARE EXPECTED.

KEEP ADJACENT STREETS FREE OF MUD, DIRT AND DEBRIS 5. PROTECT PAVEMENTS CURBS AND WALKS FROM DAMAGE BY TRUCKS AND DEMOLITION EQUIPMENT/ACTIVITY.

PROCEED WITH DEMOLITION OF STRUCTURAL FRAMING MEMBERS SYSTEMATICALLY, FROM HIGHER TO LOWER LEVEL. COMPLETE BUILDING DEMOLITION OPERATIONS ABOVE EACH FLOOR OR TIER BEFORE DISTURBING SUPPORTING MEMBERS ON THE NEXT

B. REMOVE DEBRIS FROM ELEVATED PORTIONS BY CHUTE, HOIST, OR OTHER DEVICE THAT WILL CONVEY DEBRIS TO GRADE LEVEL IN A CONTROLLED DESCENT.

C. CONCRETE: CUT CONCRETE FULL DEPTH AT JUNCTURES WITH CONSTRUCTION INDICATED TO REMAIN, USING POWER-DRIVEN SAW. THEN REMOVE CONCRETE BETWEEN SAW CUTS.

D. MASONRY: CUT MASONRY AT JUNCTURES WITH CONSTRUCTION INDICATED TO REMAIN, USING POWER-DRIVEN SAW, THEN REMOVE MASONRY BETWEEN SAW CUTS.

E. CONCRETE SLABS-ON-GRADE: IF PORTION IS INDICATED TO REMAIN, SAW-CUT PERIMETER OF AREA TO BE DEMOLISHED AT JUNCTURES WITH CONSTRUCTION INDICATED TO REMAIN, THEN BREAK UP AND REMOVE.

F. DEMOLITION OF BELOW-GRADE STRUCTURES:

COMPLETELY REMOVE ALL BELOW GRADE STRUCTURES, FOOTINGS, FOUNDATIONS AND UTILITIES BACKFILL AND COMPACT AREAS TO PROPOSED GRADE.

G. SIDEWALKS AND PAVING 1. REMOVE SIDEWALKS AND STONE BASE TO EARTH SUBGRADE.

2. REMOVE CONCRETE AND ASPHALT PAVING AND STONE BASE TO EARTH SUBGRADE.

H. FENCES, BARRIERS AND MISCELLANEOUS SITE ITEMS: COMPLETELY REMOVE INCLUDING CONCRETE OR STONE FOUNDATIONS.

I. PLANT MATERIAL: DEMOLISH AND REMOVE PLANT MATERIAL DESIGNATED TO BE REMOVED INCLUDING ROOT BALLS AND ROOT STRUCTURE TO A DEPTH 3' BELOW PROPOSED GRADES.

STOCKPILE BORROW SOIL MATERIALS AND EXCAVATED SATISFACTORY SOIL MATERIALS WITHOUT INTERMIXING. PLACE, GRADE, AND SHAPE STOCKPILES TO DRAIN SURFACE WATER. COVER TO PREVENT WINDBLOWN DUST.

A. BELOW-GRADE AREAS: COMPLETELY FILL BELOW-GRADE AREAS AND VOIDS RESULTING FROM BUILDING, SITE, AND UTILITY DEMOLITION OPERATIONS WITH ENGINEERED BACKFILL. PLACE FILL IN LIFTS 6" TO 8" THICK, LOOSE MEASURE, COMPACTING EACH LAYER. COMPACTION SHALL BE TESTED BY AN INDEPENDENT QUALIFIED SOILS ENGINEER EMPLOYED BY THE OWNER. LIFTS SHALL BE ADEQUATELY KEYED INTO STRIPPED AND SCARIFIED SUBGRADE SOILS.

1. SHALL BE NOT LESS THAN 95% OF MAXIMUM DRY DENSITY AS ESTABLISHED BY ASTM D 1557. B. BACKFILL WITH ENGINEERED FILL.

C. RECONSTRUCT SUBGRADES DAMAGED BY FREEZING TEMPERATURES, FROST, RAIN, ACCUMULATED WATER, OR DEMOLITION ACTIVITIES, AS DIRECTED BY ENGINEER OR ARCHITECT, WITHOUT ADDITIONAL COMPENSATION

D. SITE GRADING: UNIFORMLY ROUGH GRADE AREA OF DEMOLISHED CONSTRUCTION TO A SMOOTH SURFACE, FREE FROM IRREGULAR SURFACE CHANGES. PROVIDE A SMOOTH TRANSITION BETWEEN ADJACENT EXISTING GRADES AND NEW GRADES.

A. PLOW, SCARIFY, BENCH, OR BREAK UP SLOPED SURFACES STEEPER THAN 1 VERTICAL TO 4 HORIZONTAL SO FILL MATERIAL WILL BOND WITH EXISTING MATERIAL.

B. PLACE AND COMPACT FILL MATERIAL IN LAYERS TO REQUIRED ELEVATIONS AS FOLLOWS: 1. USE ENGINEERED FILL MATERIAL AND COMPACT IN LIFTS.

3.09 SOIL MOISTURE CONTROI

A. UNIFORMLY MOISTEN OR AERATE SUBGRADE AND EACH SUBSEQUENT FILL OR BACKFILL SOIL LAYER BEFORE COMPACTION TO WITHIN 3 PERCENT OF OPTIMUM MOISTURE CONTENT.

1. DO NOT PLACE BACKFILL OR FILL SOIL MATERIAL ON SURFACES THAT ARE MUDDY, FROZEN, OR CONTAIN FROST OR ICE. 2. REMOVE AND REPLACE, OR SCARIFY AND AIR DRY, OTHERWISE SATISFACTORY SOIL MATERIAL THAT EXCEEDS OPTIMUM MOISTURE CONTENT BY 3 PERCENT AND IS TOO WET TO COMPACT TO SPECIFIED DRY UNIT WEIGHT.

GENERAL: PROMPTLY REPAIR DAMAGE TO ADJACENT PROPERTIES CAUSED BY BUILDING DEMOLITION OPERATIONS.

B. WHERE REPAIRS TO EXISTING SURFACES ARE REQUIRED, PATCH TO PRODUCE SURFACES SUITABLE FOR NEW MATERIALS.

C. RESTORE EXPOSED FINISHES OF PATCHES AREAS AND EXTEND RESTORATION INTO ADJOINING PROPERTIES IN A MANNER THAT ELIMINATES EVIDENCE OF PATCHING AND REFINISHING.

3.11 DISPOSAL OF DEMOLISHED MATERIALS

A. GENERAL: EXCEPT FOR ITEMS OR MATERIALS INDICATED TO BE RECYCLED, REUSED, SALVAGED, REINSTALLED, OR OTHERWISE INDICATED TO REMAIN OWNER'S PROPERTY, REMOVE DEMOLISHED MATERIALS FROM PROJECT SITE AND LEGALLY DISPOSE OF THEM IN AN EPA AND OWNER APPROVED LANDFILL. I. DO NOT ALLOW DEMOLISHED MATERIALS TO ACCUMULATE ON-SITE.

2. REMOVE AND TRANSPORT DEBRIS IN A MATTER THAT WILL PREVENT SPILLAGE ON ADJACENT SURFACES AND AREAS.

3. REVENUES AND OTHER INCENTIVES RECEIVED FOR BUILDING DEMOLITION MATERIALS OR PRODUCTS REMOVED FROM BUILDING SHALL ACCRUE TO CONTRACTOR.

B. BURNING: DO NOT BURN DEMOLISHED MATERIALS

C. DISPOSAL: TRANSPORT DEMOLISHED MATERIALS OFF OWNER'S PROPERTY AND LEGALLY DISPOSE OF THEM.

3.12 SALVAGED HISTORIC ITEMS

A. REMOVED AND SALVAGED ITEMS, IF REQUIRED: COMPLY WITH THE FOLLOWING: 1. CLEAN SALVAGED ITEMS OF DIRT AND DEMOLITION DEBRIS, REMOVE MORTAR.

2. PACK OR CRATE SMALL ITEMS AFTER CLEANING. IDENTIFY CONTENTS OF CONTAINERS.

3. PROTECT ITEMS FROM DAMAGE DURING TRANSPORT AND STORAGE. 4. PROTECT PIECES FROM RUBBING TOGETHER BY PLACING FOAM PLASTIC BETWEEN PIECES AND STRAP TO SECURE TO PREVENT MOVEMENT. COVER ITEMS TO PROTECT FROM WATER AND ICE DAMAGE. THEY SHALL BE DELIVERED TO THE

OWNER'S DESIGNATED STORAGE AREA. 5. CRATES SHALL BE CONSTRUCTED OF WHITE PINE, POPLAR OR YELLOW PINE WOOD AND PLYWOOD WHICH DO NOT CONTAIN EXCESSIVE AMOUNTS OF RESIN. FOAM PLASTIC SHALL BE NON-STAINING TYPE.

COMPLETION OF DEMOLITION THE CONTRACTOR SHALL CLEAN ADJACENT STORM STRUCTURES. PAVEMENT AND IMPROVEMENTS OF DUST, DIRT, AND DEBRIS CAUSED BY BUILDING DEMOLITION OPERATIONS. RETURN ADJACENT AREAS TO CONDITION EXISTING BEFORE BUILDING DEMOLITION OPERATIONS BEGAN.

O O

NEER * * PROY


S S 1 **≧** □

APPLICATION NO.

SCALE

DATE

SHEET

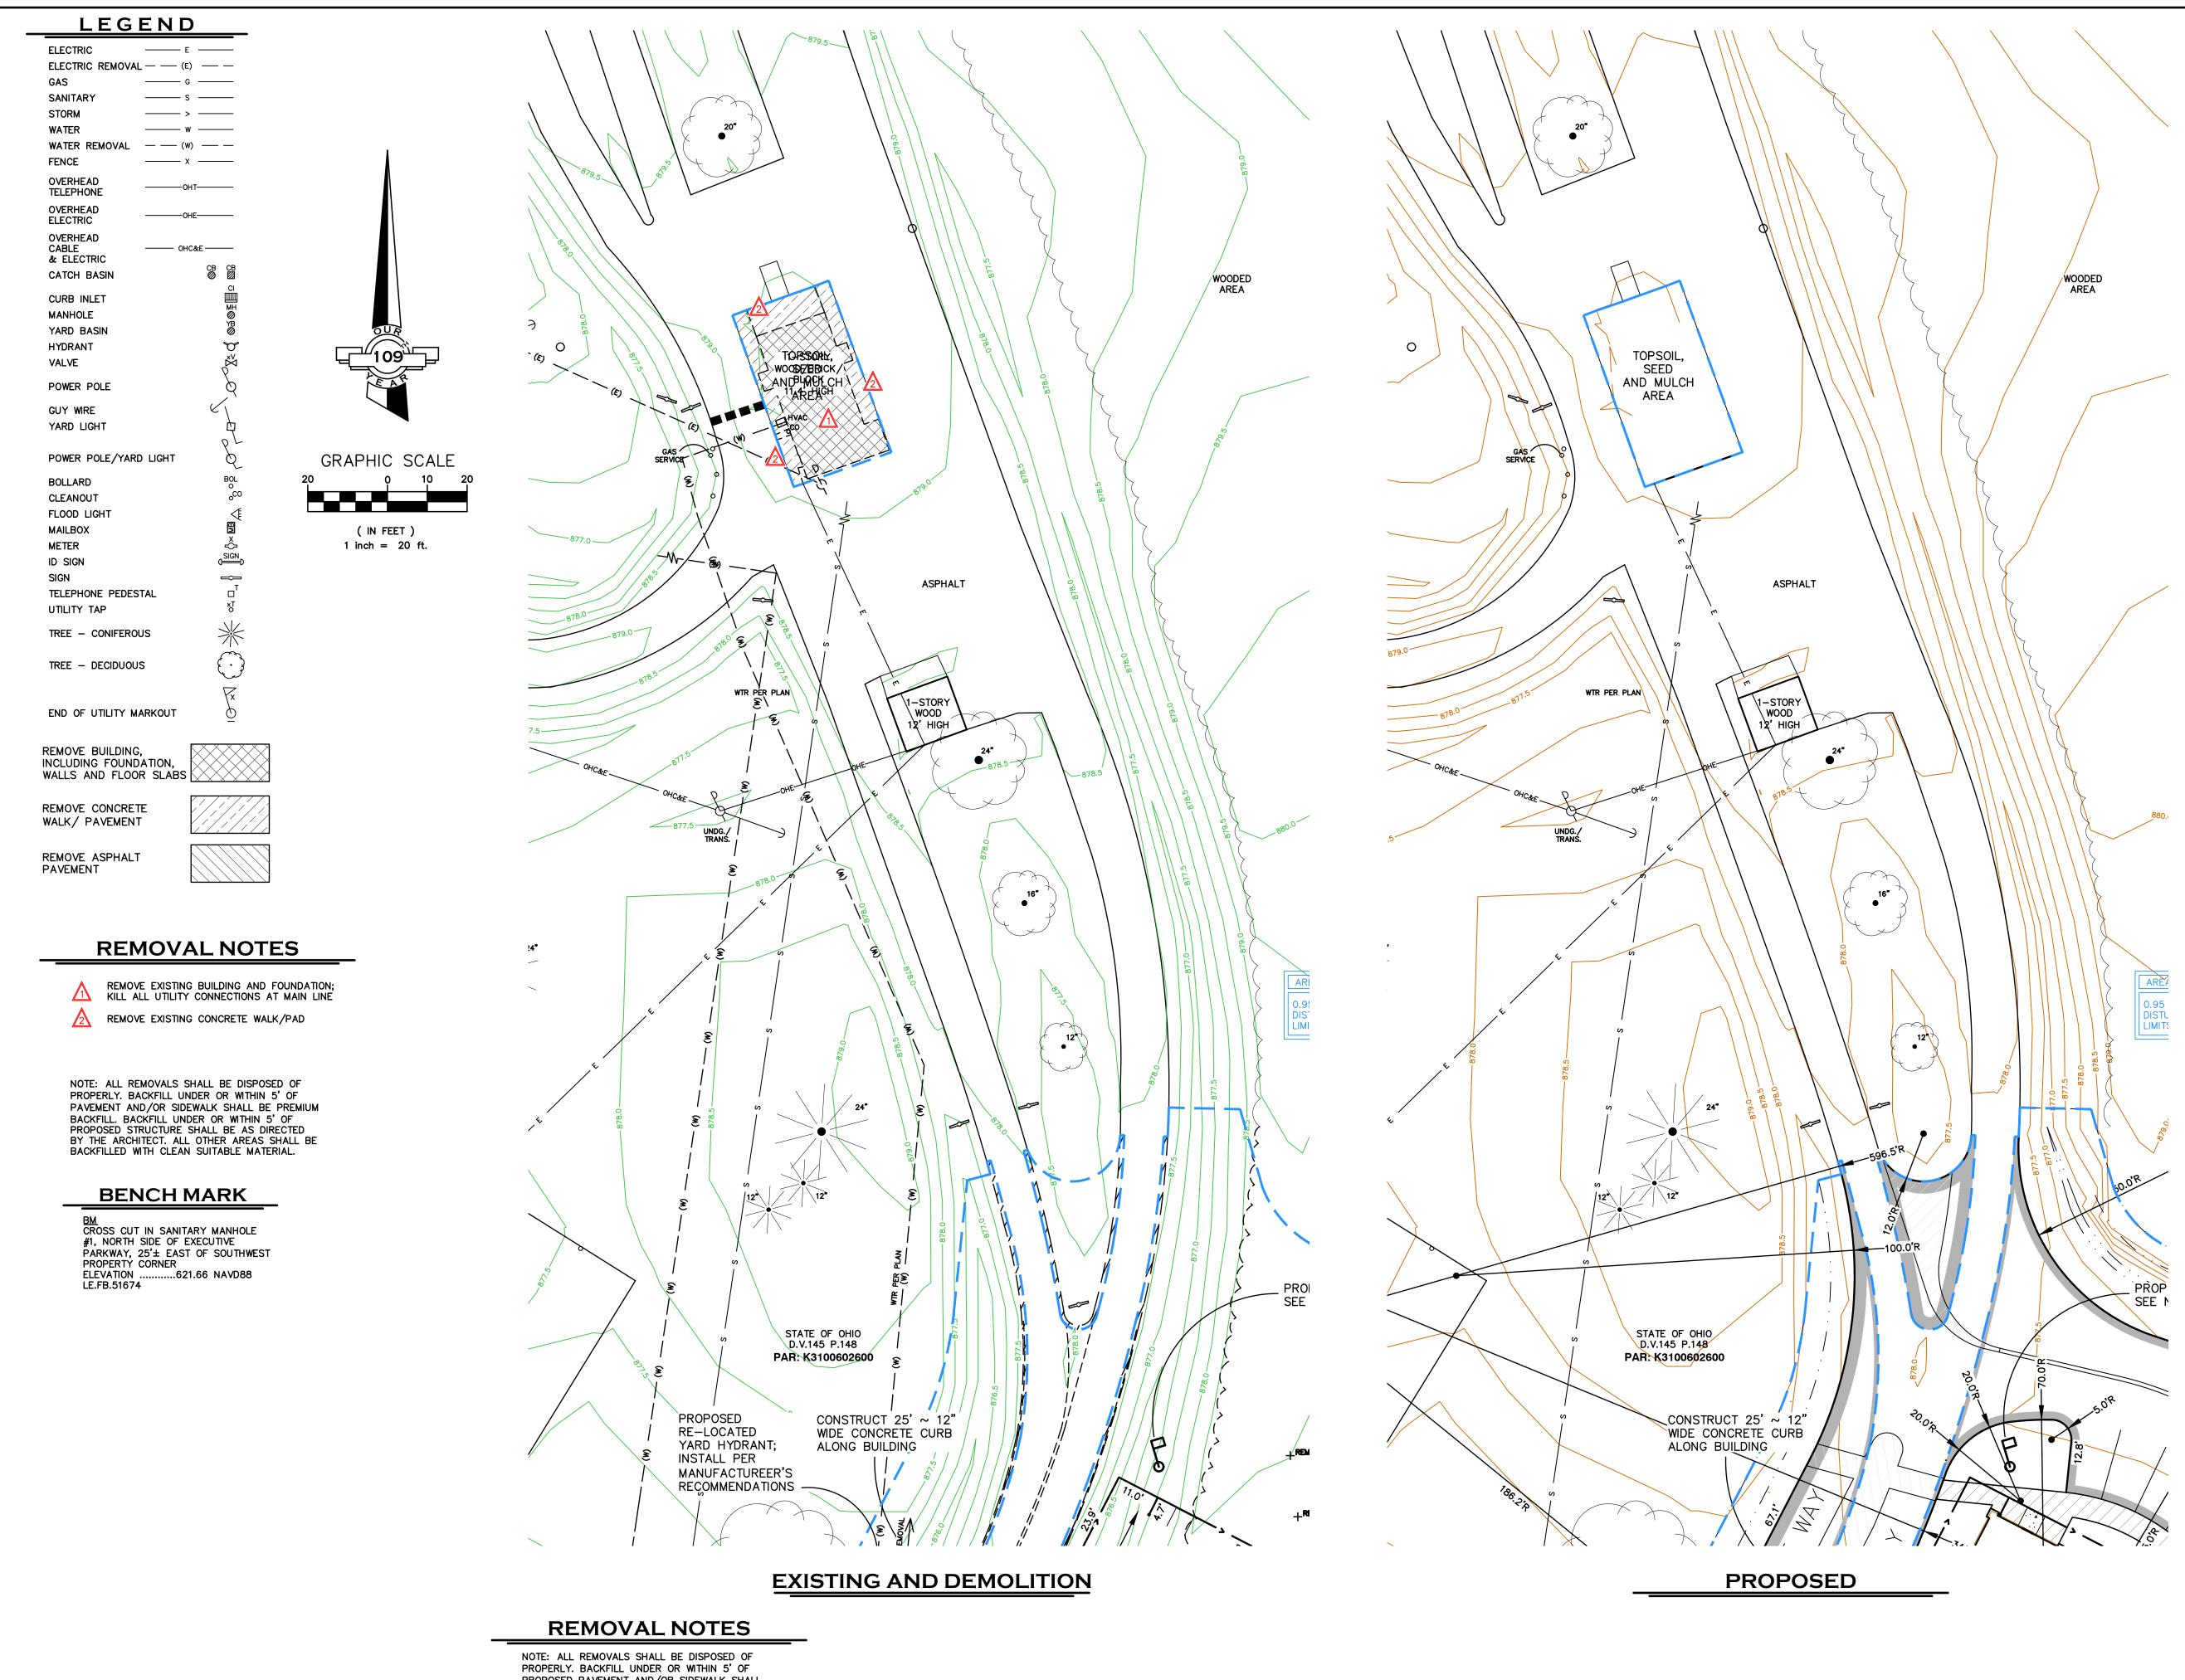

PROPOSED PAVEMENT AND/OR SIDEWALK SHALL BE COMPACTED PREMIUM BACKFILL, MAXIMUM 6" LIFTS. BACKFILL UNDER OR WITHIN 5' OF PROPOSED STRUCTURE SHALL BE AS DIRECTED BY THE ARCHITECT. ALL OTHER AREAS SHALL BE BACKFILLED WITH CLEAN SUITABLE MATERIAL. verdanta

ď		111	1111	1111	PA	1111	1111	1	1	1	1	STATE
CHK'D BY DATE DATE	MPF	70 01/101110	CHECKED BY	TMB		VTI IITI I/OBOT		MPF		DRO IECT NO		30131
CHK'D BY DATE												
REVISION												
No.												


T. MARYS TOWNS
GRAND L

APPLICATION NO. DATE 09/19/2025

SCALE


1" = 20'


5 OF 10

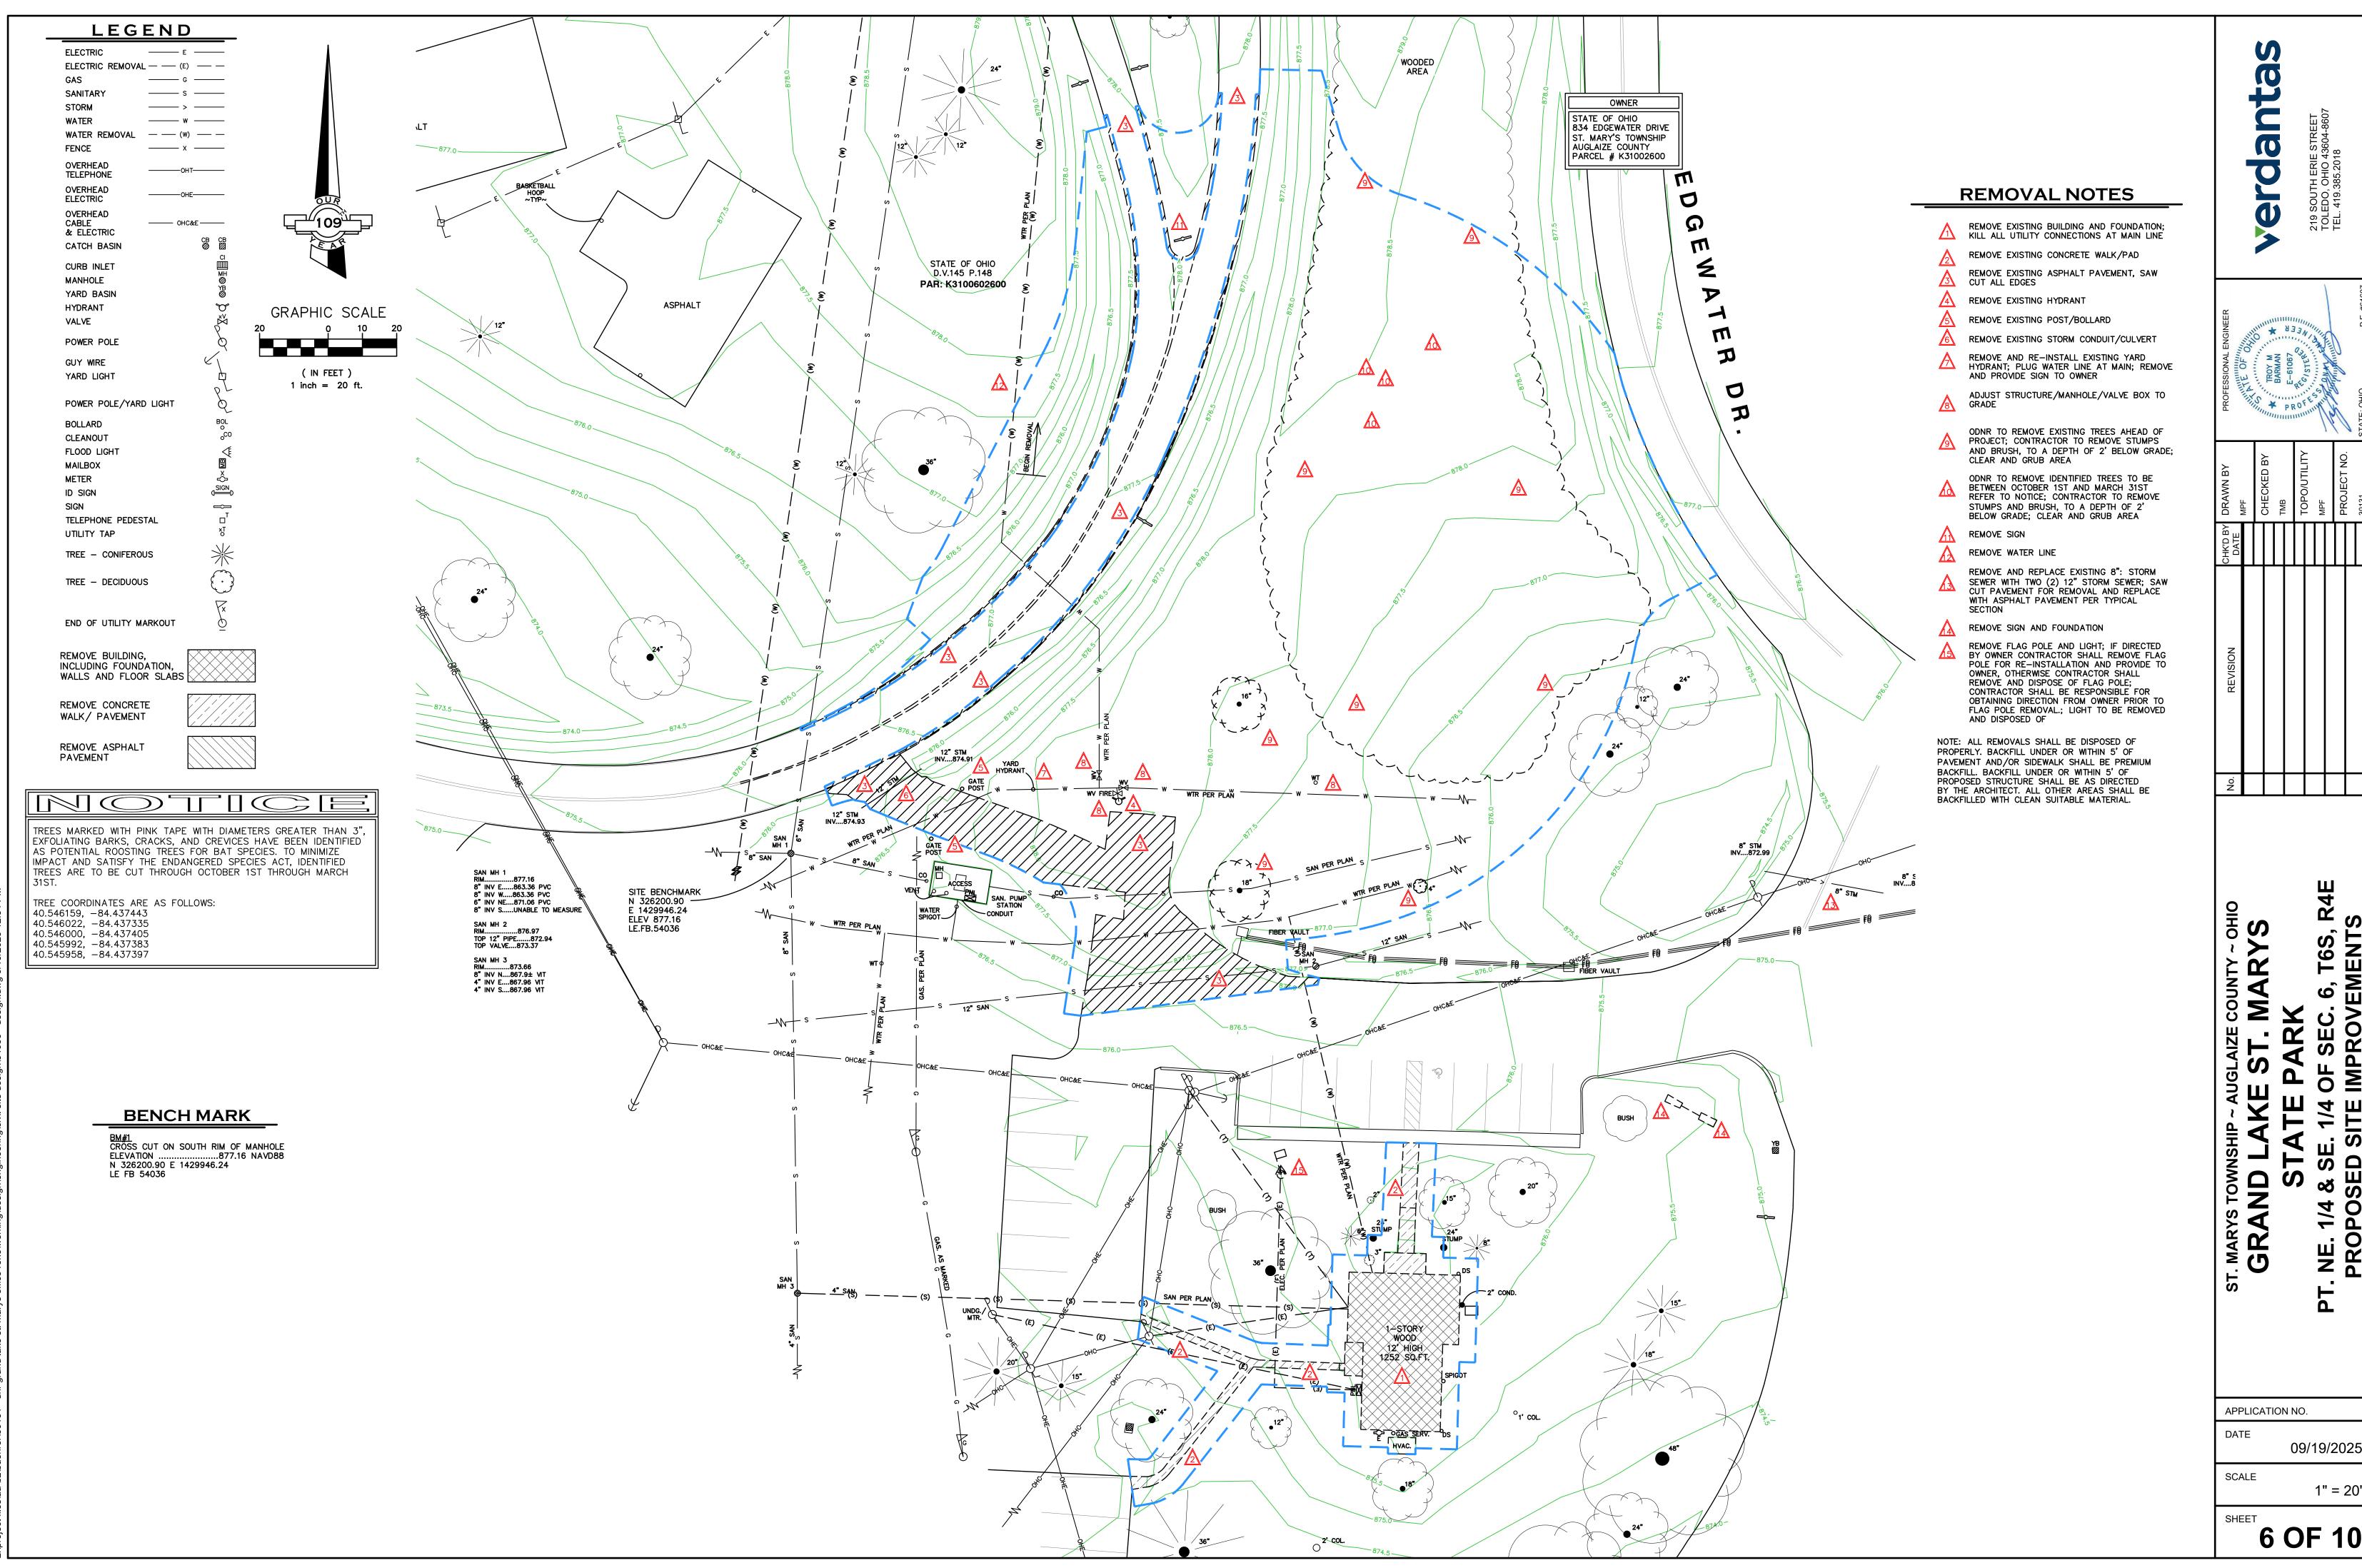

09/19/2025

6 OF 10

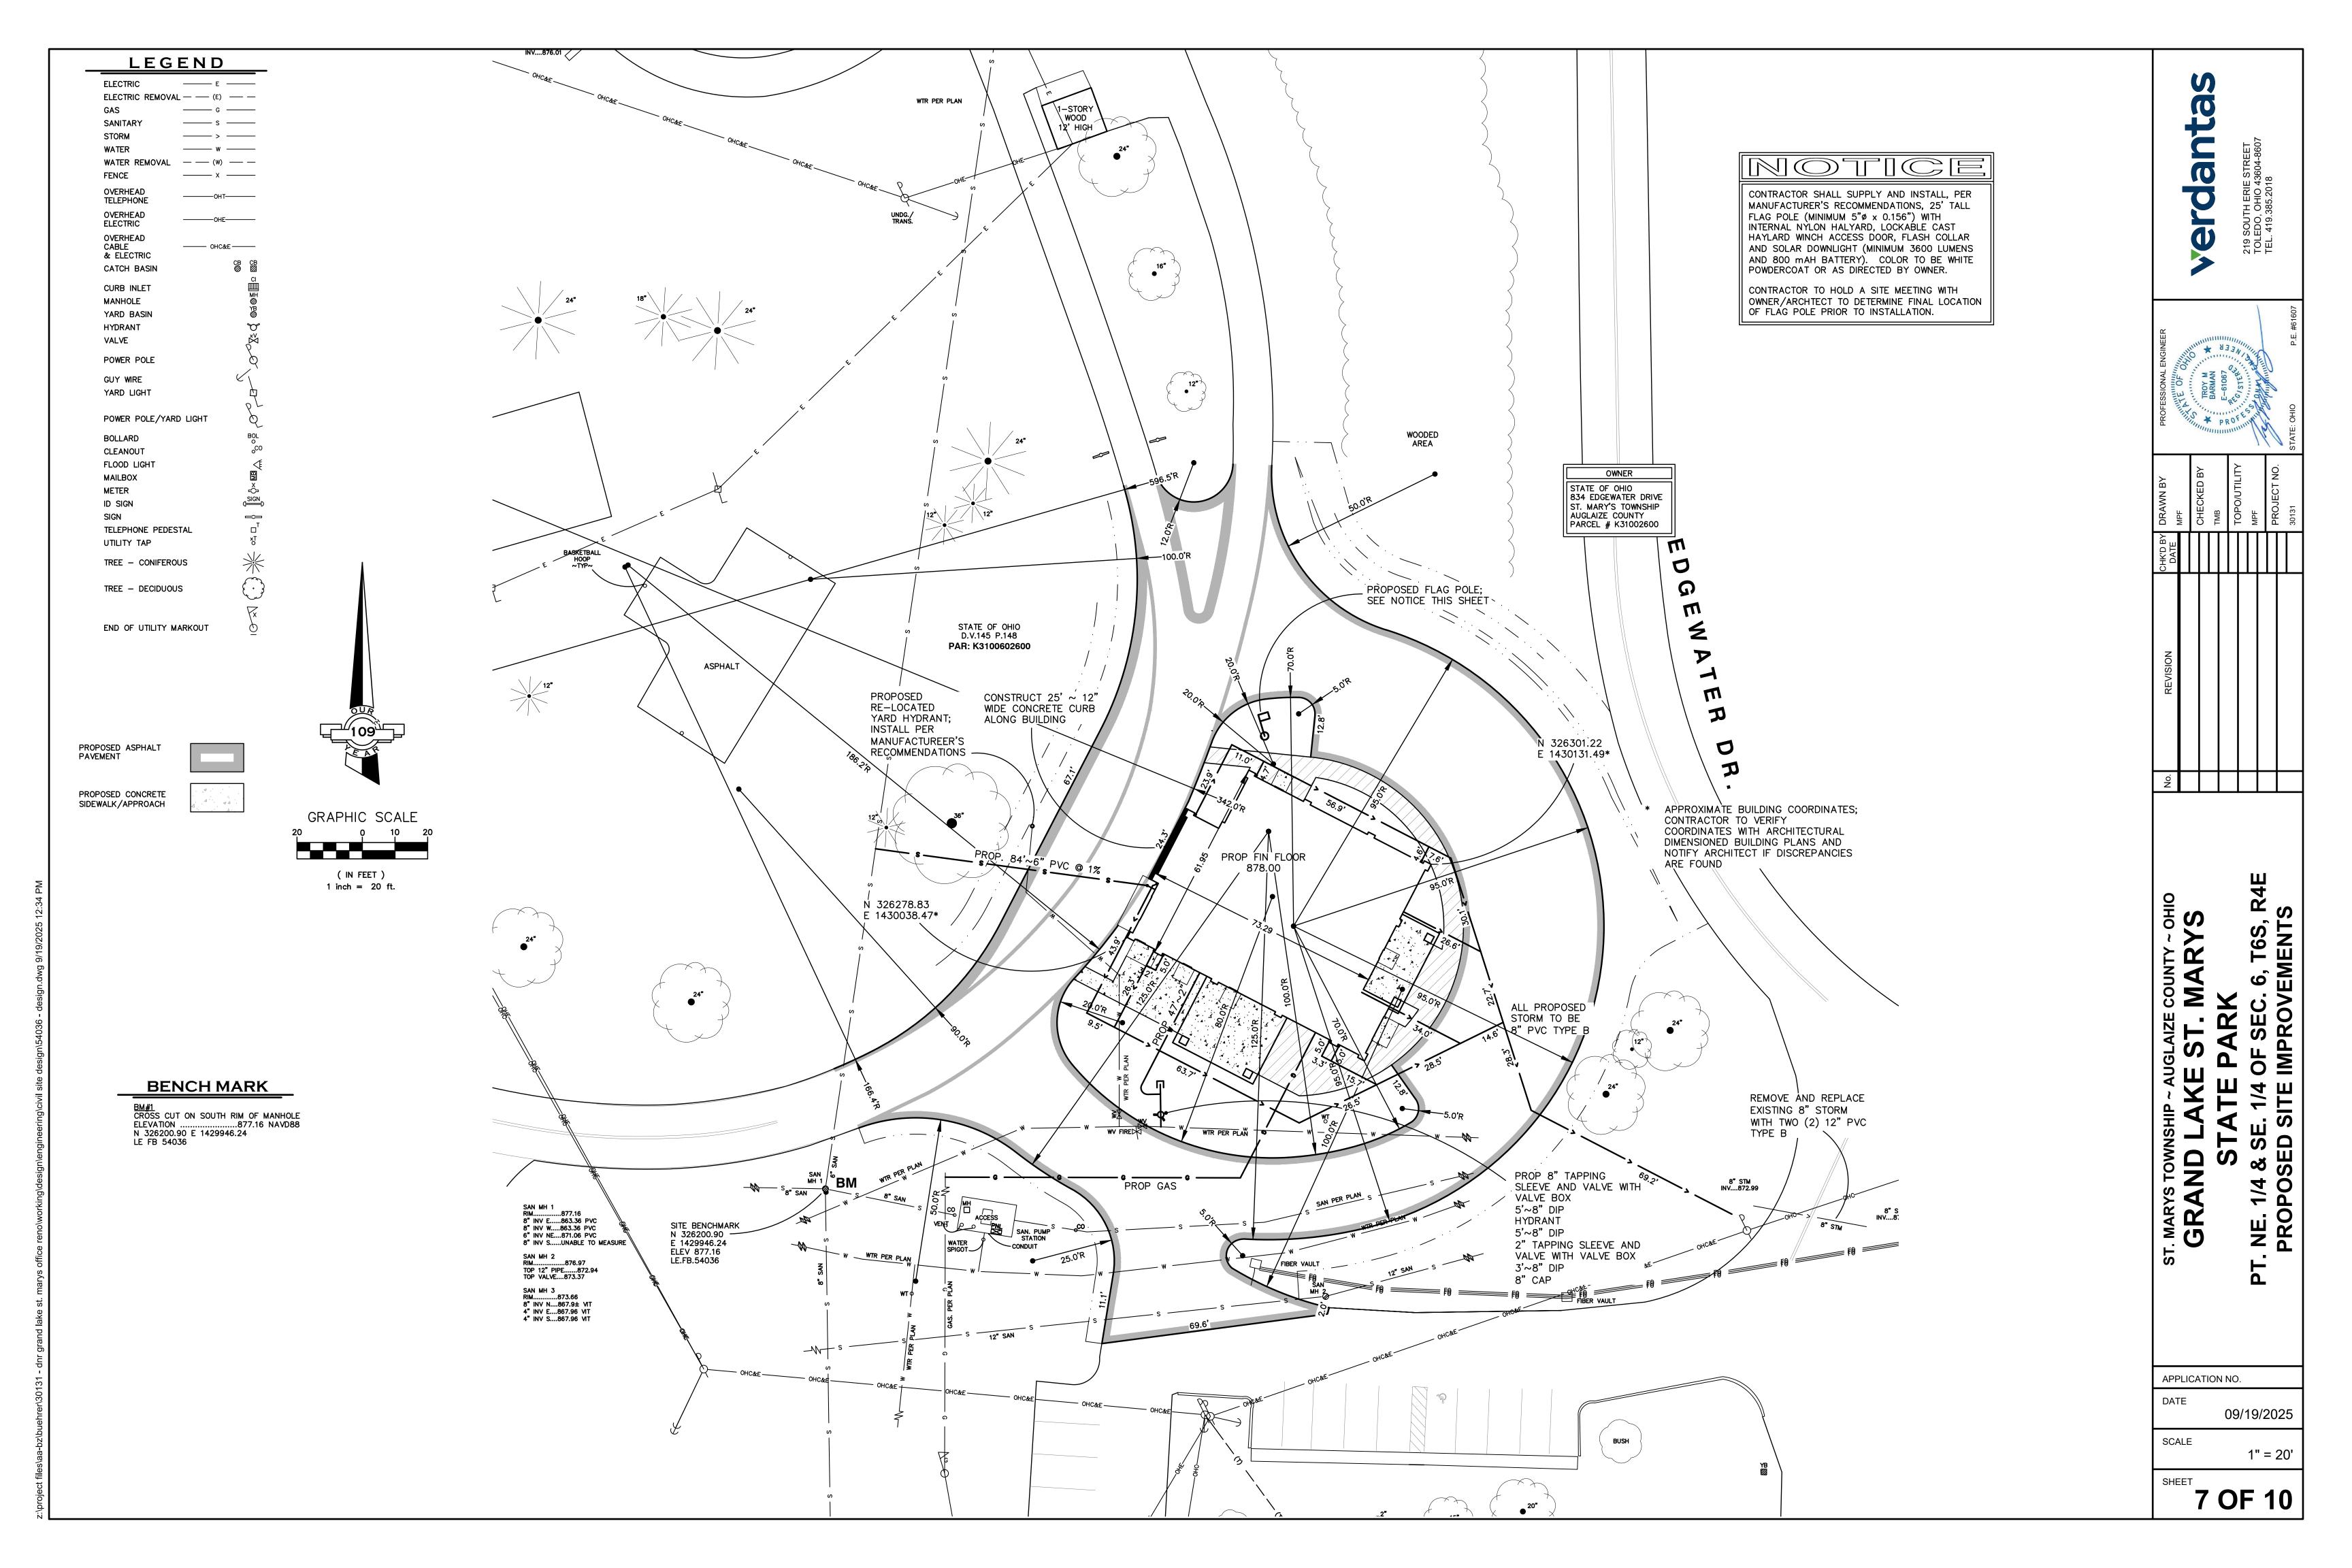

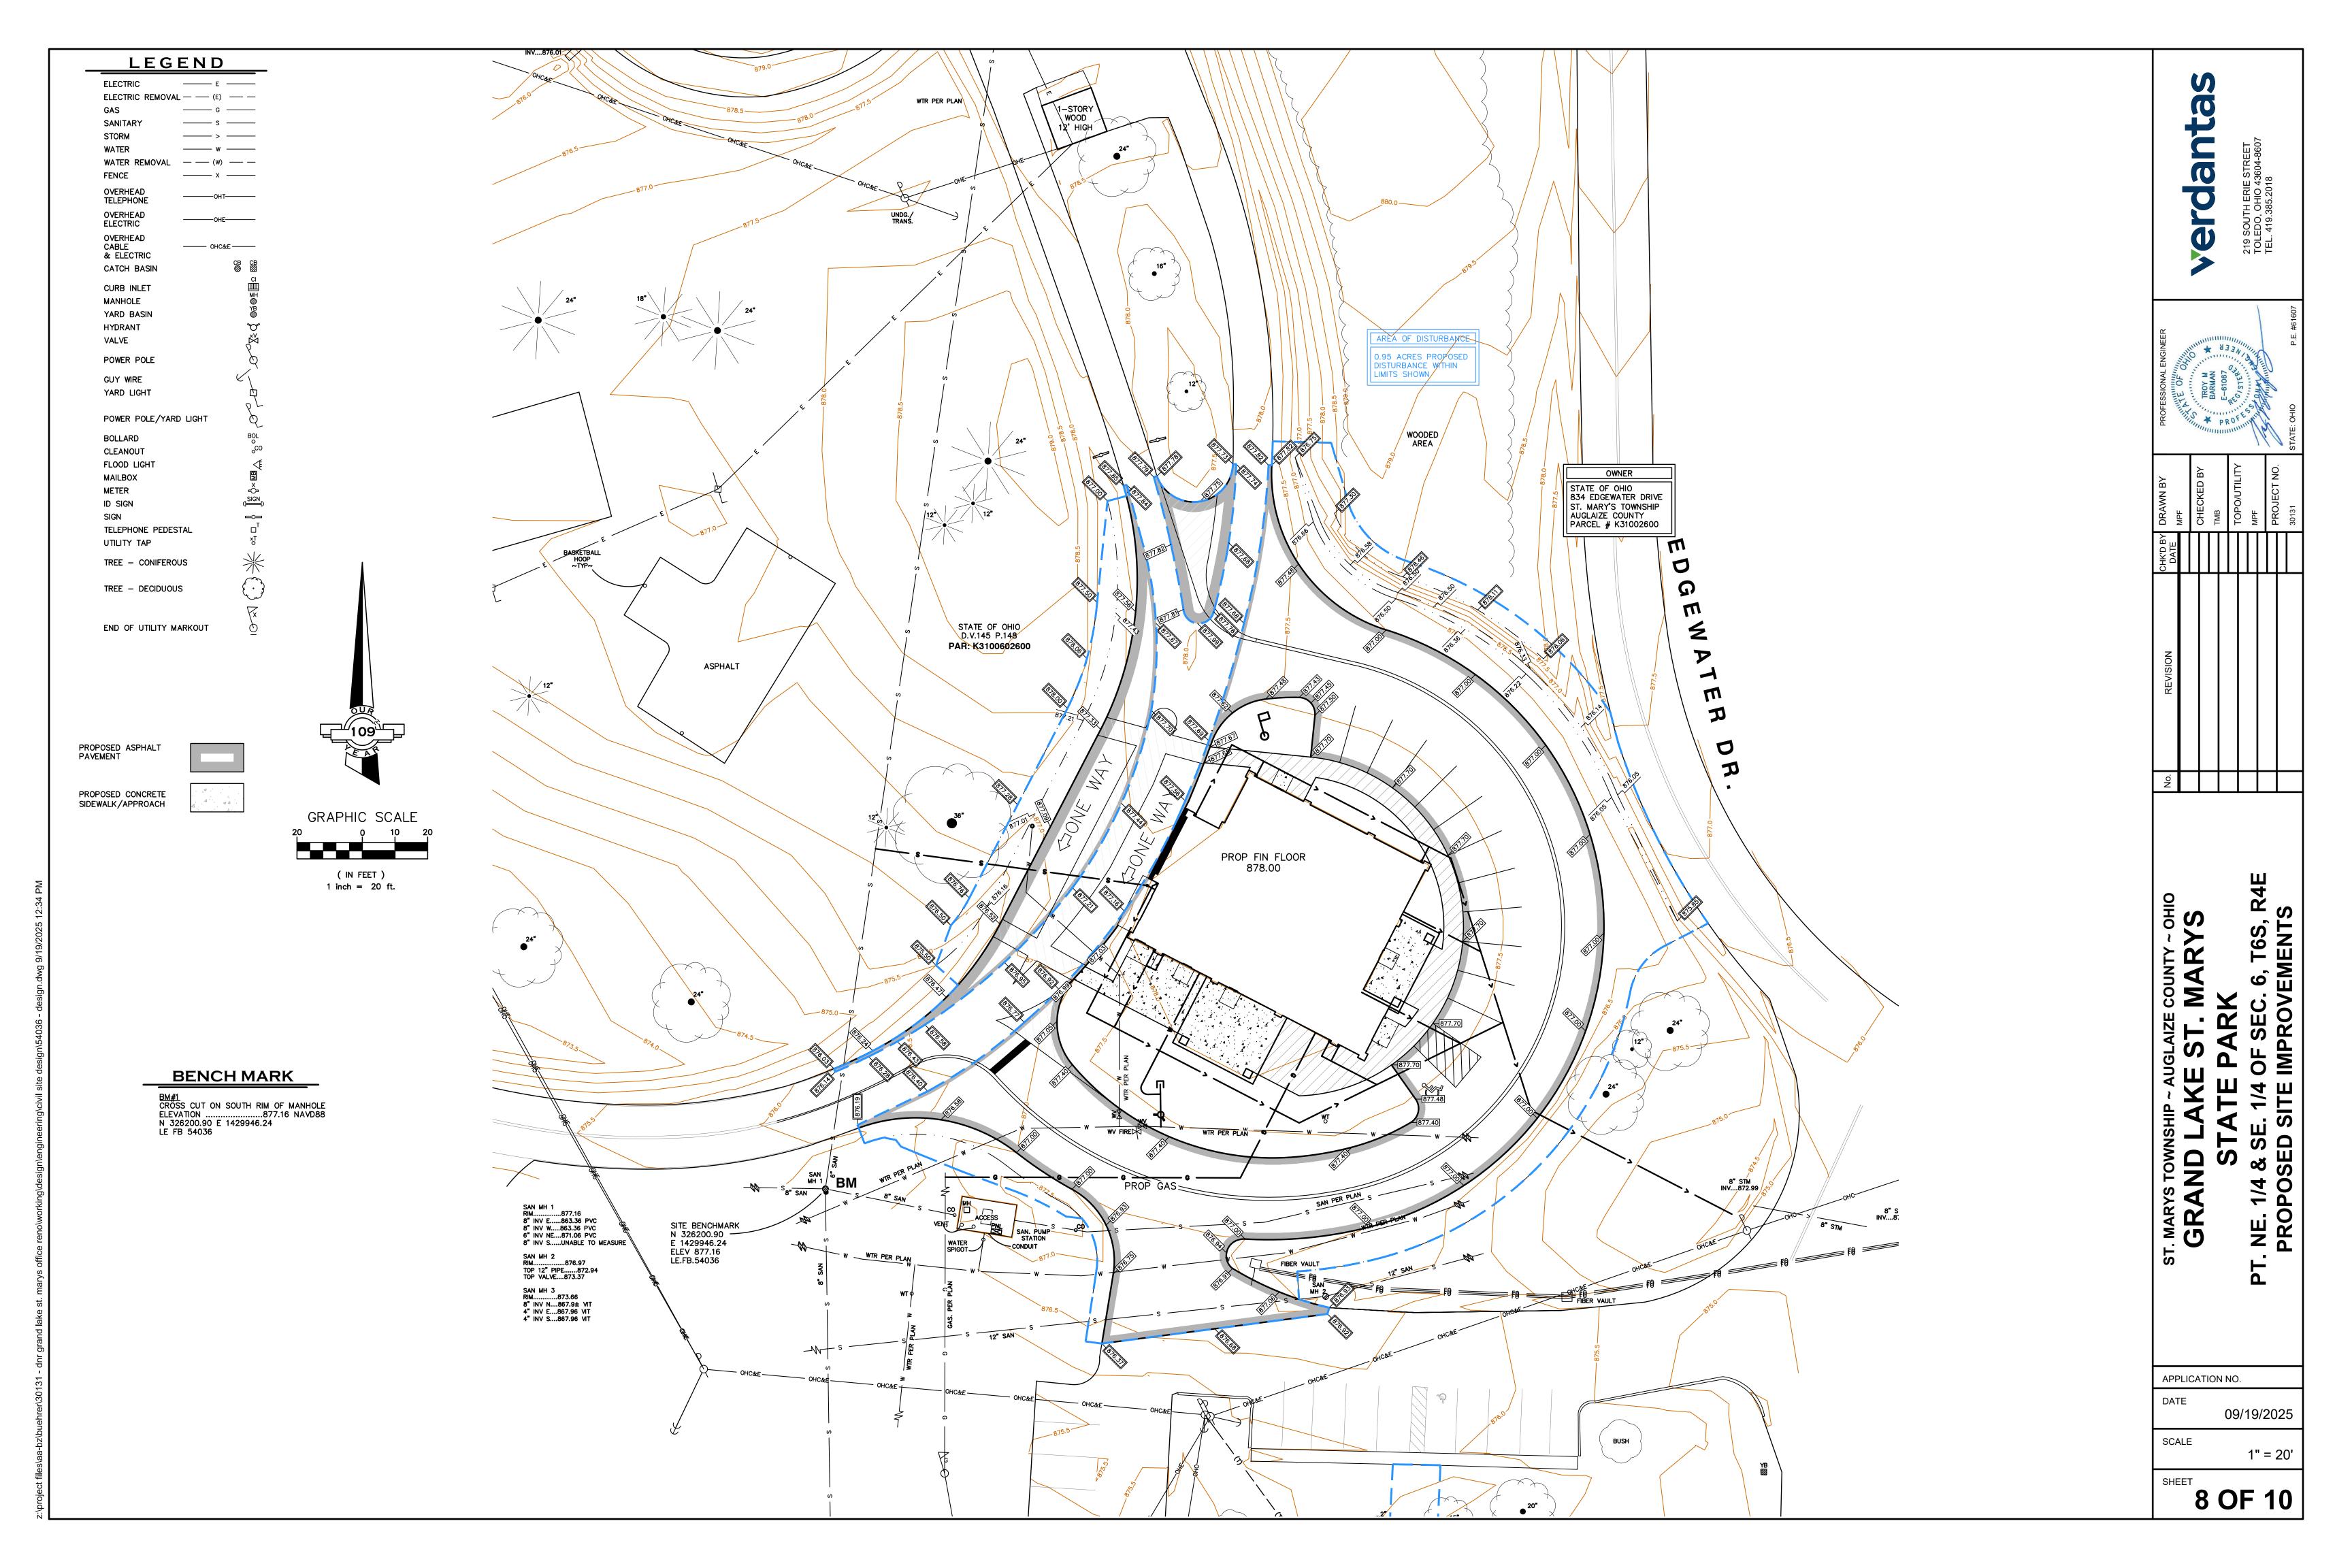

BENCH MARK

BM#1 CROSS CUT ON SOUTH RIM OF MANHOLE ELEVATION877.16 NAVD88 N 326200.90 E 1429946.24 LE FB 54036

CONTRACTOR SHALL VERIFY ALL CONTROL POINTS PRIOR TO COMMENCING WORK.

* APPROXIMATE BUILDING COORDINATES; CONTRACTOR TO VERIFY COORDINATES WITH ARCHITECTURAL DIMENSIONED BUILDING PLANS AND NOTIFY ARCHITECT IF DISCREPANCIES ARE FOUND

CULTURAL / ENVIRONMENTAL NOTE:
CONTRACTOR SHALL NOTIFY THE OWNER IMMEDIATELY IF
ARCHAEOLOGICAL DEPOSITS ARE DISCOVERED IN THE LIMITS OF WORK
AND WORK STOPPED UNTIL DIRECTION IS GIVEN.

NO TREE CLEARING SHALL BE PERMITTED OUTSIDE THE LIMITS OF



EROSION CONTROL SILT FENCE

CONSTRUCTION ENTRANCE

DUMPSTER AREA

SEDIMENT BARRIER

CONCRETE WASH-OUT AREA

VEHICLE FUELING/MAINTENANCE AREA

verdanta

APPLICATION NO. DATE 09/19/2025

SCALE

1" = 60'

THE CONTRACTOR SHALL BE RESPONSIBLE FOR COMPLETING THE CONTRACTOR CONTACT SHEET, THE STORM WATER POLLUTION PREVENTION PLAN CONTACT LIST, COMPLETING AND FILING THE N.O.I CO-PERMITEE PERMIT (CO-PERMITTEE AND SHALL BE SUBMITTED A MINIMUM OF 21 DAYS BEFORE GROUND IS BROKEN), ALL INSPECTIONS, SWP3 MODIFICATION AND FILLING OUT THE N.O.T.

ALL SUB—CONTRACTOR SHALL BE RESPONSIBLE FOR COMPLETING THE CONTRACTOR CONTACT SHEET, THE STORM WATER POLLUTION PREVENTION PLAN CONTACT LIST AND COMPLETING AND FILING THE N.O.I CO-PERMITEE PERMIT (CO-PERMITTEE AND SHALL BE SUBMITTED A MINIMUM OF 21 DAYS BEFORE GROUND IS BROKEN) AS NECESSARY. THE EROSION CONTROL MEASURES DESCRIBED HEREIN ARE TYPICAL. $\,$ THE CONTRACTOR SHALL USE THIS PLAN AS A GUIDE TO CONTROL EROSION. IN THE EVENT OF ADVERSE WEATHER CONDITIONS, ETC. ADDITIONAL MEASURES SHALL BE TAKEN TO ESTABLISH AND MAINTAIN PROTECTIVE VEGETATION. THE CONTRACTOR'S QUALIFED INSPECTOR HAS ALL

WORK SHALL NOT COMMENCE UNTIL A COPY OF THE OHIO EPA LETTER GRANTING COVERAGE, FOR STORM WATER DISCHARGES ASSOCIATED WITH CONSTRUCTION ACTIVITY UNDER THE NATIONAL POLLUTANT DISCHARGE ELIMINATION SYSTEM (NPDES) HAS BEEN SUBMITTED BY THE CONTRACTOR TO THE LOCAL MUNICIPALITY OR COUNTY.

RIGHTS AND RESPONSIBILITIES TO MODIFY THIS SWP3 PLAN IN ORDER TO MAINTAIN COMPLIANCE WITH THE NPDES

CONTRACTOR SHALL MAINTAIN NOTES ON ALL MODIFICATIONS TO THE SWP3 IN THE SWP3 LOG BOOK AND SHALL KEEP ALL RECORDS AND PLANS ON-SITE. CONTRACTOR SHALL UPDATE THE EROSION CONTROL PLAN WITH THE FINAL LOCATION FOR STORAGE AREAS OF SOLID, SANITARY AND TOXIC WASTE (INCLUDING DUMPSTER AREAS), AREAS DESIGNATED FOR CONCRETE TRUCK WASHOUT, AREAS FOR REFUELING AND DESIGNATED CONSTRUCTION ENTRANCE(S)

THE CONTRACTOR SHALL COMPLETE THE NOTICE OF TERMINATION (N.O.T.) WITHIN 45 DAYS AFTER FINAL SITE STABILIZATION HAS BEEN ACHIEVED AND CONSTRUCTION ACTIVITY IS COMPLETED. COPY OF N.O.T., ALL INSPECTION LOGS, EROSION CONTROL NOTES AND PLANS SHALL BE DELIVERED TO THE OWNER FOR FILING WITH THE OHIO EPA.

FINAL SITE STABILIZATION IS CONSIDERED ACHIEVED ONCE ALL TEMPORARY EROSION AND SEDIMENT CONTROL PRACTICES ARE REMOVED AND DISPOSED OF AND ALL TRAPPED SEDIMENT HAS BEEN PERMANENTLY STABILIZED TO PREVENT FURTHER EROSION. THE TERMS AND CONDITIONS OF THIS PERMIT SHALL REMAIN IN EFFECT UNTIL A SIGNED

FAILURE TO SUBMIT A N.O.T. CONSTITUTES A VIOLATION OF THIS PERMIT AND MAY AFFECT THE ABILITY OF THE PERMITTEE TO OBTAIN GENERAL PERMIT COVERAGE IN THE FUTURE.

A. SITE ENVIRONMENTAL CONDITIONS

. DESCRIPTION OF WORK: COMMERCIAL BUILDING AND DEMOLITION 2. AREA TO BE DISTURBED BY CONSTRUCTION: 0.9 ACRES

B. CONSTRUCTION SCHEDULE

- 1. FILE N.O.I. AND CO-PERMITTEE NOI 2. INSTALL CONSTRUCTION ENTRANCE
- 3. INSTALL SILT FENCING AT DOWNSLOPE PERIMETER OF SITE
- 4. INSTALL FILTER FABRIC AROUND EXISTING CATCHBASINS 5. DEMOLITION, CLEAR AND GRUB SITE AND PLACE TEMPORARY SEED
- 6. CONSTRUCT BUILDINGS AND PARKING LOT
- 7. TEMPORARY EROSION CONTROLS SHALL BE APPLIED TO ALL DISTURBED AREAS THAT ARE TO BE LEFT IDLE OVER WINTER PRIOR TO THE ONSET OF WINTER WEATHER
- 8. INSTALL LANDSCAPE AND FINAL CONSTRUCTION STABILIZATION
- 9. FILE N.O.T.

C. STORM WATER RECEIVING STREAM 1. IMMEDIATE RECEIVING STREAM: DISCHARGES TO GRAND LAKE ST. MARYS

D. BATCH PLANTS

. ASPHALT AND/OR CONCRETE BATCH PLANTS ARE NOT ANTICIPATED FOR THIS PROJECT. CONTRACTOR SHALL MODIFY THE NPDES CONSTRUCTION STORM WATER GENERAL PERMIT AS REQUIRED PRIOR TO ESTABLISHING BATCH PLANTS IF THEY DEEM THEM NECESSARY FOR THE CONSTRUCTION ACTIVITIES.

E. SWPPP GENERAL NOTES

- TEMPORARY EROSION CONTROL SHALL CONFORM TO OHIO EPA PERMIT NO: OCHOOO005. ALL EROSION AND SEDIMENT CONTROL PRACTICES MUST MEET THE STANDARDS & SPECIFICATIONS OF THE OHIO RAINWATER AND LAND DEVELOPMENT HANDBOOK (CURRENT EDITION) ALONG WITH ALL LOCAL CODES, STANDARDS AND REQUIREMENTS.
- 2. THE CONTRACTOR SHALL TAKE SPOILS AND RECEIVE BORROW FROM OFF—SITE LOCATIONS THAT MAINTAIN THEIR OWN N.O.I.. IF OFF-STE LOCTAIONS DO NOT HAVE THEIR OWN N.O.I THE CONTRACTOR SHALL BE RESPONSIBLE FOR PERMITTING THE OFF-SITE BORROW/SPOIL SITES. ADDRESS FOR OFF-SITE AREAS ALONG WITH COPIES OF THEIR N.O.I. PERMITS SHALL BE MAINTAINED ADDED TO THE END OF THIS EROSION CONTROL LOG BOOK.
- a.THE EARTHWORK ON THIS SITE MAY NOT BE BALANCED AND IT IS THE CONTRACTOR'S RESPONSIBILITY TO EXCAVATE AND PROPERLY DISPOSE OF EXCESS MATERIAL OFF SITE AND/OR PROVIDE. PLACE AND COMPACT SUITABLE FILL MATERIAL AS REQUIRED FOR THE PROJECT. MOUNDING OF EXCESS MATERIAL OR EXCAVATING BORROW PITS ON SITE IS NOT PERMITTED WITHOUT THE WRITTEN APPROVAL OF THE OWNER.
- THE CONTRACTOR SHALL NOT DISPOSE ANY SOLID, SANITARY OR TOXIC WASTES ON SITE.
- 4. DISTURBED AREAS SHALL BE KEPT TO A MINIMUM WITH RESPECT TO AREAS EXPOSED AND TIME OF EXPOSURE.
- 5. TO ASSIST IN EROSION CONTROL, ALL TREES AND VEGETATION OUTSIDE OF GRADED AREAS SHALL REMAIN UNDISTURBED.
- 3. TEMPORARY STABILIZATION (SEEDING AND/OR MULCHING) TO DISTURBED AREAS MUST BE APPLIED: 1) WITHIN 7 DAYS OF LAST DISTURBANCE ON ANY AREA THAT WILL LIE DORMANT FOR ONE YEAR OR LONGER; 2) WITHIN 2 DAYS ON ANY AREAS WITHIN 50 FT. OF A STREAM OR SURFACE WATER THAT WILL LIE DORMANT FOR 14 DAYS OR LONGER; 3) WITHIN 7 DAYS ON ANY AREAS OVER 50 FT. OF A STREAM OR SURFACE WATER THAT WILL LIE DORMANT FOR 14 DAYS OR LONGER: AND 4) PRIOR TO THE ONSET OF WINTER IN THOSE AREAS THAT WILL BE IDLE OVER WINTER, PERMANENT STABILIZATION TO DISTURBED AREAS MUST BE APPLIED TO ANY AREA: 1) WITHIN 7 DAYS OF REACHING FINAL GRADE; 2) WITHIN 7 DAYS FOR AREAS THAT WILL LIE DORMANT FOR 1 YEAR OR MORE. OR 3) WITHIN 2 DAYS OF REACHING FINAL GRADE WITHIN 50 FT. OF A STREAM. DISTURBED AREAS SHALL BE STABILIZED WITH SEEDING AND MULCHING OR OTHER APPROPRIATE MEANS.
- SEDIMENT CONTROL DEVICES SHALL BE IMPLEMENTED FOR ALL AREAS TO BE DISTURBED FOR OVER 14 DAYS
- SEDIMENT PONDS/TRAPS AND PERIMETER CONTROLS, AS REQUIRED, SHALL BE IMPLEMENTED AS A FIRST STEP OF GRADING AND WITHIN 7 DAYS OF GRUBBING AND SHALL CONTINUE TO FUNCTION UNTIL UPLAND AREAS ARE
- 9. EROSION CONTROL BLANKETS WITH MATTING WILL BE USED ON DITCHES GREATER THAN 1.5% AND ALL OTHER SLOPES GREATER THAN 6% GRADE.
- 10. ALL SITES WITH OVER 10 ACRES OF DISTURBED AREA, WHEN THERE IS CONCENTRATED RUNOFF (STORM SEWER OR DITCH), OR WHEN THE DESIGN CAPACITY OF SILT FENCE OR INLET PROTECTION HAS BEEN EXCEEDED SHALL HAVE A SEDIMENT POND. SEDIMENT POND SHALL BE SIZED PER THE N.O.I. PERMIT. OUTLET STRUCTURE FOR THE SEDIMENT POND SHALL WITHDRAW WATER FROM THE SURFACE. CONTRACTOR SHALL PROVIDE AND INSTALL A STORM WATER SKIMMER TO REGULATE DISCHARGE FROM THE SURFACE OF THE SEDIMENT POND. SEDIMENT AREA SHALL BE CLEANED OUT WHEN SILT OCCUPIES 40% OF THE SEDIMENT STORAGE ZONE OR WHEN THE SEDIMENT ACCUMULATION CREATES A DRAINAGE ISSUE, WHICHEVER COMES FIRST.
- 11. DETENTION POND SHALL BE SEEDED WITH GRASS PER THE EROSION CONTROL NOTE SPECIFICATIONS. DETENTION AREA SHALL BE CLEANED OUT WHEN SEDIMENT OCCUPIES 40% OF THE SEDIMENT STORAGE ZONE OR WHEN THE SEDIMENT ACCUMULATION CREATES A DRAINAGE ISSUE, WHICHEVER COMES FIRST
- 12. DETENTION AREA SHALL HAVE MAXIMUM SIDE SLOPES OF 3:1.

13. SILT FENCE FABRIC SHALL BE EXXON GTF-100S OR APPROVED EQUAL. SILT FENCE IS NOT PERMITTED TO BE USED FOR CONTROLLING HIGH VELOCITY STORM WATER FLOW (ONLY SHEET FLOW).

14. STRUCTURAL SEDIMENT CONTROLS SHALL NOT BE CONSTRUCTED IN ANY STREAMS. ANY WORK/DISTURBANCE ALONG STREAM BANKS SHALL BE MINIMIZED TO THE WIDTH OF CONSTRUCTION AS SHOWN ON THE PLANS.

15. NO SOLID OR LIQUID WASTE, TOXIC/HAZARDOUS/OTHERWISE, SHALL BE DISCHARGED INTO STORM WATER RUNOFF. IT IS PROHIBITED TO BURN, BURY, OR POUR ONTO THE GROUND OR INTO A STORM WATER CONVEYANCE ANY SOLVENTS, PAINTS, STAINS, GASOLINE, DIESEL FUEL, HYDRAULIC FLUID, USED MOTOR OIL, ANTIFICHEZE, CEMENT CURING COMPOUNDS, AND OTHER SUCH SOLID OR HAZARDOUS WASTES. ANY RINSE WATERS CONTAINING SUCH MATERIALS ARE COMPOUNDS, AND OTHER SUCH SOLID OR HAZARDOUS WASTES. ANY RINSE WATERS CONTAINING SUCH MATERIALS ARE 1. A SUBSOILER, PLOW OR OTHER IMPLEMENT SHALL BE USED TO REDUCE SOIL PAINTS, STAINS, GASOLINE, DIESEL FUEL, HYDRAULIC FLUID, USED MOTOR OIL, ANTIFREEZE, CEMENT CURING PROHIBITED BEING PLACED WHERE THEY MAY ENTER DRAINAGEWAYS. WASH OUT OF CEMENT TRUCKS SHOULD OCCUR IN A DIKED, DESIGNATED AREA, AWAY FROM ANY CONVEYANCE CHANNEL. STORAGE TANKS, EQUIPMENT MAINTENANCE, AND CHEMICAL MIXING SHOULD BE LOCATED IN DIKED AREAS AWAY FROM DRAINAGE CHANNELS. THE NPDES CONSTRUCTION STORM WATER GENERAL PERMIT ONLY AUTHORIZES THE DISCHARGE OF STORM WATER AND CERTAIN UNCONTAMINATED NON-STORM WATERS. THE DISCHARGE OF NON-STORM WATERS TO WATERS OF THE STATE MAY BE IN VIOLATION OF LOCAL, STATE AND FEDERAL LAWS OR REGULATIONS. THE SWPPP PLAN DRAWING SHALL BE UPDATED

16. CONTRACTOR SHALL PROVIDE, AS NECESSARY, CONTAINERS FOR DISPOSAL OF DEBRIS, TRASH, HAZARDOUS OR PETROLIUM PRODUCTS. ALL CONTAINERS MUST BE COVERED AND LEAK-PROOF.

17. CONTRACTOR SHALL VERIFY THAT BRICKS, HARDENED CONCRETE AND SOIL WASTE ARE FREE FROM CONTAMINATION.

18. CONTRACTOR SHALL DISPOSE OF ALL CONSTRUCTION AND DEMOLITION DEBRIS WASTE AT A LANDFILL FACILITY APPROVED BY THE OHIO EPA TO ACCEPT SUCH WASTE AS REQUIRED BY THE OHIO REVISED CODE (ORC) 3714. CONSTRUCTION DEBRIS MAY BE DISPOSED OF ON-SITE, BUT DEMOLITION DEBRIS MUST BE DISPOSED IN AN OHIO EPA APPROVED LANDFILL. MATERIAL WHICH CONTAIN ASBESTOS MUST COMPLY WITH AIR POLLUTION REGULATIONS (SEE OHIO

19. ALL STORAGE TANKS, EQUIPMENT MAINTENANCE AND CHEMICAL MIXING SHALL BE LOCATED/COMPLETED IN DIKED AREAS AWAY FROM DRAINAGE CHANNELS. THE SWPPP PLAN DRAWING SHALL BE UPDATED TO SHOW THE LOCATION OF

20. VEHICLE FUELING AND MAINTENCE AREA SHALL BE LOCATED AWAY FROM WATERCOURSES, DRAINAGE DITCHES, FIELD DRAINS OR OTHER STORM WATER AREAS.

21. CONTRACTOR SHALL BE LIMITED TO THE FOLLOWING STORAGE TANKS FOR SUPPORT OF CONSTRUCTION ACTIVITIES: SINGLE ABOVE GROUND STORAGE TANKS SHALL BE LESS THAN 660 GALLONS AND TOTAL OF ABOVE GROUND STORAGE TANKS SHALL BE LESS THAN 1330 GALLONS. BELOW GROUND STORAGE TANKS SHALL NOT BE PERMITTED FOR SUPPORT OF CONSTRUCTION ACTIVITES.

22. IF CONTAMINATED SOILS ARE FOUND ONE OF THE FOLLOWING PRACTICES SHALL BE FOLLOWED BY THE CONTRACTOR TO PRVENT CONTAMINATION FROM BEING RELEASED: A. THE USE OF BERMS, TRENCHES AND PITS TO COLLECT CONTAMINATED RUNOFF; B. THE PUMPING OF RUNOFF INTO A SANITARY SEWER (CONTRACTOR SHALL OBTAIN ALL NECESSARY PERMITS AND APPROVALS PRIOR TO COMMENCING PUMPING ACTIVITIES INTO S SANITARY SEWER) OR INTO A CONTAINER FOR TRANSPORT TO AN APPROPRIATE TREATMENT/DISPOSAL FACILITY; C. COVERING AREAS OF CONTAMINATION WITH TARPS OR OTHER METHODS THAT PREVENT STORM WATER FROM COMING INTO CONTACT WITH THE

23. SPILLS OF LESS THAN 25 GALLONS OF PETROLEUM PRODUCT AND SOIL FOUND TO BE CONTAMINATED SHALL BE PROPERLY DISPOSED OFF-SITE AT AN OHIO EPA APPROVED SOLID WASTE MANAGEMENT FACILITY OR HAZARDOUS WASTE TREATMENT, STORAGE OR DISPOSAL FACILITY PER LOCAL, STATE AND FEDERAL REGULATIONS. PETROLEUM BASED AND CONCRETE CURING COMPOUNDS MUST HAVE SPECIAL HANDLING PROCEDURES.

24. PETROLEUM PRODUCT SPILLS OF 25 GALLONS OR GREATER AND ALL SPILLS WHICH RESULT IN CONTACT WITH WATERS OF THE STATE SHALL BE REPORTED TO THE OHIO EPA'S SPILL HOTLINE (1-800-282-9378), THE LOCAL FIRE DEPARTMENT AND THE LOCAL EMERGENCY PLANNING COMMITTEE WITHIN 30 MINUTES OF THE DISCOVERY OF A RELEASE.

25. OPEN BURNING IS PROHIBITED AT THE CONSTRUCTION SITE.

TO SHOW THE LOCATION OF THESE AREAS.

26. CONTRACTOR SHALL OBTAIN ALL AIR POLLTUION PERMITS AS REQUIRED FOR THEIR PROPOSED OPERATIONS AND

27. FOR RESTORATION OR DEMOLITION PROJECTS THE CONTRACTOR SHALL NOTIFY THE OHIO EPA, DIVISION OF AIR POLLUTION CONTROL AS NECESSARY TO DETERMINE IF ASBESTOS CORRECTIVE ACTIONS ARE REQUIRED.

28. CONTRACTOR SHALL KEEP THE SITE IN A NEAT CONDITION WITH ADJACENT ROADS KEPT FREE OF DIRT AND DEBRIS AT ALL TIMES. CONTRACTOR SHALL USE PROTECTED STORAGE AREAS FOR INDUSTRIAL OR CONSTRUCTION MATERIALS AS NECESSARY TO PROTECT THEM FROM EXPOSURE TO STORM WATER.

THE CONTRACTOR SHALL PROVIDE REGULAR INSPECTION AND MAINTENANCE FOR ALL EROSION CONTROL PRACTICES AND DISTURBED AREAS. PROVIDE NAME OF INSPECTOR, MAJOR OBSERVATIONS, DATE OF INSPECTION, CERTIFICATION OF COMPLIANCE AND CORRECTIVE MEASURES TAKEN. CONTRACTOR SHALL USE A CONSTRUCTION INSPECTION CHECKLIST MEETING THE REQUIREMENTS OF THE OHIO EPA PERMIT AND LOCAL REVIEWING AGENCIES. CHECKLIST SHALL BE COMPLETED AND SIGNED BY THE INSPECTOR AFTER EVERY INSPECTION.

THE CONTRACTOR SHALL SUBMIT THE NAME OF THE QUALIFIED INSPECTION PERSONNEL RESPONSIBLE FOR CONDUCTING THE WEEKLY AND EVENT EROSION CONTROL INSPECTIONS OF THE CONSTRUCTION SITE TO THE OWNER AND GOVERNMENT SWP3 INSPECTION AGENCY PRIOR TO COMMENCING CONSTRUCTION ACTIVITIES.

1. INSPECTIONS MUST BE MADE A MINIMUM OF ONCE EVERY 7 DAYS AND IMMEDIATELY AFTER STORM EVENTS GREATER THAN 0.5 INCHES IN A 24 HOUR PERIOD.

- 2. ALL INSPECTIONS SHALL BE COMPLETED BY THE CONTRACTOR'S QUALIFIED PERSONNEL
- 3. CONTRACTOR'S INSPECTOR SHALL FILL IN THE INSPECTION LOG AFTER EACH INSPECTION (SEE APPENDIX)

4. CONTRACTOR SHALL MAINTAIN PERMANENT RECORDS OF MAINTENANCE AND INSPECTIONS THROUGHOUT CONSTRUCTION AND FOR A PERIOD OF 3 YEARS AFTER TERMINATION OF CONSTRUCTION ACTIVITIES.

- 5. CONTINUOUS MAINTENANCE WILL BE REQUIRED AS NECESSARY UNTIL PERMANENT, STABLE VEGETATIVE COVER HAS BEEN ESTABLISHED AND EROSION HAS BEEN CONTROLLED. THIS INCLUDES BUT IS NOT LIMITED TO RESEEDING, MULCHING, EARTH FILLING, ETC.
 - a.THE FOLLOWING ITEMS SHALL BE COMPLETED WITHIN 3 DAYS OF INSPECTION: REPAIR OR MAINTENANCE OF NON-SEDIMENT POND BMPS
- b. THE FOLLOWING ITEMS SHALL BE COMPLETED WITHIN 10 DAYS OF INSPECTION: CONSTRUCTION/INSTALLATION OF NEW AND MISSING BMPS, REPAIR AND/OR CLEAN-OUT OF SEDIMENT PONDS
- 6. THE SWP3 INSPECTION FREQUENCY MAY BE REDUCED TO MONTHLY FOR DORMANT SITES IF: a. THE ENTIRE SITE IS TEMPORARILY STABILIZED OR

b.RUNOFF IS UNLIKELY DUE TO WEATHER CONDITIONS FOR EXTENDED PERIODS OF TIME

NOTICE CONTRACTOR SHALL INSTALL INLET PROTECTION IN ALL CATACH BASINS RECEIVING CONSTRUCTION STORM WATER RUNOFF AND SHALL INSTALL SILT FENCE ALONG ALL GRASS AREAS WHERE CONSTRUCTION STORM WATER

CONTRACTOR SHALL PROVIDE, MAINTAIN AND AT THE COMPLETION OF THE PROJECT REMOVE A CONCRETE WASH-OUT PIT

LEAVES THE CONSTRUCTION LIMITS

CONCRETE **WASH-OUT**

 CONCRETE TRUCKS SHALL WASH-OUT THEIR EQUIPMENT SO THAT ALL WASTE WATERS ARE DIRECTED INTO THE CONCRETE WASH-OUT PIT. 2. CONCRETE WASH-OUT SHALL BE CONSTRUCTED PRIOR TO PLACING

CONCRETE ON SITE.

3. CONTRACTOR SHALL PROVIDE A VINYL WASH-OUT CONTAINER OF APPROPRIATE SIZE TO BE USED FOR THE CONCRETE WASH-OUT. CONTAINER AND ALL WASH-OUT MATERIAL SHALL BE REMOVED AND PROPERLY DISPOSED OF OFF-SITE BY THE CONTRACTOR.

SPECIFICATIONS FOR PERMANENT SEEDING

COMPACTION AND ALLOW MAXIMUM INFILTRATION. (MAXIMIZING INFILTRATION WILL HELP CONTROL BOTH RUNOFF RATE AND WATER QUALITY.) SUBSOILING SHOULD BE DONE WHEN THE SOIL MOISTURE IS LOW ENOUGH TO ALLOW THE SOIL TO CRACK OF FRACTURE. SUBSOILING SHOULD NOT BE DONE ON SLIP-PRONE AREAS WHERE SOIL PREPARATION SHOULD BE LIMITED TO WHAT IS NECESSARY FOR ESTABLISHING

2. THE SITE SHALL BE GRADED AS NEEDED TO PERMIT THE USE OF CONVENTIONAL EQUIPMENT FOR SEEDBED PREPARATION AND SEEDING. 3. RESOIL SHALL BE APPLIED WHERE NEEDED TO ESTABLISH VEGETATION.

1. LIME—AGRICULTURAL GROUND LIMESTONE SHALL BE APPLIED TO ACID SOIL AS RECOMMENDED BY A SOIL TEST. IN LIEU OF A SOIL TEST, LIME SHALL BE APPLIED

AT THE RATE OF 100 LB./1,000 SQ. FT. OR 2 TONS/AC. 2. FERTILIZER—FERTILIZER SHALL BE APPLIED AS RECOMMENDED BY A SOIL TEST. IN LIEU OF A SOIL TEST, FERTILIZER SHALL BE APPLIED AT A RATE OF 12 LB./1,000 SQ. FT. OR 500 LB./AC. OF 10-10-10 OR 12-12-12 ANALYSIS. HARROW, SPRING-TOOTHED HARROW, OR OTHER SUITABLE FIELD IMPLEMENT TO A

DEPTH OF 3 IN. ON SLOPING LAND, THE SOIL SHALL BE WORKED ON THE CONTOUR.

SEEDING DATES AND SOIL CONDITIONS

1. SEEDING SHALL BE DONE MARCH 1 TO MAY 31 OR AUGUST 1 TO SEPTEMBER
30. THESE SEEDING DATES ARE IDEAL BUT, WITH THE USE OF ADDITIONAL MULCH AND IRRIGATION, SEEDINGS MAY BE MADE ANY TIME THROUGHOUT THE GROWING SEASON. TILLAGE/SEEDBED PREPARATION SHOULD BE DONE WHEN THE SOIL IS DRY ENOUGH TO CRUMBLE AND NOT FORM RIBBONS WHEN COMPRESSED BY HAND. FOR WINTER SEEDING, SEE THE FOLLOWING SECTION ON DORMANT SEEDING.

SEEDINGS SHALL NOT BE PLANTED FROM OCTOBER 1 THROUGH NOVEMBER 20. DURING THIS PERIOD THE SEEDS ARE LIKELY TO GERMINATE, BUT PROBABLY WILL NOT BE ABLE TO SURVIVE THE WINTER.

2. THE FOLLOWING METHODS MAY BE USED FOR "DORMANT SEEDING":

-FROM OCTOBER 1 TO NOVEMBER 20, PREPARE THE SEEDBED, ADD THE REQUIRED AMOUNTS OF LIME AND FERTILIZER, THEN MULCH AND ANCHOR. AFTER NOVEMBER 20, AND BEFORE MARCH 15, BROADCAST THE SELECTED SEED MIXTURE. INCREASE THE SEEDING RATES BY 50% -FROM NOVEMBER 20 THROUGH MARCH 15, WHEN SOIL CONDITIONS PERMIT, PREPARE THE SEEDBED, LIME AND FERTILIZE, APPLY THE

SELECTED SEED MIXTURE, MULCH AND ANCHOR. INCREASE THE SEEDING RATES BY 50% FOR THIS TYPE OF SEEDING. -APPLY SEED UNIFORMLY WITH A CYCLONE SEEDER, DRILL, CULTIPACKER

SEEDER, OR HYDRO-SEEDER (SLURRY MAY INCLUDE SEED AND FERTILIZER) ON A FIRM, MOIST SEEDBED. -WHERE FEASIBLE. EXCEPT WHEN A CULTIPACKER TYPE SEEDER IS USED, THE SEEDBED SHOULD BE FIRMED FOLLOWING SEEDING OPERATIONS WITH A CULTIPACKER, ROLLER, OR LIGHT DRAG. ON SLOPING LAND, SEEDING OPERATION SHOULD BE ON THE CONTOUR

MULCHING

MULCH SHALL CONSIST OF THE FOLLOWING NOTICE: STRAW MATTING SHALL NOT BE USED; ONLY ORGANIC MATERIAL TO BE

TONS/ACRE OR 90 LB/1,000 SQ FT (TWO TO THREE BALES). THE STRAW MULCH SHALL BE SPREAD UNIFORMLY BY HAND OR MECHANICALLY SO THE SURFACE IS COVERED. FOR UNIFORM DISTRIBUTION OF HAND—SPREAD MILLOW DIVIDE ADEA TO THE SURFACE IS COVERED. FOR UNIFORM DISTRIBUTION OF HAND-SPREAD MULCH, DIVIDE AREA INTO APPROXIMATELY 1,000 SQ FT SECTIONS AND PLACE TWO 45 LB BALES OF STRAW IN

2. HYDROSEEDERS - WOOD CELLULOSE FIBER SHOULD BE USED AT 2,000 LB/ACRE OR 46 LB/1,000 SQ FT. MULCH SHALL BE ANCHORED BY THE FOLLOWING METHODS:

ANCHORED SHALL NOT BE FINELY CHOPPED BUT BE LEFT GENERALLY LONGER THAN 2. ASPHALT EMULSION - FOR STRAW MULCH, APPLY AT THE RATE OF 160 GAL/ACRE (0.1 GAL/SY) INTO THE MULCH AS IT IS BEING APPLIED OR AS

RECOMMENDED BY THE MANUFACTURER.

PUNCH OR ANCHOR THE MULCH MATERIAL INTO THE SOIL. STRAW MECHANICALLY

3. SYNTHETIC BINDERS - FOR STRAW MULCH, SYNTHETIC BINDERS SUCH AS ACRYLIC DLR (AGRI-TAC), DCA-70, PETROSET, TERRA TACK OR EQUAL MAY BE USED AT RATES RECOMMENDED BY THE MANUFACTURER.

4. WOOD CELLULOSE FIBER - FOR STRAW MULCH, APPLIED AT A DRY WEIGHT OF 750 LB/ACRE. THE WOOD CELLULOSE FIBER SHALL BE MIXED WITH WATER AND THE MIXTURE SHALL CONTAIN A MAXIMUM OF 50 LB/100 GAL OF WOOD CELLULOSE

SEED MIX	SEEDI	NG RATE	NOTES:
SEED MIX	LB./AC.	LB./1,000FT. ²	NOIES:
	GENEF	RAL USE	
CREEPING RED FESCUE	20-40	1/2-1	
DOMESTIC RYE GRASS	10-20	1/4-1/2	
KENTUCKY BLUEGRASS	10-20	1/4-1/2	
TALL FESCUE	40	1	
DWARF FESCUE	40	1	
STI	EEP BANKS	OR CUT SLOP	ES
TALL FESCUE	40	1	
CROWN VETCH	10	1/4	DO NOT SEED
TALL FESCUE	20	1/2	LATER THAN AUGUST.
FLAT PEA	20	1/2	DO NOT SEED
TALL FESCUE	20	1/2	LATER THAN AUGUST.
R	OAD DITCH	ES AND SWALE	s
TALL FESCUE	40	1	
DWARF FESCUE	90	2 1/4	
KENTUCKY BLUEGRASS	5		
	L	AWNS	
KENTUCKY BLUEGRASS	60	1 1/2	
PERENNIAL RYE GRASS	60	1 1/2	
KENTUCKY BLUEGRASS	60	1 1/2	FOR SHADED AREAS
CREEPING RED FESCUE	60	1 1/2	I ON SHADED AREAS

NOTE: OTHER APPROVED SEED SPECIES MAY BE SUBSTITUTED.

SILT FENCE

. THE HEIGHT OF A SILT FENCE SHALL NOT EXCEED 36 INCHES (HIGHER FENCES MAY IMPOUND VOLUMES OF WATER SUFFICIENT TO CAUSE FAILURE OF THE STRUCTURE).

THE FILTER FABRIC SHALL BE PURCHASED IN A CONTINUOUS ROLL CUT TO THE LENGTH OF THE BARRIER TO AVOID THE USE OF JOINTS. WHEN JOINTS ARE NECESSARY, FILTER CLOTH SHALL BE SPLICED TOGETHER ONLY AT A SUPPORT POST, WITH A MINIMUM 6-INCH OVERLAP, AND SECURELY SEALED.

3. POSTS SHALL BE SPACED A MAXIMUM OF 10 FEET APART AT THE BARRIER LOCATION AND DRIVEN SECURELY INTO THE GROUND (MINIMUM OF 12 INCHES). WHEN EXTRA STRENGTH FABRIC IS USED MITHOUT THE WIRE SUPPORT FENCE, POST SPACING SHALL NOT


4. A TRENCH SHALL BE EXCAVATED APPROXIMATELY 4 INCHES WIDE AND 6 INCHES DEEP ALONG THE LINE OF POSTS AND UPSLOPE FROM

. WHEN STANDARD STRENGTH FILTER FABRIC IS USED, A WIRE MESH SUPPORT FENCE SHALL BE FASTENED SECURELY TO THE UPSLOPE SIDE OF THE POSTS USING HEAVY DUTY WIRE STAPLES AT I FAST 1 INCH LONG. TIE WRES OR HOG RINGS. THE WRE SHALL EXTEND INTO THE TRENCH A MINIMUM OF 2 INCHES AND SHALL NOT EXTEND MORE THAN 36 INCHES ABOVE THE ORIGINAL GROUND SURFACE.

6. THE STANDARD STRENGTH FILTER FABRIC SHALL BE STAPLED OR WRED TO THE FENCE, AND 8 INCHES OF THE FABRIC SHALL BE EXTENDED INTO THE TRENCH. THE FABRIC SHALL NOT EXTEND MORE THAN 36 INCHES ABOVE THE ORIGINAL GROUND SURFACE. FILTER FABRIC SHALL NOT BE STAPLED TO EXISTING TREES.

WHEN EXTRA STRENGTH FILTER FABRIC AND CLOSER POS SPACING ARE USED, THE WIRE MESH SUPPORT FENCE MAY BE ELIMINATED. IN SUCH A CASE, THE FILTER FABRIC IS STAPLED OR WIRED DIRECTLY TO THE POSTS WITH ALL OTHER PROVISIONS OF ITEM NO.6 APPLYING.

THE TRENCH SHALL BE BACKFILLED AND SOIL COMPACTED OVER 9. SILT FENCES SHALL BE REMOVED WHEN THEY HAVE SERVED THEIR USEFUL PURPOSE, BUT NOT BEFORE THE UPSLOPE AREA HAS BEEN PERMANENTLY STABILIZED.

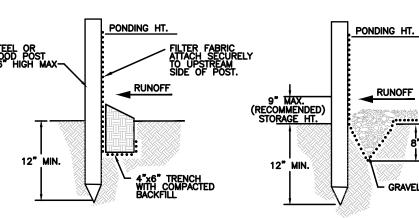

STANDARD DETAIL

NOTE: THE MAXIMUM DRAINAGE AREA BEHIND THE SILT FENCE SHALL NOT EXCEED: DRAINAGE AREA FOR 100 RANGE OF LINEAL FT. OF SILT FENCE SLOPE 0.5 ACRES (217.8' DEEP) 0.25 ACRES (108.9' DEEP) | ≥2% BUT <20%

0.125 ACRES (54.5' DEEP)


<u>ALTERNATE DETAIL</u>

INSPECT AND REPAIR FENCE AFTER EACH STORM EVENT AND REMOVE SEDIMENT WHEN SILT REACHES 1/3 TO 1/2 HEIGHT OF SILT

. REMOVED SEDIMENT SHALL BE DEPOSITED TO AN AREA THAT WILL NOT CONTRIBUTE SEDIMENT OFF—SITE AND CAN BE PERMANENTLY

3. SILT FENCE SHALL BE PLACED ON SLOPE CONTOURS TO MAXIMIZE PONDING EFFICIENCY. IT SHOULD ALSO BE CURVED TOWARDS THE

CONSTRUCTION ENTRANCE

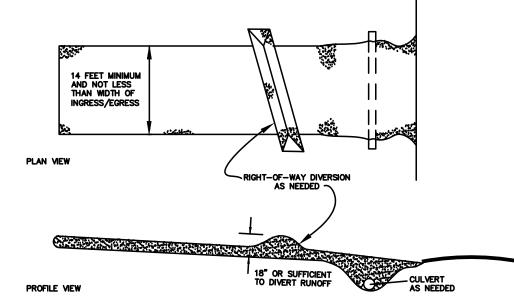

- 1. STONE SIZE--TWO INCH STONE SHALL BE USED. OR RECYCLED CONCRETE EQUIVALENT. 2. LENGTH--THE CONSTRUCTION ENTRANCE SHALL BE AS LONG AS REQUIRED TO STABILIZE HIGH
- 3. THICKNESS--THE STONE LAYER SHALL BE AT LEAST 6 INCHES THICK.

RESTRICTED FROM MUDDY AREAS.

4. WIDTH--THE ENTRANCE SHALL BE AT LEAST 14 FEET WIDE, BUT NOT LESS THAN THE FULL WIDTH AT POINTS WHERE INGRESS AND EGRESS OCCUR BEDDING--A GEOTEXTILE SHALL BE PLACED OVER THE ENTIRE AREA PRIOR TO PLACING STONE. IT

SHALL HAVE A GRAB TENSILE STRENGTH OF AT LEAST 200 LB. AND A MULLEN BURST STRENGTH OF AT

6. CULVERT -- A PIPE OR CULVERT SHALL BE CONSTRUCTED UNDER THE ENTRANCE IF NEEDED TO PREVENT SURFACE WATER FLOWING ACROSS THE ENTRANCE FROM BEING DIRECTED OUT ONTO PAVED

7. WATER BAR--A WATER BAR SHALL BE CONSTRUCTED AS PART OF THE CONSTRUCTION ENTRANCE IF NEEDED TO PREVENT SURFACE RUNOFF FROM FLOWING THE LENGTH OF THE CONSTRUCTION ENTRANCE AND OUT ONTO PAVED SURFACES. 8. MAINTENANCE——TOP DRESSING OF ADDITIONAL STONE SHALL BE APPLIED AS CONDITIONS DEMAND. MUD SPILLED, DROPPED, WASHED OR TRACKED ONTO PUBLIC ROADS, OR ANY SURFACE WHERE RUNOFF

IS NOT CHECKED BY SEDIMENT CONTROLS, SHALL BE REMOVED IMMEDIATELY. REMOVAL SHALL BE ACCOMPLISHED BY SCRAPING OR SWEEPING. 9. CONSTRUCTION ENTRANCES SHALL NOT BE RELIED UPON TO REMOVE MUD FROM VEHICLES AND PREVENT OFF-SITE TRACKING. VEHICLES THAT ENTER AND LEAVE THE CONSTRUCTION-SITE SHALL BE

O

VEER *

§ **≥**

4 ≧ □ Z ⊁ ⊀ ≥ 0

APPLICATION NO.

SCALE

DATE

GENERAL NOTES:

- 1. EXAMINE FINISH SURFACE, GRADES, TOPSOIL QUALITY AND DEPTH. DO NOT START ANY WORK UNTIL UNSATISFACTORY CONDITIONS HAVE BEEN CORRECTED. VERIFY LIMITS OF WORK BEFORE STARTING.
- 2. CONTRACTOR IS RESPONSIBLE FOR COST OF REPAIRS TO EXISTING CONDITIONS WHEN DAMAGED BY CONTRACTOR. REPAIR DAMAGES TO THE SATISFACTION OF THE OWNER.
- 3. CONTRACTOR IN SCOPE SHALL INCLUDE SOIL MOVED/FURNISHED/PLACED AND FINE GRADING AND PLANTINGS TO BE PROVIDED BY OWNER.
- 4. CONTRACTOR TO COORDINATE WITH ODNR TO PLANT WITHIN 1 WEEK OF SOILS INSTALLATION TO REDUCE RUNOFF AND LEACHING OF ORGANICS.
- 5. SEE CIVIL ENGINEERING FOR EROSION CONTROL.

SOILS CONSTRUCTION NOTES:


- 1 LOCKSTONE BENCH SEATING BY CONTRACTOR. LOCKSTONE IS TO BE RELOCATED FROM OFF-SITE LOCATION PROVIDED BY ODNR. UTILIZE LARGER STONES 18"-24" IN HGT. AND 36"-48" IN LENGTH AS SEATING ELEMENTS. CONTRACTOR TO SAW-CUT EXISTING LOCKSTONE TO WITHIN 6" OF LISTED SIZE. HOLD BOTTOM OF STONE 2-3" BELOW ADJACENT HARDSCAPE. PROVIDE MINIMUM 8" OF ODOT 304 AGGREGATE BELOW BASE WHEN NOT LOCATED ON CONCRETE. HAMMER SHARP CORNERS. CONFIRM SEATING ELEMENT PRIOR TO RELOCATION WITH ODNR. ITEM SHALL COVER RELOCATION, PLACEMENT, AND BASE MATERIAL.
- $\langle 2 \rangle$ LOCKSTONE VEHICLE BARRIER BY CONTRACTOR. STAGGER AND DRY-STACK 6" to 12" HGT. LOCKSTONE BEHIND CURB TO MATCH GRADES AS INDICATED IN PLANS. PROVIDE 8" OF COMPACTED ODOT 304 AGGREGATE BASE OVER COMPACTED SUBGRADE. ITEM SHALL COVER RELOCATION, PLACEMENT, AND BASE MATERIAL. SAW-CUT EXISTING LOCKSTONE TO WITHIN 6" OF LISTED SIZE. SEE DETAIL, THIS SHEET.
- $\overline{3}$ EXISTING BIKE RACK TO BE SALVAGED AND RELOCATED BY CONTRACTOR. SURFACE MOUNT TO CONCRETE WITH NEW STAINLESS STEEL HARDWARE. PAINT HARDWARE TO MATCH BIKE RACK COLOR.
- (4) LANDSCAPE BED AREA. CONTRACTOR TO PROVIDE MINIMUM DEPTH OF 18" DEPTH OF SOIL MIX. PLANTINGS TO BE COMPLETED BY OWNER.

CONTRACTOR TO UTILIZE EXISTING TOPSOIL STOCKPILE ON SITE. SPREAD TOPSOIL & AMEND WITH 2" DEPTH OF EPA RATED CLASS IV COMPOST AND TILLED TO A DEPTH OF 12" - MIX THOROUGHLY. THEN TOP-DRESS WITH 1" OF COMPOST OVER ENTIRE BED. STOCKPILE TOPSOIL SHALL BE AMENDED WITH CLASS 4 COMPOST. PER SOIL PROFILE DETAIL BELOW.

IF SOIL QUANTITIES ARE INSUFFICIENT, SUPPLEMENT WITH PLANTING SOIL PER SPECIFICATIONS.

HOLD TOP OF SOIL DOWN 3" FROM TOP OF CURB AND/OR ADJACENT PAVEMENT TO ALLOW FOR INSTALLATION OF MULCH BY OTHERS. PROVIDE POSITIVE DRAINAGE ACROSS ALL SURFACES.

Item	Quantity	Unit
BASE BID		
LOCKSTONE BENCH SEATS BY CONTRACTOR	6	EA
LOCKSTONE VEHICULAR BARRIER BY CONTRACTOR	8	EA
BIKE RACK RELOCATION BY CONTACTOR	1	EA
STOCKPILED TOP SOIL - PLACED & AMENDED BY OWNER	48	CY
MULCH BY OWNER	8	CY

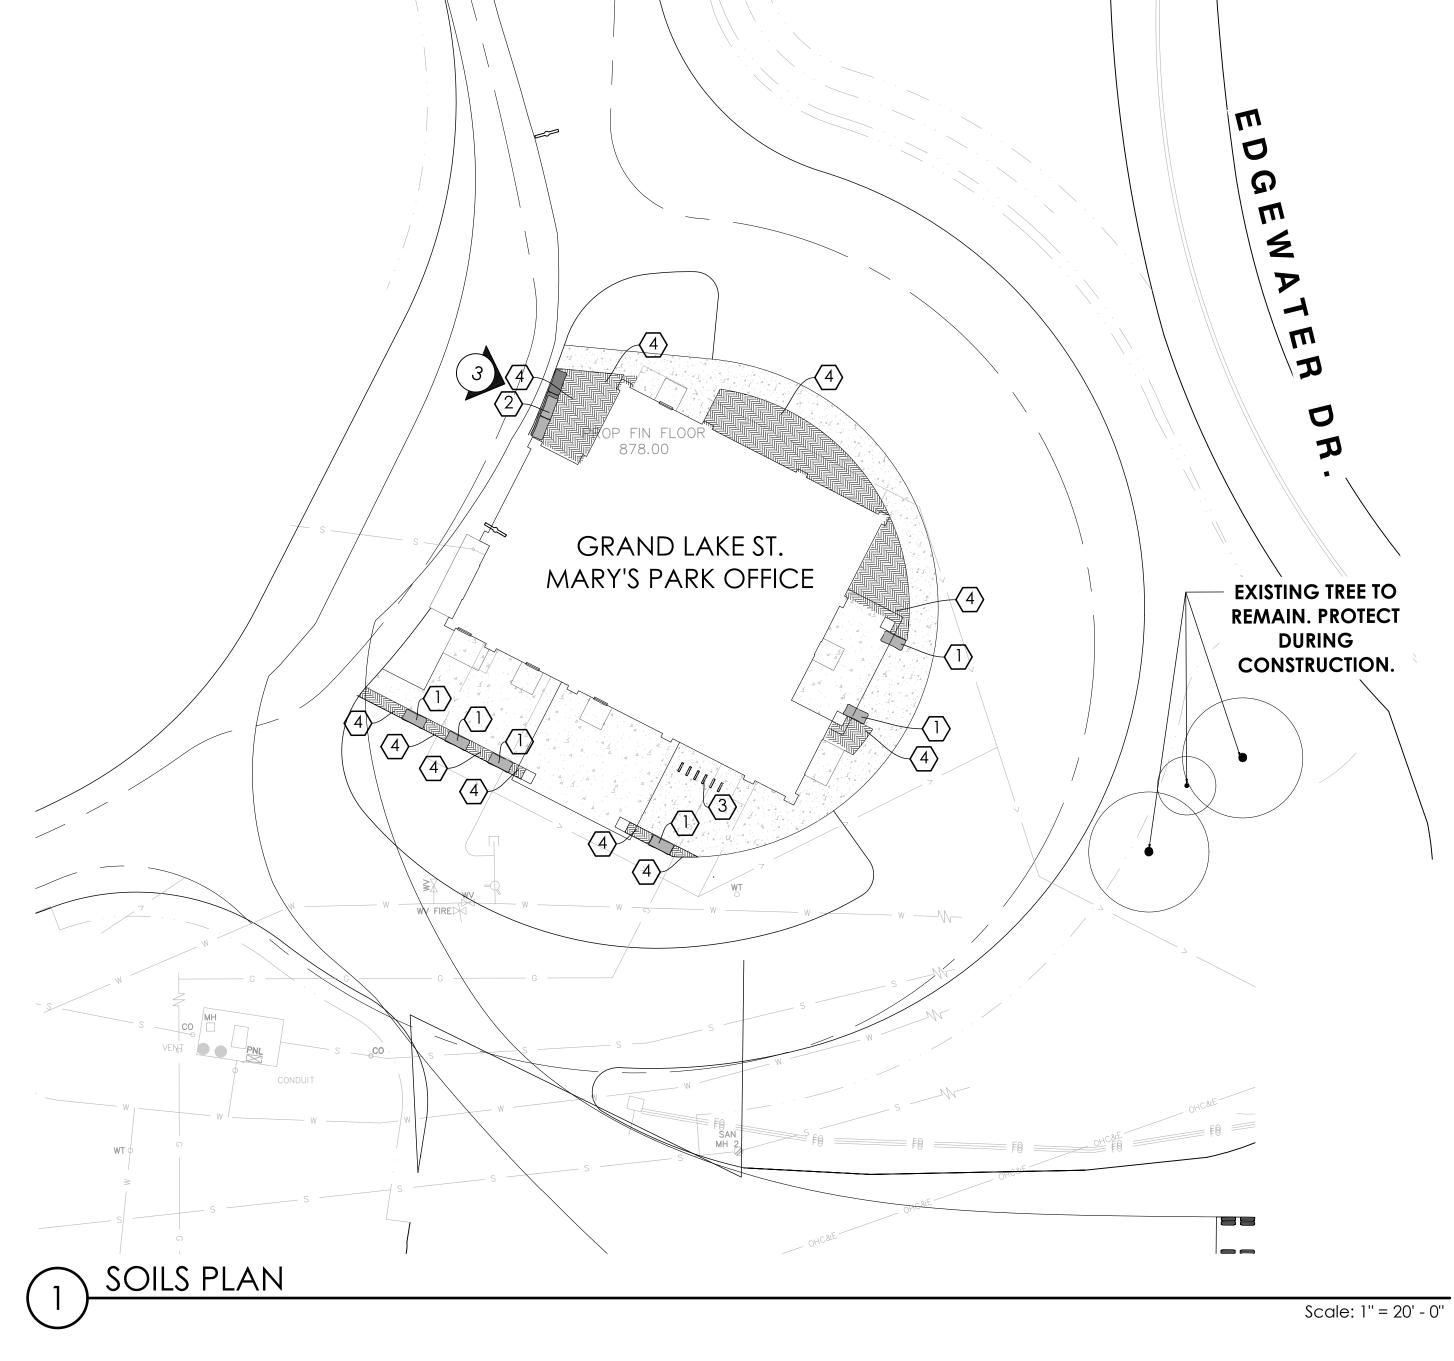

2" DEPTH OF COMPOST

6" OF THE SOIL PROFILE


STOCKPILED TOPSOIL

SUBGRADE

STOCKPILE TOPSOIL AMENDMENT DETAIL

SOILS PLAN LEGEND:

PLANTING SOIL MIX SEE SPECIFICATIONS

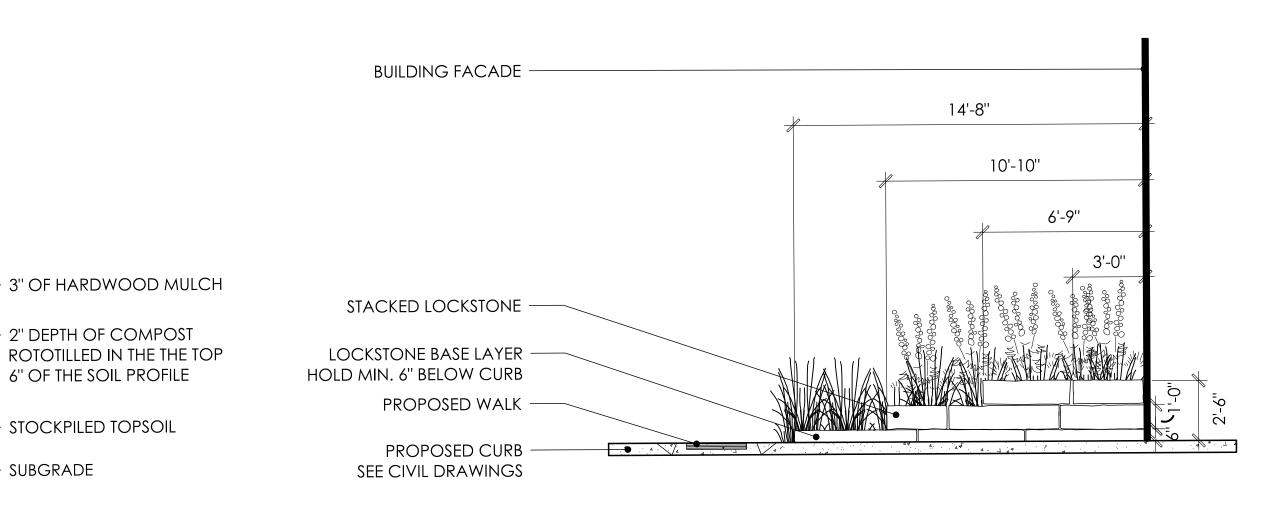

LOCKSTONE VEHICULAR BARRIER Scale: 1/4" = 1' - 0"

GRAND LAKE ST. MARYS STATE PARK PARK OFFICE

RENOVATION

33 South Michigan St. Suite 100 Toledo, Oh 43604 419.255.5335 www.edgela.com

OHIO DEPT. OF NATURAL RESOURCES


PROJECT NO. 250013


09-19-2025 Date:

CONSTRUCTION DOCUMENTS

REVISIONS

SOILS AND MATERIALS PLAN

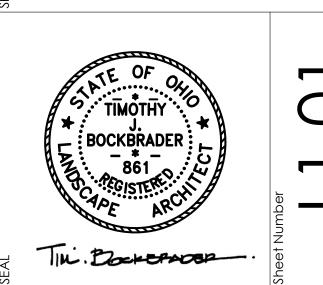

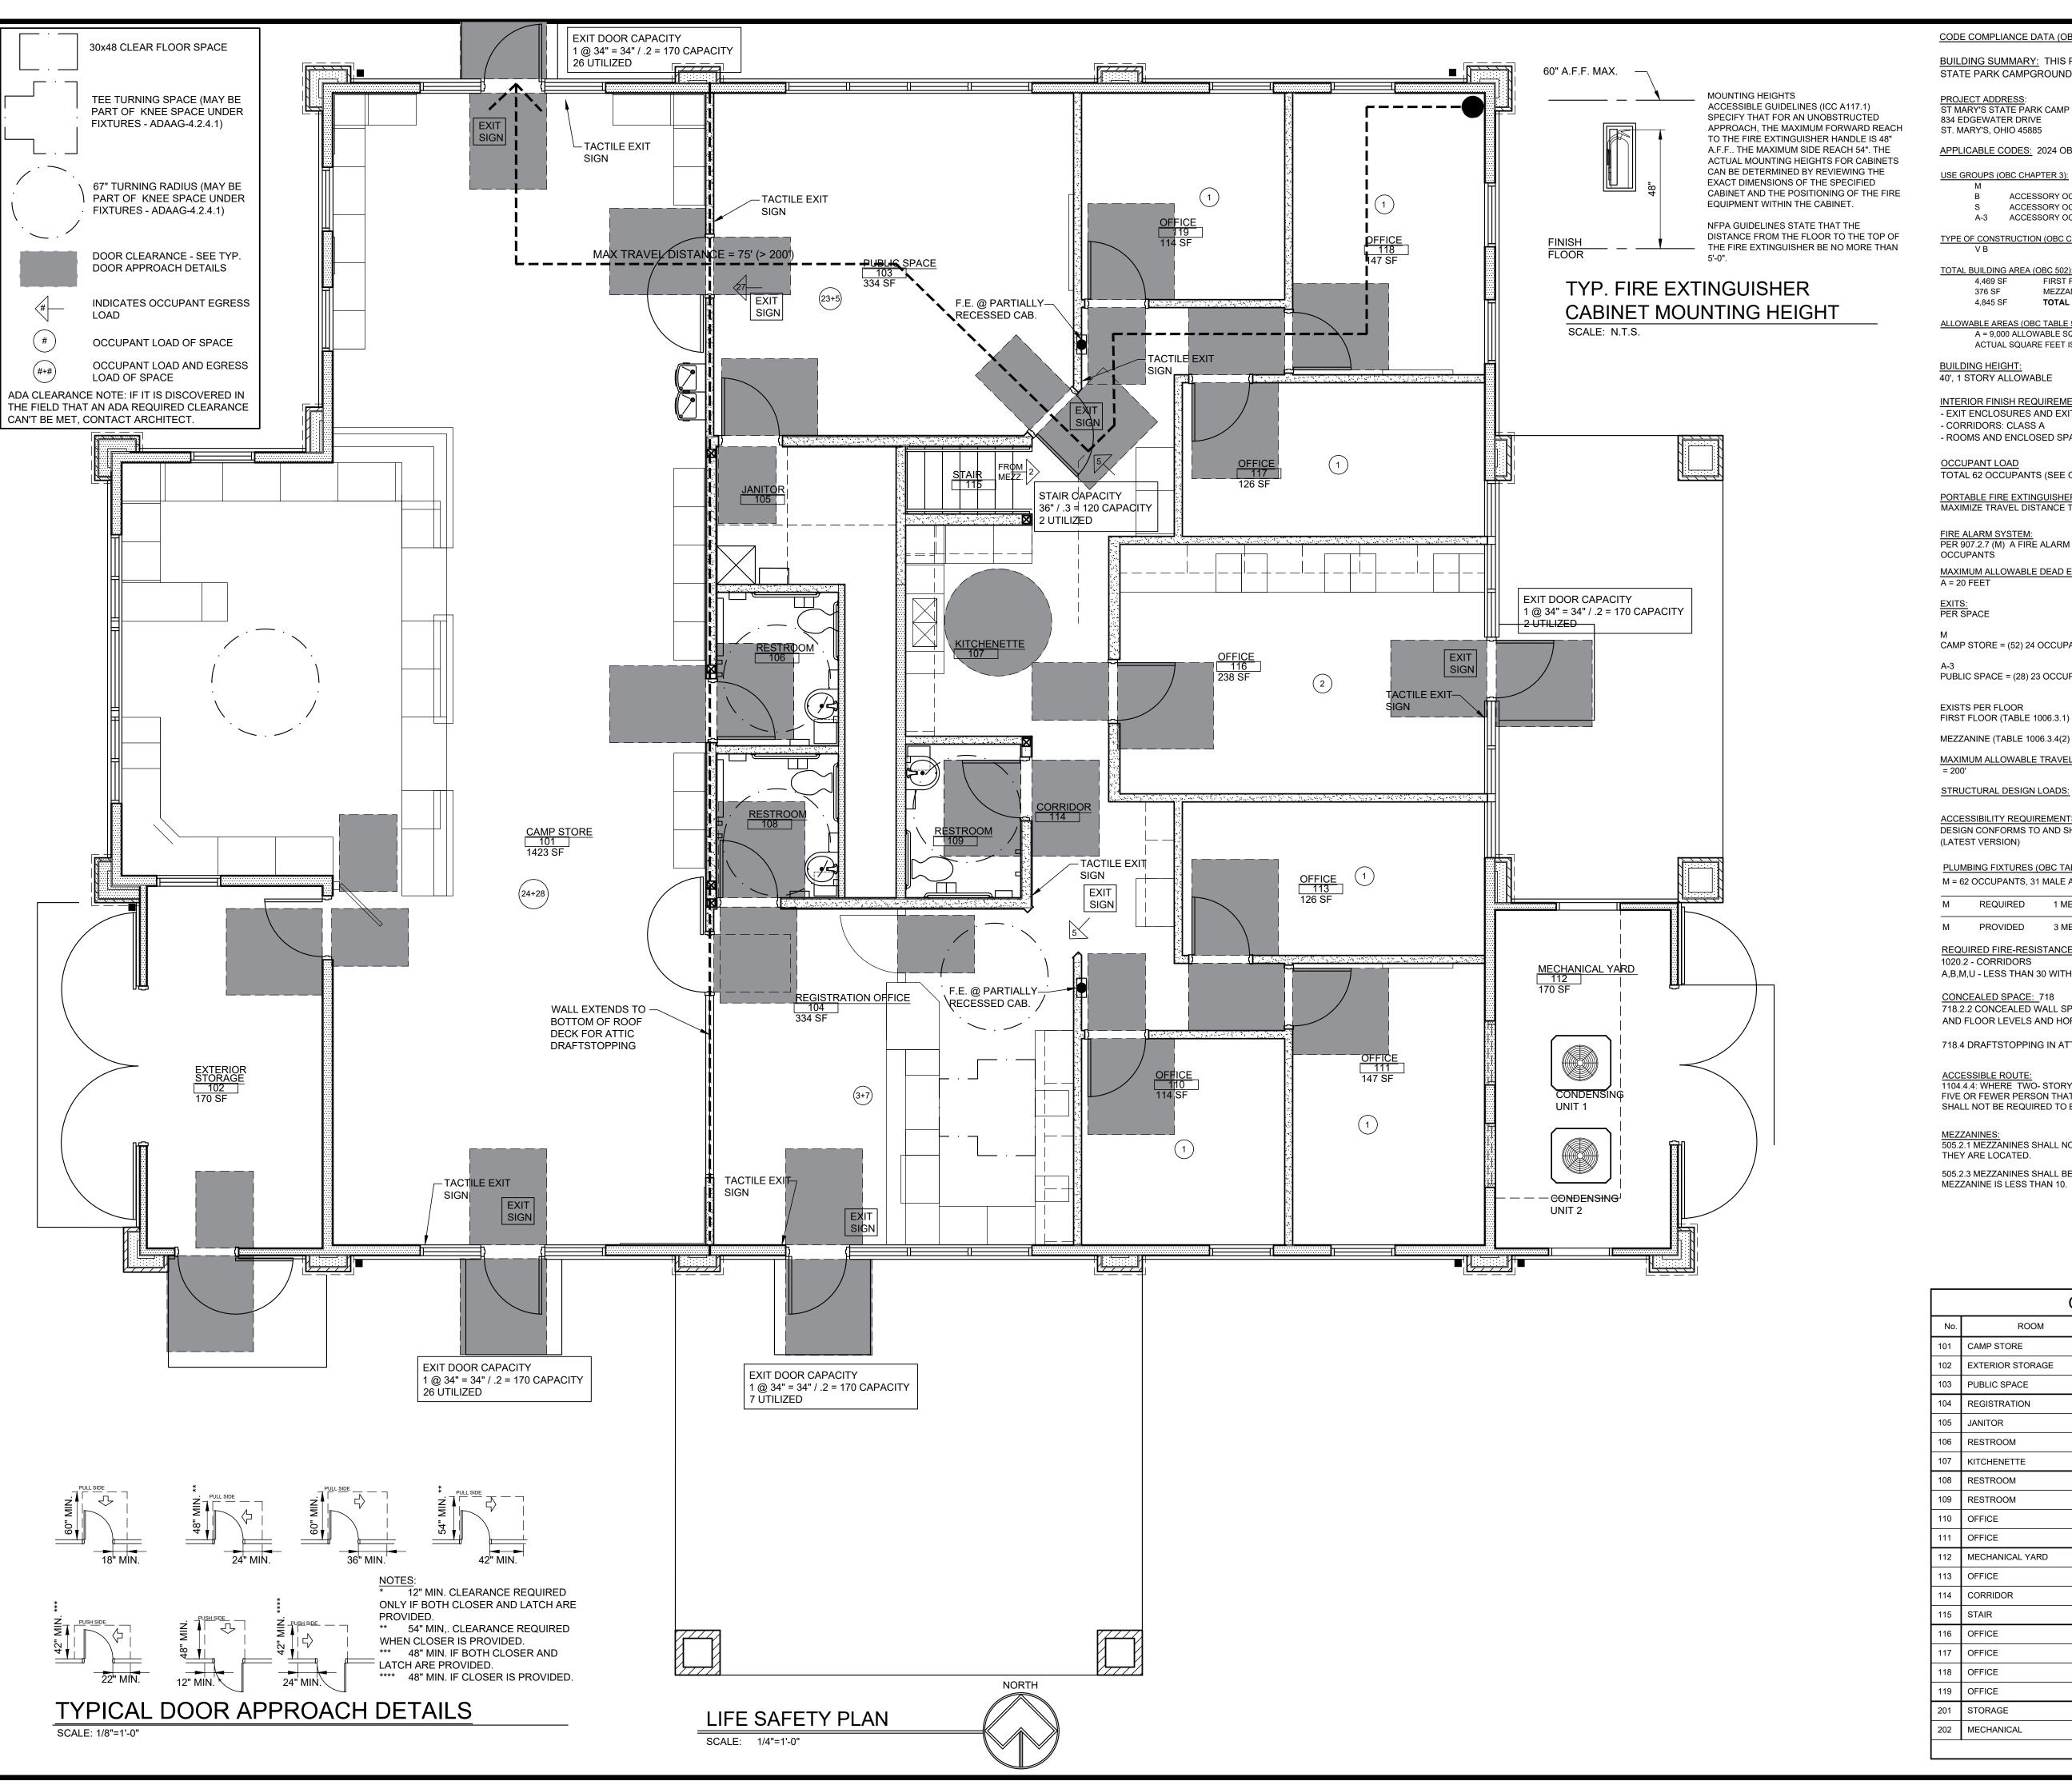

CODE COMPLIANCE DATA (OBC 2024)

BUILDING SUMMARY: THIS PROJECT INCLUDES A NEW CAMP STORE AND OFFICES FOR ST. MARY'S STATE PARK CAMPGROUND.

PROJECT ADDRESS: ST MARY'S STATE PARK CAMP STORE 834 EDGEWATER DRIVE

ST. MARY'S, OHIO 45885 APPLICABLE CODES: 2024 OBC, 2024 OMC, 2023 NEC, 2024 OPC, ANSI A117.1-2017, 2024 OHIO FIRE CODE

ACCESSORY OCCUPANCY S ACCESSORY OCCUPANCY
A-3 ACCESSORY OCCUPANCY

TYPE OF CONSTRUCTION (OBC CHAPTER 6)

TOTAL BUILDING AREA (OBC 502): 4,469 SF FIRST FLOOR 376 SF MEZZANINE

ALLOWABLE AREAS (OBC TABLE 506.2): A = 9,000 ALLOWABLE SQUARE FEET ACTUAL SQUARE FEET IS UNDER 9,000 SF

BUILDING HEIGHT: 40', 1 STORY ALLOWABLE

4,845 SF

INTERIOR FINISH REQUIREMENTS; TABLE 803.11 - EXIT ENCLOSURES AND EXIT PASSAGEWAYS: CLASS A

- CORRIDORS: CLASS A - ROOMS AND ENCLOSED SPACES : CLASS C

TOTAL 62 OCCUPANTS (SEE OCCUPANT CALCULATIONS)

PORTABLE FIRE EXTINGUISHERS:
MAXIMIZE TRAVEL DISTANCE TO PORTABLE FIRE EXTINGUISHER = 75'

FIRE ALARM SYSTEM:
PER 907.2.7 (M) A FIRE ALARM SYSTEM IS NOT REQUIRED FOR THIS BUILDING SINCE IT US UNDER 500

MAXIMUM ALLOWABLE DEAD END: 1020.4 A = 20 FEET

CAMP STORE = (52) 24 OCCUPANTS +28 EGRESS OCCUPANTS - 2 EXITS REQUIRED, 2 PROVIDED (TABLE 1006.2.1)

PUBLIC SPACE = (28) 23 OCCUPANTS + 5 EGRESS OCCUPANTS = 1 EXIT REQUIRED, 2 PROVIDED (TABLE 1006.2.1)

EXISTS PER FLOOR

FIRST FLOOR (TABLE 1006.3.1) - 2 EXITS REQUIRED, 5 PROVIDED

MEZZANINE (TABLE 1006.3.4(2) - 1 EXIT REQUIRED, 1 PROVIDED

MAXIMUM ALLOWABLE TRAVEL DISTANCE:1017.2

STRUCTURAL DESIGN LOADS: SEE STRUCTURAL DRAWINGS

DESIGN CONFORMS TO AND SHALL BE CONSTRUCTED TO CONFORM WITH OBC CHAPTER 11 AND ICC A117.1 (LATEST VERSION)

PLUMBING FIXTURES	(OBC TABLE 2902.1):
M = 62 OCCUPANTS 3	1 MALE AND 31 FEMALE

	,	W.C.	LAV.	D.F.	S.S.
М	REQUIRED	1 MEN, 1 WOMEN	1 MEN, 1 WOMEN	1	1
М	PROVIDED	3 MEN, 3 WOMEN	3 MEN, 3 WOMEN	1	1

REQUIRED FIRE-RESISTANCE RATING:

1020.2 - CORRIDORS A,B,M,U - LESS THAN 30 WITH NO SPRINKLER = NOT REQUIRED

CONCEALED SPACE: 718

718.2.2 CONCEALED WALL SPACES: FIREBLOCKING TO BE INSTALLED VERTICALLY AT CEILING AND FLOOR LEVELS AND HORIZONTALLY AT INTERVALS NOT EXCEEDING 10 FEET.

718.4 DRAFTSTOPPING IN ATTICS: REQUIRED WHEN ATTIC IS OVER 3,000 SF

ACCESSIBLE ROUTE: 1104.4.4: WHERE TWO- STORY BUILDING HAS ONE STORY OR MEZZANINE WITH AN OCCUPANT LOAD OF FIVE OR FEWER PERSON THAT DOES NOT CONTAIN PUBLIC USE SPACE, THAT STORY OR MEZZANINE SHALL NOT BE REQUIRED TO BE CONNECTED TO AN ACCESSIBLE ROUTE TO THE STORY ABOVE OR BELOW.

MEZZANINES: 505.2.1 MEZZANINES SHALL NOT BE GREATER THAN ONE THIRD THE FLOOR AREA OF THAT ROOM IN WHICH

505.2.3 MEZZANINES SHALL BE OPEN TO THE ROOM BELOW. EXCEPT WHEN THE OCCUPANT LOAD OF THE MEZZANINE IS LESS THAN 10.

OCCUPANT CALCULATIONS												
No.	ROOM	SIZE	USE	DENSITY	CALCULATION	OCCUP	ANTS					
101	CAMP STORE	1423 SF	М	60	1423 SF / 60 SF PER PERSON =	23.72	24					
102	EXTERIOR STORAGE	170 SF	S	300	170 SF / 300 SF PER PERSON =	.57	1					
103	PUBLIC SPACE	334 SF	A-3	15	334 SF / 15 SF PER PERSON =	22.26	23					
104	REGISTRATION	334 SF	В	150	334 SF / 150 SF PER PERSON =	2.23	3					
105	JANITOR				N/A	0	0					
106	RESTROOM				N/A	0	0					
107	KITCHENETTE				N/A	0	0					
108	RESTROOM				N/A	0	0					
109	RESTROOM				N/A	0	0					
110	OFFICE	114 SF	В	150	114 SF / 150 SF PER PERSON =	.76	1					
111	OFFICE	147 SF	В	150	147 SF / 150 SF PER PERSON =	.98	1					
112	MECHANICAL YARD	170 SF		300	170 SF / 300 SF PER PERSON =	.57	1					
113	OFFICE	126 SF	В	150	126 SF / 150 SF PER PERSON =	.84	1					
114	CORRIDOR				N/A	0	0					
115	STAIR				N/A	0	0					
116	OFFICE	238 SF	В	150	238 SF / 150 SF PER PERSON =	1.59	2					
117	OFFICE	128 SF	В	150	128 SF / 150 SF PER PERSON =	.85	1					
118	OFFICE	147 SF	В	150	147 SF / 150 SF PER PERSON =	.98	1					
119	OFFICE	114 SF	В	150	114 SF / 150 SF PER PERSON =	.76	1					
201	STORAGE	133 SF	S	300	133 SF / 300 SF PER PERSON =	.44	1					
202	MECHANICAL	136 SF	S	300	136 SF / 300 SF PER PERSON =	.45	1					
		•	тот	AL OCCUP	ANTS	•	62					



OFFICE 0 2 ARK


ering


REVISION SCHEDULE

ISSUE DATE: 09/19/2025 JOB NUMBER: 241224

CONSTRUCTION DOCUMENTS

LS100

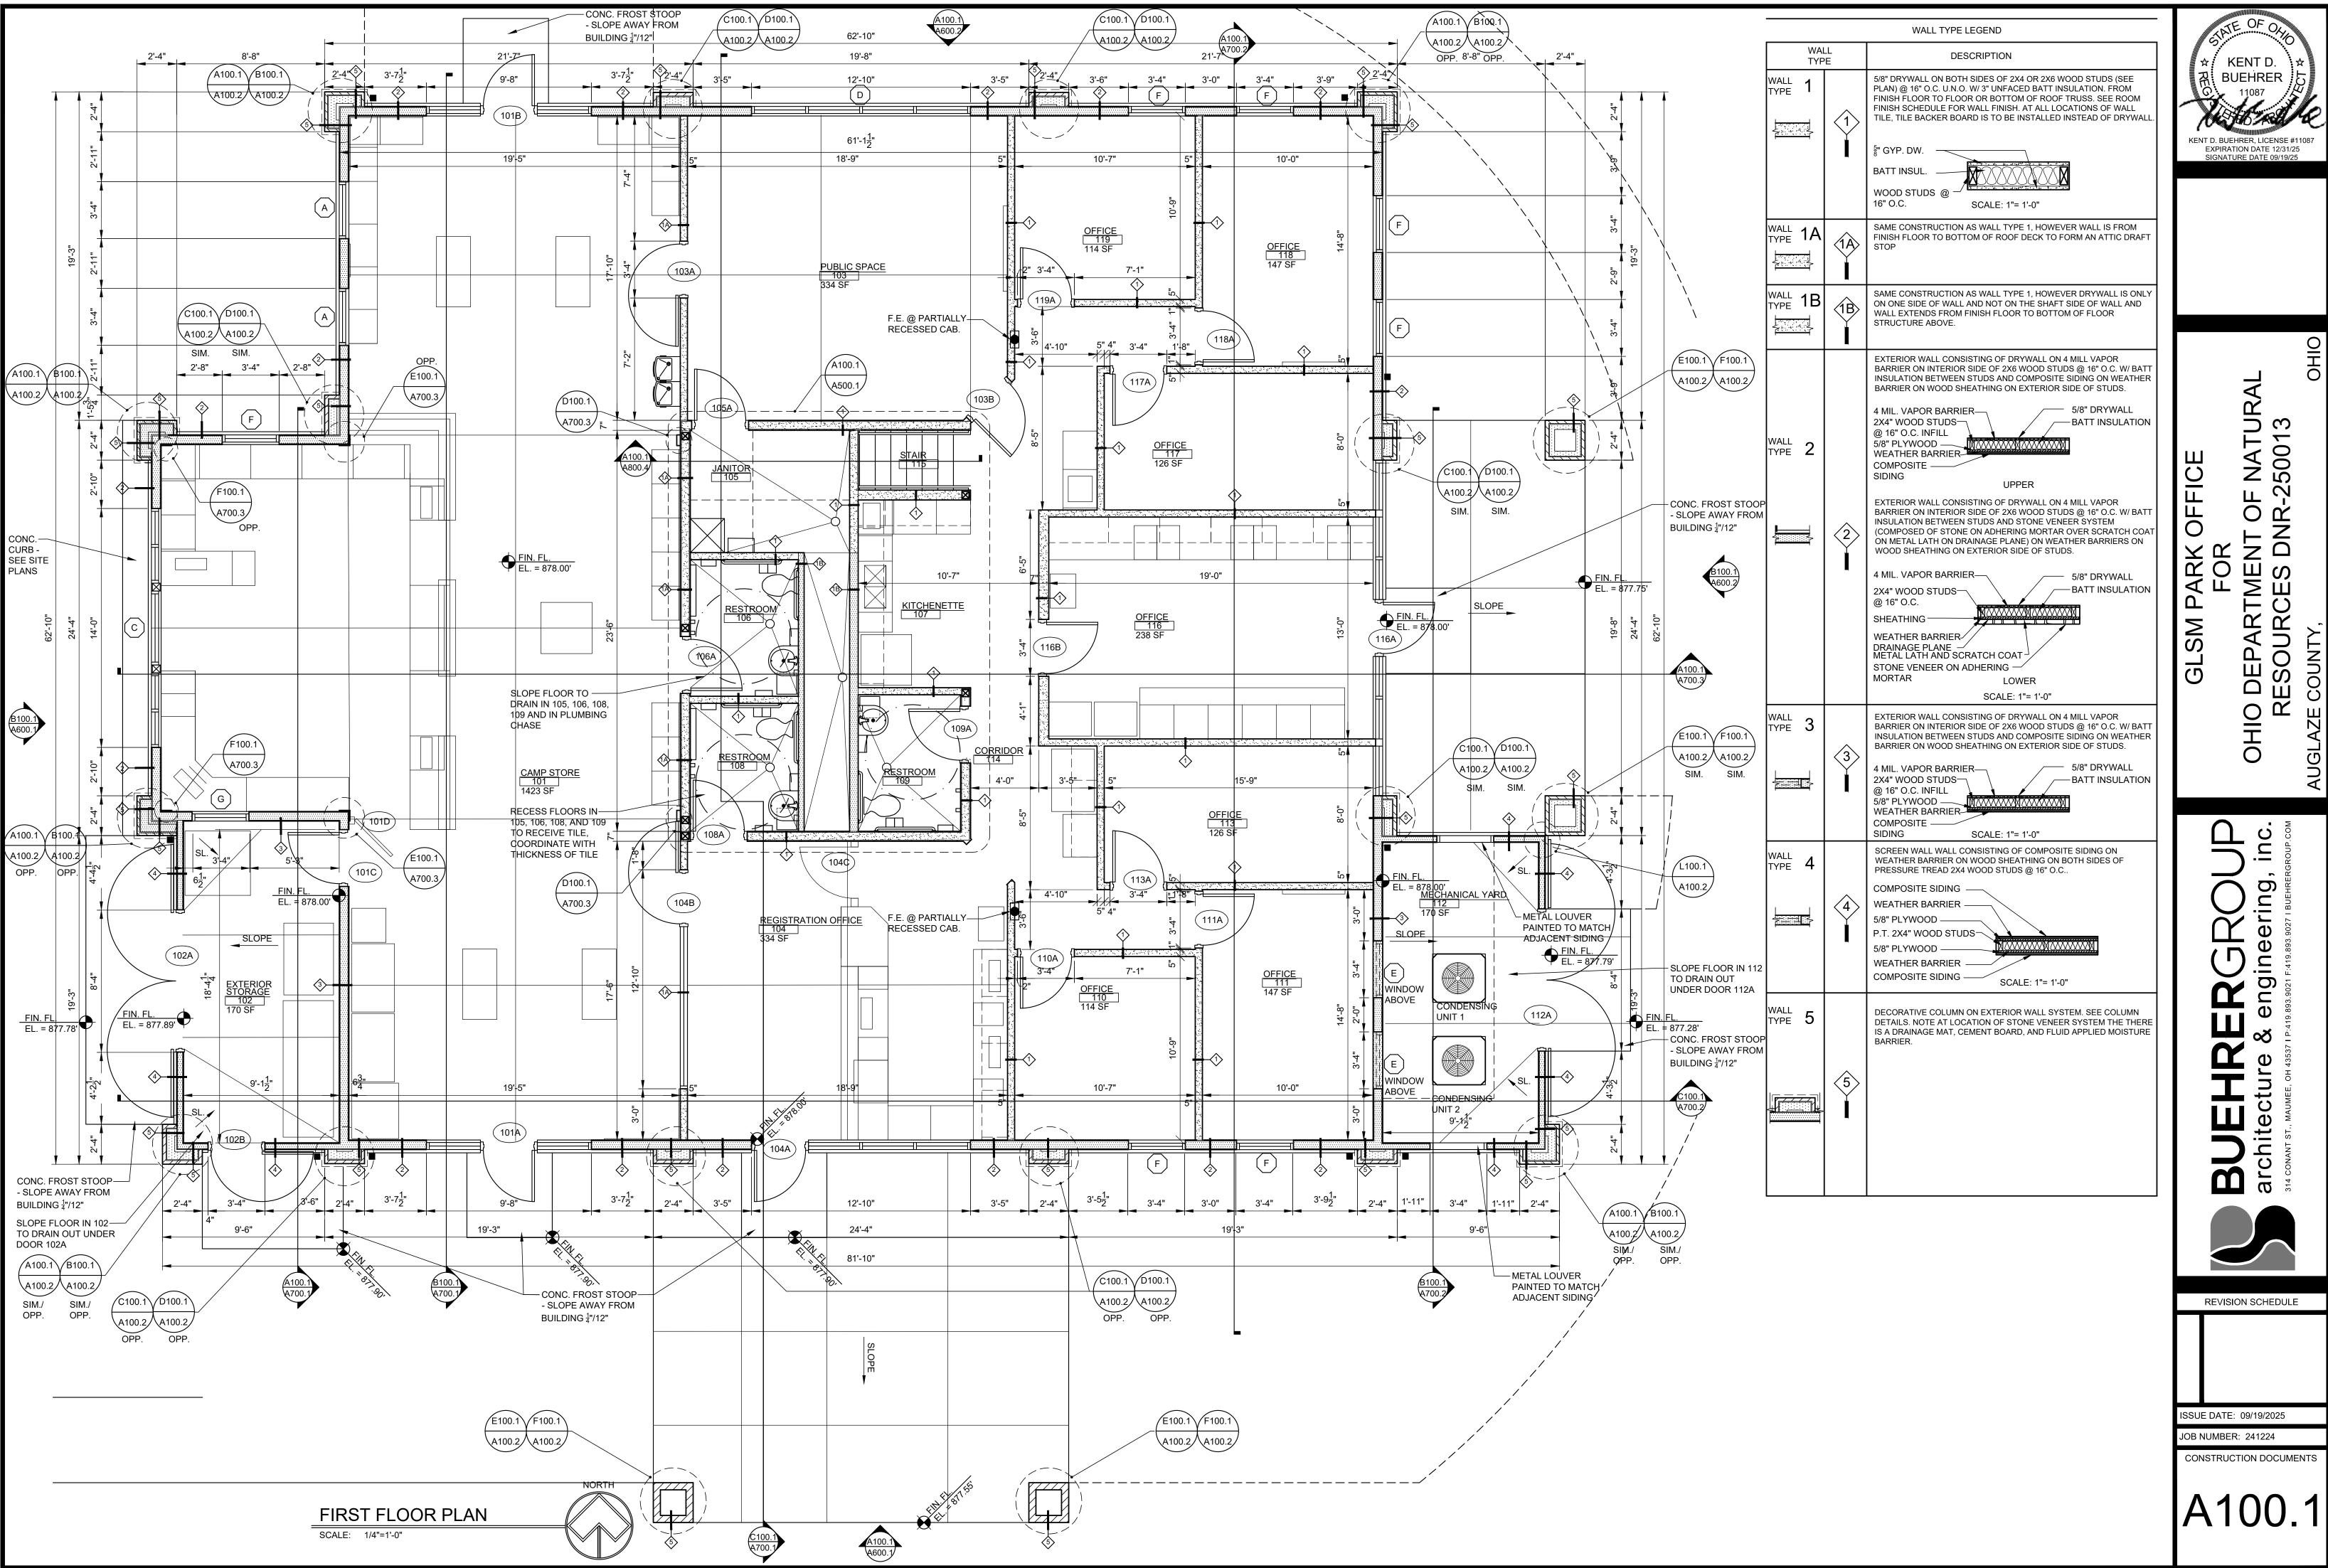

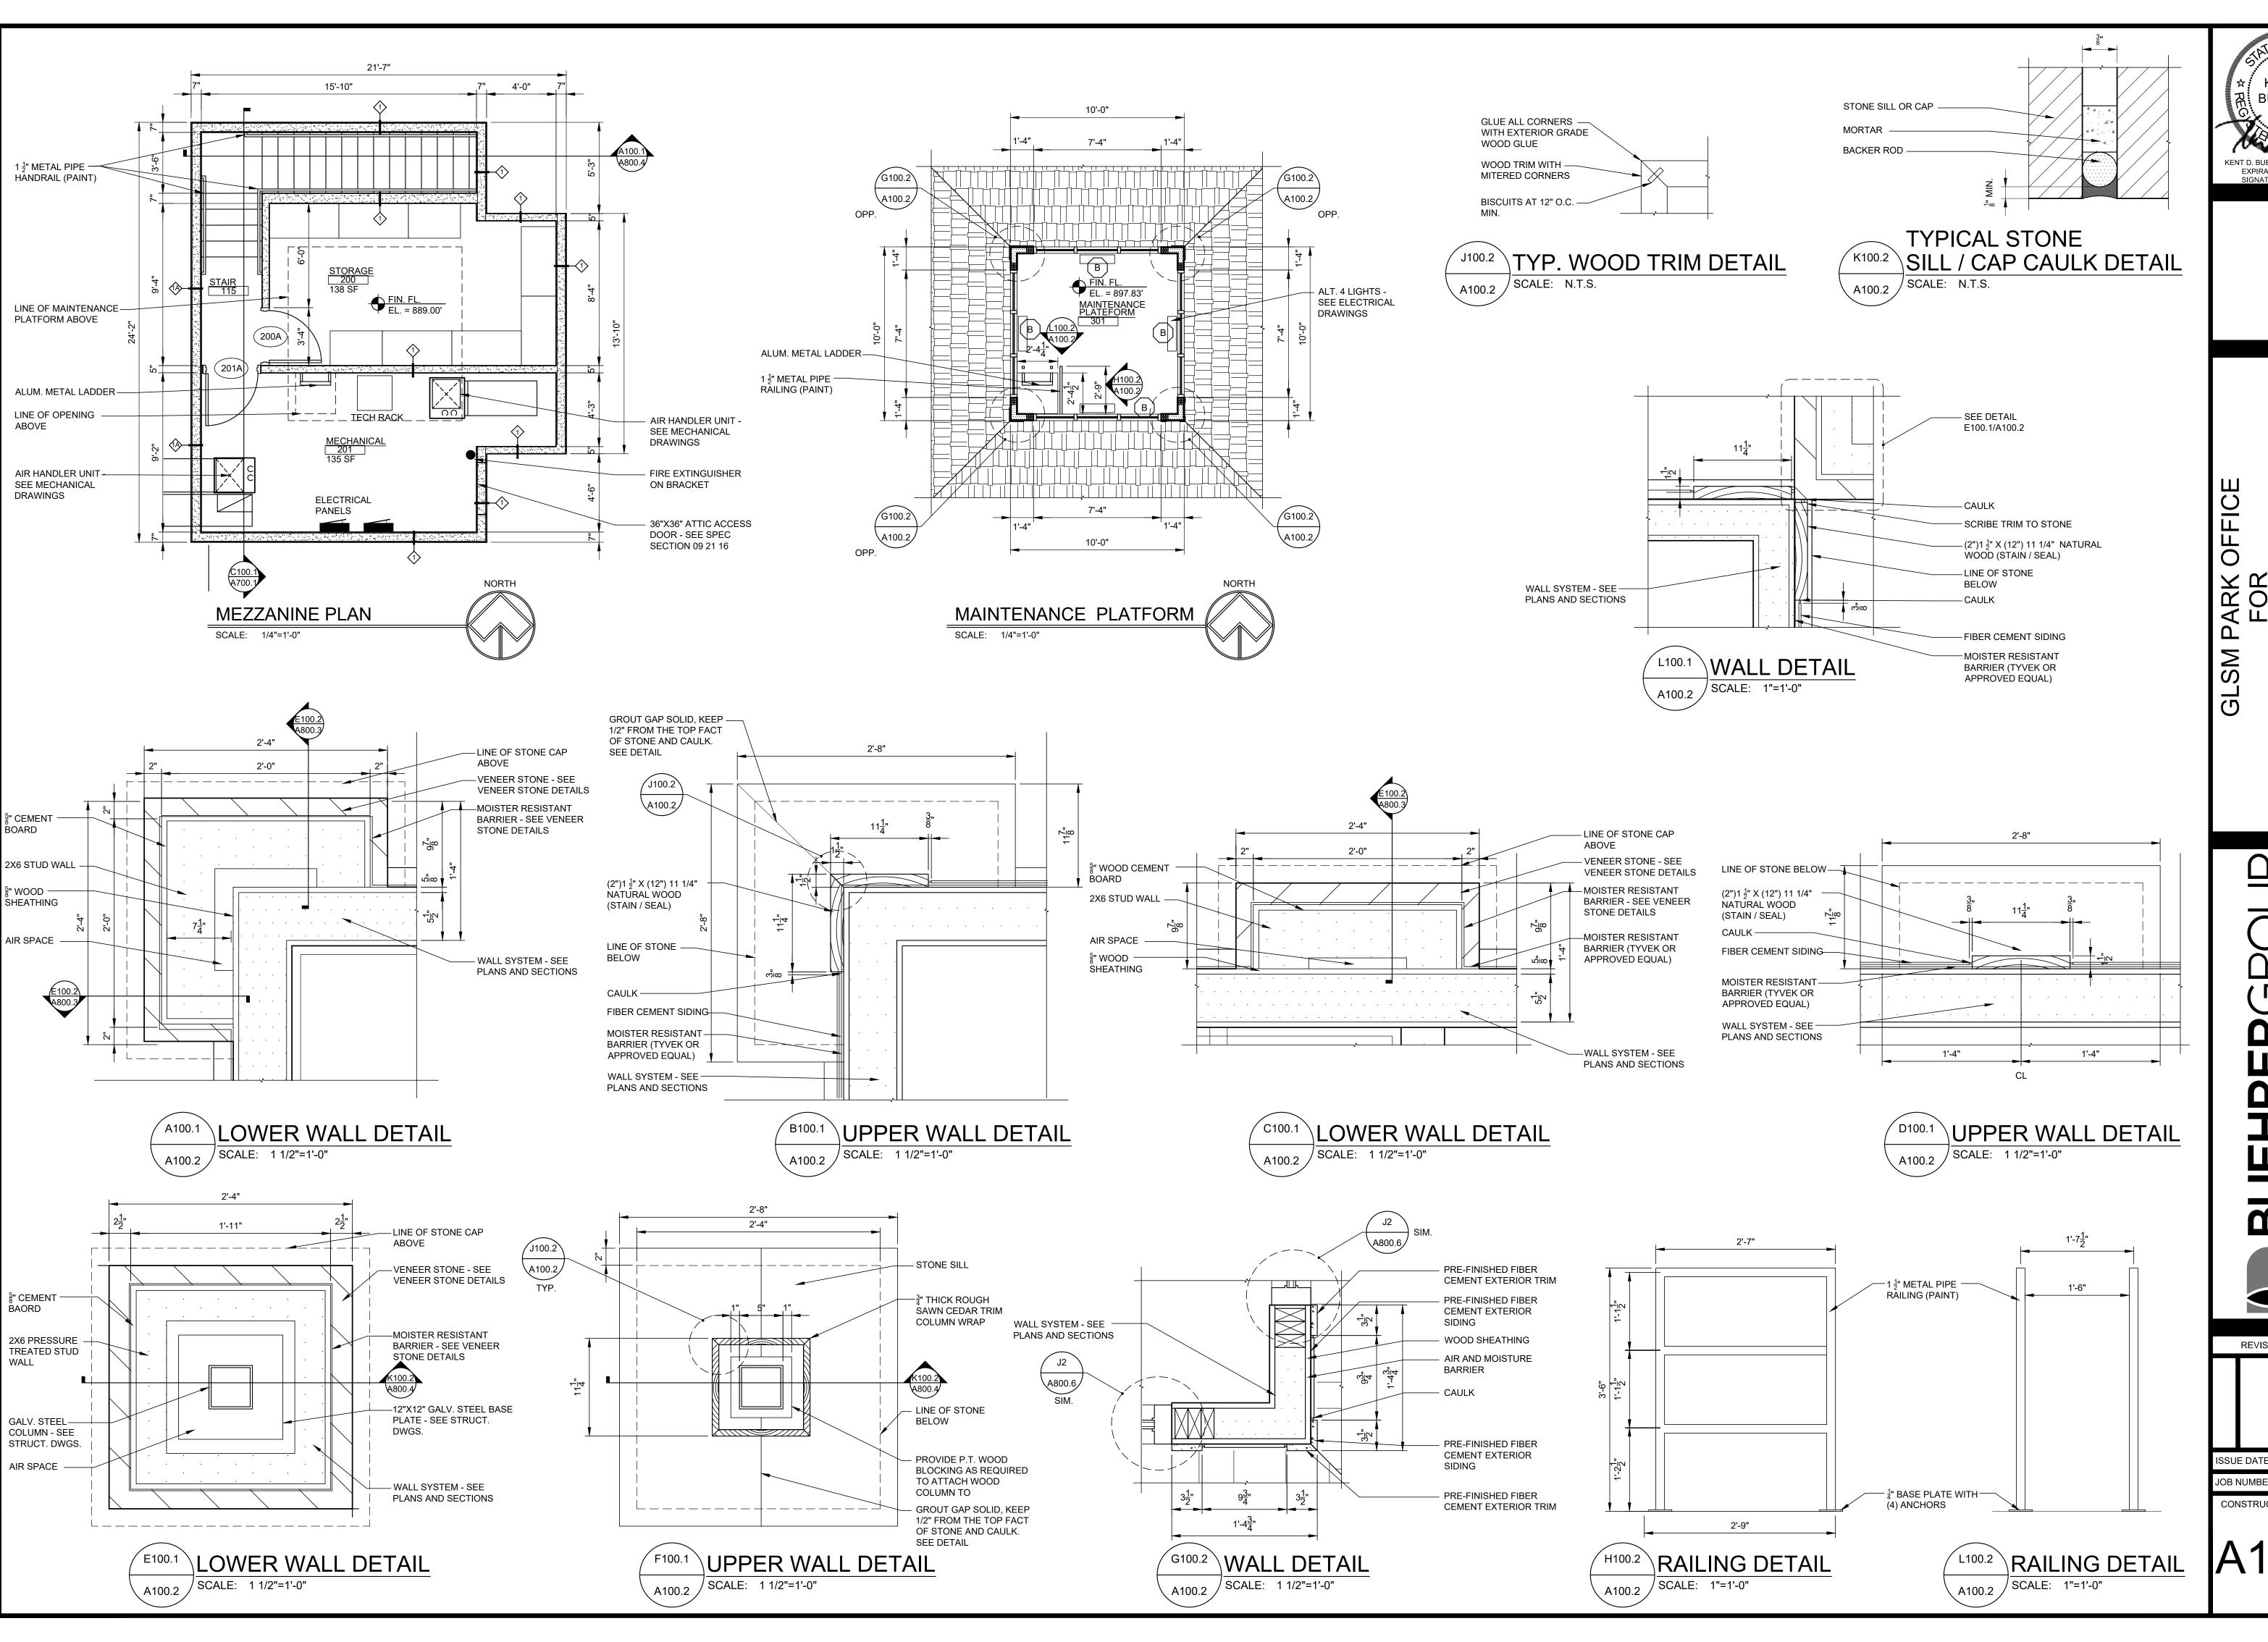



NAT 500 0 8 PARK FOR


> ering engin



REVISION SCHEDULE ISSUE DATE: 09/19/2025 JOB NUMBER: 241224

CONSTRUCTION DOCUMENTS

A100.2

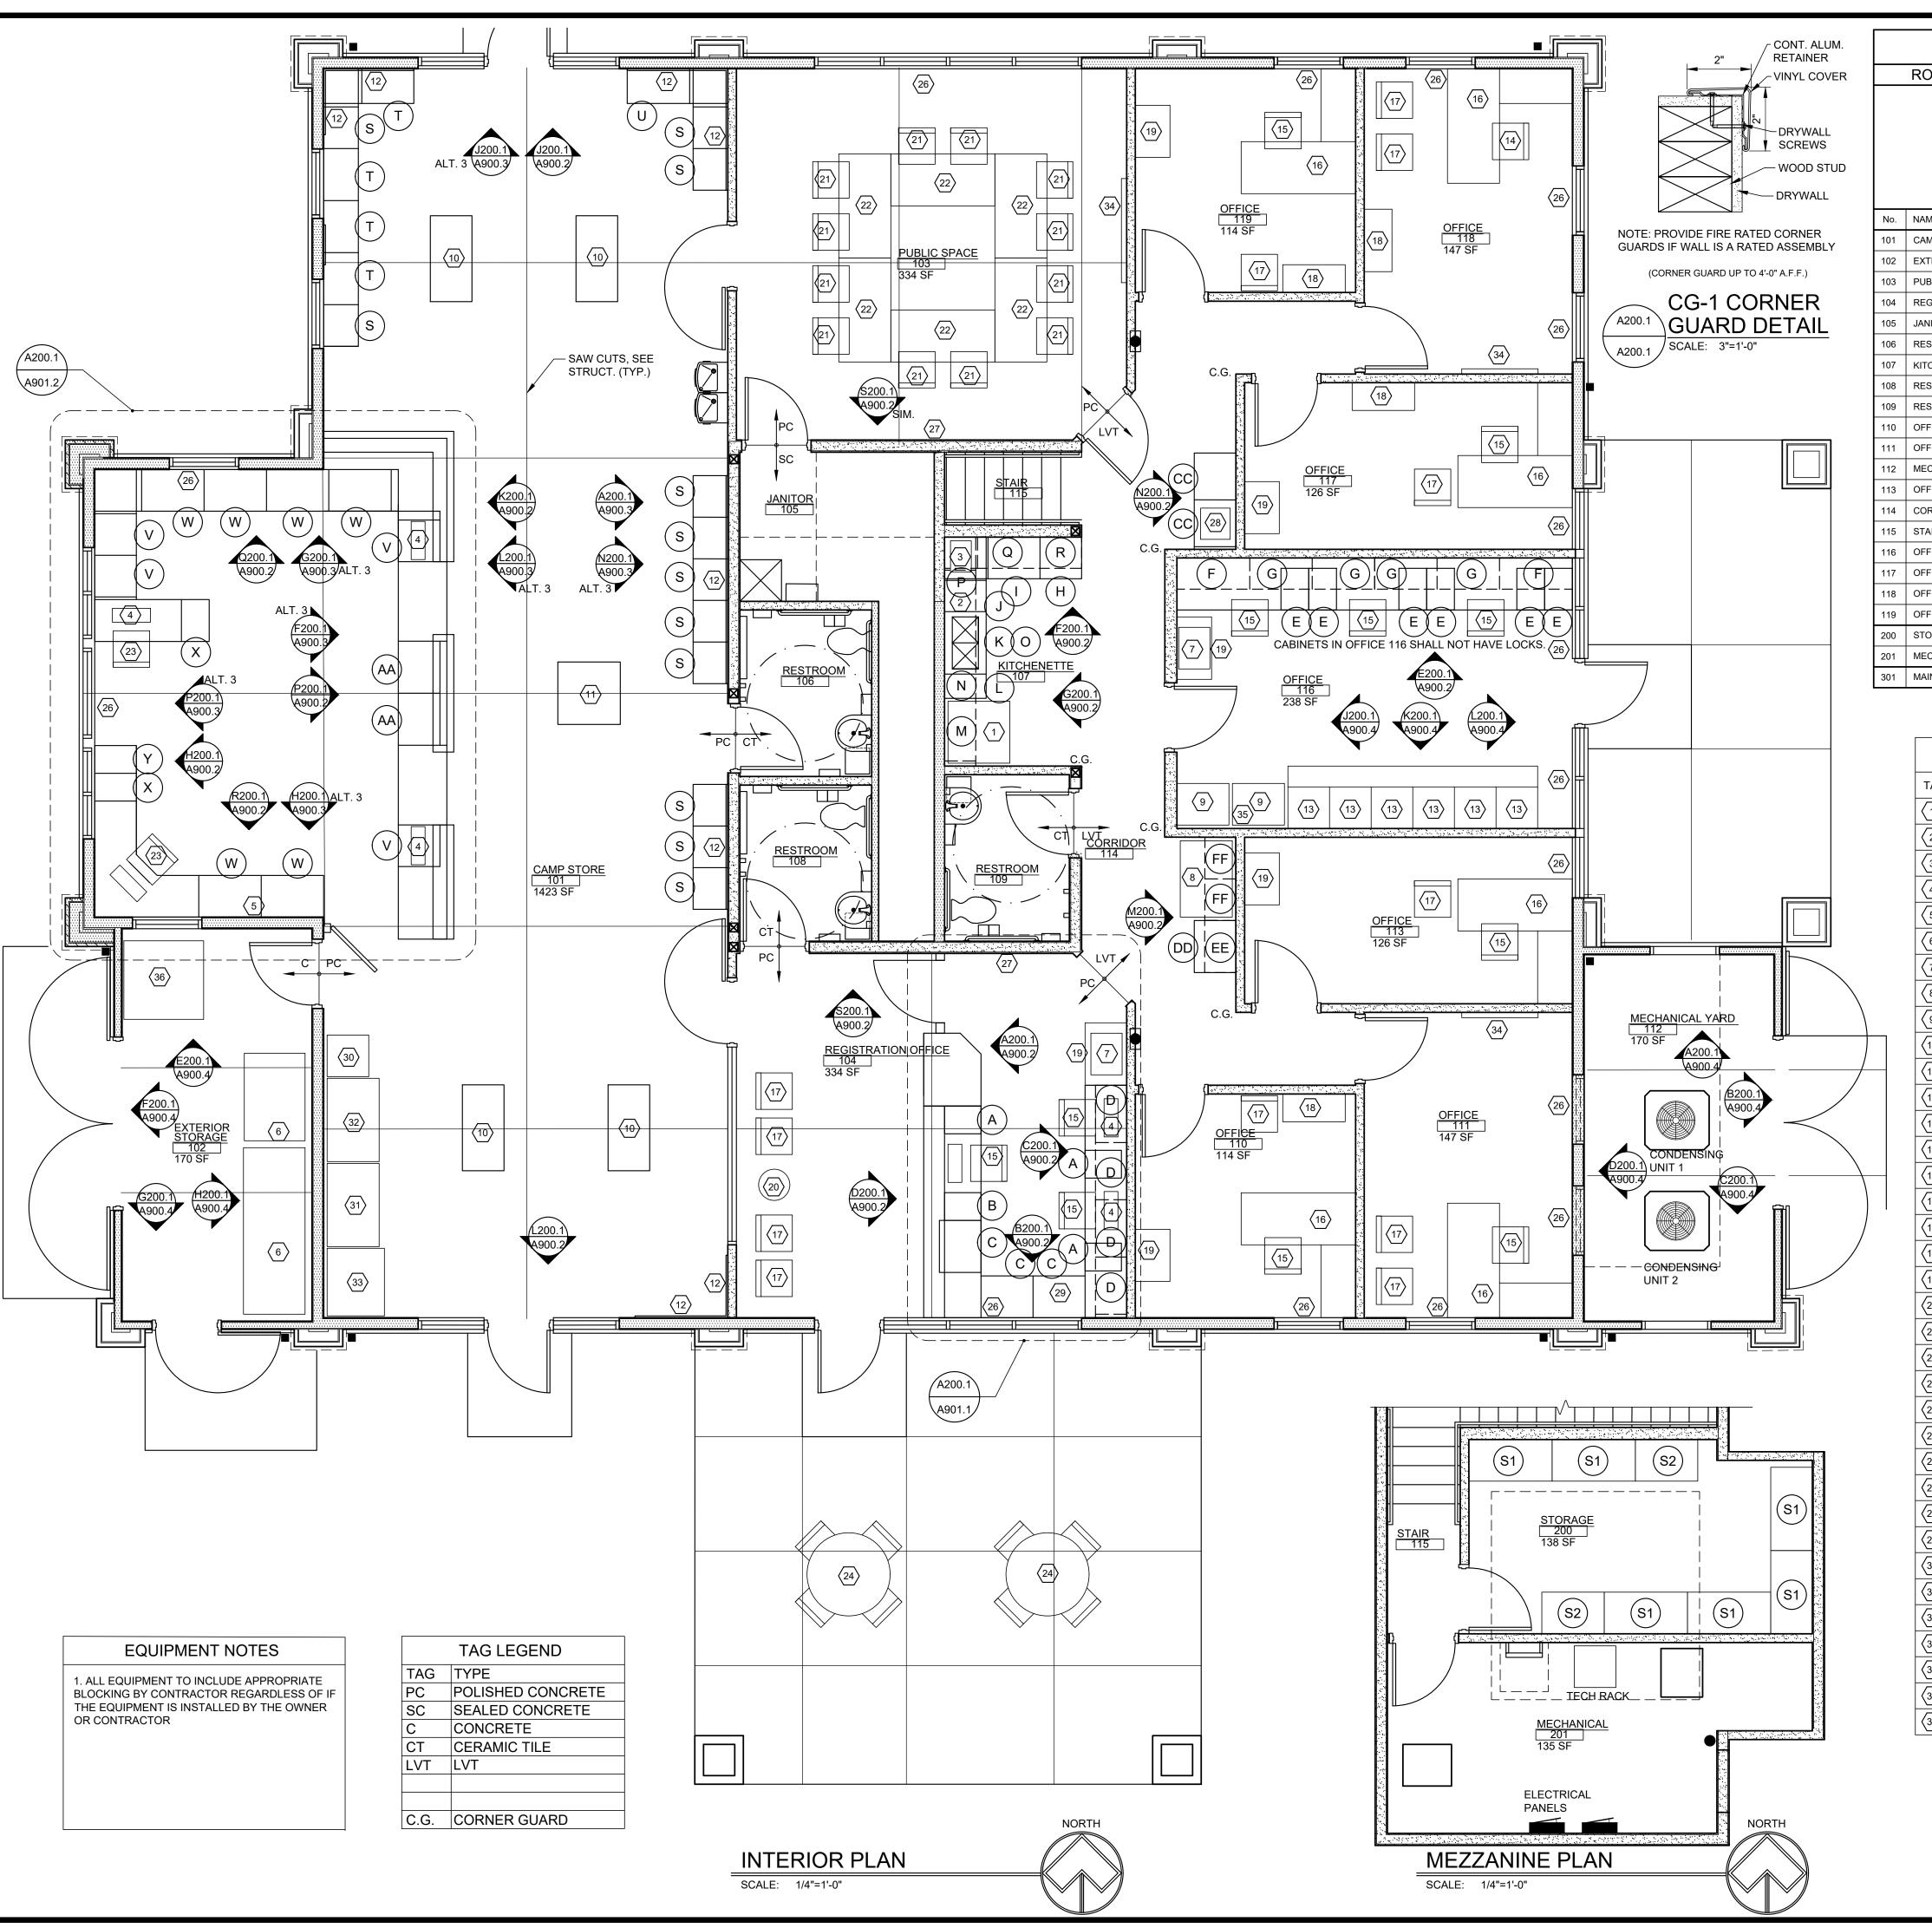

						F	RO	O	M	FI	NI	Sł	┨ \$	SC	H	Εľ	JL	JL	Ξ							
	ROOM			FL	OC	R					BA	\SE				V	VAI	LS)			(ŒI	LIN	G	
		UNFINISHED PLYWOOD	POLISHED CONCRETE	SEALED CONCRETE	CONCRETE	CERAMIC TILE	LVT	RUBBER STAIR TREADS	DIMENSION RES. BASE	4" RUBBER BASE	6" RUBBER BASE	CERAMIC BASE	NO BASE	COMPOSITE TRIM	EPOXY PAINT	GYP. BOARD	PAINT	COMPOSITE SIDING	CERAMIC TILE (ALT. 1)	2x2 ACOUSTICAL TILE - A1	2x2 ACOUSTICAL TILE - A2	GYP. BOARD	PAINT	EPOXY PAINT	COMPOSITE SOFFIT	
No.	NAME	PW	РС	sc	С	СТ	LVT	RST	DB1	RB1	RB2	СВ	N	СТ	EP	GP	Р	cs	СТ	A1	A2	GP	Р	EP	cs	HGT.
101	CAMP STORE		РС						DB1							GP	Р					GP	Р			11'-11 3/8 VARIES
102	EXTERIOR STORAGE				С									СТ			Р	cs					Р		cs	VARIES
103	PUBLIC SPACE		РС						DB1							GP	Р					GP	Р			11'-11 3/8
104	REGISTRATION OFFICE		РС						DB1							GP	Р					GP	Р			11'-11 3/8
105	JANITOR			sc							RB2				EP	GP						GP	Р			VARIES
106	RESTROOM					СТ						СВ			EP	GP			СТ		A2					8'-6"
107	KITCHENETTE						LVT			RB1					EP	GP				A1						8'-6"
108	RESTROOM					СТ						СВ			EP	GP			СТ		A2					8'-6"
109	RESTROOM					СТ						СВ			EP	GP			СТ		A2					8'-6"
110	OFFICE						LVT			RB1						GP	Р			A1						9'-4"
111	OFFICE						LVT			RB1						GP	Р			A1						9'-4"
112	MECHANICAL YARD				С									СТ			Р	cs					Р		cs	8'-0"
113	OFFICE						LVT			RB1						GP	Р			A1						9'-4"
114	CORRIDOR						LVT			RB1						GP	Р			A1						9'-4"
115	STAIR						LVT	RST		RB1						GP	Р					GP	Р			VARIES
116	OFFICE						LVT			RB1						GP	Р			A1						9'-4"
117	OFFICE						LVT			RB1						GP	Р			A1						9'-4"
118	OFFICE						LVT			RB1						GP	Р			A1						9'-4"
119	OFFICE						LVT			RB1						GP	Р			A1						9'-4"
200	STORAGE						LVT			RB1						GP	Р					GP	Р			7'-9 3/8"
201	MECHANICAL						LVT			RB1						GP	Р					GP	Р			7'-9 3/8"
301	MAINTENANCE PLATFORM	PW											N			GP	Р					GP	Р			VARIES

TAG	DESCRIPTION	SUPPLIED BY	INSTALLED BY	NOTES
1	REFRIGERATOR	CONTRACTOR	CONTRACTOR	SPEC SECTION 11 31 13
2	MICROWAVE	CONTRACTOR	CONTRACTOR	SPEC SECTION 11 31 13
3	COFFEE POT	OWNER	OWNER	
4	P.O.S.	OWNER	OWNER	
5	PARK MAP	CONTRACTOR	CONTRACTOR	SPEC SECTION 10 14 00, GRAPHIC PROVIDED TO CONTRACTOR BY OWNER
6	ICE MACHINE	OTHERS	OTHERS	73" X 36"
7	DESKTOP PRINTER	OWNER	OWNER	
8	FREESTANDING COPIER	OWNER	OWNER	
9	GUN SAFE	OWNER	OWNER	30" X 24" X 60"H, (1) EXISTING & (1) NEW
(10)	RETAIL SHELVING	FF&E PACKAGE	FF&E PACKAGE	
11	RETAIL SHELVING	FF&E PACKAGE	FF&E PACKAGE	
(12)	SLATWALL	CONTRACTOR	CONTRACTOR	SPEC SECTION 10 56 17, LOW STORAGE UNDE ALT. 3 - SPEC SECTION 12 30 00 / DWG. 900.3
(13)	LAW ENFORCEMENT LOCKERS	CONTRACTOR	CONTRACTOR	SPEC SECTION 10 51 13
(14)	TASK CHAIR	FF&E PACKAGE	FF&E PACKAGE	
(15)	TASK CHAIR (EXISTING)	OWNER	OWNER	
(16)	L-SHAPED DESK	FF&E PACKAGE	FF&E PACKAGE	
(17)	GUEST CHAIR	FF&E PACKAGE	FF&E PACKAGE	
(18)	BOOKCASE	FF&E PACKAGE	FF&E PACKAGE	
(19)	LATERAL FILE	FF&E PACKAGE	FF&E PACKAGE	
20	SIDE TABLE	FF&E PACKAGE	FF&E PACKAGE	
21	STACK CHAIR	FF&E PACKAGE	FF&E PACKAGE	
22	RECTANGULAR ACTIVITY TABLE	FF&E PACKAGE	FF&E PACKAGE	
23	TASK STOOL	FF&E PACKAGE	FF&E PACKAGE	
24	PICNIC TABLE W/ ATTACHED CHAIRS	FF&E PACKAGE	FF&E PACKAGE	
25				
26	MANUAL WINDOW SHADES	CONTRACTOR	CONTRACTOR	SPEC SECTION 12 49 40
27	PHOTO FRAME RAIL/HANGING SYSTEM	1 CONTRACTOR	CONTRACTOR	SPEC SECTION 10 11 00
28	SAFE	OWNER	OWNER	LOCATED INSIDE TALL CABINET
29	HIN STAMPER SET	OWNER	OWNER	
(30)	BAIT FRIDGE	OWNER	OWNER	
31	COLD FOOD FRIDGE	OWNER	OWNER	
(32)	COLD FOOD FREEZER	OWNER	OWNER	
33	VENDING MACHINE	OTHERS	OTHERS	
(34)	TV	FF&E PACKAGE	FF&E PACKAGE	
35	BODY CAM AND TASER CHARGING STATION	OWNER	OWNER	CONTRACTOR TO PROVIDE POWER/DATA, UNITS TO SET ATOP THE GUN SAFE(S)
(36)	FIREWOOD PALLET	OWNER	OWNER	




OFFICE GLSM PARK OFFIC FOR DEPARTMENT OF N ESOURCES DNR-25 DEP, ESO

ering

REVISION SCHEDULE

ISSUE DATE: 09/19/2025

JOB NUMBER: 241224

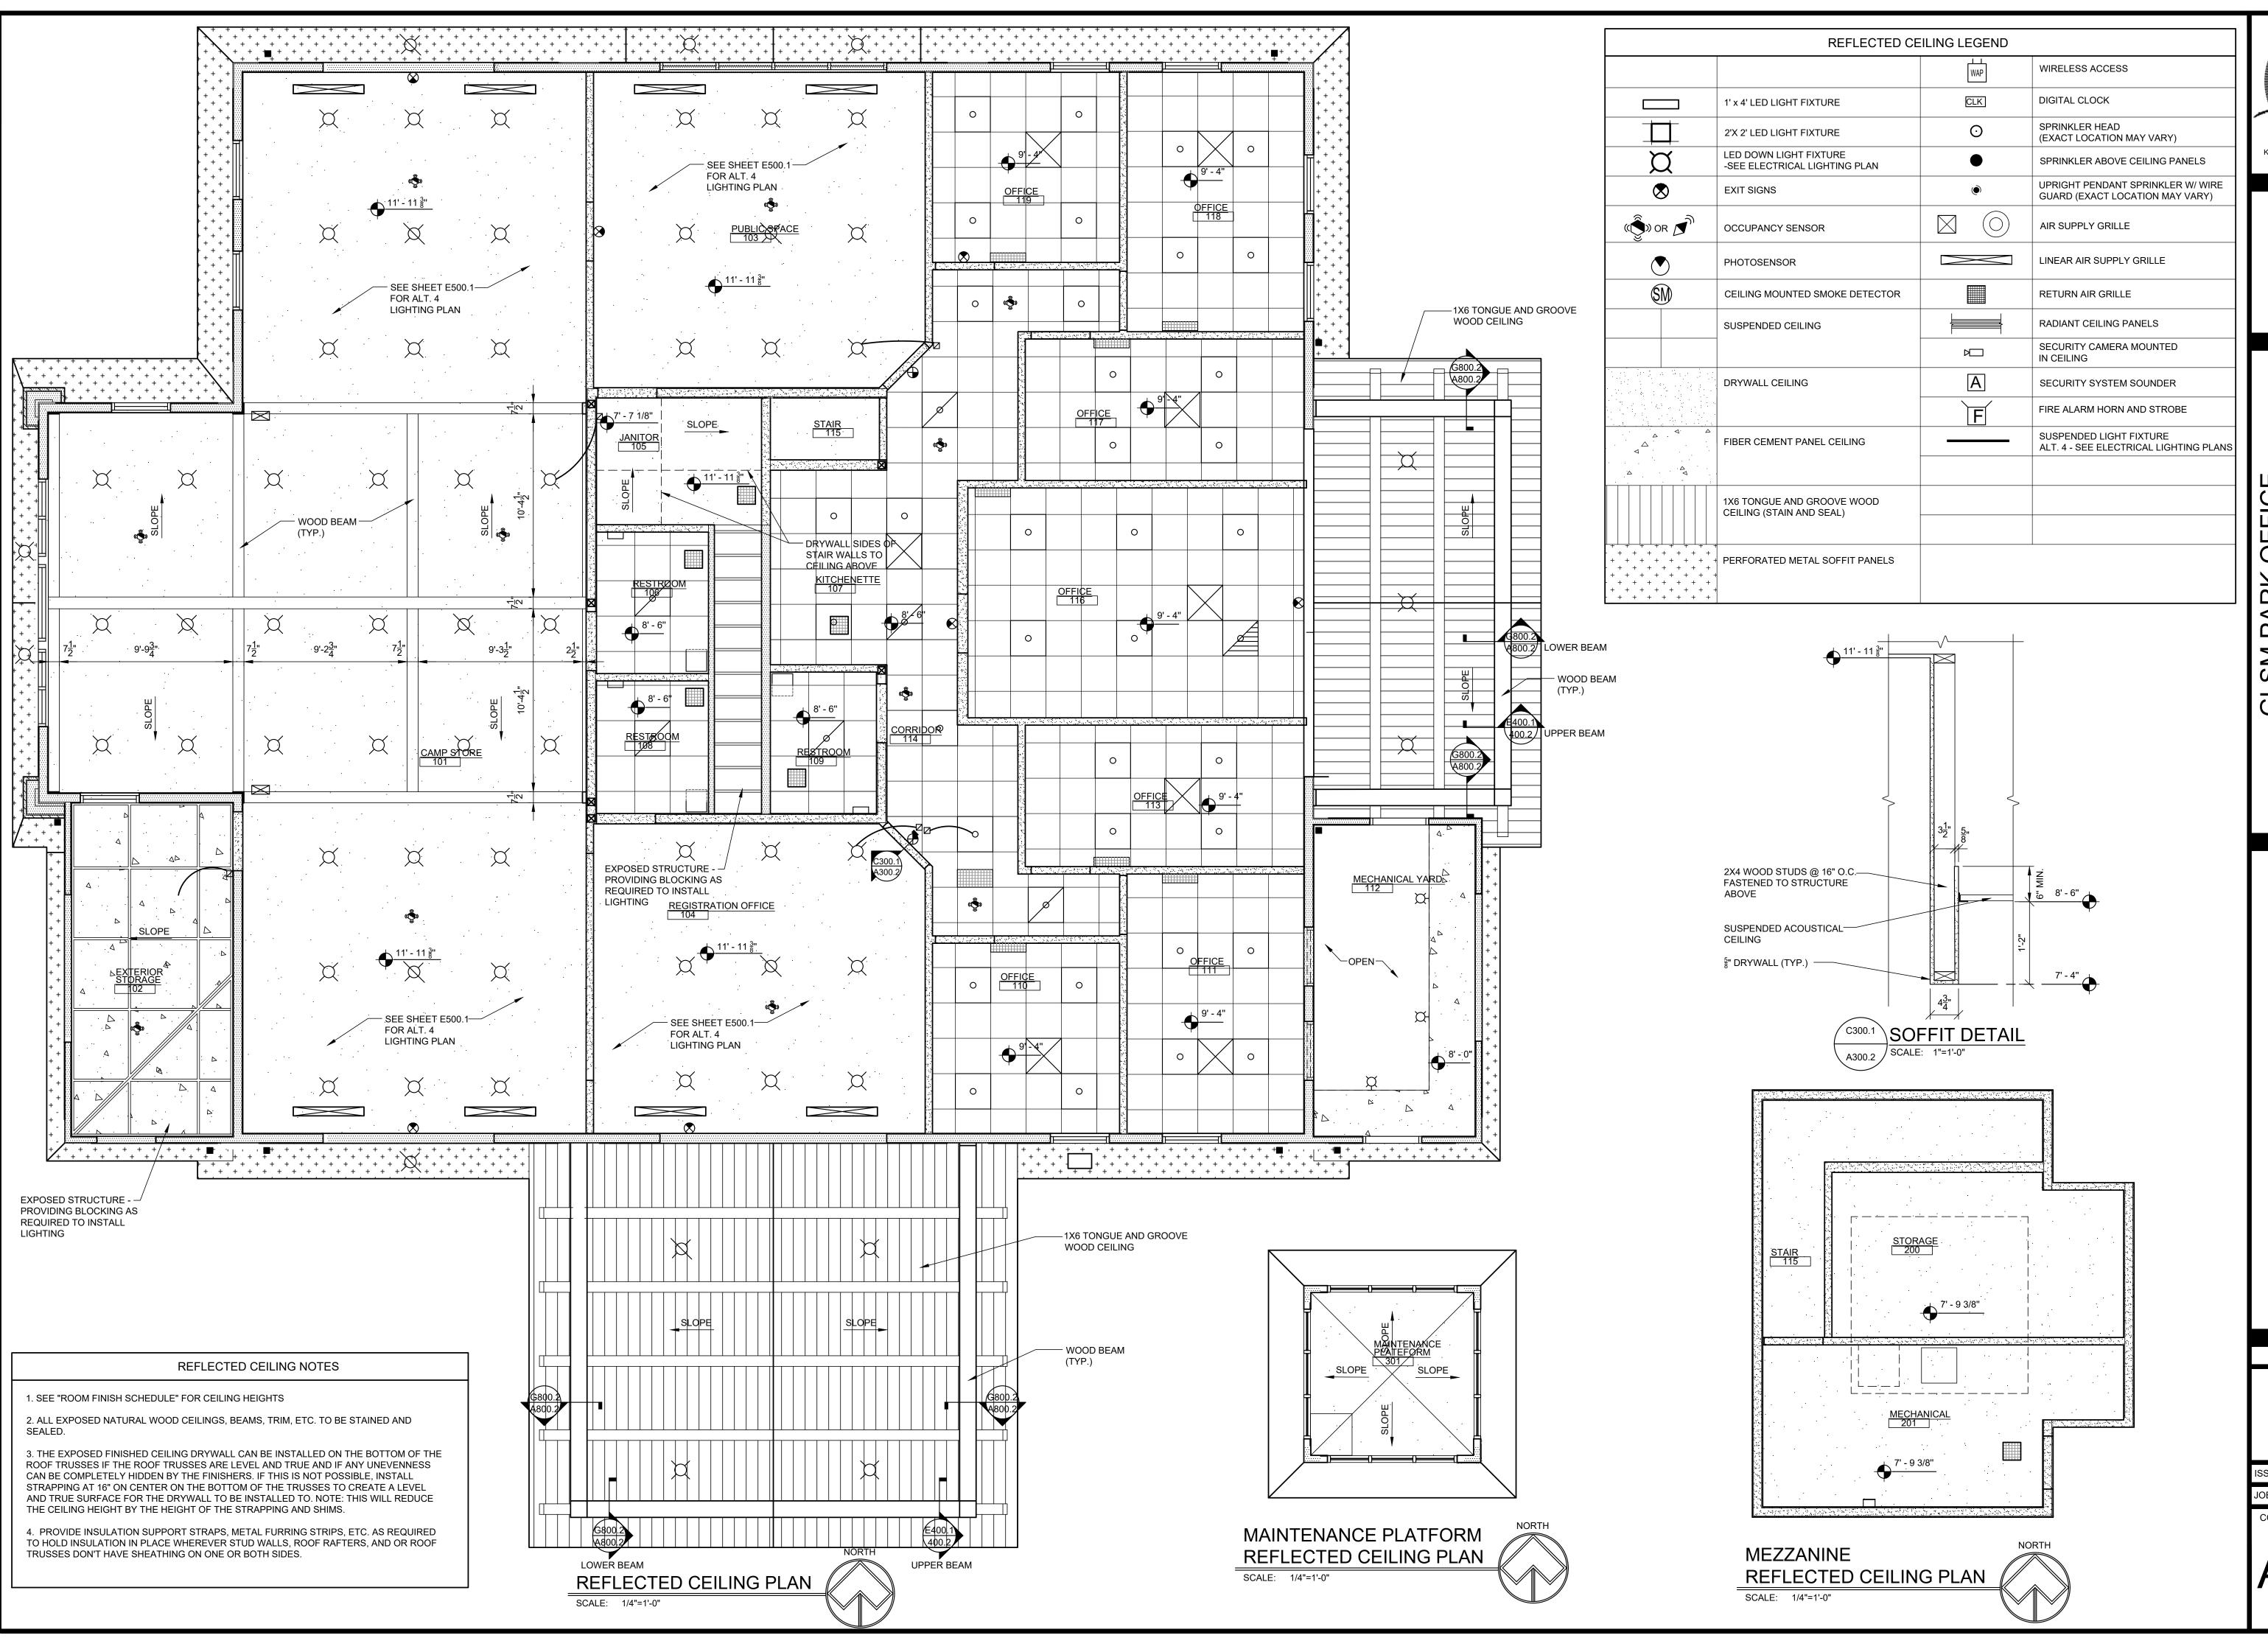



GLSM PARK OFFICE
FOR
OHIO DEPARTMENT OF NATURAL
RESOURCES DNR-250013

BUEHRERGROUP architecture & engineering, inc.
314 CONANT ST., MAUMEE, OH 43537 I P:419,893.9027 I BUEHRERGROUP COM




REVISION SCHEDULE


ISSUE DATE: 09/19/2025

JOB NUMBER: 241224

CONSTRUCTION DOCUMENTS

A300.1

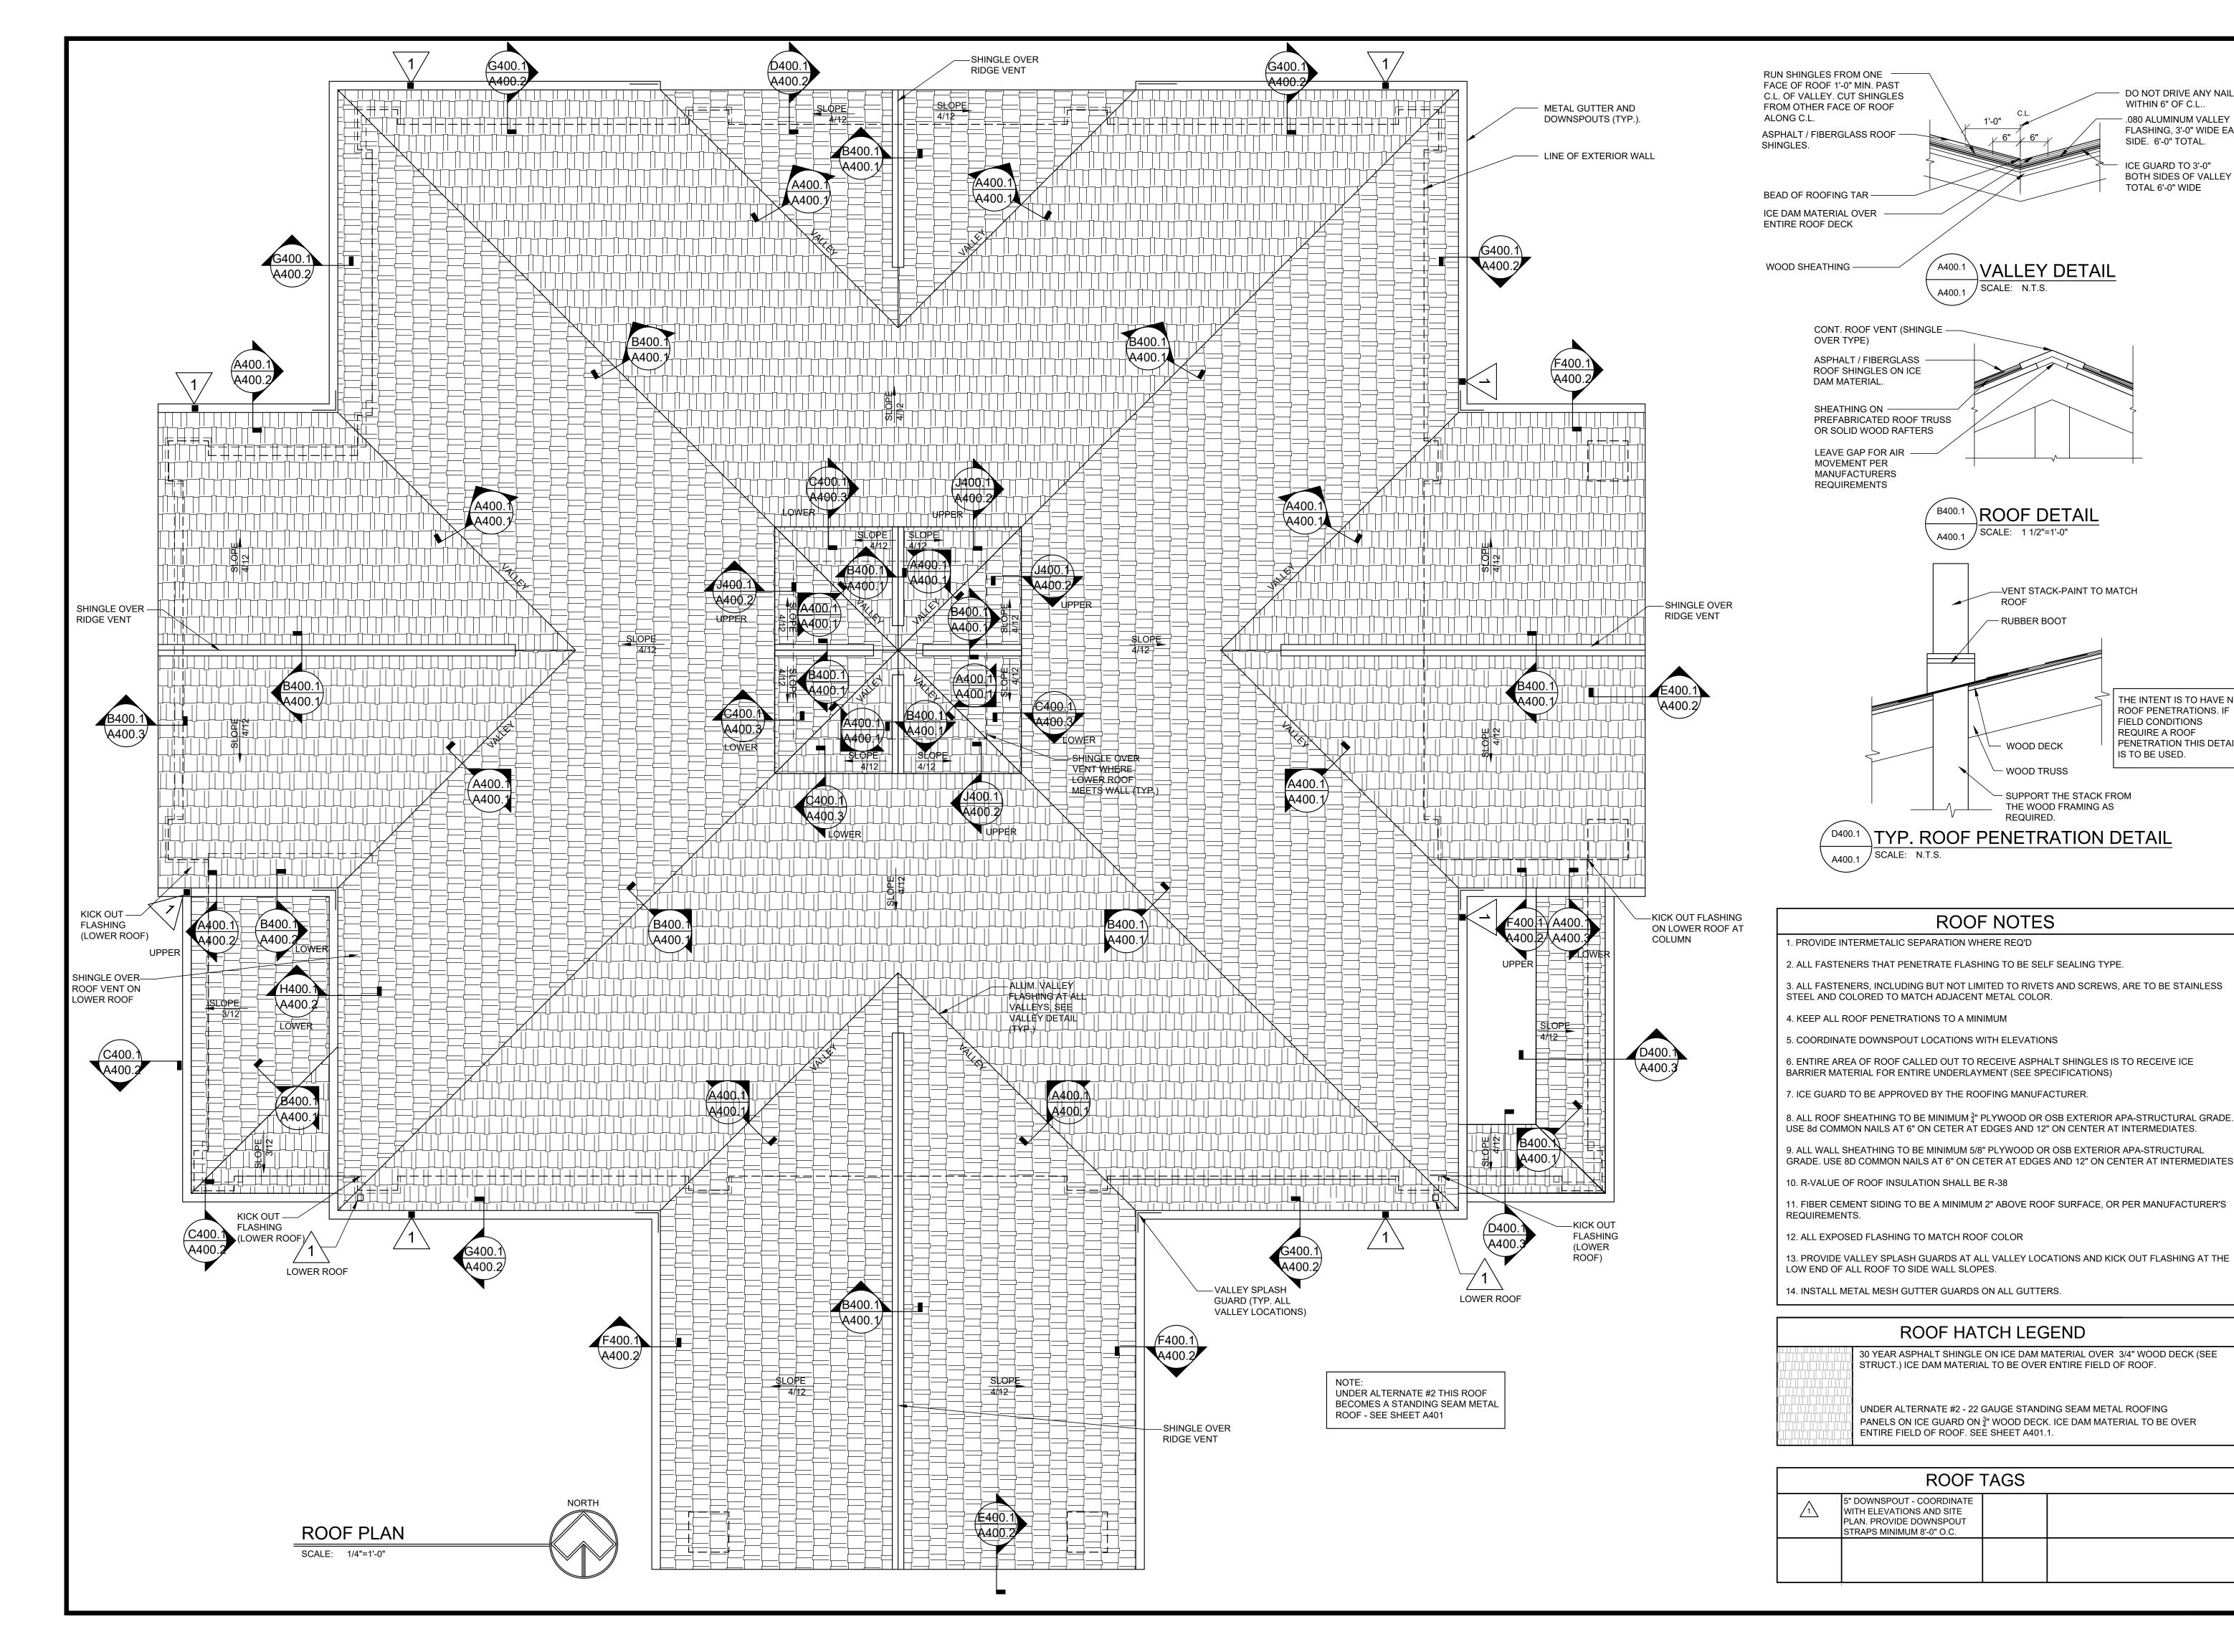

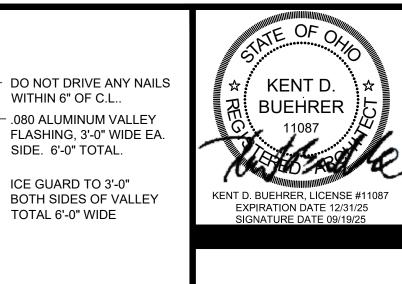

WITHIN 6" OF C.L..

SIDE. 6'-0" TOTAL.

ICE GUARD TO 3'-0"

TOTAL 6'-0" WIDE

THE INTENT IS TO HAVE NO ROOF PENETRATIONS. IF

PENETRATION THIS DETAIL

FIELD CONDITIONS REQUIRE A ROOF

IS TO BE USED.

VALLEY DETAIL

ROOF DETAIL

—VENT STACK-PAINT TO MATCH

SCALE: 1 1/2"=1'-0"

ROOF

— RUBBER BOOT

WOOD DECK

- WOOD TRUSS

SUPPORT THE STACK FROM THE WOOD FRAMING AS

SCALE: N.T.S.


OFFICE PARK FOR SM GL

D

REVISION SCHEDULE

ISSUE DATE: 09/19/2025

JOB NUMBER: 241224

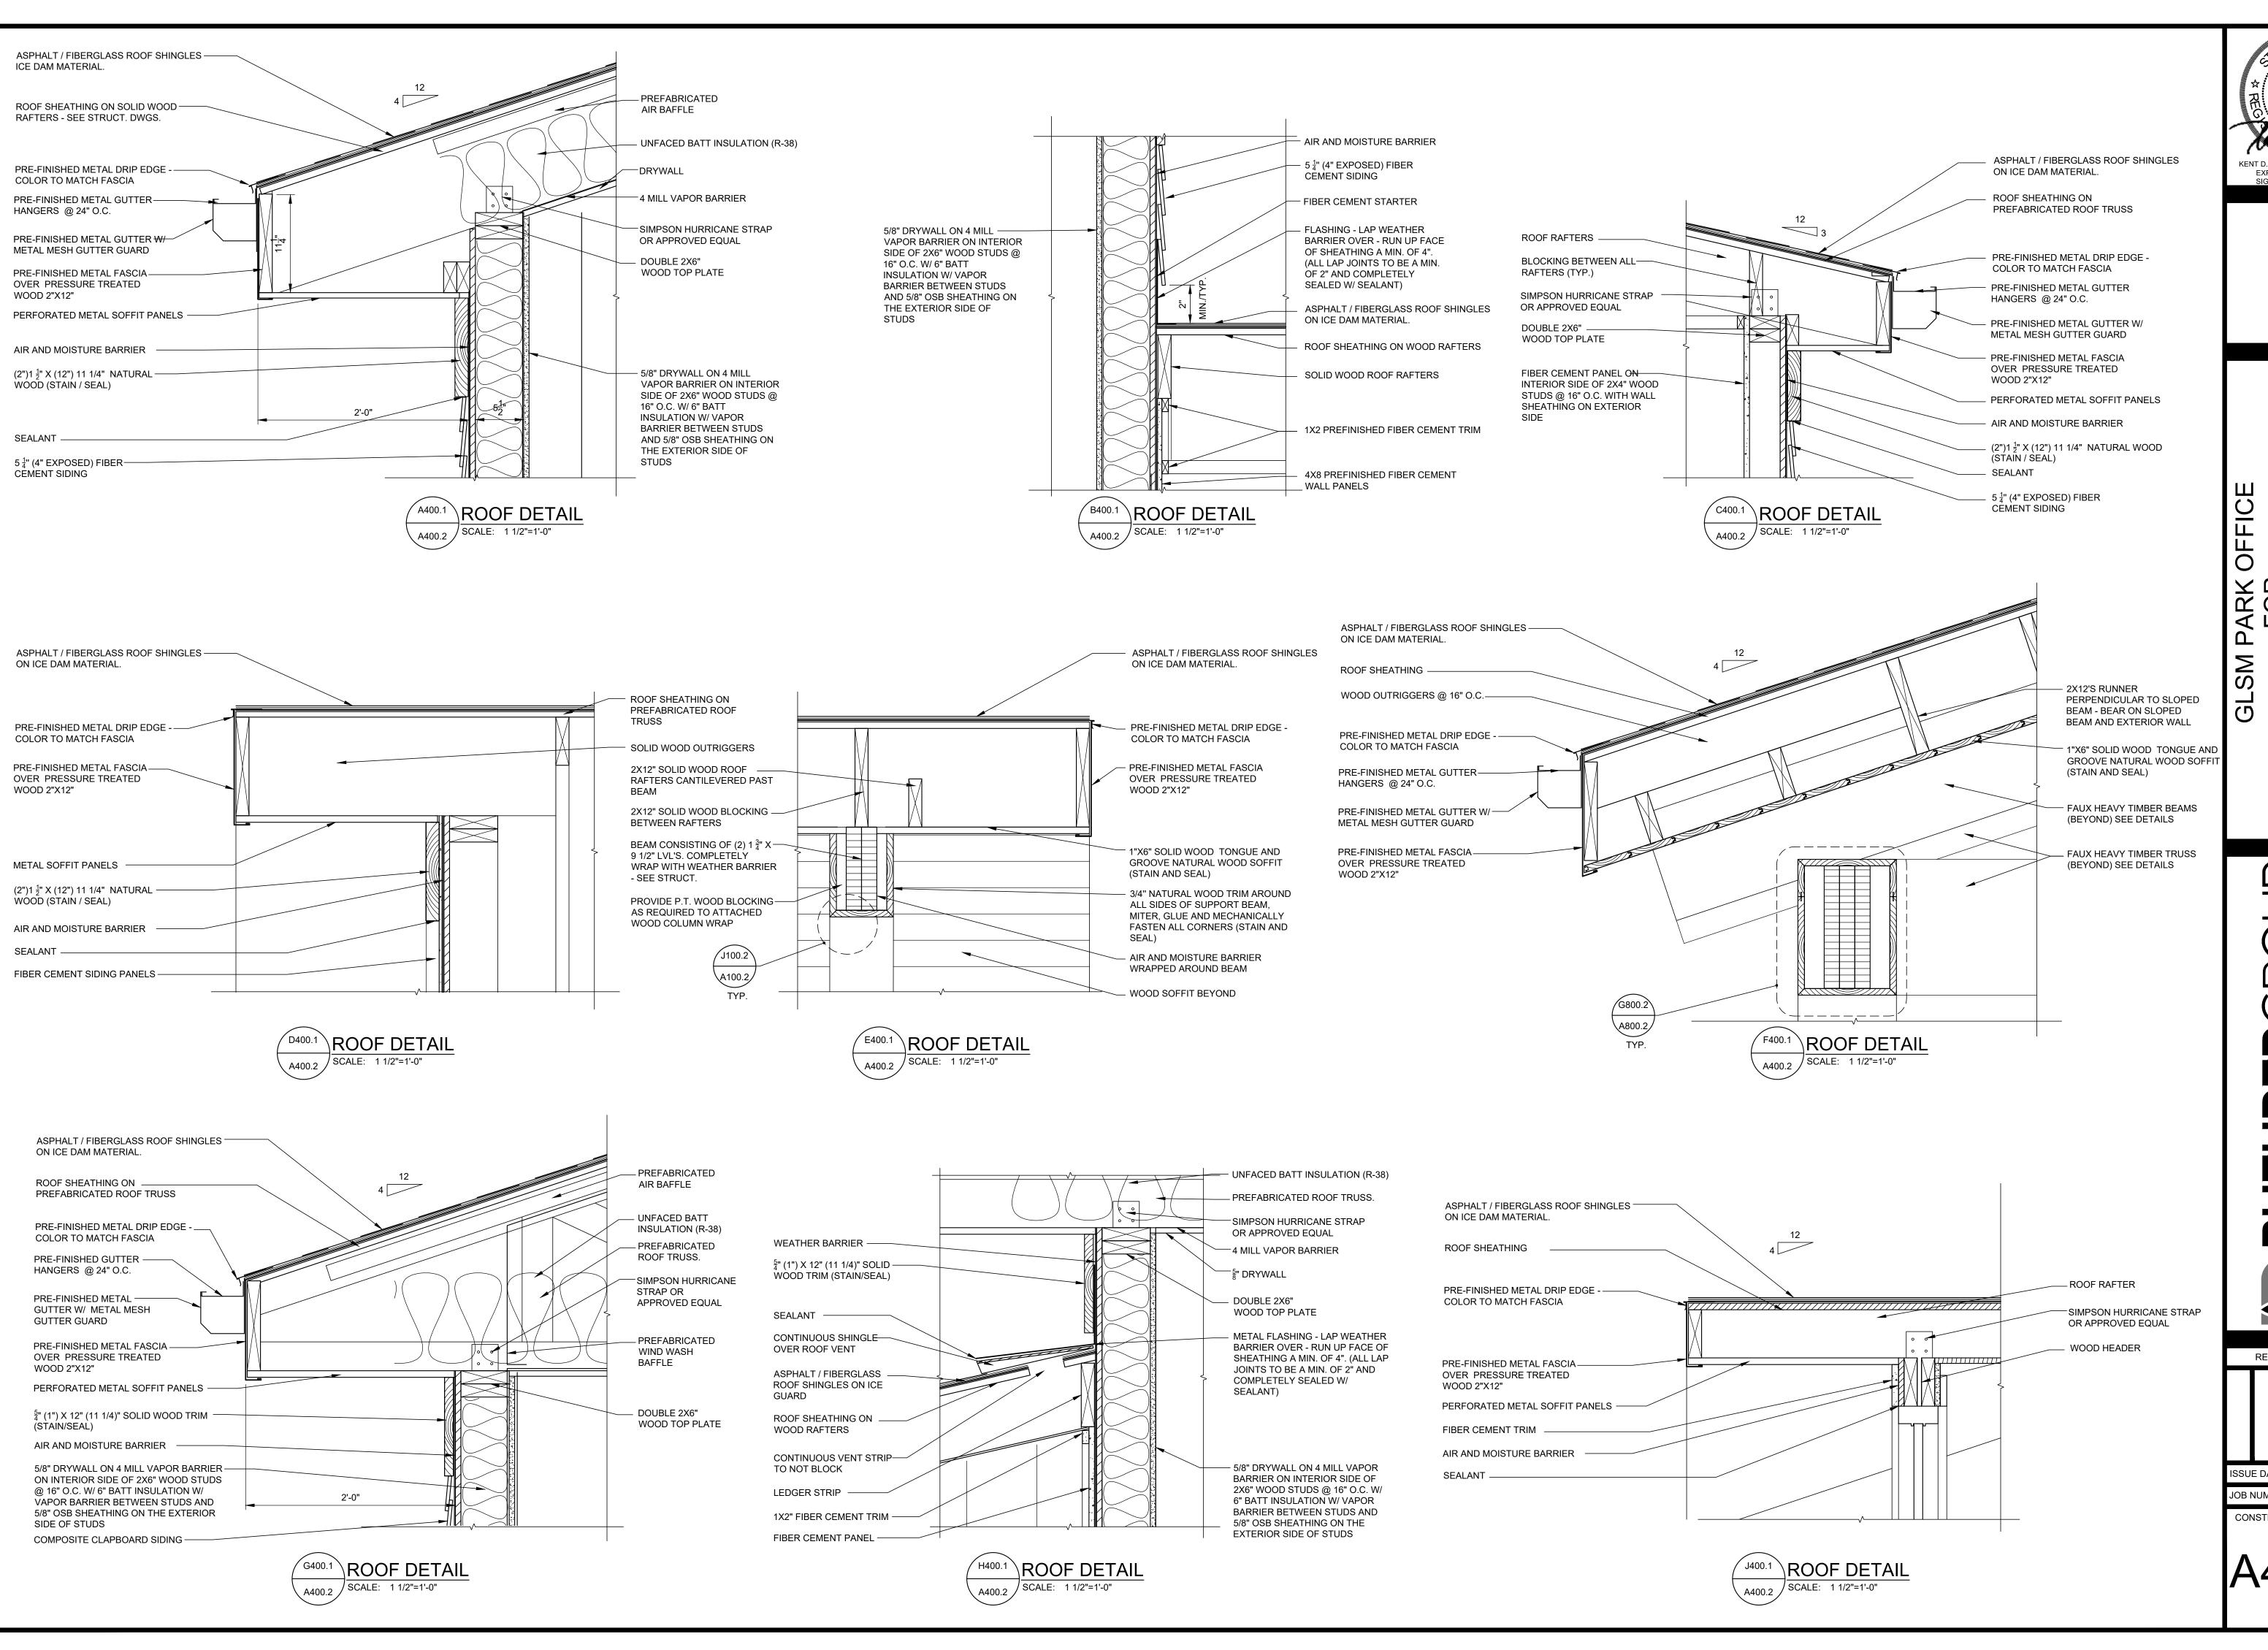

KENT D. **BUEHRER** 11087 KENT D. BUEHRER, LICENSE #11087 EXPIRATION DATE 12/31/25 SIGNATURE DATE 09/19/25

ARK

Σü


D Φ




REVISION SCHEDULE

ISSUE DATE: 09/19/2025

JOB NUMBER: 241224

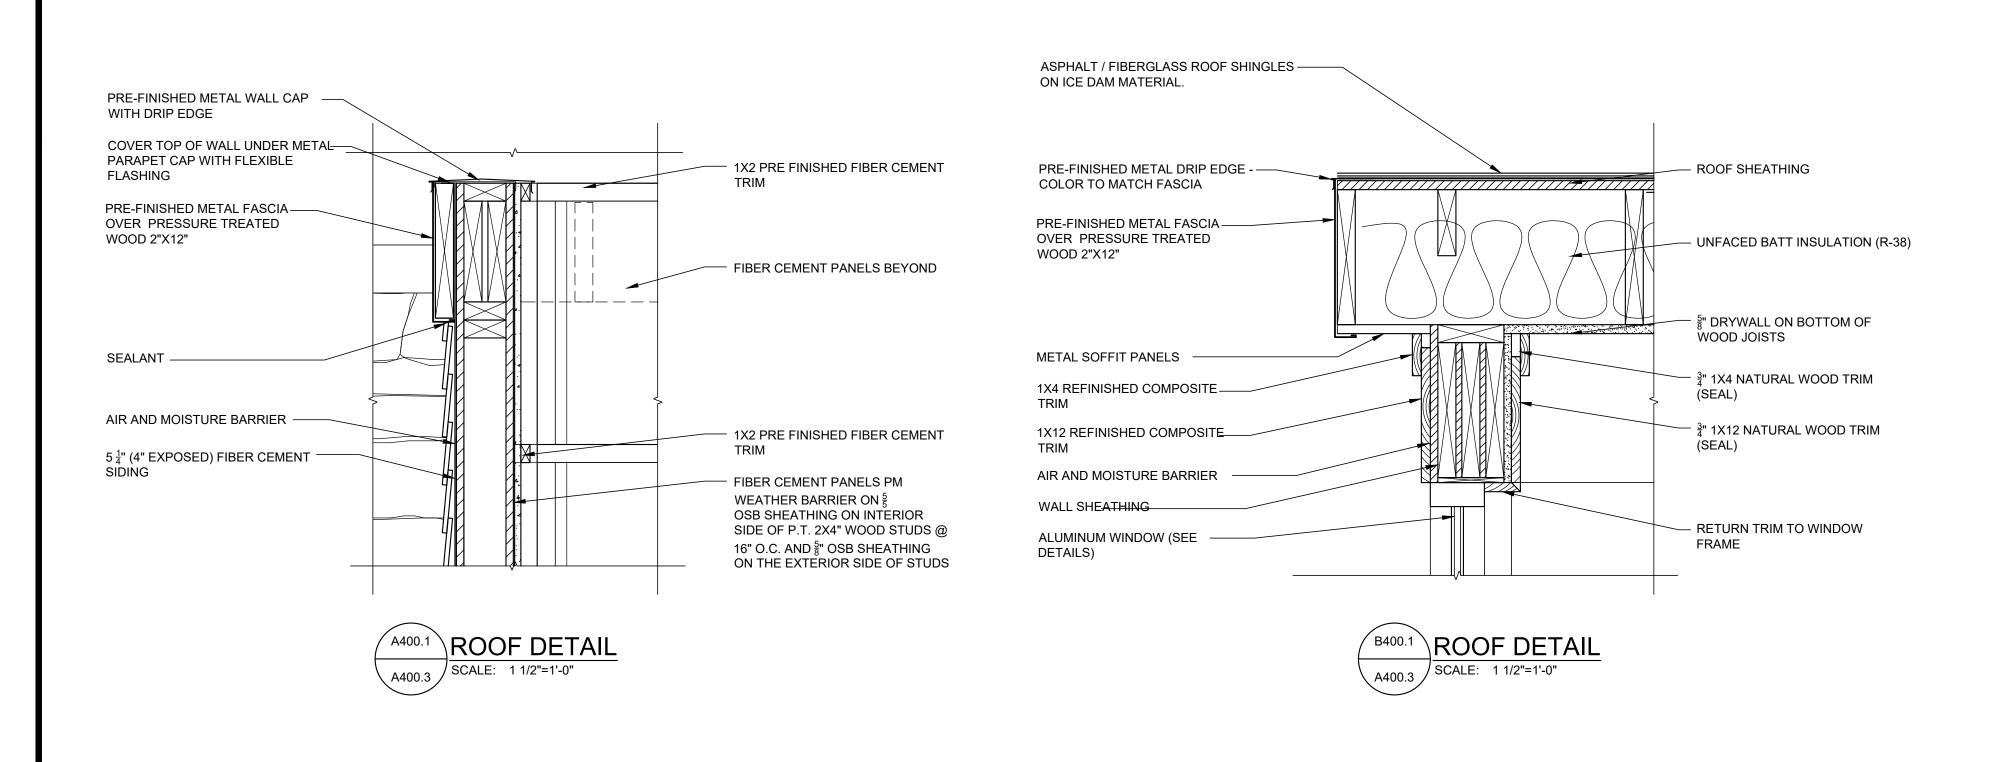

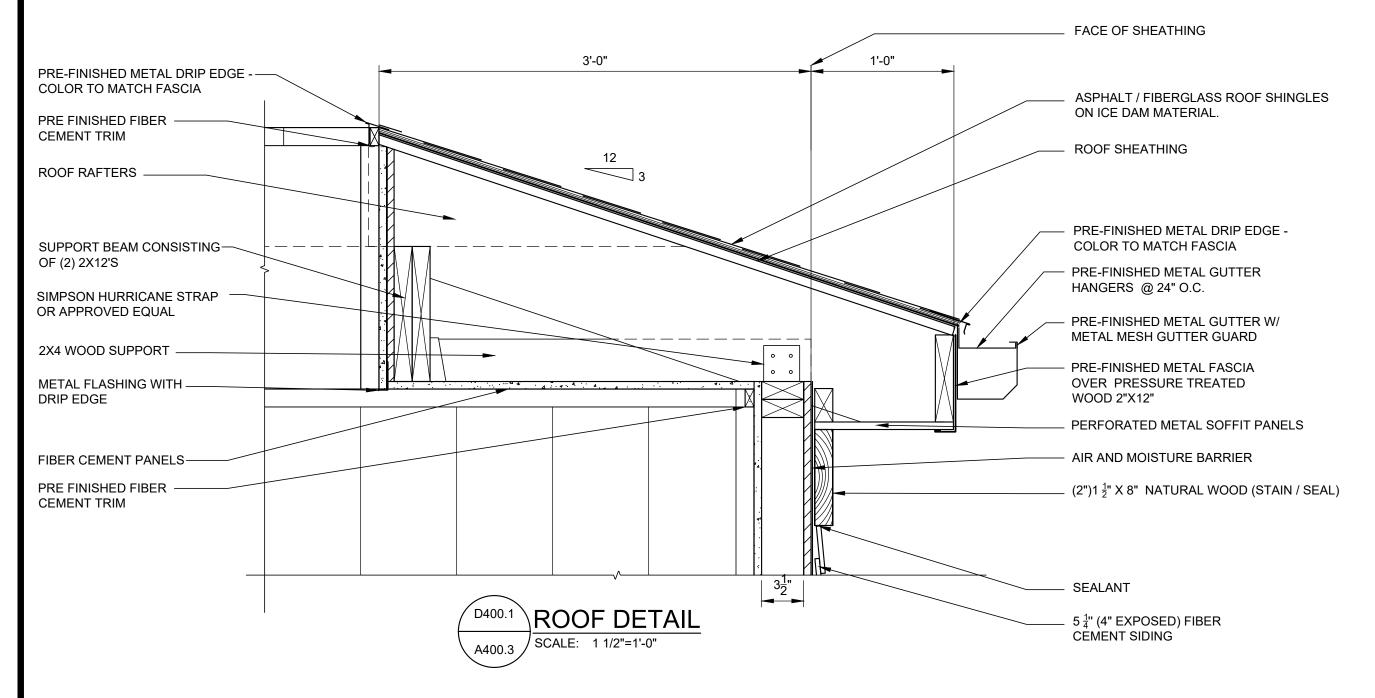

ROOF DETAIL NOTES

1 PROVIDE INTERMETALIC SEPARATION WHERE REQ'D


TOPS WHICH ARE LEVEL.

2. ALL FASTENERS THAT PENETRATE FLASHING TO BE SELF SEALING TYPE.

3. ALL ROOF CURBS ON SLOPES OVER $\frac{1}{4}$ "/12" TO HAVE BOTTOMS WHICH MATCH THE ROOF SLOPE &

4. PROVIDE ROOF SADDLES ON THE UP SLOPE SIDE OF CURBS.

5. PROVIDE INSULATION SUPPORT STRAPS, METAL FURRING STRIPS, ETC. AS REQUIRED TO HOLD INSULATION IN PLACE WHEREVER STUD WALLS DON'T HAVE SHEATHING ON ONE OR BOTH SIDES.

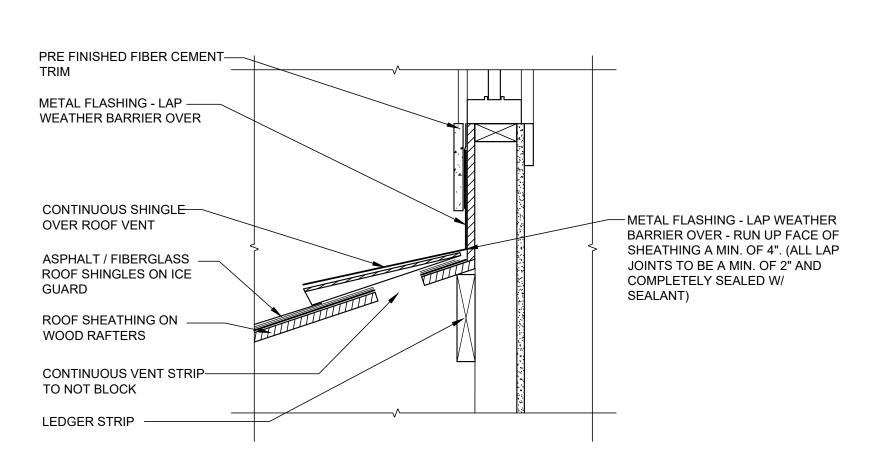

C400.1 ROOF DETAIL SCALE: 1 1/2"=1'-0"

KENT D. BUEHRER 11087

EXPIRATION DATE 12/31/25
SIGNATURE DATE 09/19/25

GLSM PARK OFFICE
FOR
DEPARTMENT OF NATURAL
SOURCES DNR-250013

JEHRERGROUP ON HITECTURE & engineering, inc.
ANT ST., MAUMEE, OH 43537 I P:419.893.9027 I BUEHRERGROUP.COM




REVISION SCHEDULE


ISSUE DATE: 09/19/2025

JOB NUMBER: 241224

CONSTRUCTION DOCUMENTS

A400.3

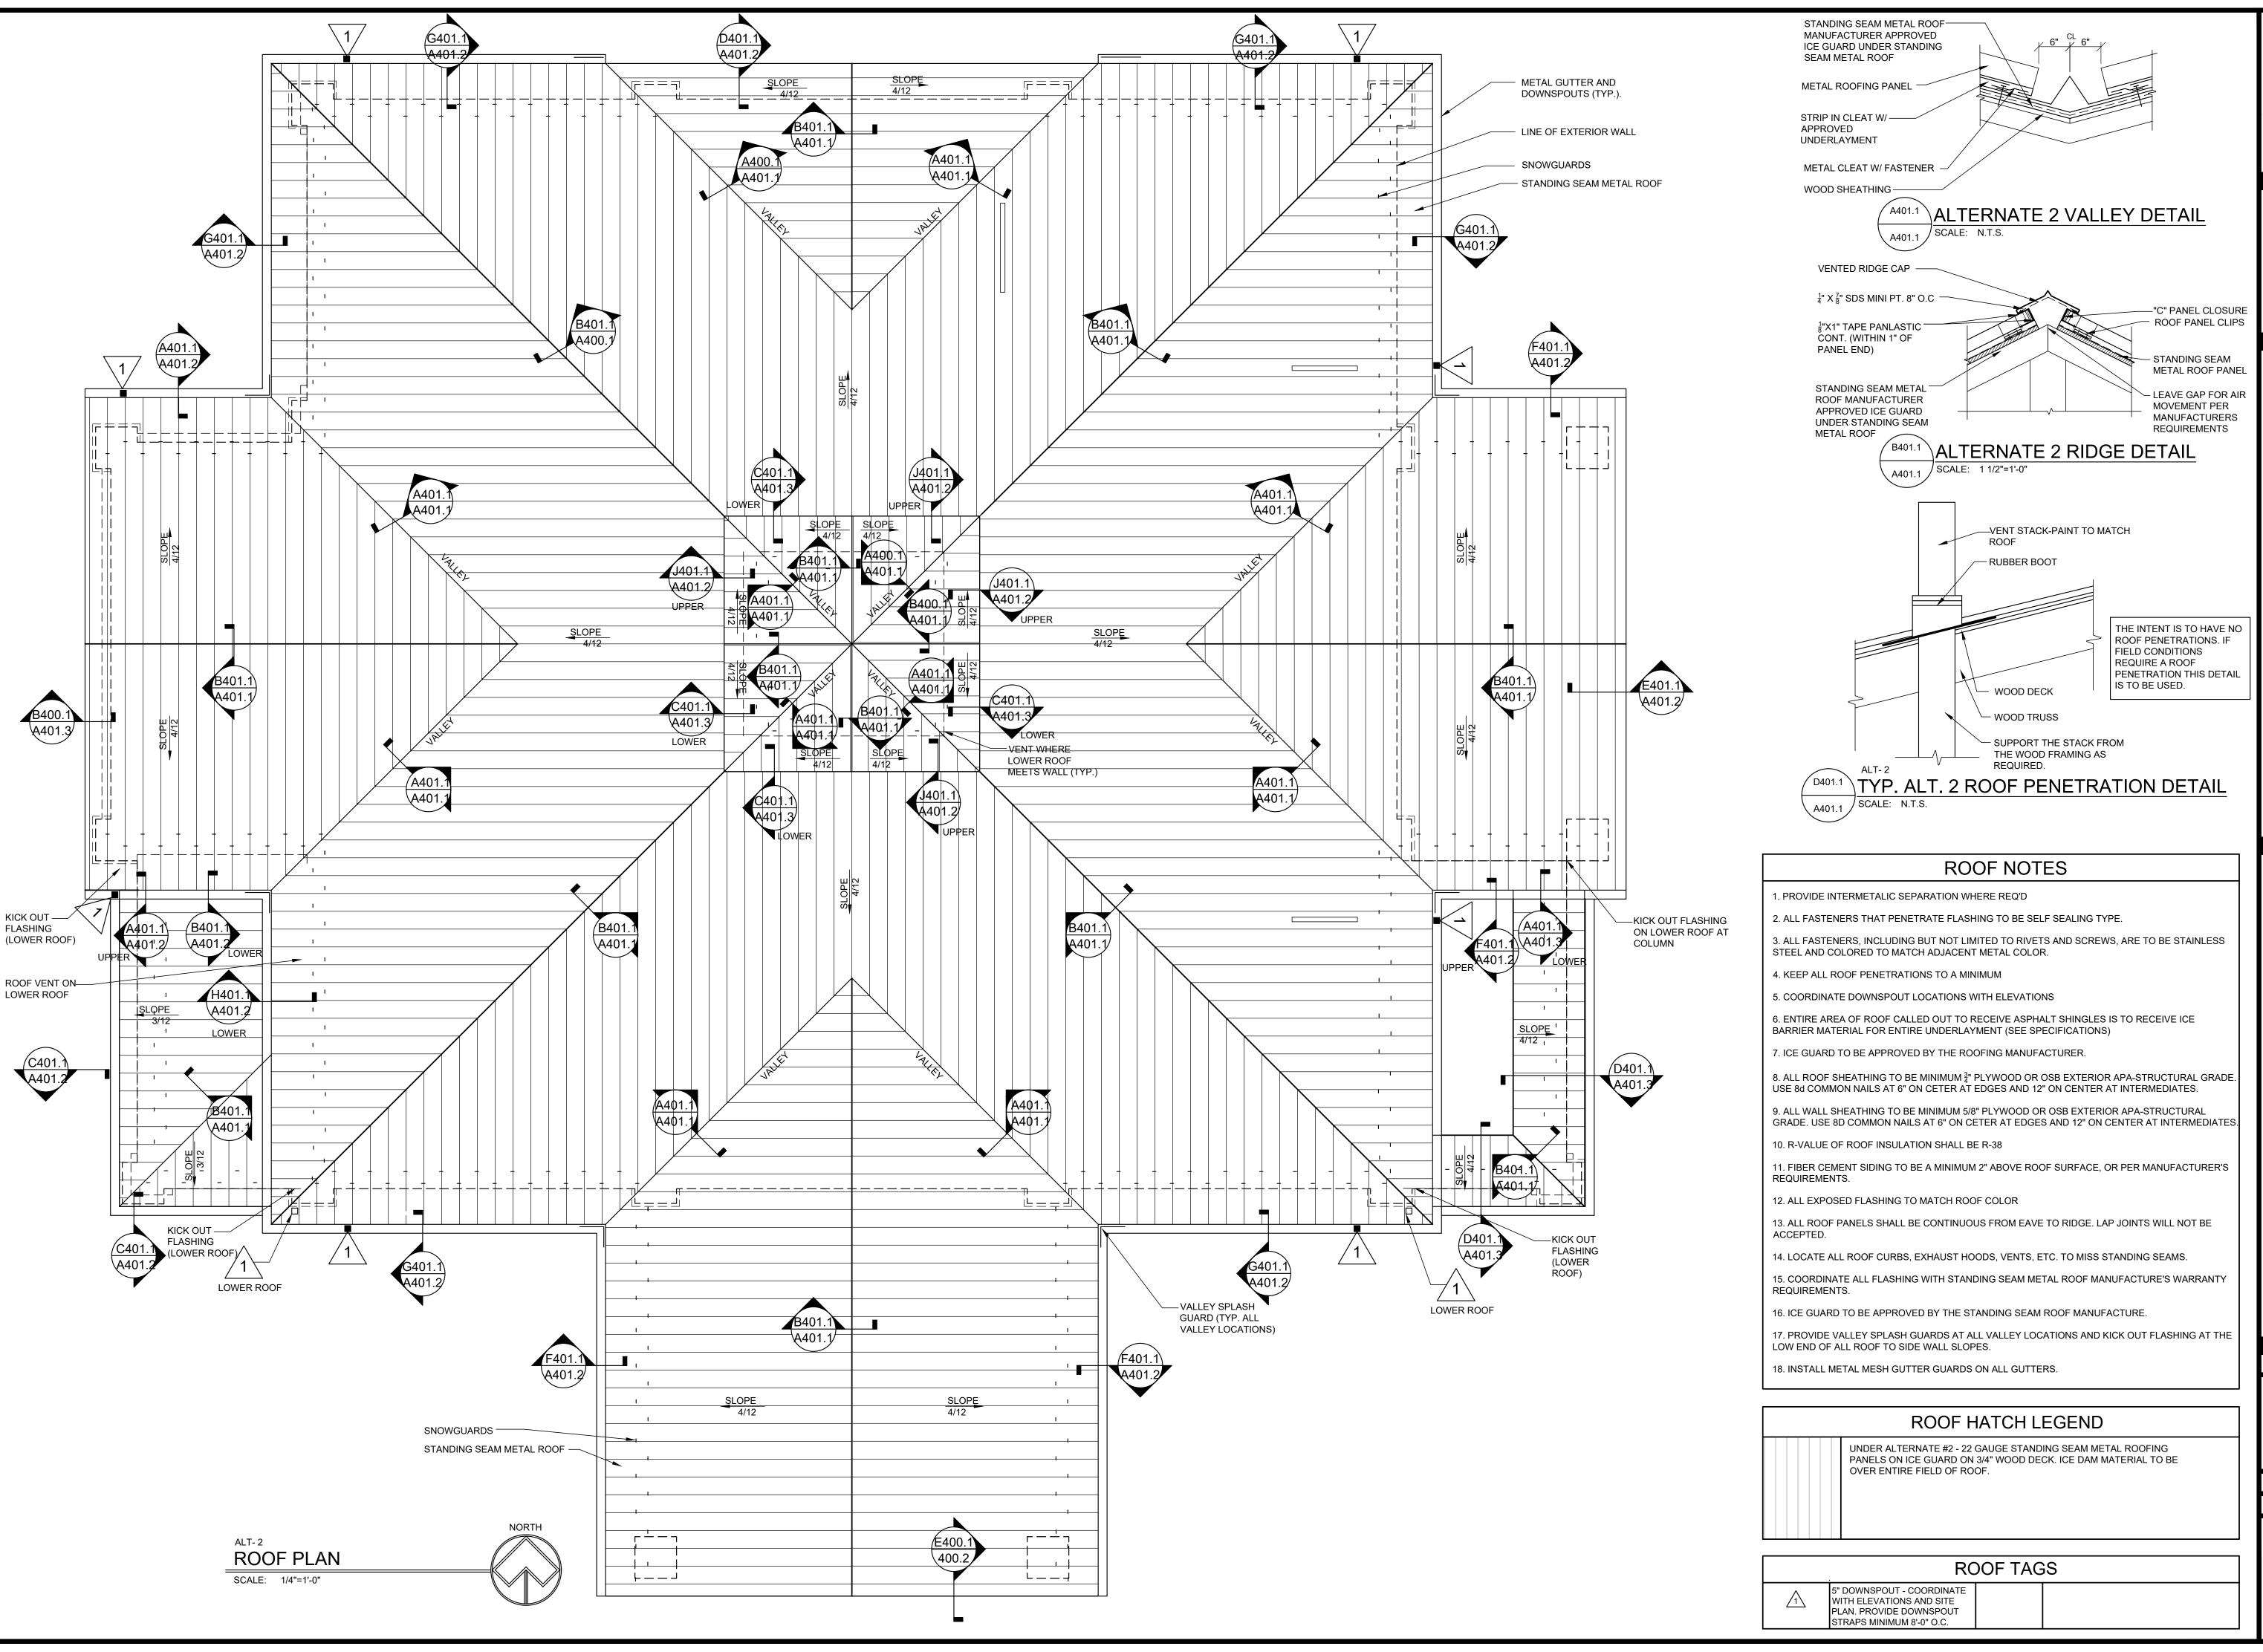

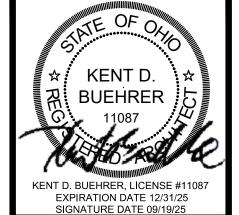

GLSM PARK OFFICE
FOR
HO DEPARTMENT OF NATURAL
RESOURCES DNR-250013

UEHRERGROUP chitecture & engineering, inc.

314


REVISION SCHEDULE

ISSUE DATE: 09/19/2025

JOB NUMBER: 241224

CONSTRUCTION DOCUMENTS

A401.1

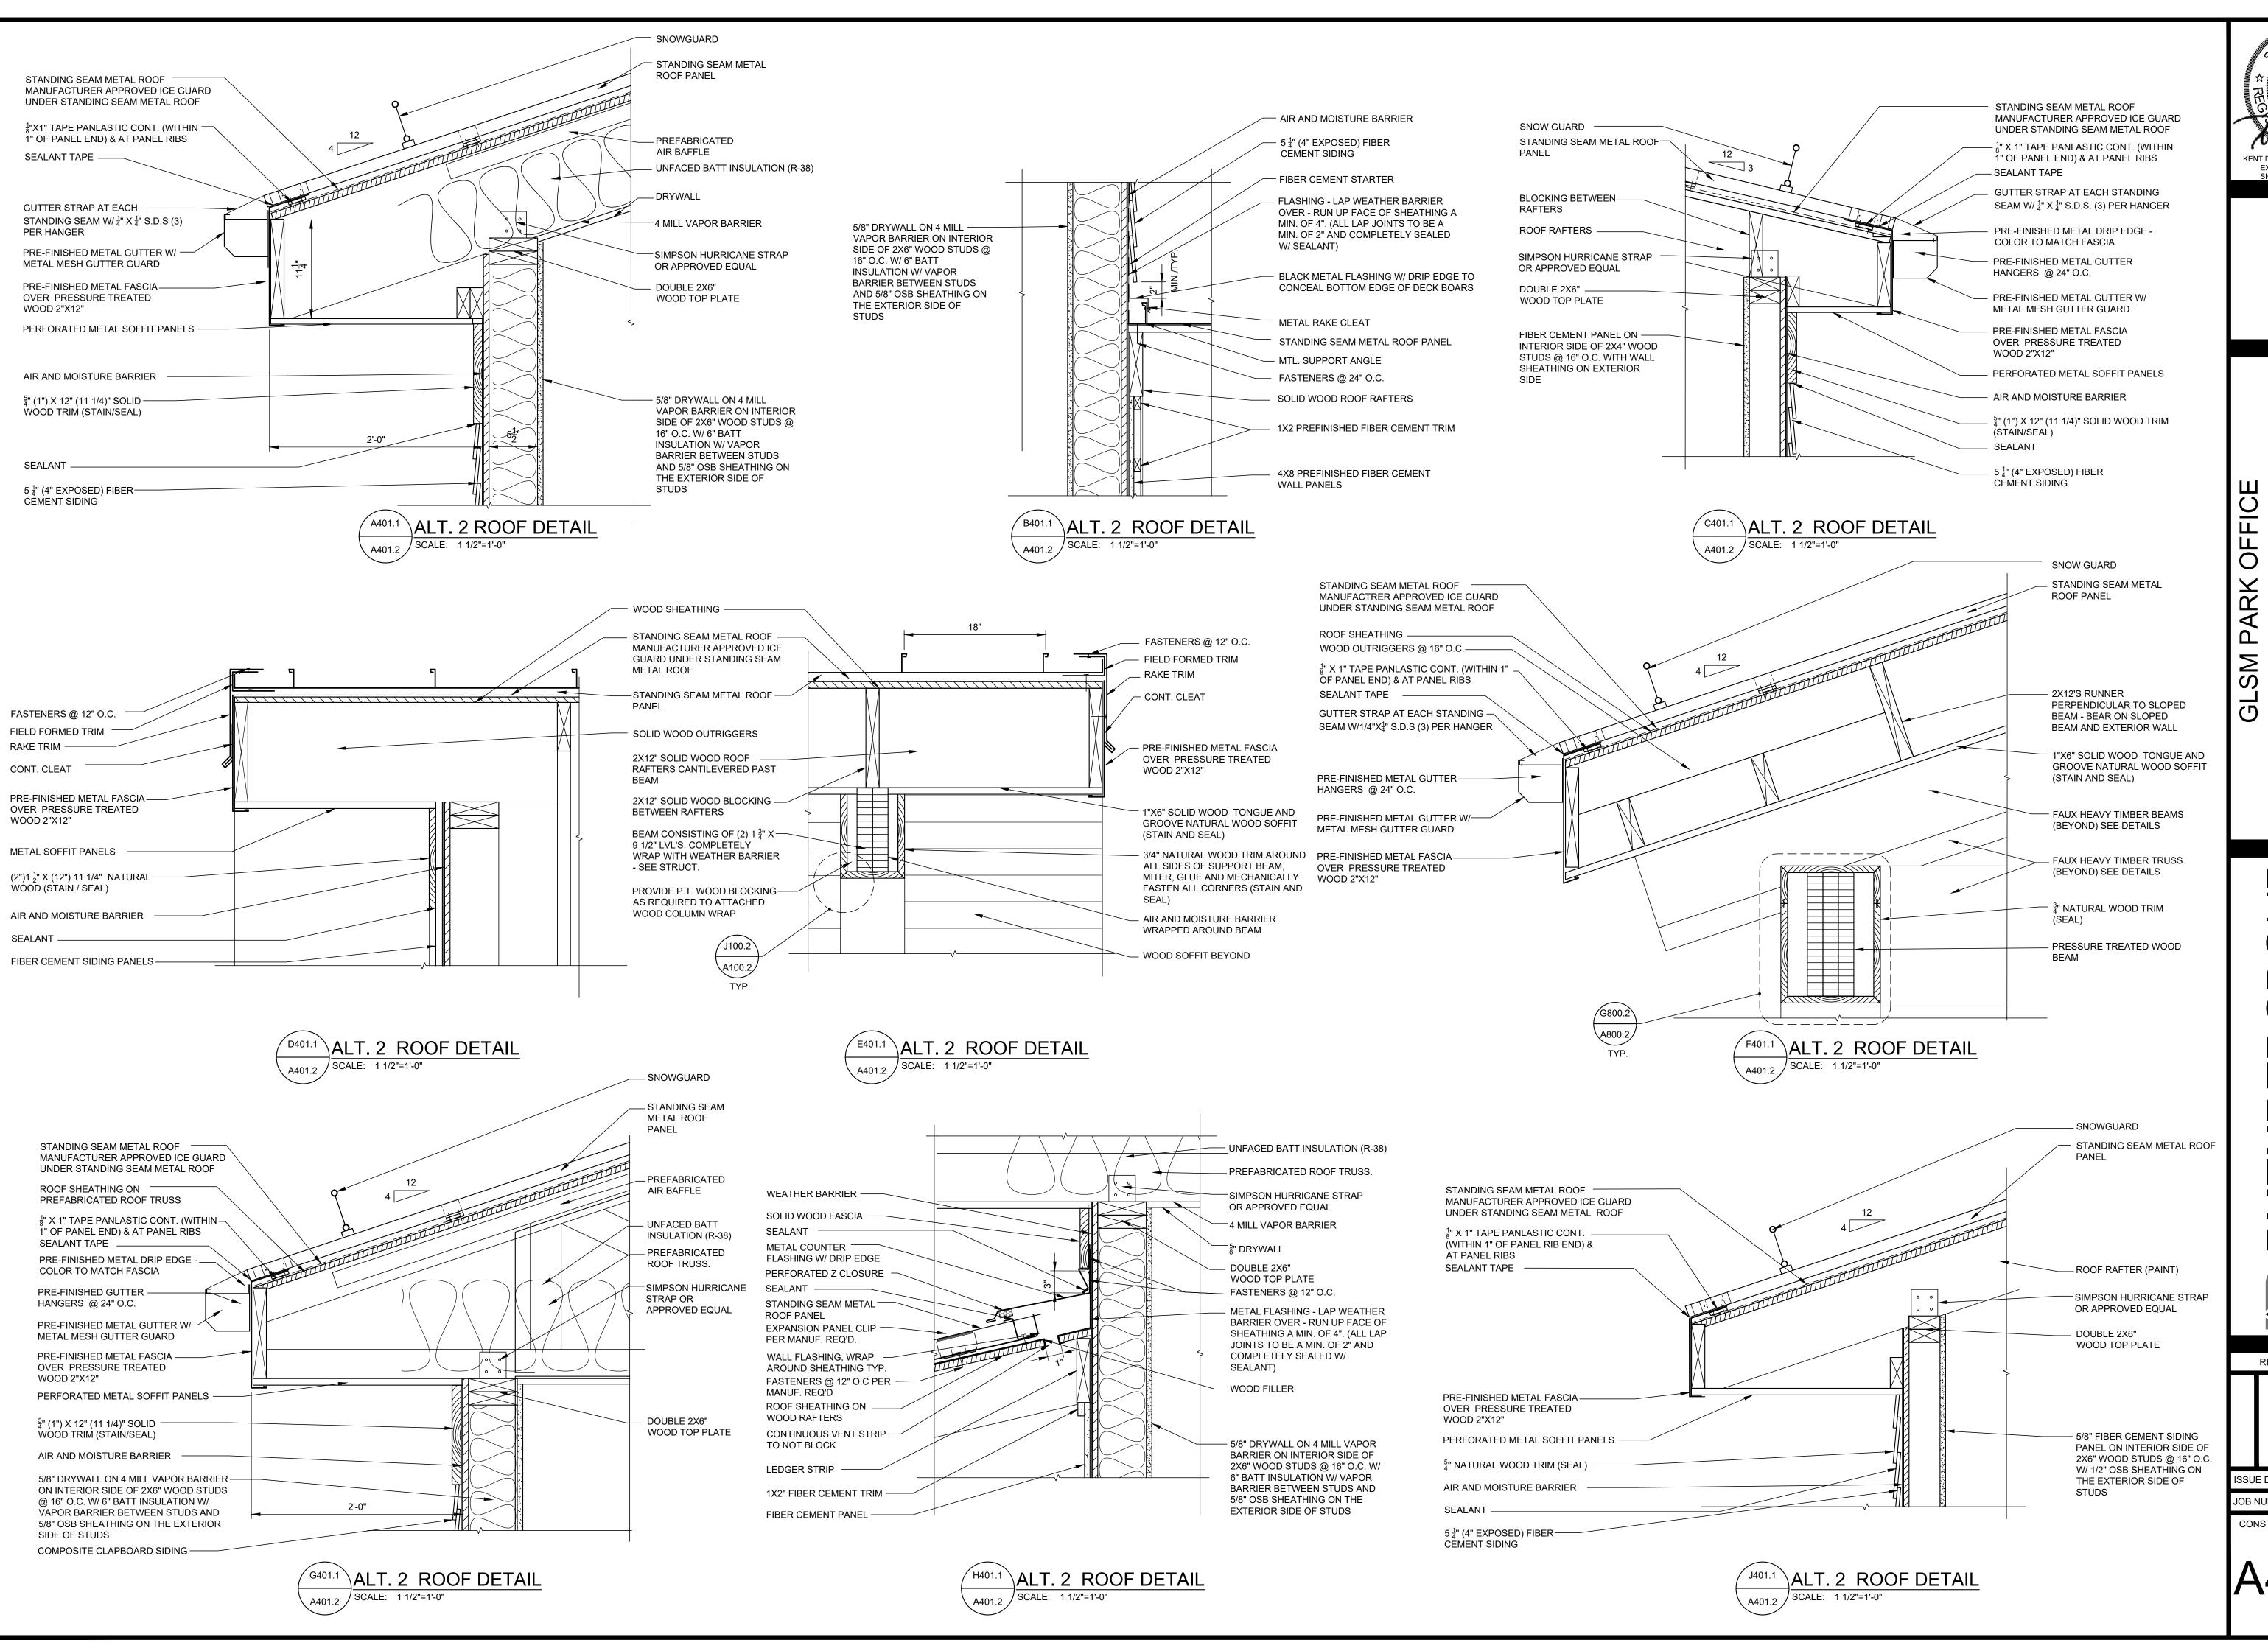

KENT D. **BUEHRER** 11087 KENT D. BUEHRER, LICENSE #11087 EXPIRATION DATE 12/31/25 SIGNATURE DATE 09/19/25

OM ARK FOR


> D (I)



REVISION SCHEDULE

ISSUE DATE: 09/19/2025

JOB NUMBER: 241224

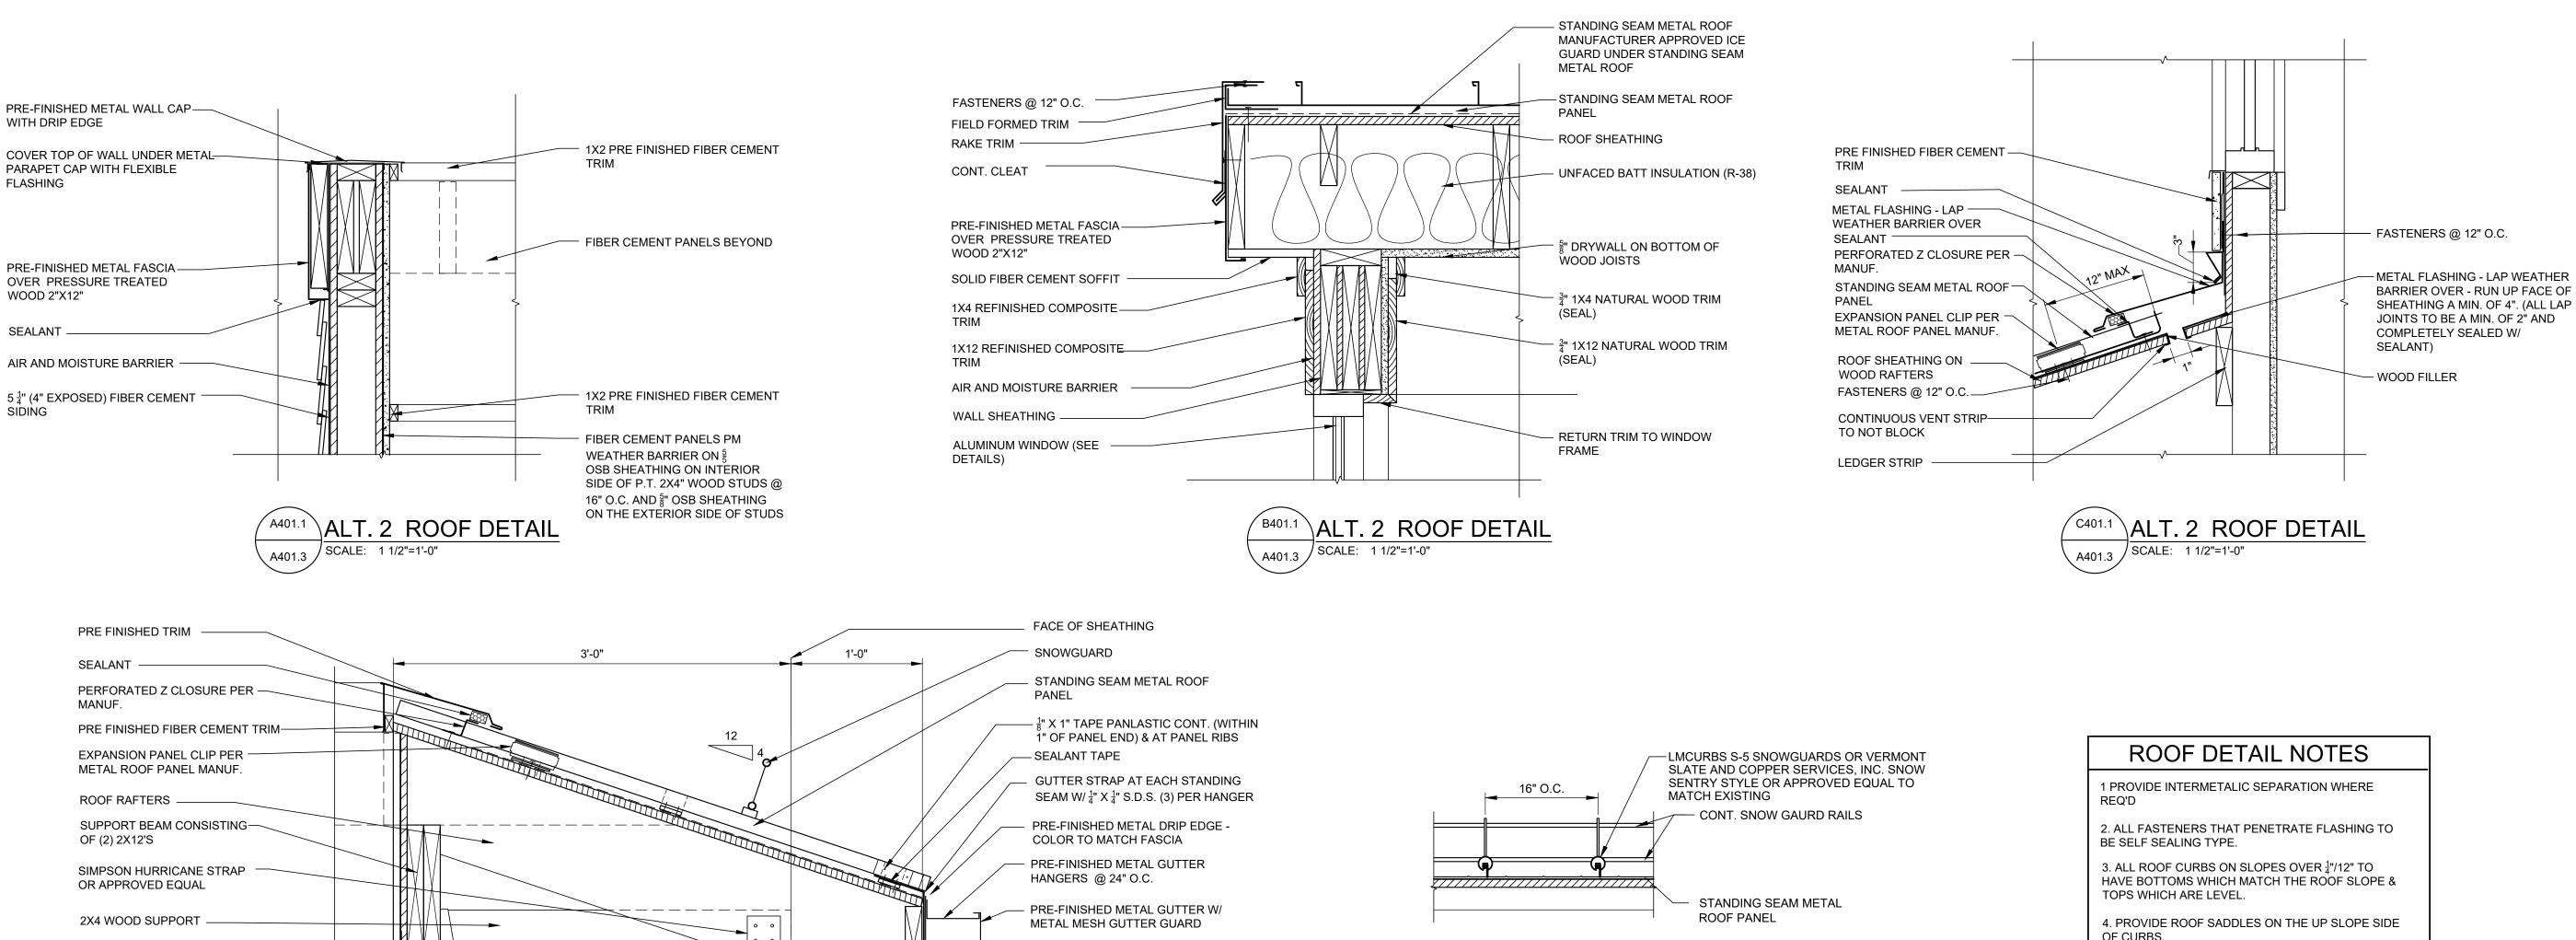

TYPICAL

SCALE: 1" =1'-0"

SNOW GUARD DETAIL - ELEVATION

PRE-FINISHED METAL FASCIA

PERFORATED METAL SOFFIT PANELS

 $(2")1\frac{1}{2}" X 8" NATURAL WOOD (STAIN / SEAL)$

OVER PRESSURE TREATED

AIR AND MOISTURE BARRIER

 $5\frac{1}{4}$ " (4" EXPOSED) FIBER CEMENT SIDING

WOOD 2"X12"

SEALANT

ALT. 2 ROOF DETAIL

SCALE: 1 1/2"=1'-0"

METAL FLASHING WITH -

FIBER CEMENT PANELS—

PRE FINISHED FIBER CEMENT

DRIP EDGE

OF CURBS.

5. PROVIDE INSULATION SUPPORT STRAPS, METAL FURRING STRIPS, ETC. AS REQUIRED TO HOLD INSULATION IN PLACE WHEREVER STUD WALLS DON'T HAVE SHEATHING ON ONE OR BOTH SIDES.

OFFICE 0 2 PARK FOR SM GL

KENT D. BUEHRER

11087


KENT D. BUEHRER, LICENSE #11087 EXPIRATION DATE 12/31/25 SIGNATURE DATE 09/19/25



REVISION SCHEDULE

ISSUE DATE: 09/19/2025

JOB NUMBER: 241224

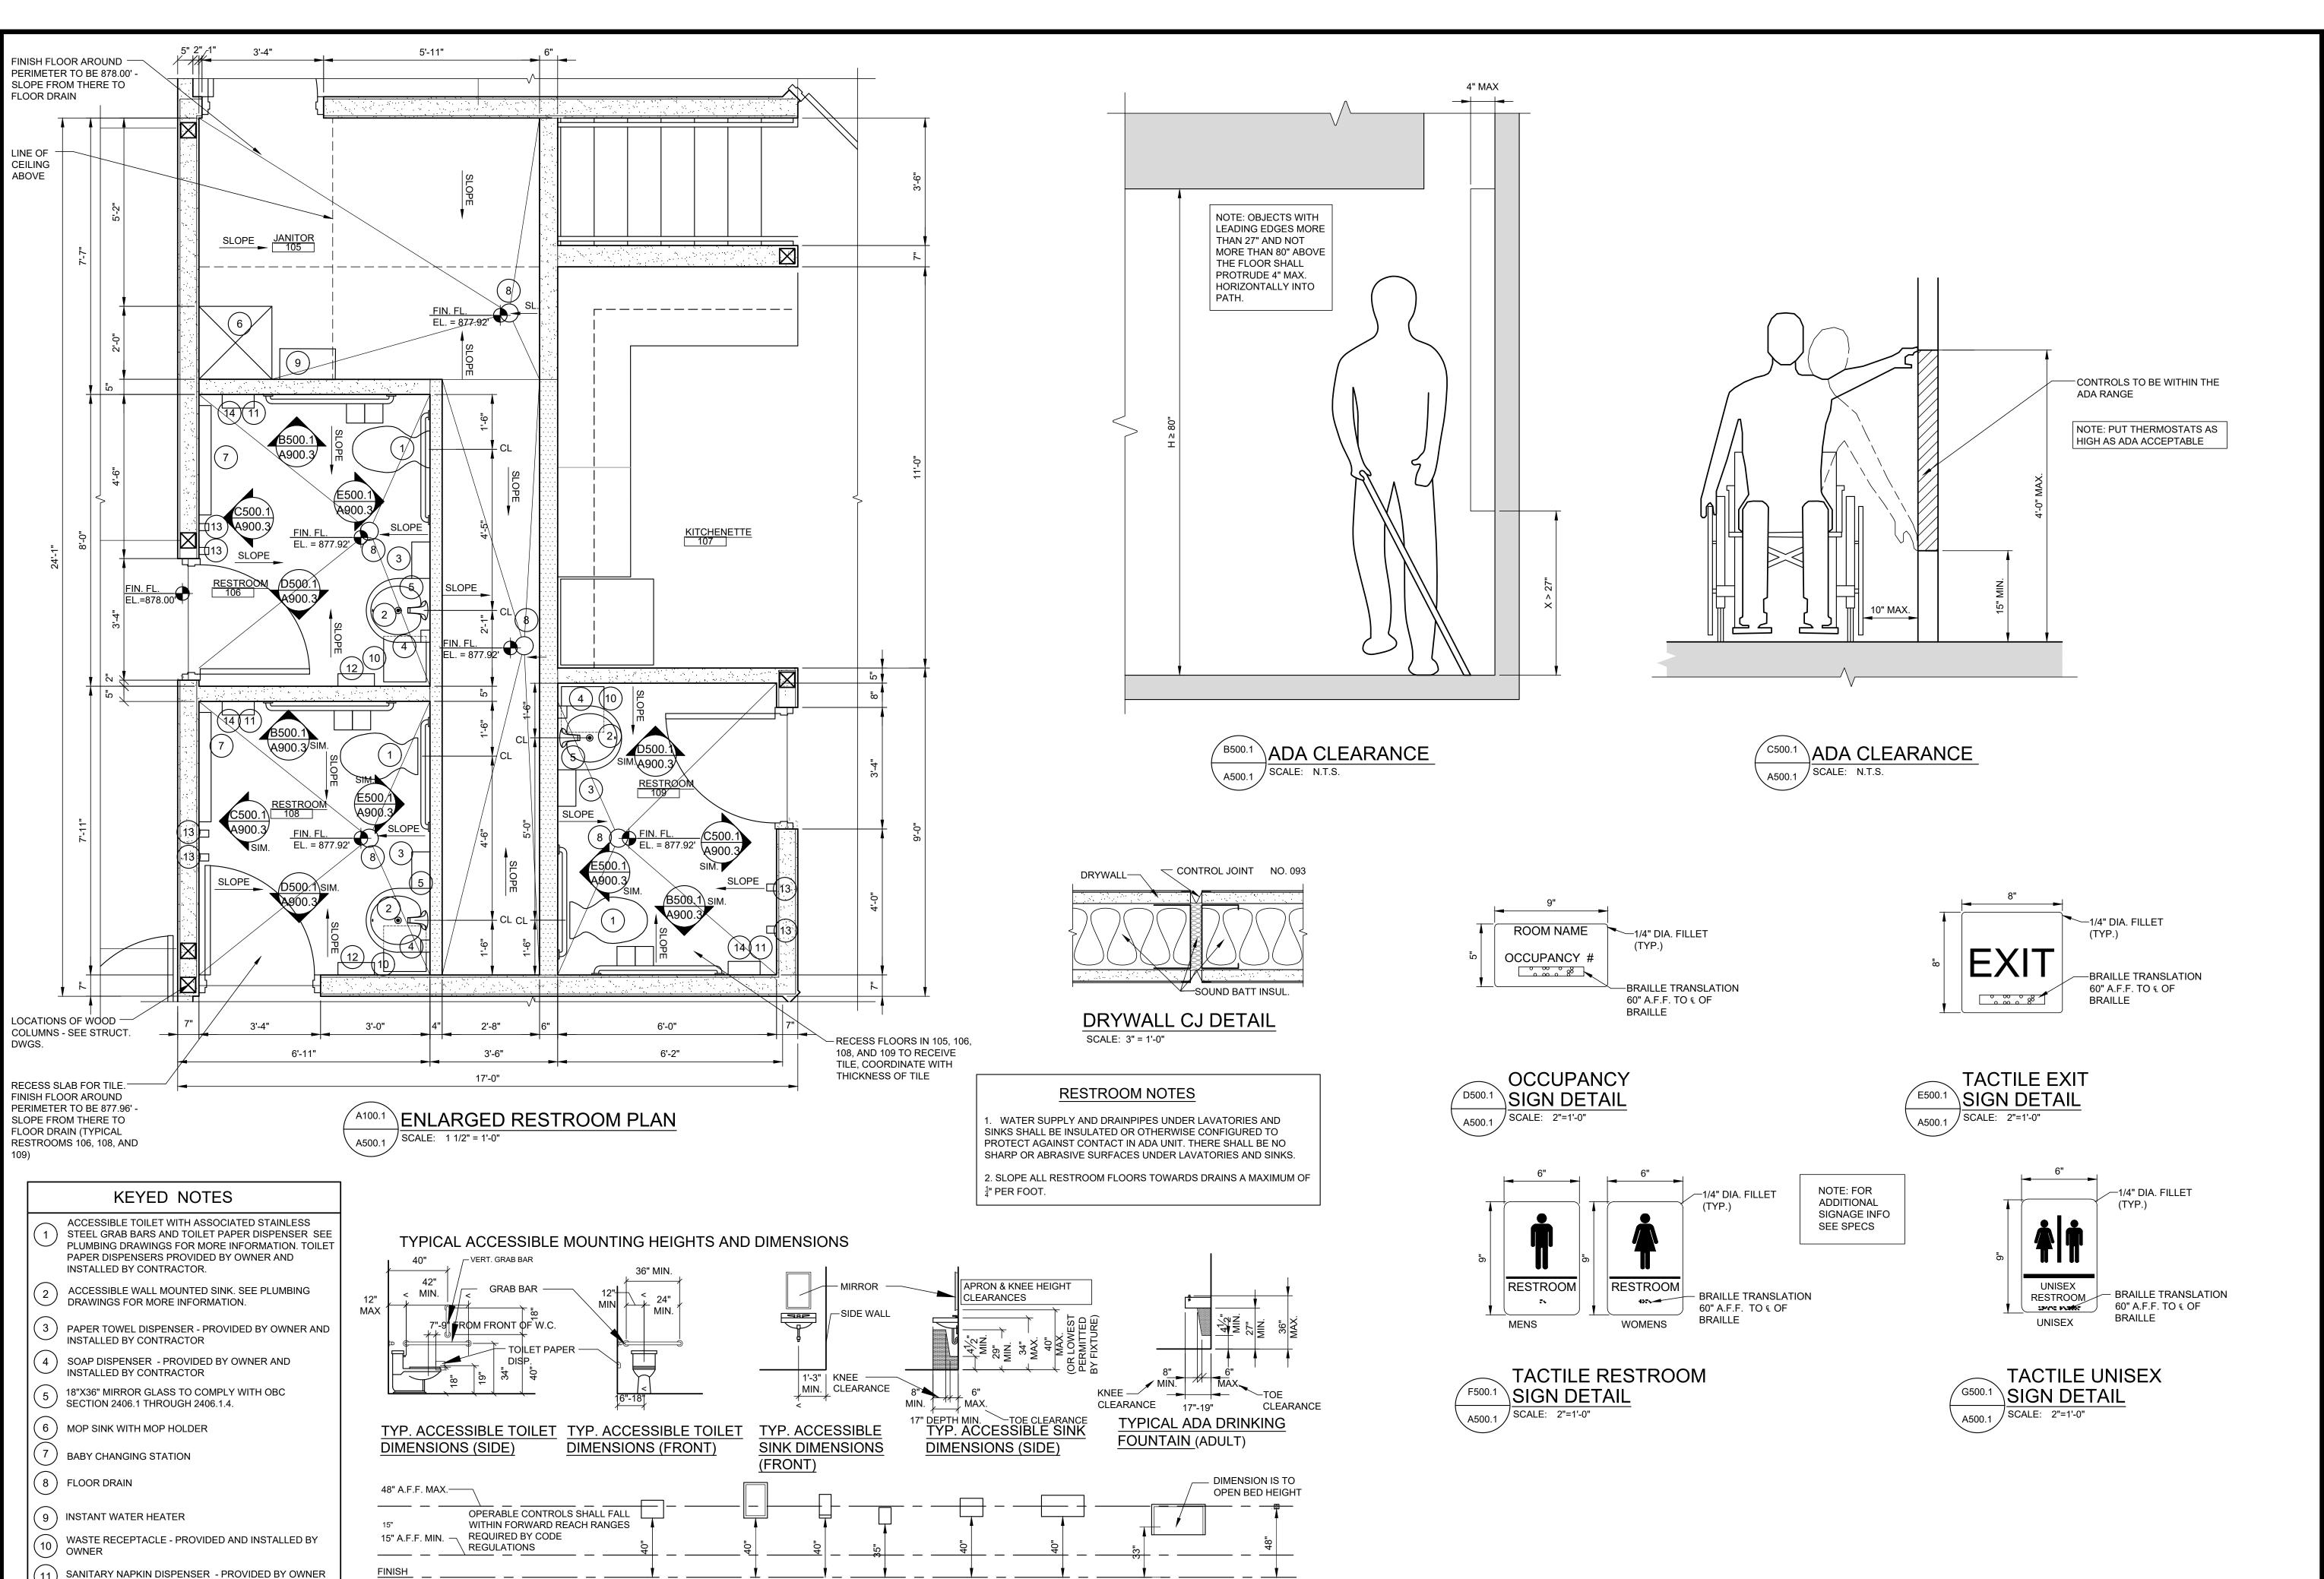

SANITARY

DISPENSER

NAPKIN

BABY

CHANGING

STATION

COAT

HOOK

(ADA)

SOAP

NAPKIN

NOTE: THE PURPOSE OF THIS SECTION IS TO SHOW TYPICAL ACCESSIBLE (ICC A117.1) DIMENSIONS AND MOUNTING HEIGHTS ONLY. ALL

FIXTURES AND ACCESSORIES SHOWN IN THIS SECTION ARE SHOWN GENERICALLY AND ARE FOR REFERENCE PURPOSES ONLY.

DISPOSAL

HAND

DRYER

DISP.

16"X36"

MIRROR

TOWEL DISPENSER

MOUNTING HEIGHT

AND INSTALLED BY CONTRACTOR

AND INSTALLED BY CONTRACTOR

(14) SANITARY NAPKIN DISPOSAL - PROVIDED BY OWNER

(12) ELECTRIC HAND DRYERS

(13) COAT HOOKS

KENT D. BUEHRER 11087

EXPIRATION DATE 12/31/25
SIGNATURE DATE 09/19/25

NATURAL 50013

GLSM PARK OFFICE
FOR
OHIO DEPARTMENT OF NATU
RESOURCES DNR-250013

Chitecture & engineering, inc.

ar co

REVISION SCHEDULE

ISSUE DATE: 09/19/2025

JOB NUMBER: 241224

CONSTRUCTION DOCUMENTS

A500.







[A] OFFICE PARK FOR

OE

ering



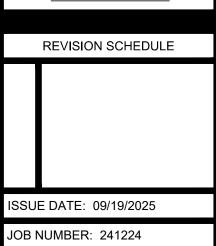

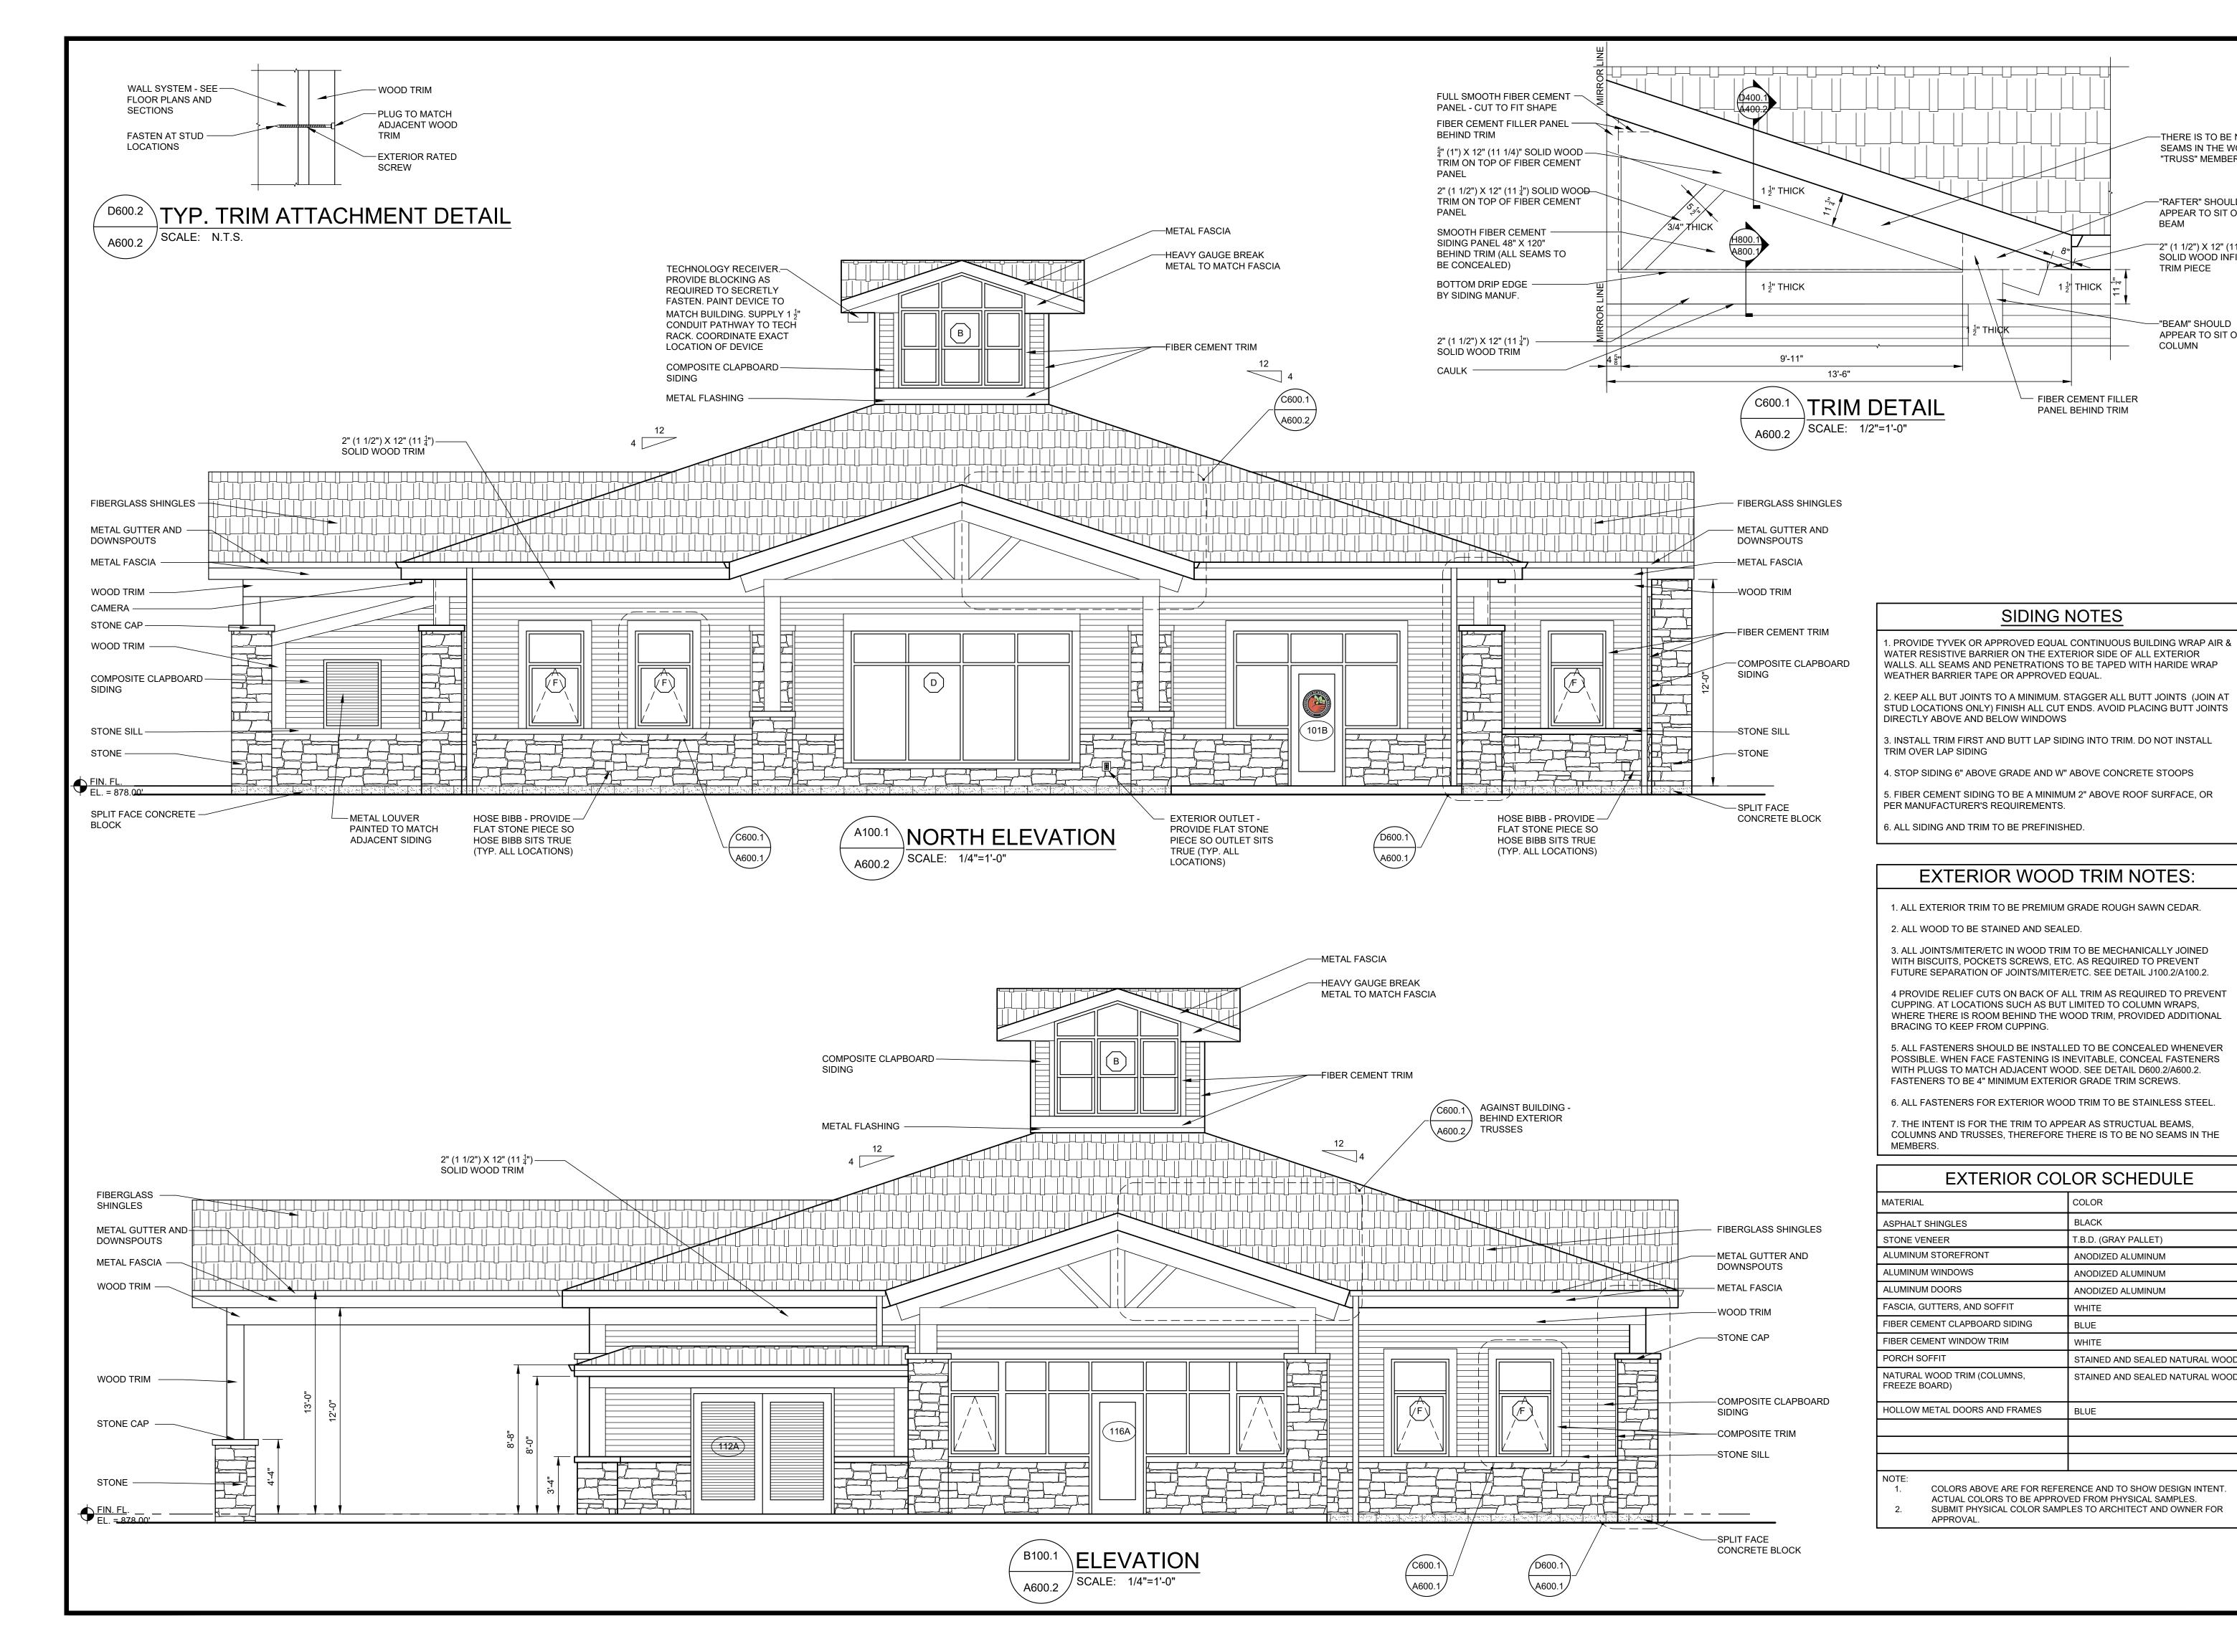

KENT D. **BUEHRER** 11087 KENT D. BUEHRER, LICENSE #11087 EXPIRATION DATE 12/31/25 SIGNATURE DATE 09/19/25

-THERE IS TO BE NO

SEAMS IN THE WOO

"TRUSS" MEMBERS

-"RAFTER" SHOULD

APPEAR TO SIT ON

2" (1 1/2") X 12" (11

SOLID WOOD INFILL

-"BEAM" SHOULD APPEAR TO SIT ON

COLUMN

TRIM PIECE

BEAM

OFFICE 0 2 PARK FOR SM GL

> D O

REVISION SCHEDULE

ISSUE DATE: 09/19/2025

JOB NUMBER: 241224











B600.3 EXTERIOR RENDERING
SCALE: 1/4"=1'-0"



GLSM PARK OFFICE
FOR
OHIO DEPARTMENT OF NATURAL
RESOURCES DNR-250013

BUEHRERGROUP.COM

architecture & engineering, inc.
314 CONANT ST., MAUMEE, OH 43537 I P:419.893.9027 I BUEHRERGROUP.COM



REVISION SCHEDULE


ISSUE DATE: 09/19/2025


JOB NUMBER: 241224

CONSTRUCTION DOCUMENTS

A600.3

NOTE: RENDERINGS ARE FOR REFERENCE AND ARE TO CONVEY DESIGN INTENT ONLY. DO NOT SCALE OFF RENDERINGS. REFER TO DRAWINGS FOR ALL CONSTRUCTION DETAILS

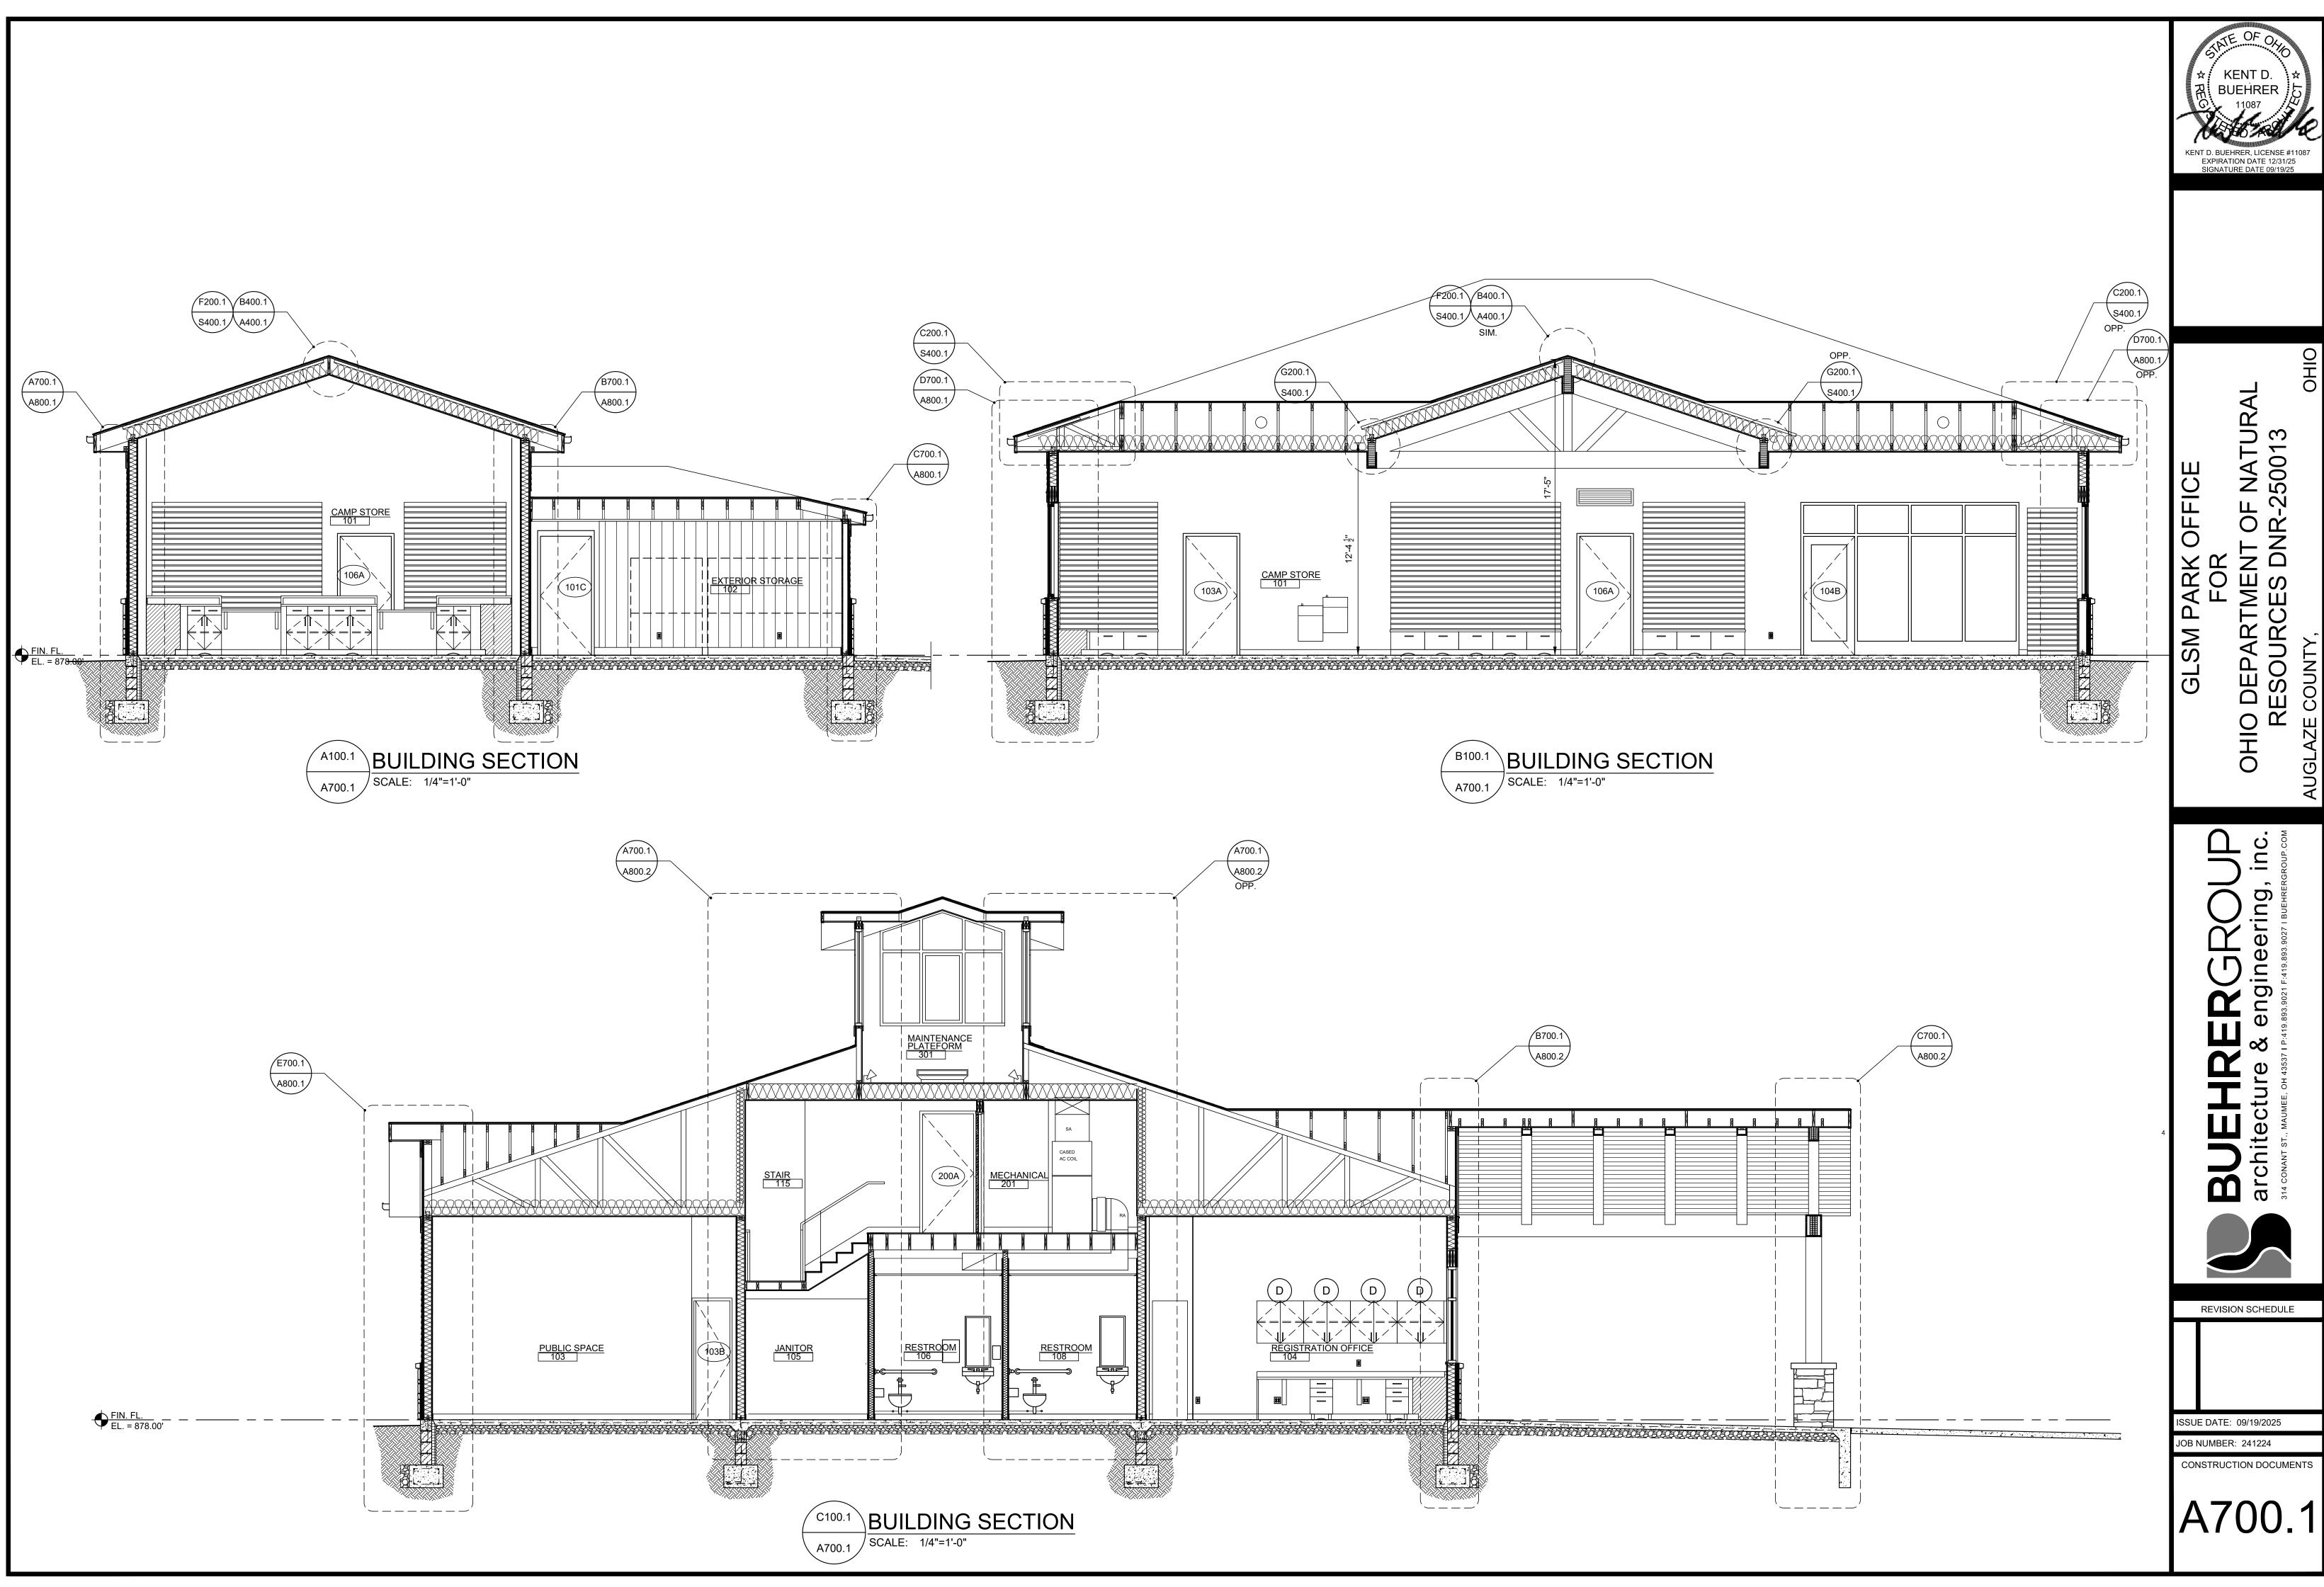

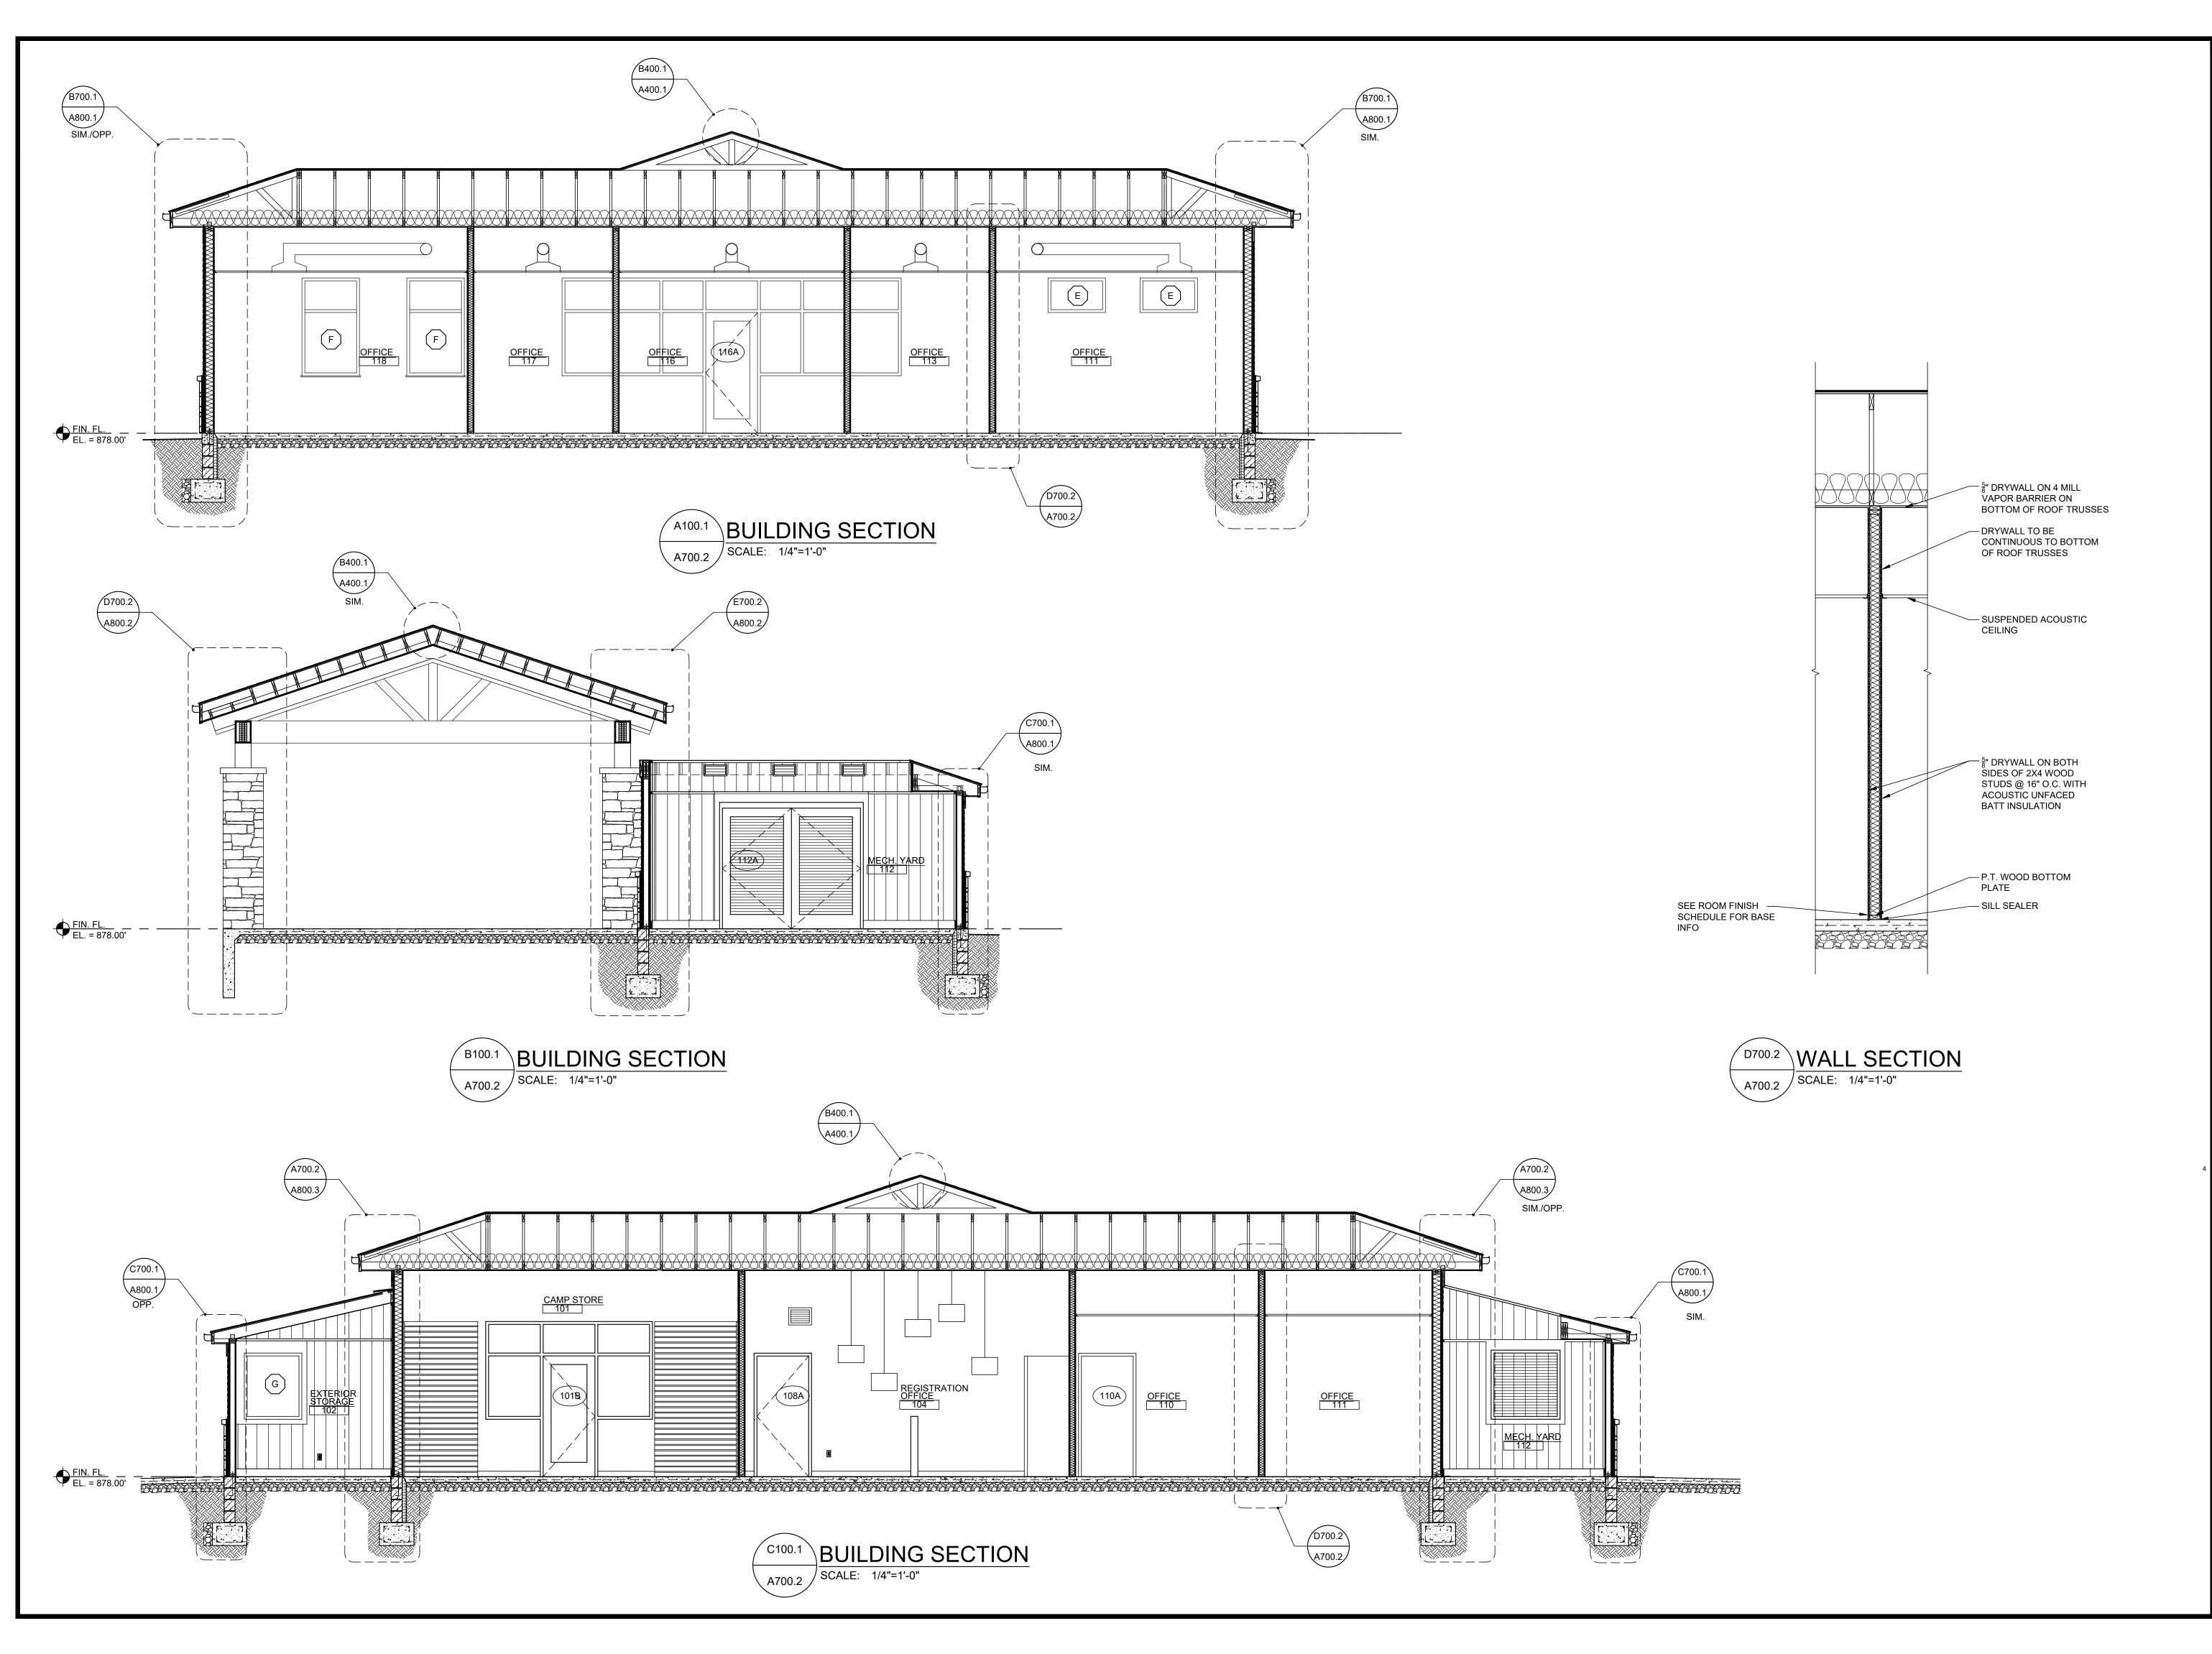



GLSM PARK OFFICE FOR OHIO DEPARTMENT OF NATURAI RESOURCES DNR-250013

BUEHRERGROUP.COM

architecture & engineering, inc.
314 CONANT ST., MAUMEE, OH 43537 I P: 419.893.9027 I BUEHRERGROUP.COM




REVISION SCHEDULE

ISSUE DATE: 09/19/2025

JOB NUMBER: 241224

CONSTRUCTION DOCUMENTS

A700.2

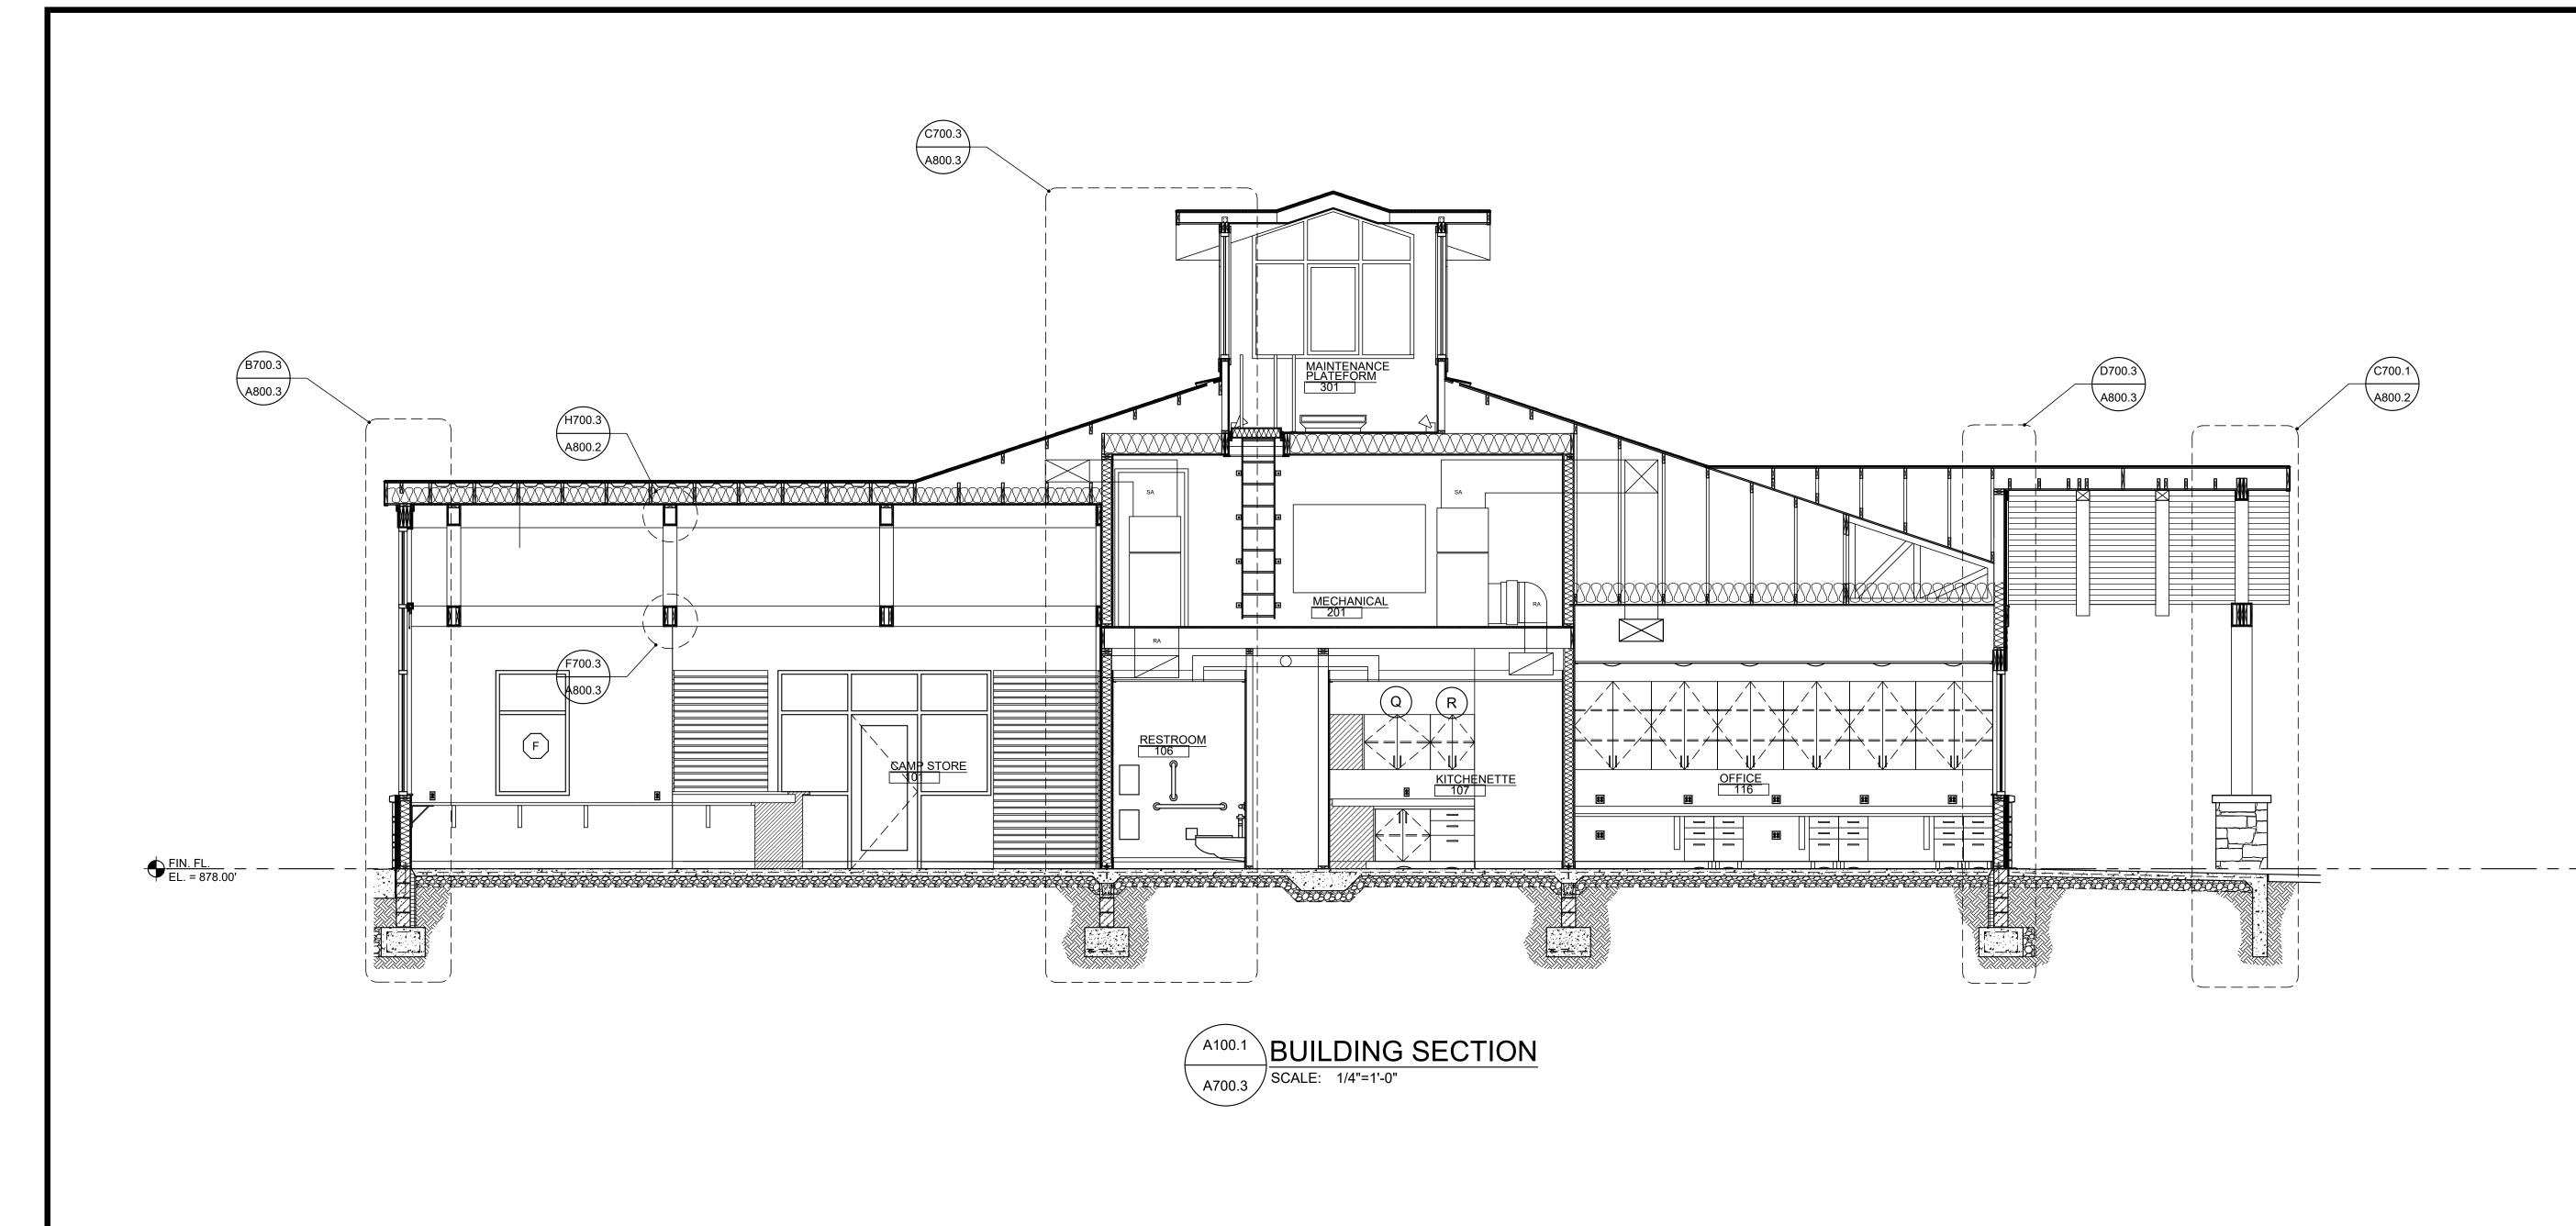




GLSM PARK OFFICE
FOR
OHIO DEPARTMENT OF NATUR

BUEHRERGROUP COM architecture & engineering, inc. 314 CONANT ST., MAUMEE, OH 43537 I P:419.893.9027 I BUEHRERGROUP COM




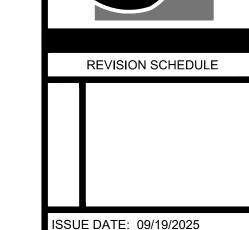


JOB NUMBER: 241224

CONSTRUCTION DOCUMENTS

A700.3

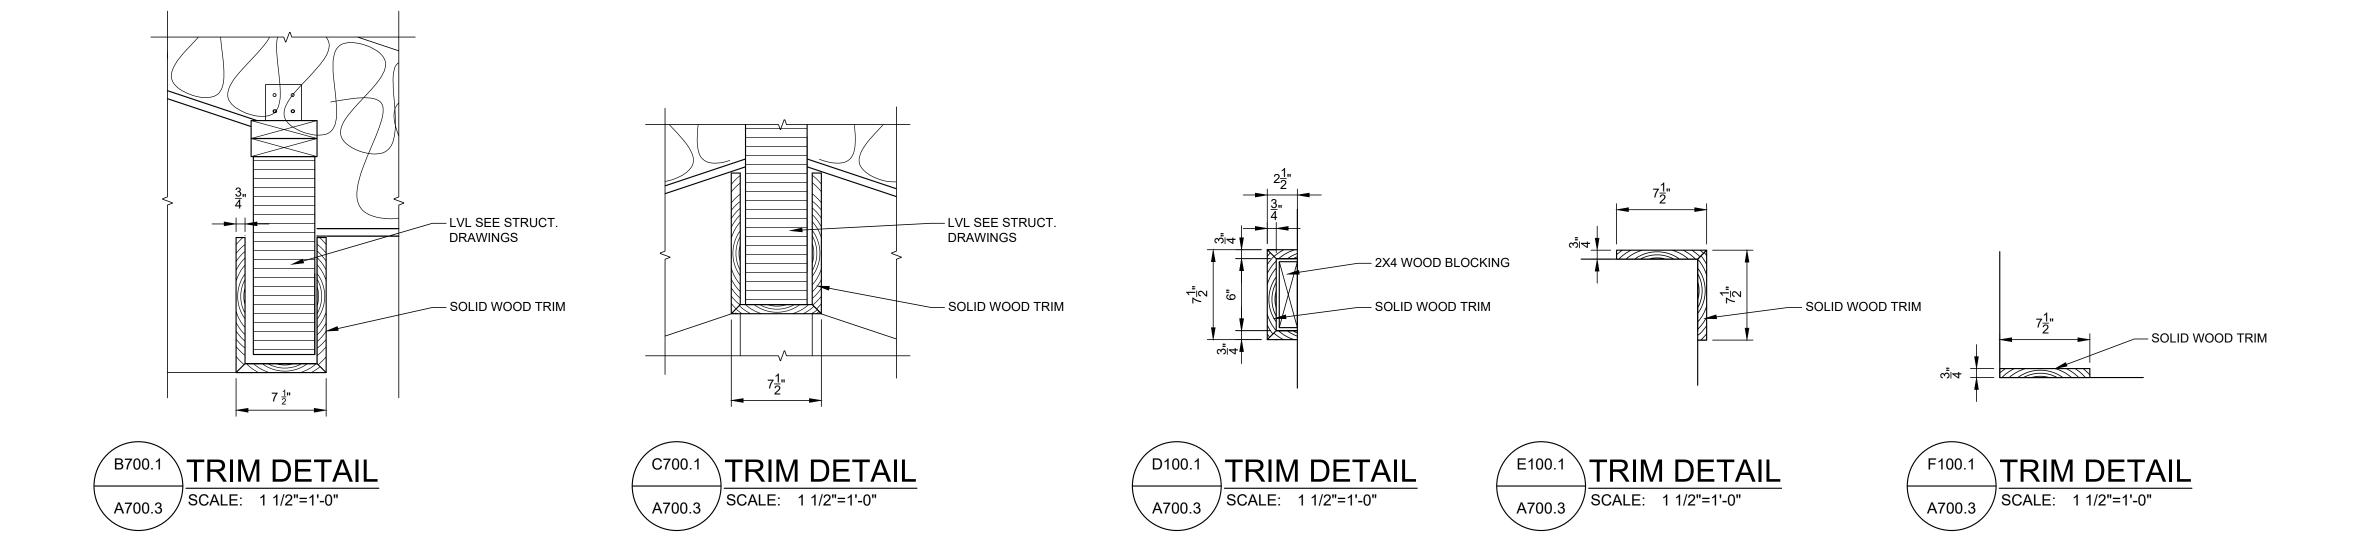

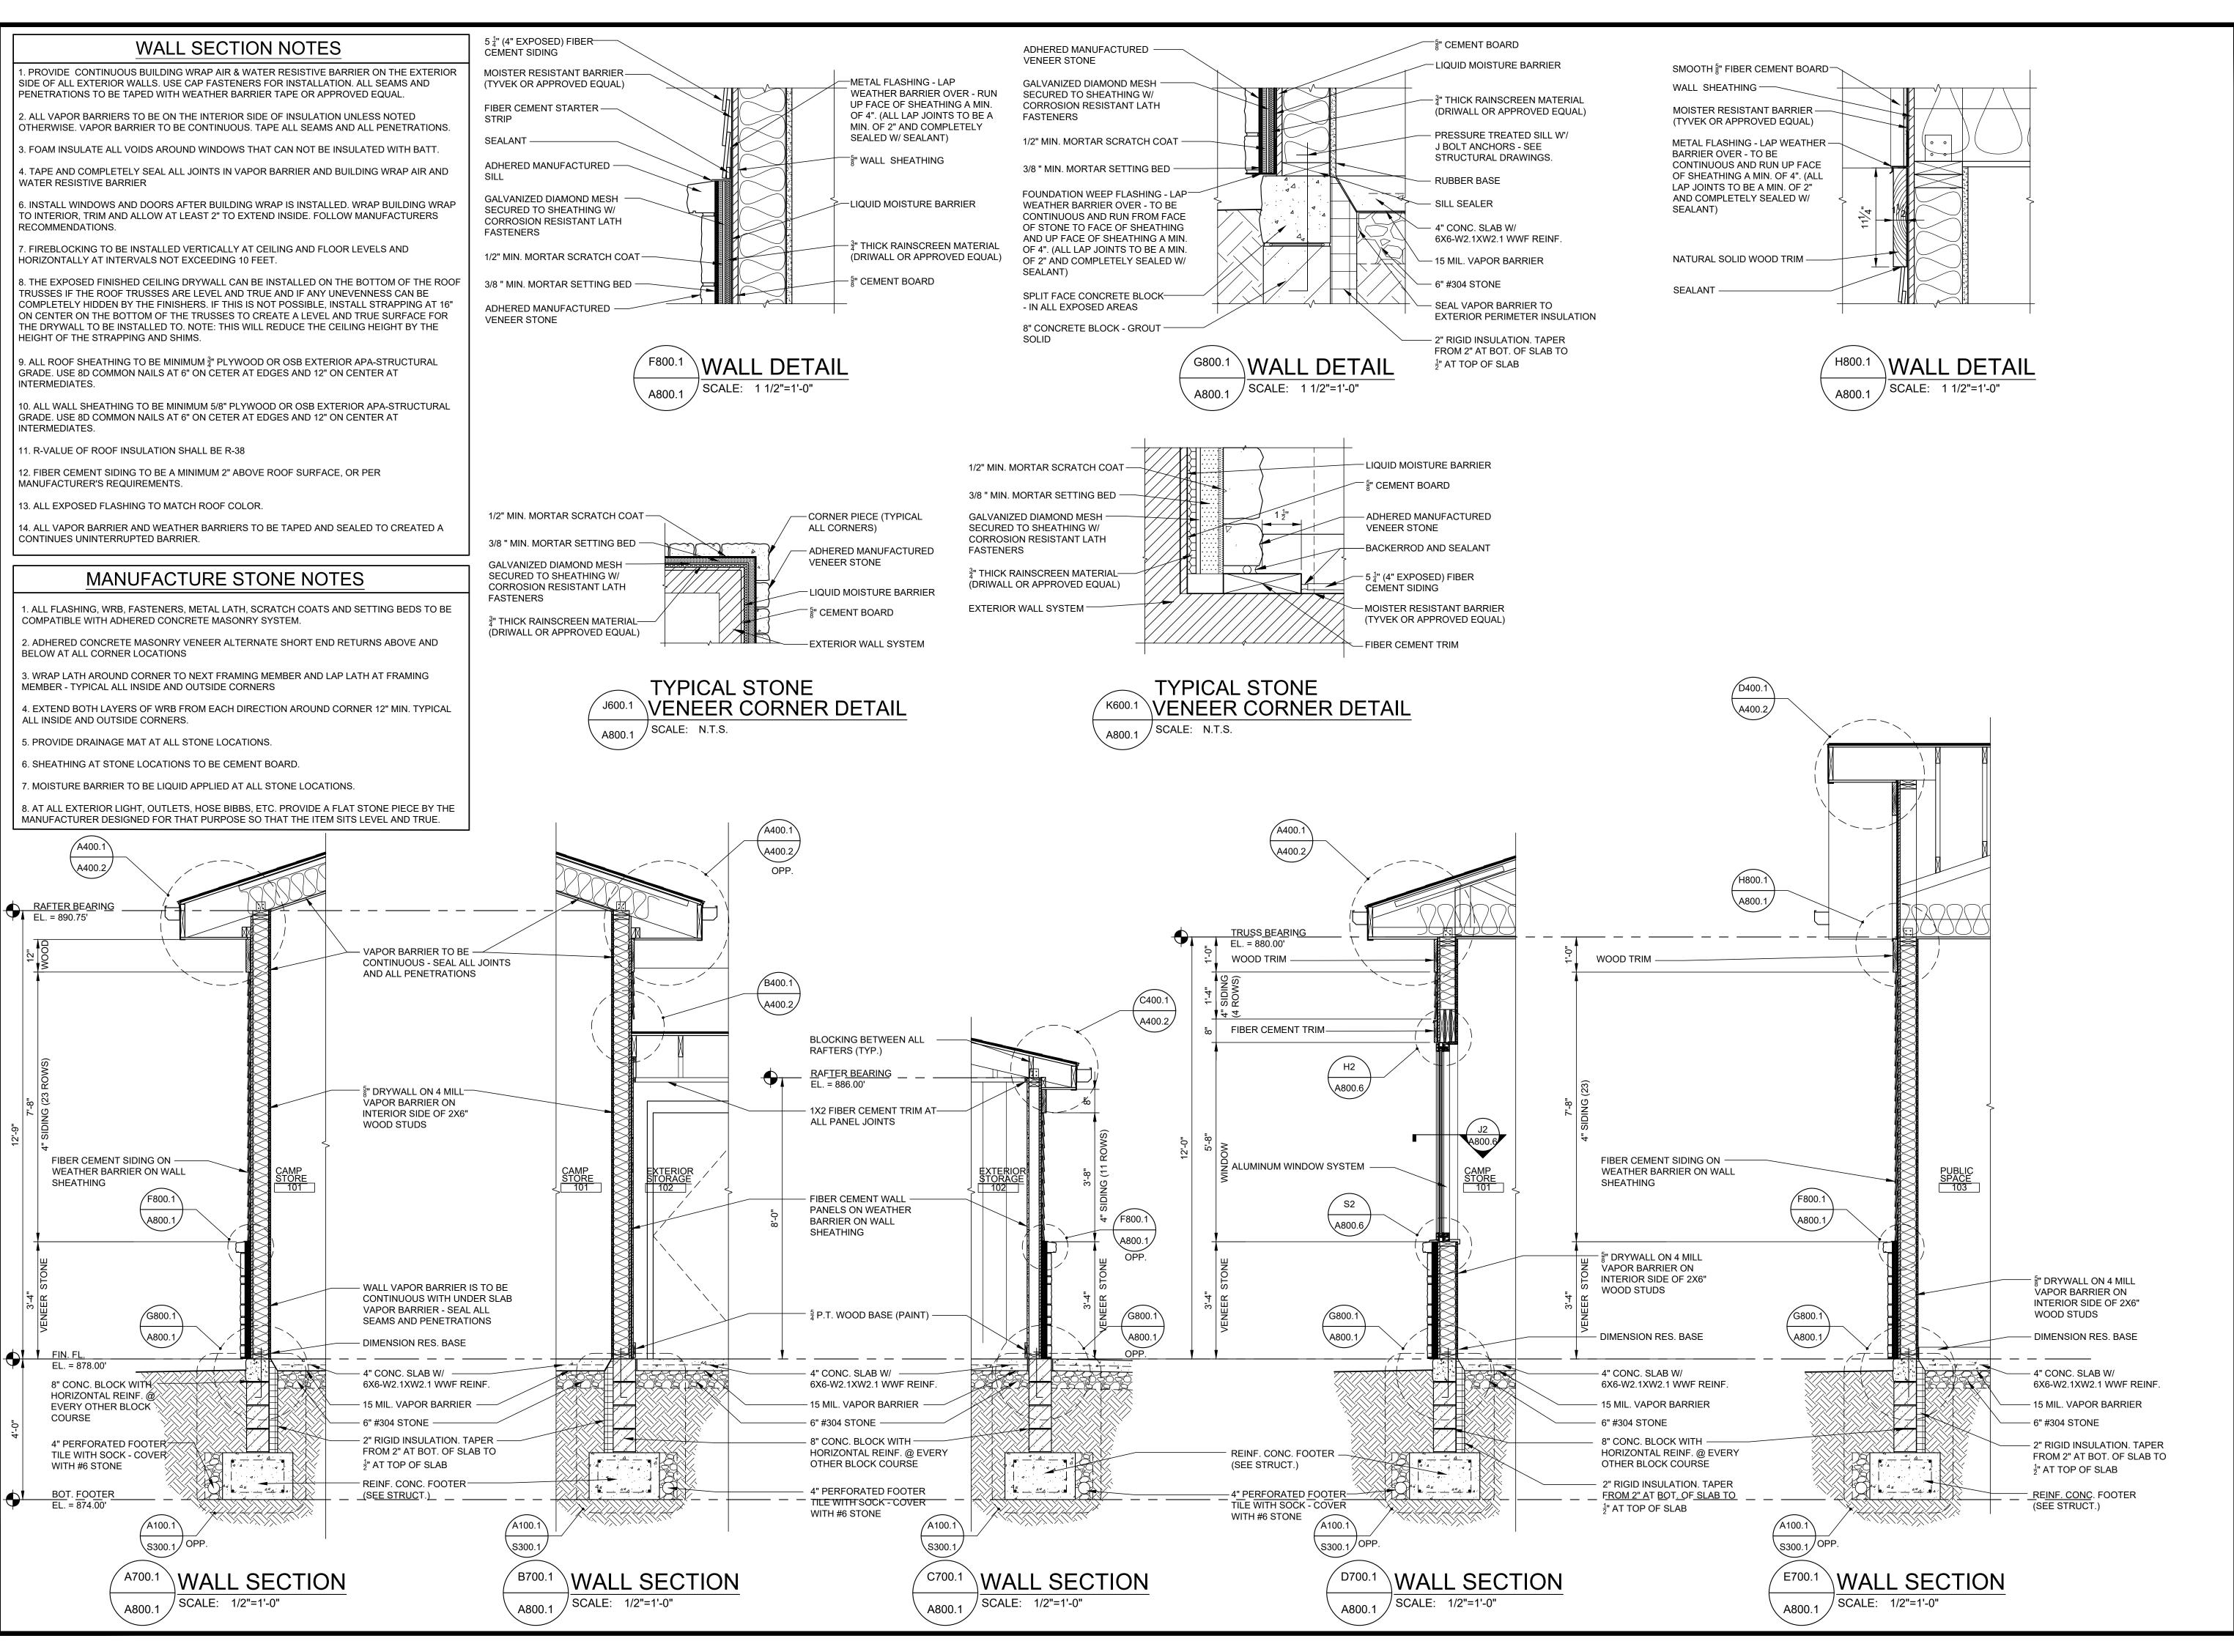



GLSM PARK OFFICE
FOR
IO DEPARTMENT OF NATURAL
RESOURCES DNR-250013

BUEHREROUP UP architecture & engineering, inc.


REVISION SCHEDULE


ISSUE DATE: 09/19/2025


JOB NUMBER: 241224

CONSTRUCTION DOCUMENTS

A800.

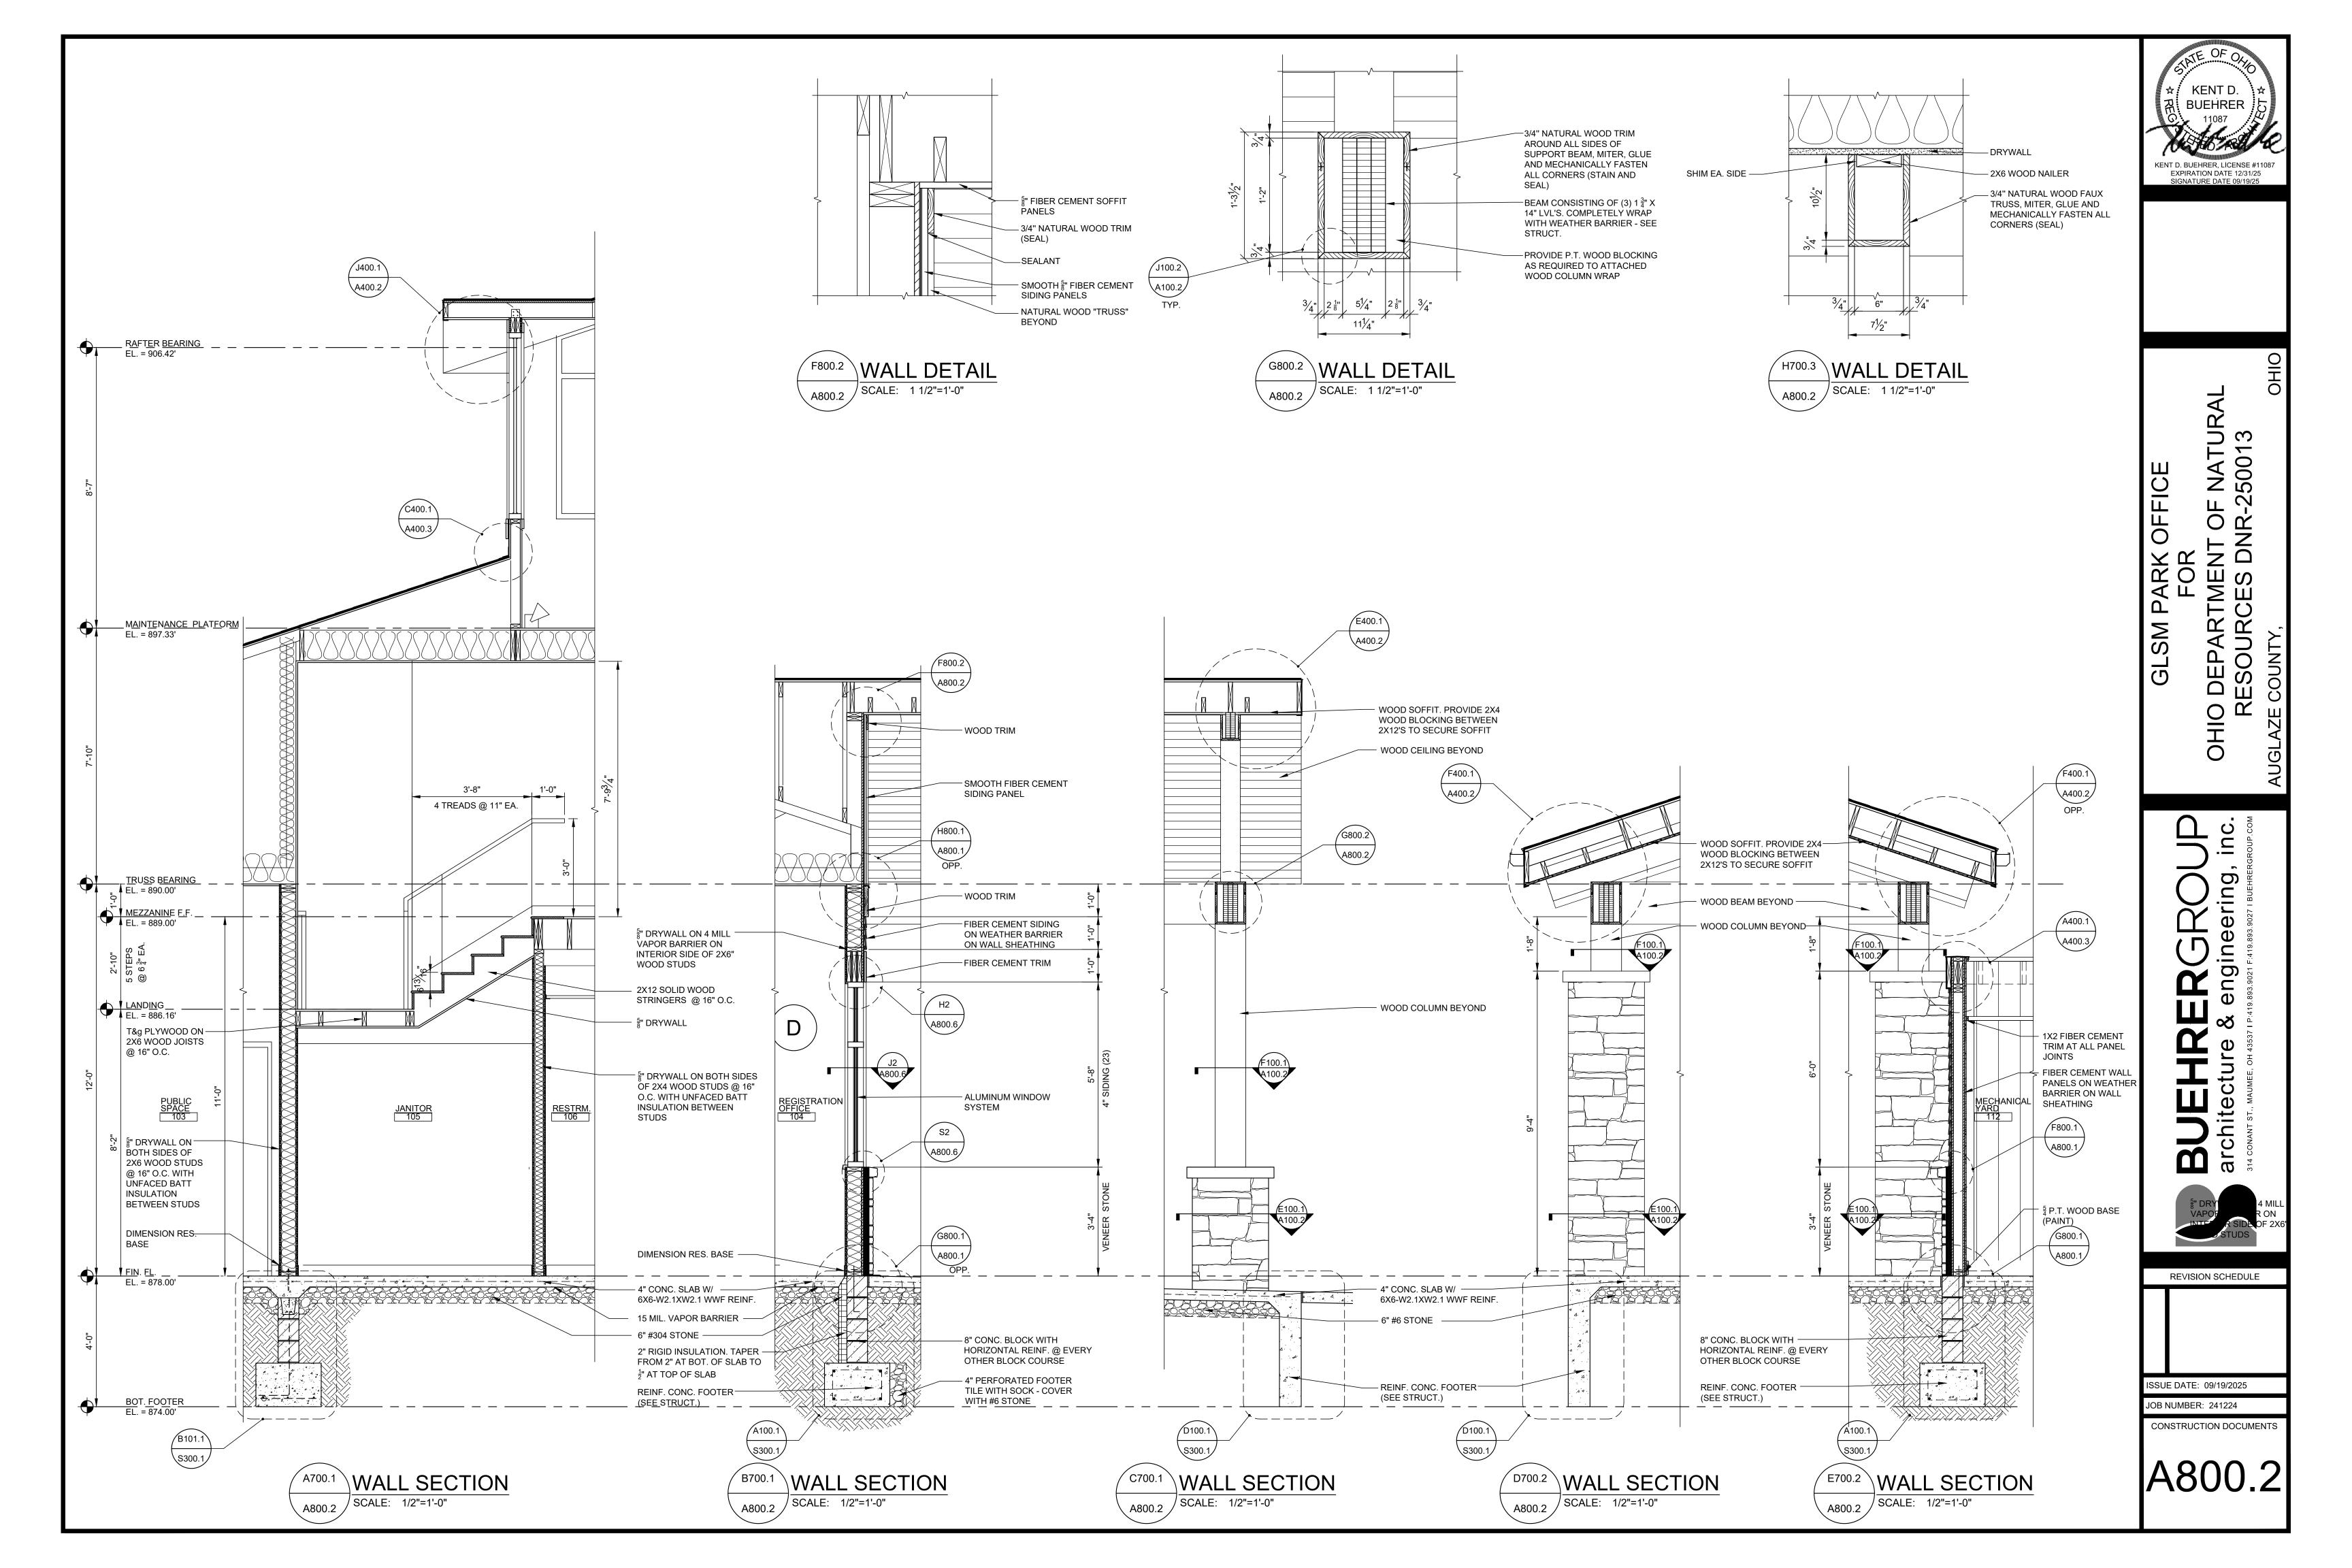

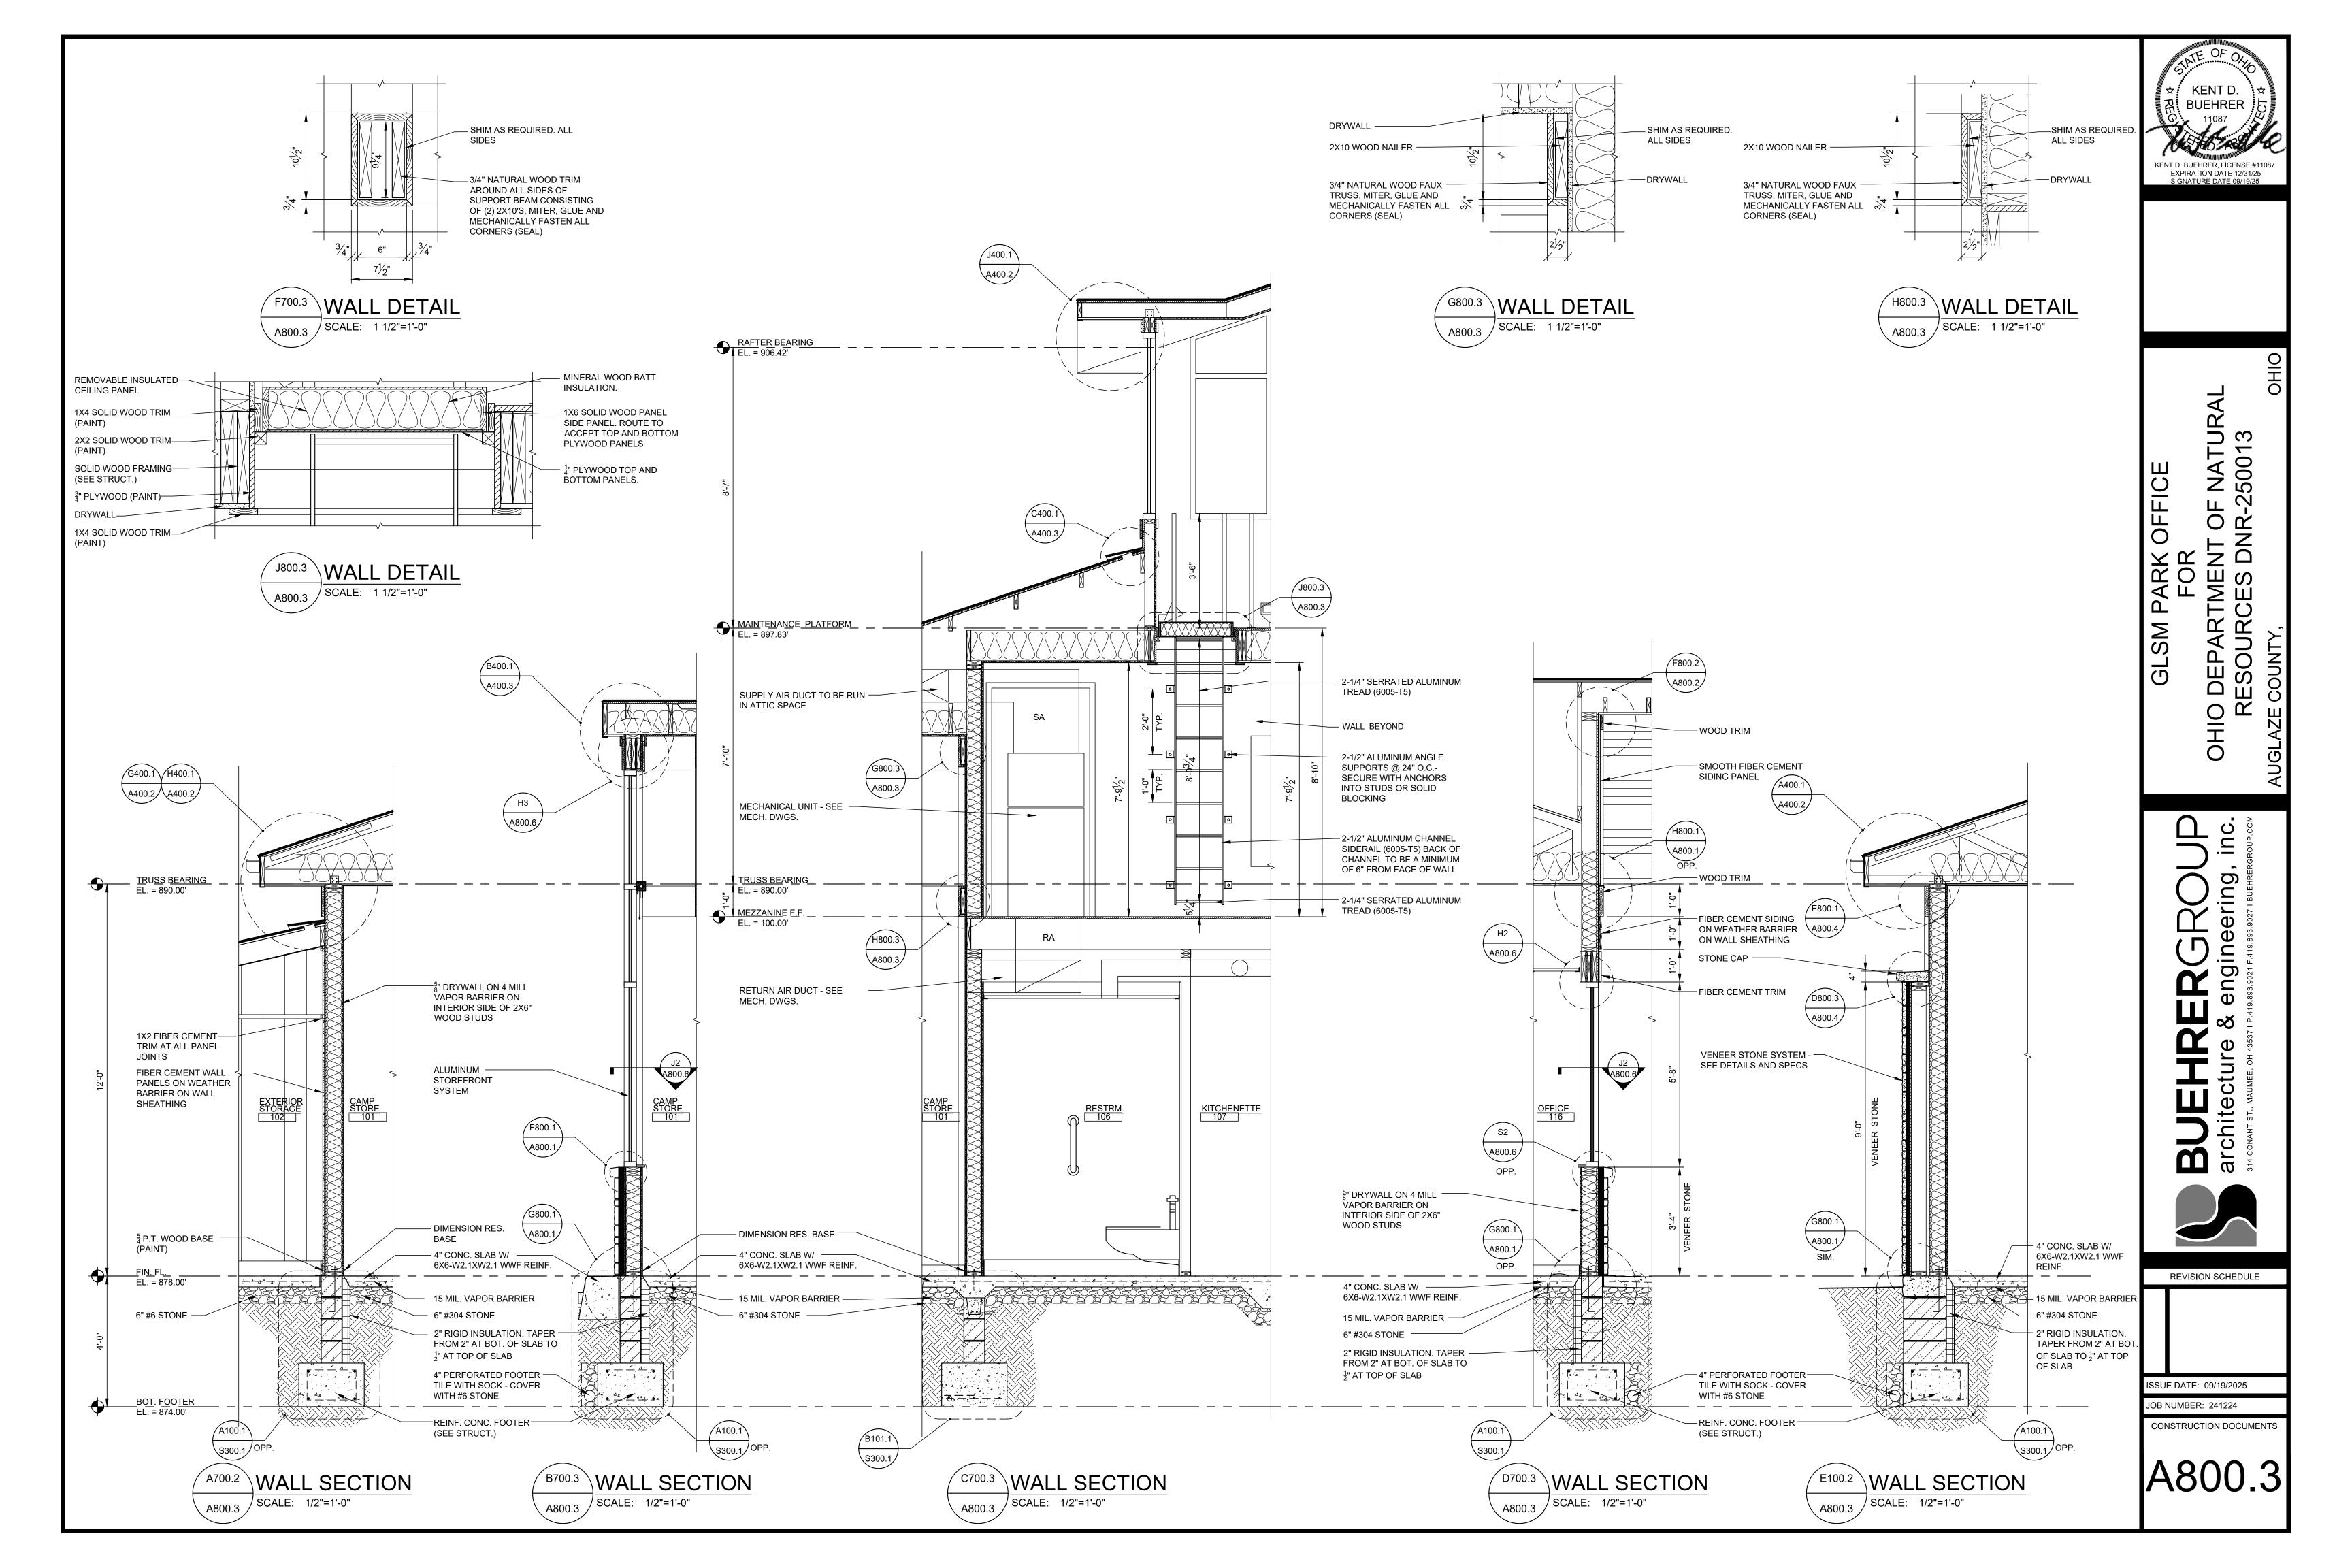

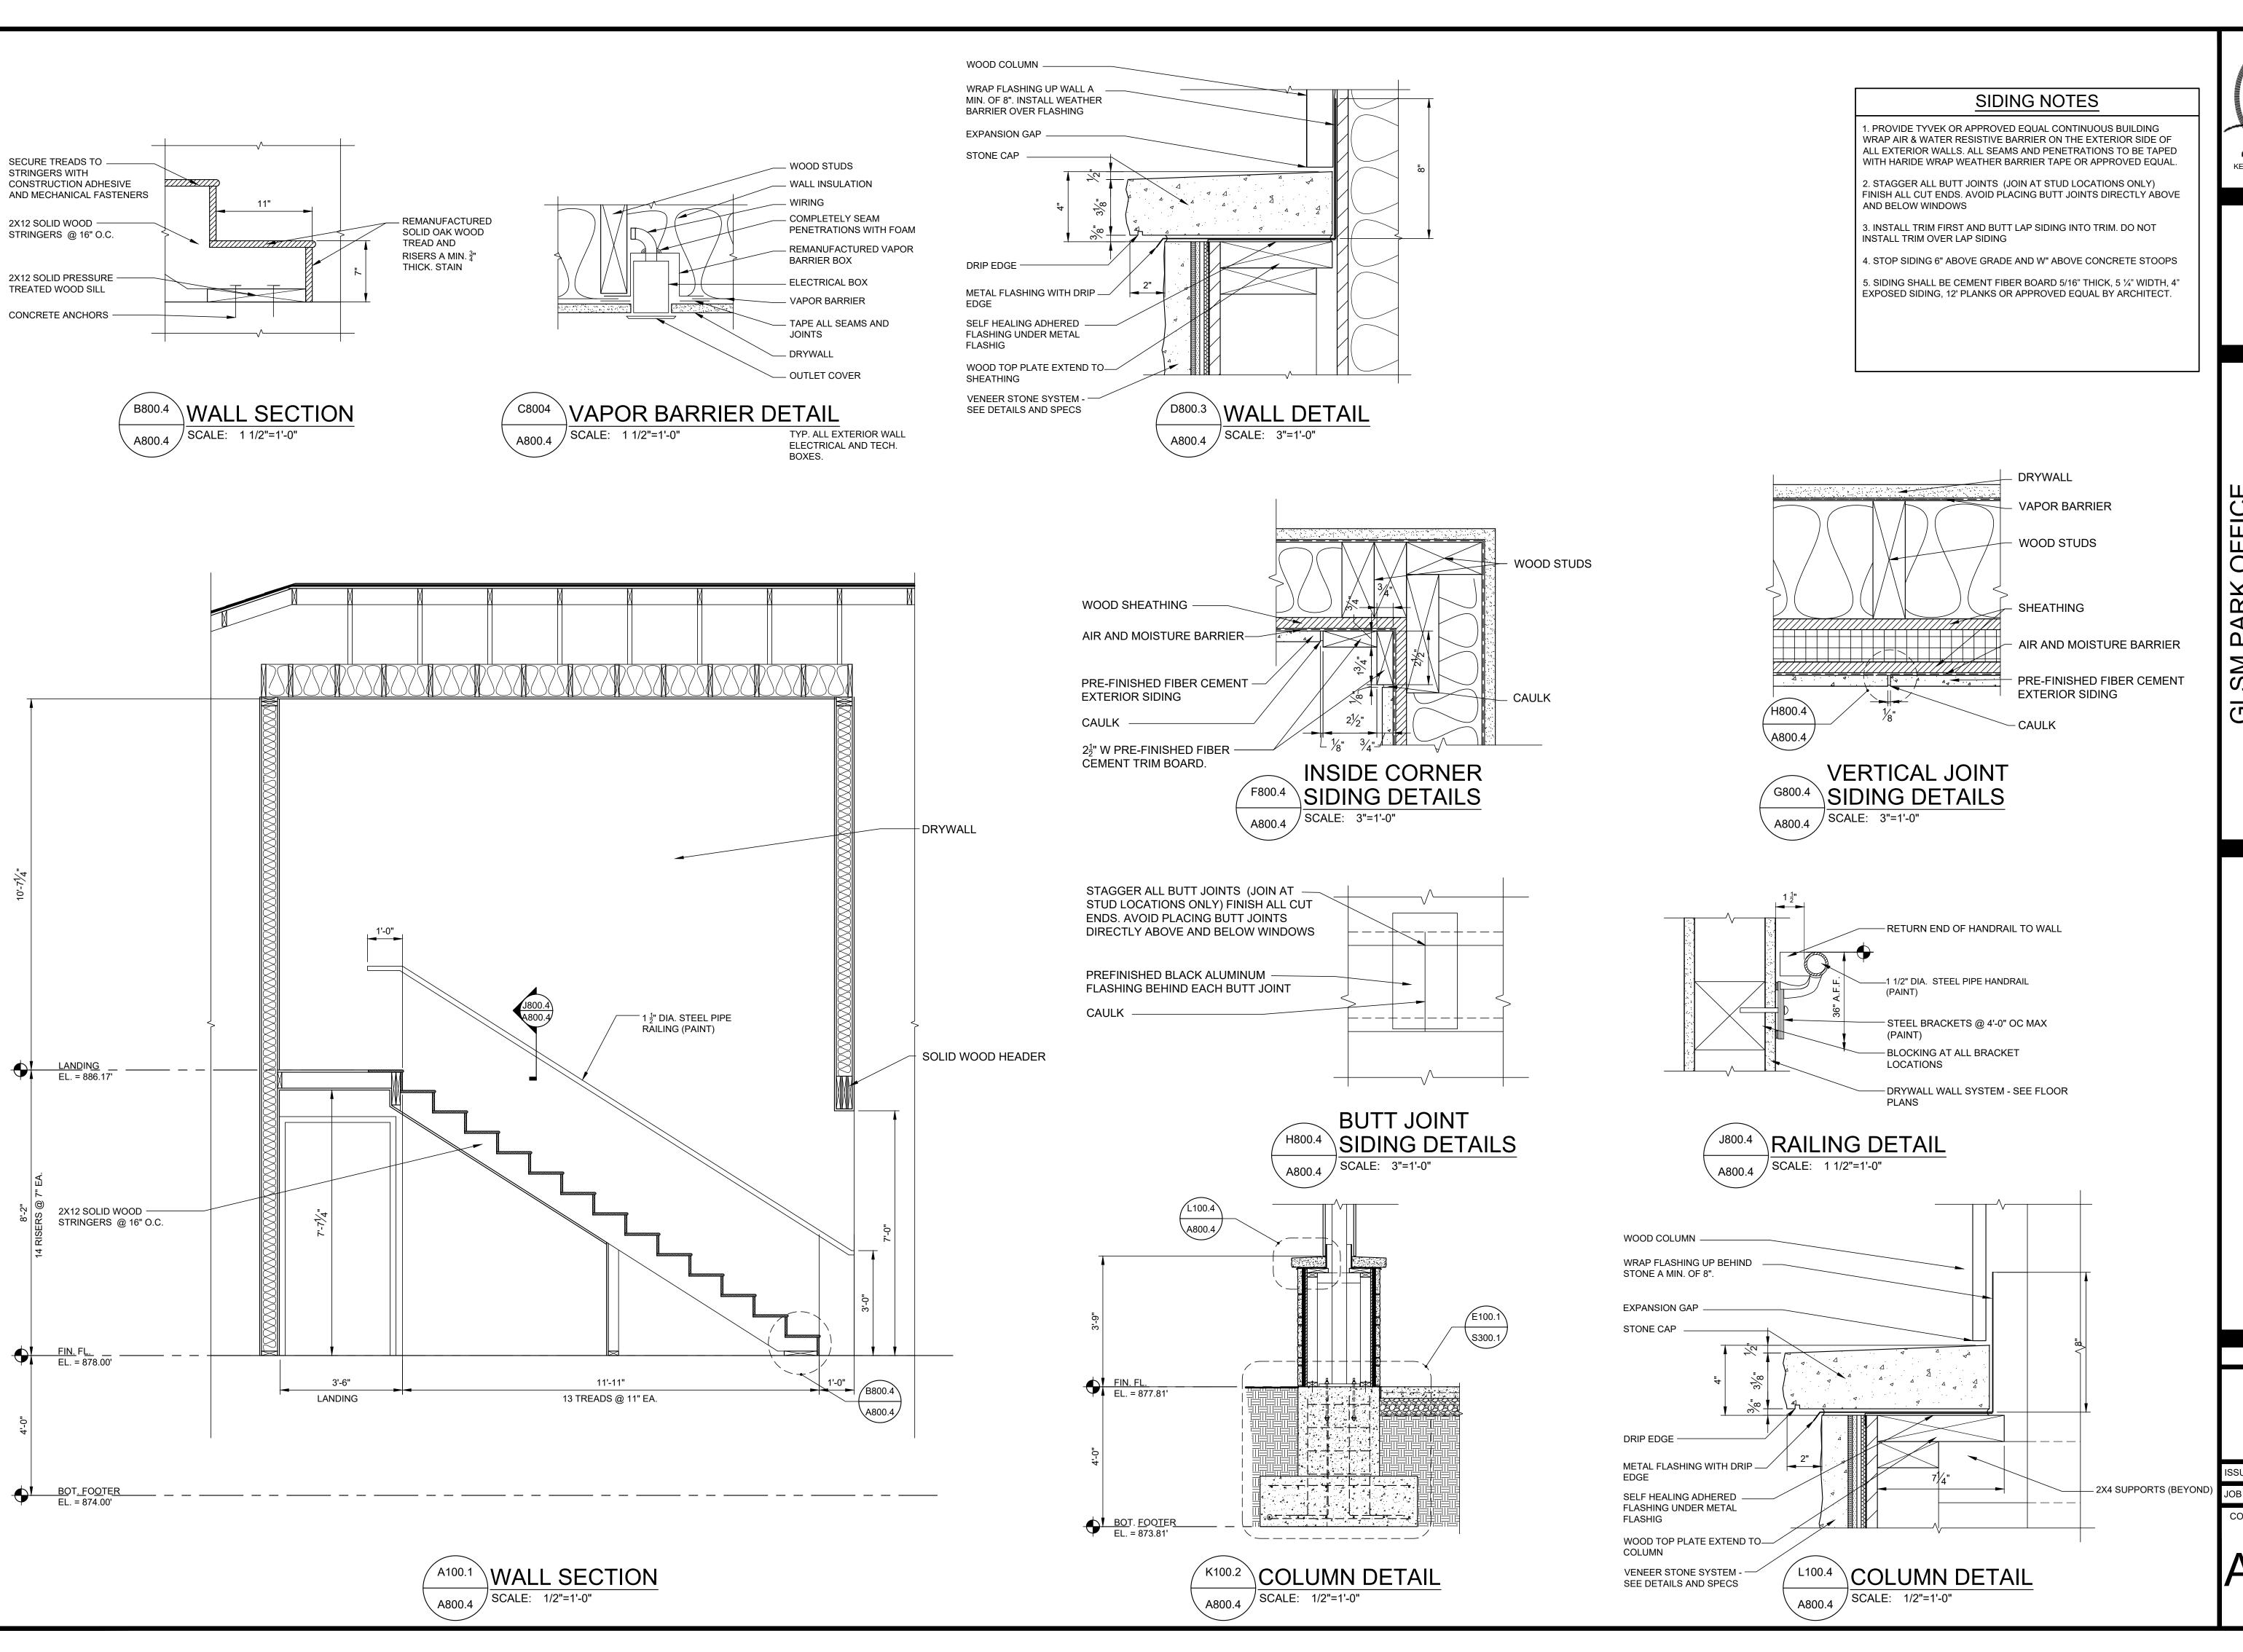

KENT D. BUEHRER 11087

KENT D. BUEHRER, LICENSE #11087 EXPIRATION DATE 12/31/25 SIGNATURE DATE 09/19/25


OFFICE OĖ PARK O FOR TMENT (CES DNF SM GL

ring




REVISION SCHEDULE ISSUE DATE: 09/19/2025


JOB NUMBER: 241224

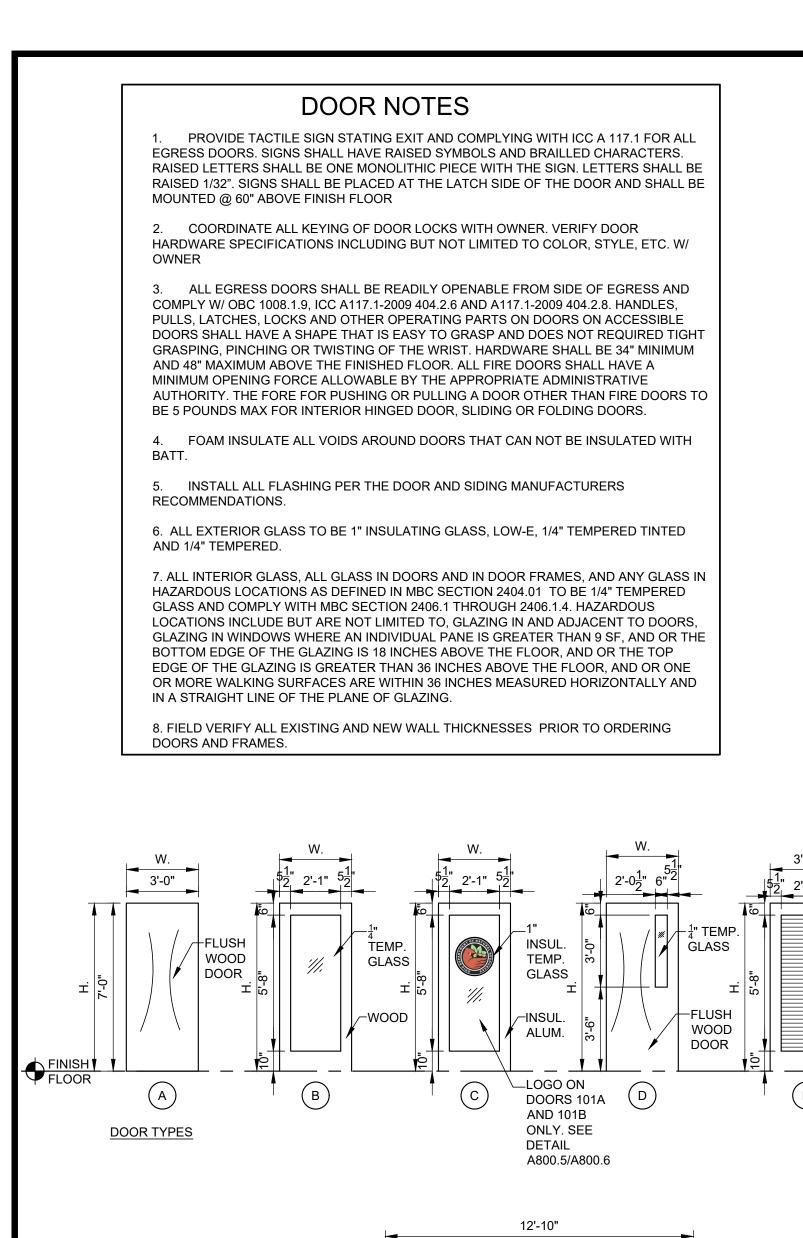

WINDOW TYPES

OPENING No.	DOOR							FRAME				DETAILS			OPENING		HARDWARE			WALL
	SIZE			TVDE	LOUVER		MATERIAL/	SIZE		TVDE	MATERIAL/	HEAD	IAMB	CII I	U.L.	ПУИГ	SET	KEYSIDE	FUNCTION	THICK NESS
	W	Н	Т	TYPE	W	Н	FINISH	W	Н	TYPE	FINISH	HEAD	JAMB	SILL	LABEL	HAND	No.	RM. No.	FUNCTION	
101A	3'-0"	7'-0"	1 3/4"	С	-	-	INSUL. ALUM.	9'-8"	9-0"	С	INSUL. ALUM.	H2	J2	S1	-	RHR	1	OUTSIDE	KEYPAD	7"
101B	3'-0"	7'-0"	1 3/4"	С	-	-	INSUL. ALUM.	9'-8"	9'-0"	С	INSUL. ALUM.	H2	J2	S1	-	LHR	1	OUTSIDE	KEYPAD	7"
101C	3'-0"	7'-0"	1 3/4"	J	-	-	INSUL. H.M.	3'-4"	7'-2"	Н	INSUL. H.M.	H2 SIM.	J2 SIM.	S1	-	LHR	2	RM. 101	CLASSROOM	7"
101D	3'-0"	3'-6"	-	-	-	-	WOOD	-	-	-	-	-	-	-	-	-	3	-		-
102A	(2) 4'-0"	7'-0"	1 3/4"	F	37"	68"	H.M.	8'-4"	7'-4"	G	H.M.	H2 SIM.	J2 SIM.	-	-	RHR/LHR	4	OUTSIDE	STOREROOM	5"
102B	3'-0"	7'-0"	1 3/4"	Е	37"	68"	H.M.	3'-4"	7'-4"	F	H.M.	H2 SIM.	J2 SIM.	-	-	RHR	2	OUTSIDE	CLASSROOM	5"
103A	3'-0"	7'-0"	1 3/4"	Α	-	-	WOOD	3'-4"	7'-2"	Α	H.M.	H1	J1	-	-	RHR	5	RM. 101	CLASSROOM	5"
103B	3'-0"	7'-0"	1 3/4"	D	-	-	WOOD	3'-4"	7'-2"	Α	H.M.	H1	J1	-	-	LHR	6	CORR. 114	CLASSROOM	5"
104A	3'-0"	7'-0"	1 3/4"	С	-	-	INSUL. ALUM.	12'-10"	9'-0"	D	INSUL. ALUM.	H2	J2	S1	-	LHR	1	OUTSIDE	KEYPAD	7"
104B	3'-0"	7'-0"	1 3/4"	В	-	-	WOOD	12'-10"	9-0"	В	H.M.	H1	J1	-	-	LHR	5	RM. 101	CLASSROOM	5"
104C	3'-0"	3'-6"	-	-	-	-	WOOD	-	-	-	-	-	-	-	-	-	3	-		-
105A	3'-0"	7'-0"	1 3/4"	Α	-	-	WOOD	3'-4"	7'-2"	Α	H.M.	H1	J1	-	-	RHR	5	RM. 103	CLASSROOM	7"
106A	3'-0"	7'-0"	1 3/4"	Α	-	-	WOOD	3'-4"	7'-2"	Α	H.M.	H1	J1	-	-	RH	7	RM. 101	PRIVACY	7"
108A	3'-0"	7'-0"	1 3/4"	Α	-	-	WOOD	3'-4"	7'-2"	Α	H.M.	H1	J1	-	-	LH	7	RM. 104	PRIVACY	7"
109A	3'-0"	7'-0"	1 3/4"	Α	-	-	WOOD	3'-4"	7'-2"	Α	H.M.	H1	J1	-	-	RH	7	CORR. 114	PRIVACY	7"
110A	3'-0"	7'-0"	1 3/4"	Α	-	-	WOOD	3'-4"	7'-2"	А	H.M.	H1	J1	-	-	RH	5	CORR. 114	CLASSROOM	5"
111A	3'-0"	7'-0"	1 3/4"	Α	-	-	WOOD	3'-4"	7'-2"	А	H.M.	H1	J1	-	-	LH	5	CORR. 114	CLASSROOM	5"
112A	(2) 4'-0"	7'-0"	1 3/4"	F	37"	68"	H.M.	8'-4"	7'-4"	G	H.M.	H2 SIM.	J2 SIM.	-	-	RHR/LHR	4	OUTSIDE	STOREROOM	5"
113A	3'-0"	7'-0"	1 3/4"	Α	-	-	WOOD	3'-4"	7'-2"	Α	H.M.	H1	J1	-	-	LH	5	CORR. 114	CLASSROOM	5"
116A	3'-0"	7'-0"	1 3/4"	Н	-	-	INSUL. ALUM.	19'-8"	9'-0"	Е	INSUL. ALUM.	H2	J2	S1	-	RHR	1	OUTSIDE	KEYPAD	7"
116B	3'-0"	7'-0"	1 3/4"	Α	-	-	WOOD	3'-4"	7'-2"	Α	H.M.	H1	J1	-	-	RH	8	CORR. 114	KEYPAD	7"
	_				-															

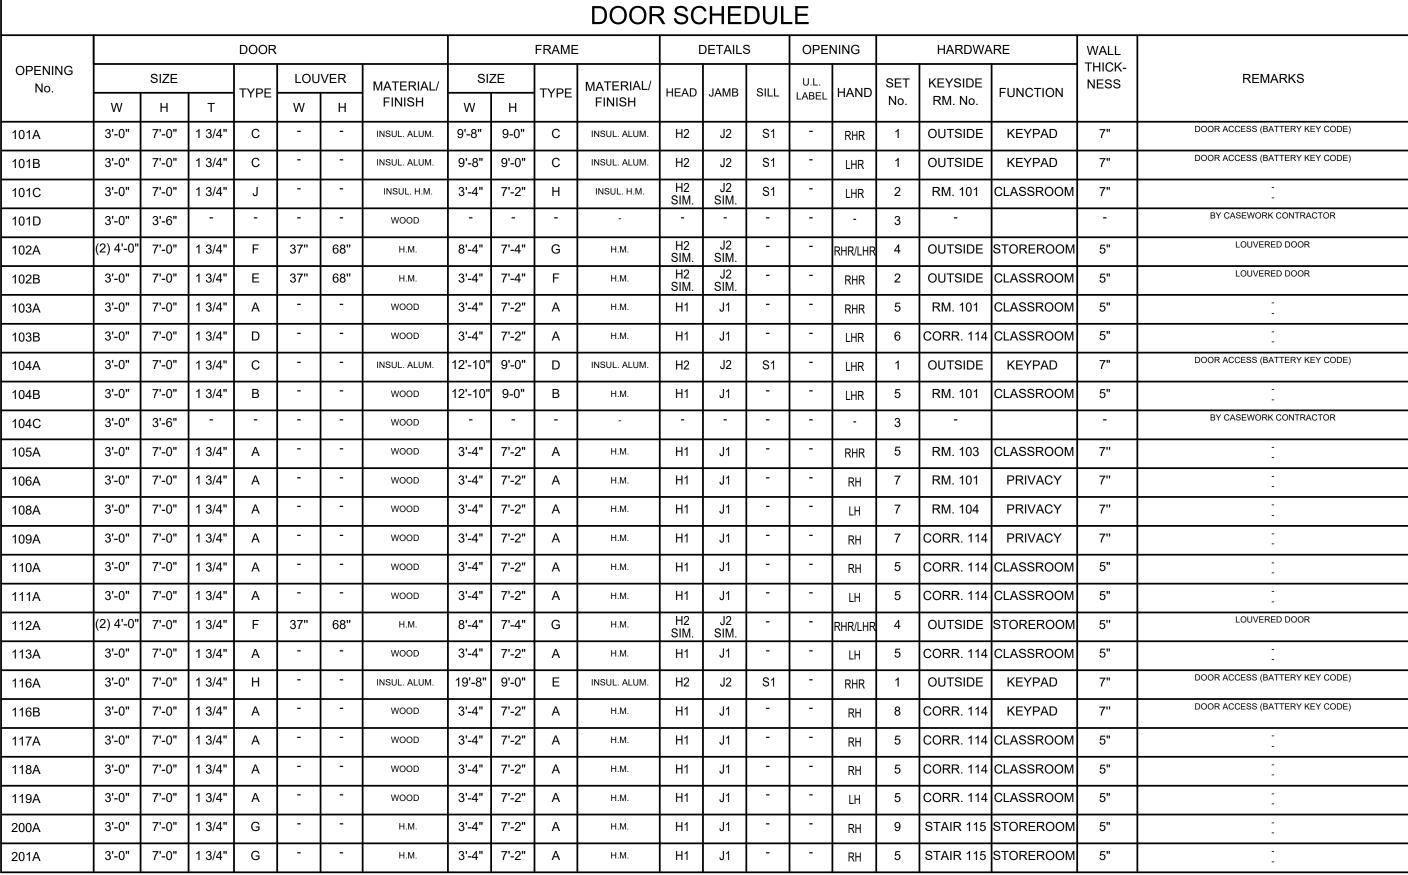

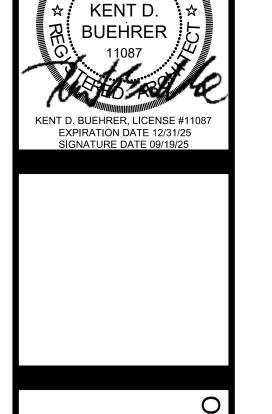

M 8 OF OE PARK FOR SMGL

> ering engin




WINDOW NOTES

REVISION SCHEDULE


ISSUE DATE: 09/19/2025

JOB NUMBER: 241224

CONSTRUCTION DOCUMENTS

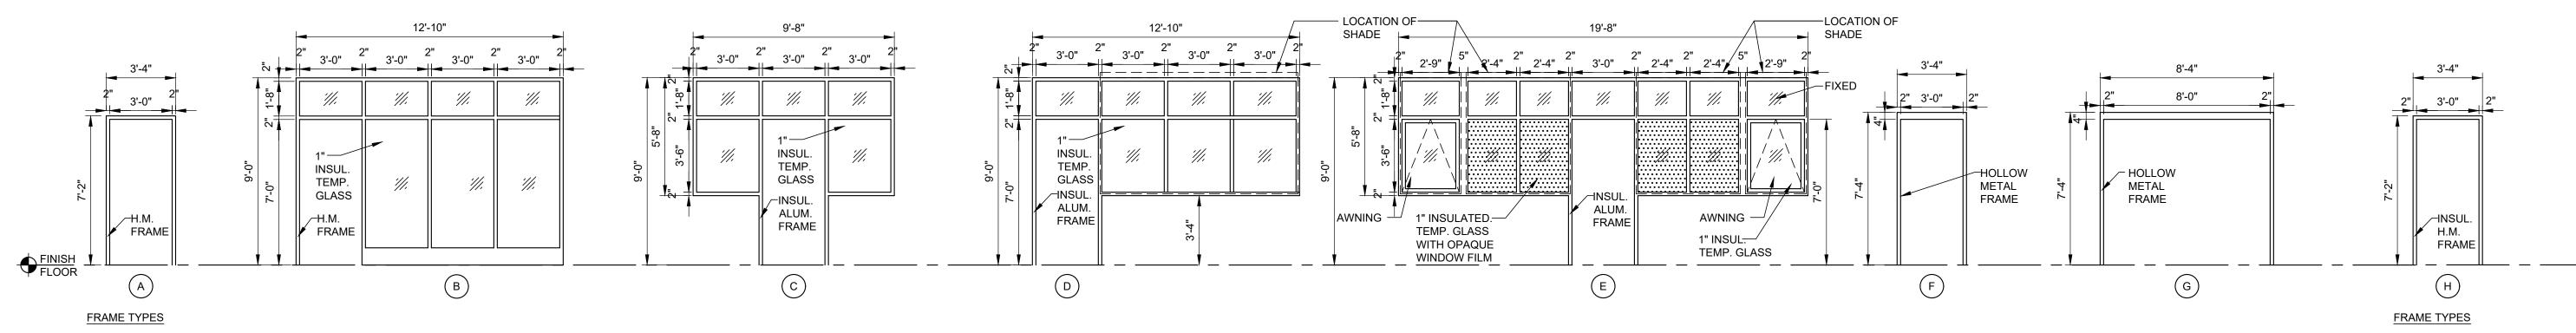

INSUL. HM. DOOR

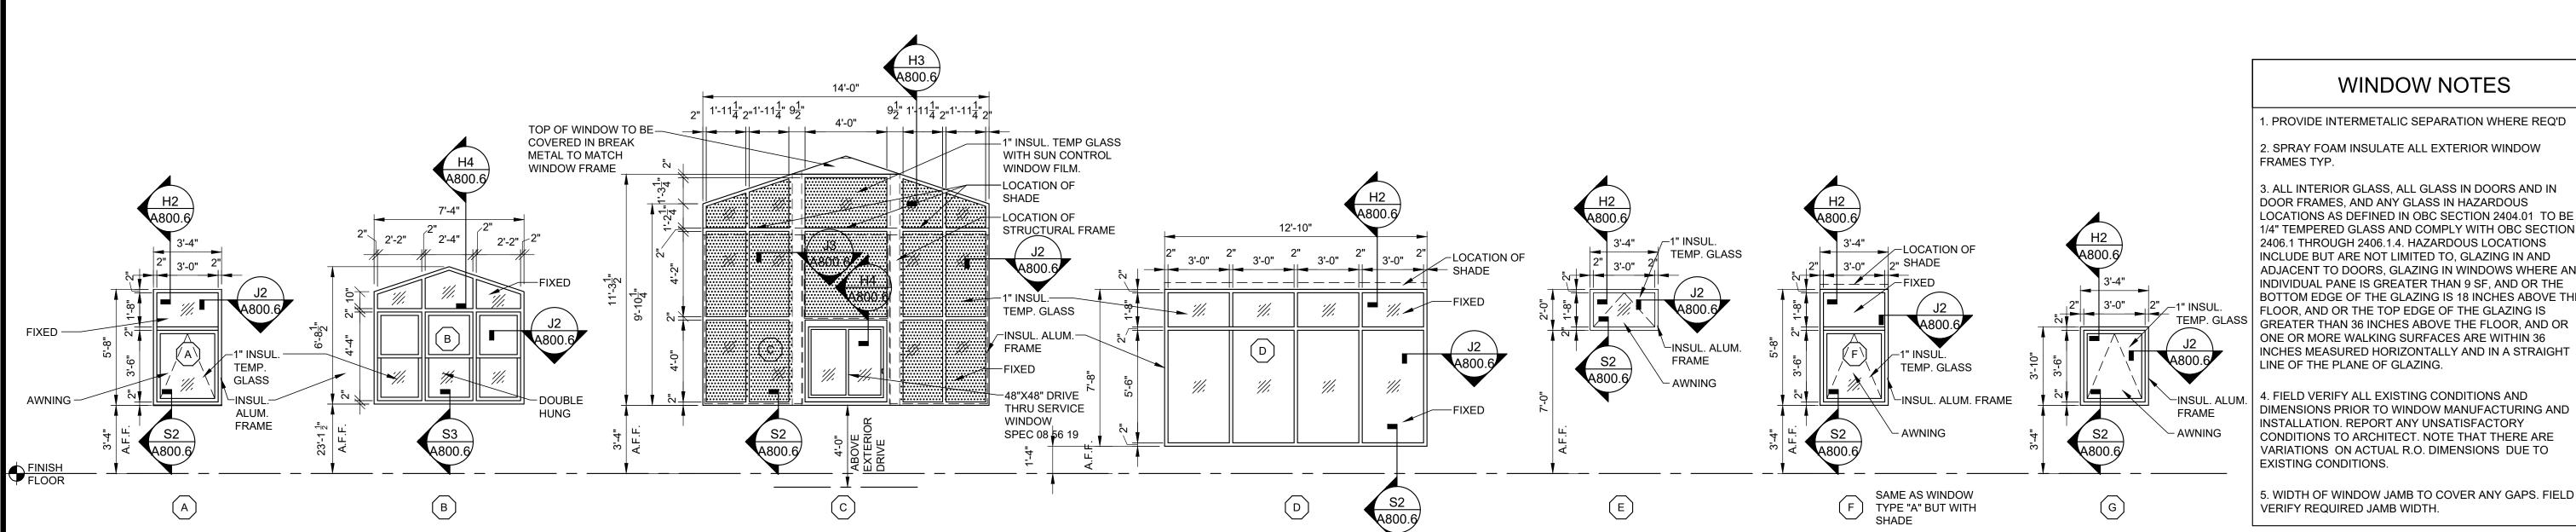

42'" MIN.

TEMP.

GLASS

∕-INSUL.

ALUM.

FRAME

— OPAQUE

12" MIN. CLEARANCE REQUIRED

54" MIN,. CLEARANCE REQUIRED

ONLY IF BOTH CLOSER AND LATCH ARE

*** 48" MIN. IF BOTH CLOSER AND

**** 48" MIN. IF CLOSER IS PROVIDED.

WHEN CLOSER IS PROVIDED.

LATCH ARE PROVIDED.

PROVIDED.

24" MIN.

TYPICAL DOOR APPROACH DETAILS

-LOUVERS


-INSUL.


H.M.

SCALE: 1/8"=1'-0"

_LOUVERS

∕-INSUL.

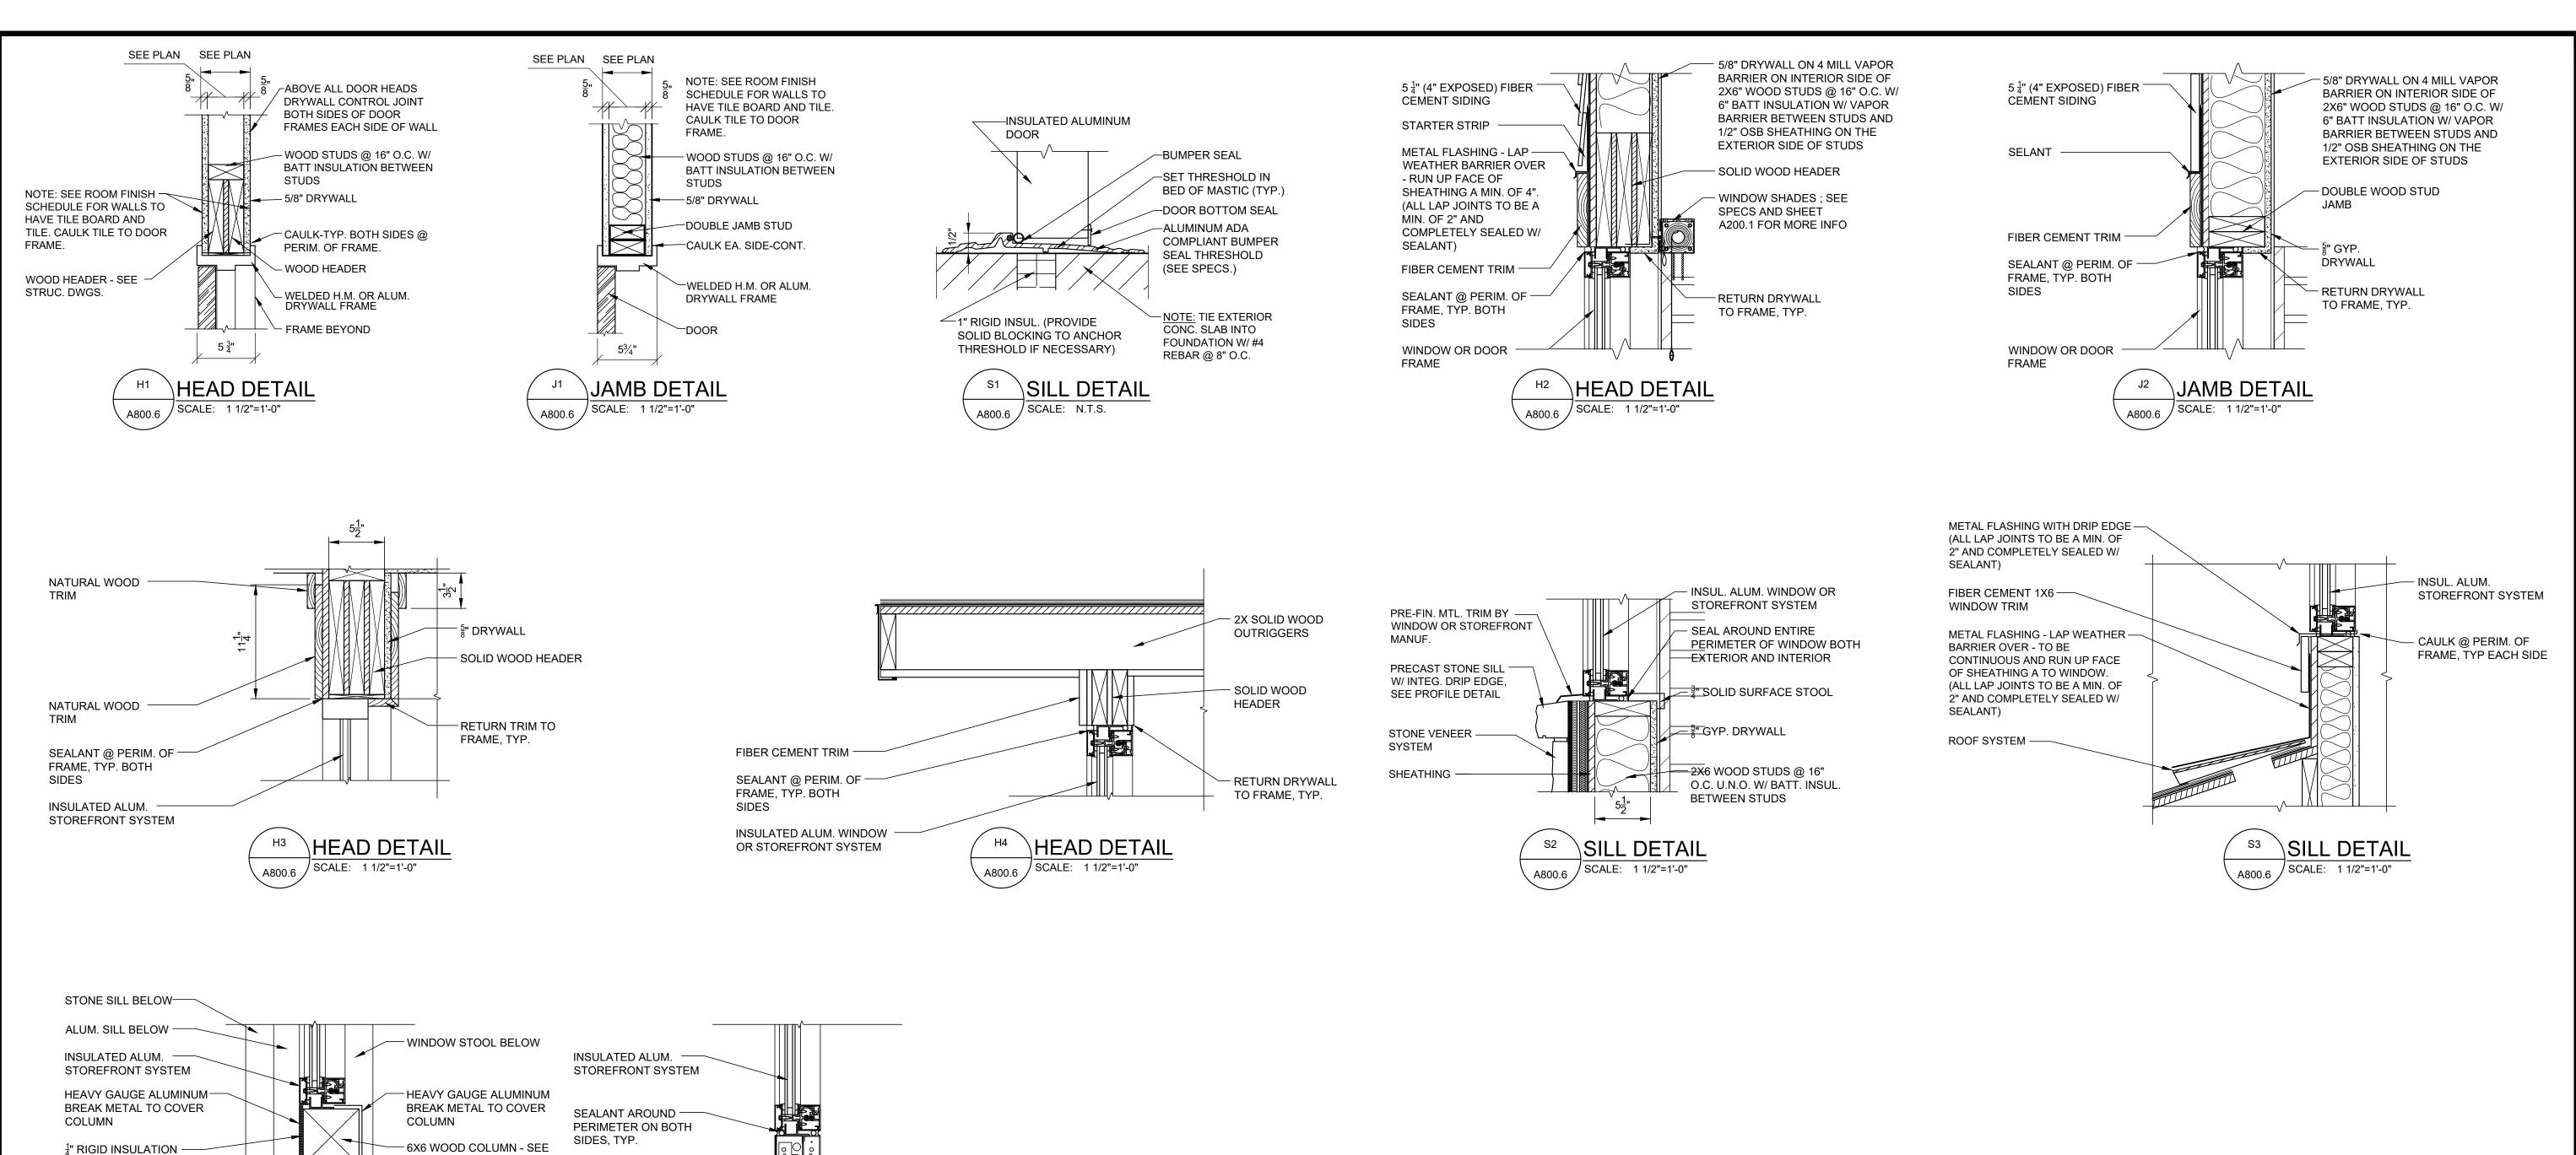

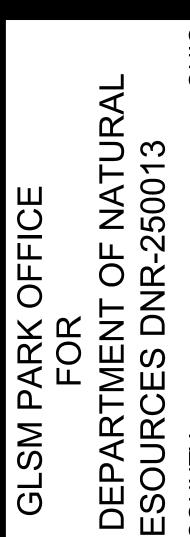

KENT D.

BUEHRER

11087

KENT D. BUEHRER, LICENSE #11087

EXPIRATION DATE 12/31/25 SIGNATURE DATE 09/19/25

BUEHRERGROUP GACHITECTURE & engineering, inc.
314 CONANT ST., MAUMEE, OH 43537 I P:419.893.9027 I BUEHRERGROUP.COM

are


REVISION SCHEDULE

ISSUE DATE: 09/19/2025

JOB NUMBER: 241224

CONSTRUCTION DOCUMENTS

A800.6

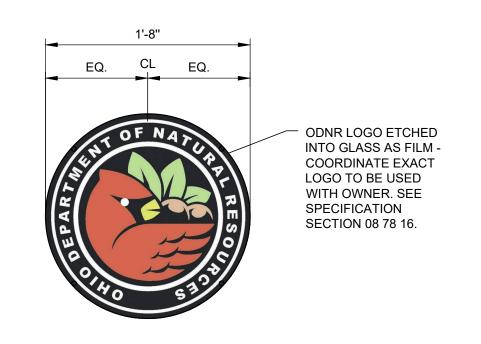

HEAD DETAIL

SCALE: 1 1/2"=1'-0"

A800.6 /

STRUCT. - WRAP WITH

FLEXIBLE FLASHING

WEATHER BARRIER AND

ALUMINUM SLIDING -

SERVICE WINDOW -

COLUMNS

SECURE JAMBS TO STEEL

HEAD DETAIL

A800.6 SCALE: 1 1/2"=1'-0"



STONE SILL BELOW-

ALUM. SILL BELOW -

INSULATED ALUM. —— STOREFRONT SYSTEM







B900.1 INTERIOR RENDERING CAMP STORE
SCALE: 1/4"=1'-0"



HO DEPARTMENT OF NATURAL
RESOURCES DNR-250013

BUEHRERGROUP

architecture & engineering, inc.
314 CONANT ST., MAUMEE, OH 43537 I P:419.893.9027 I BUEHRERGROUP.COM



REVISION SCHEDULE


ISSUE DATE: 09/19/2025

JOB NUMBER: 241224

CONSTRUCTION DOCUMENTS

A900.1

NOTE: RENDERINGS ARE FOR REFERENCE AND ARE TO CONVEY DESIGN INTENT ONLY. DO NOT SCALE OFF RENDERINGS. REFER TO DRAWINGS FOR ALL CONSTRUCTION DETAILS

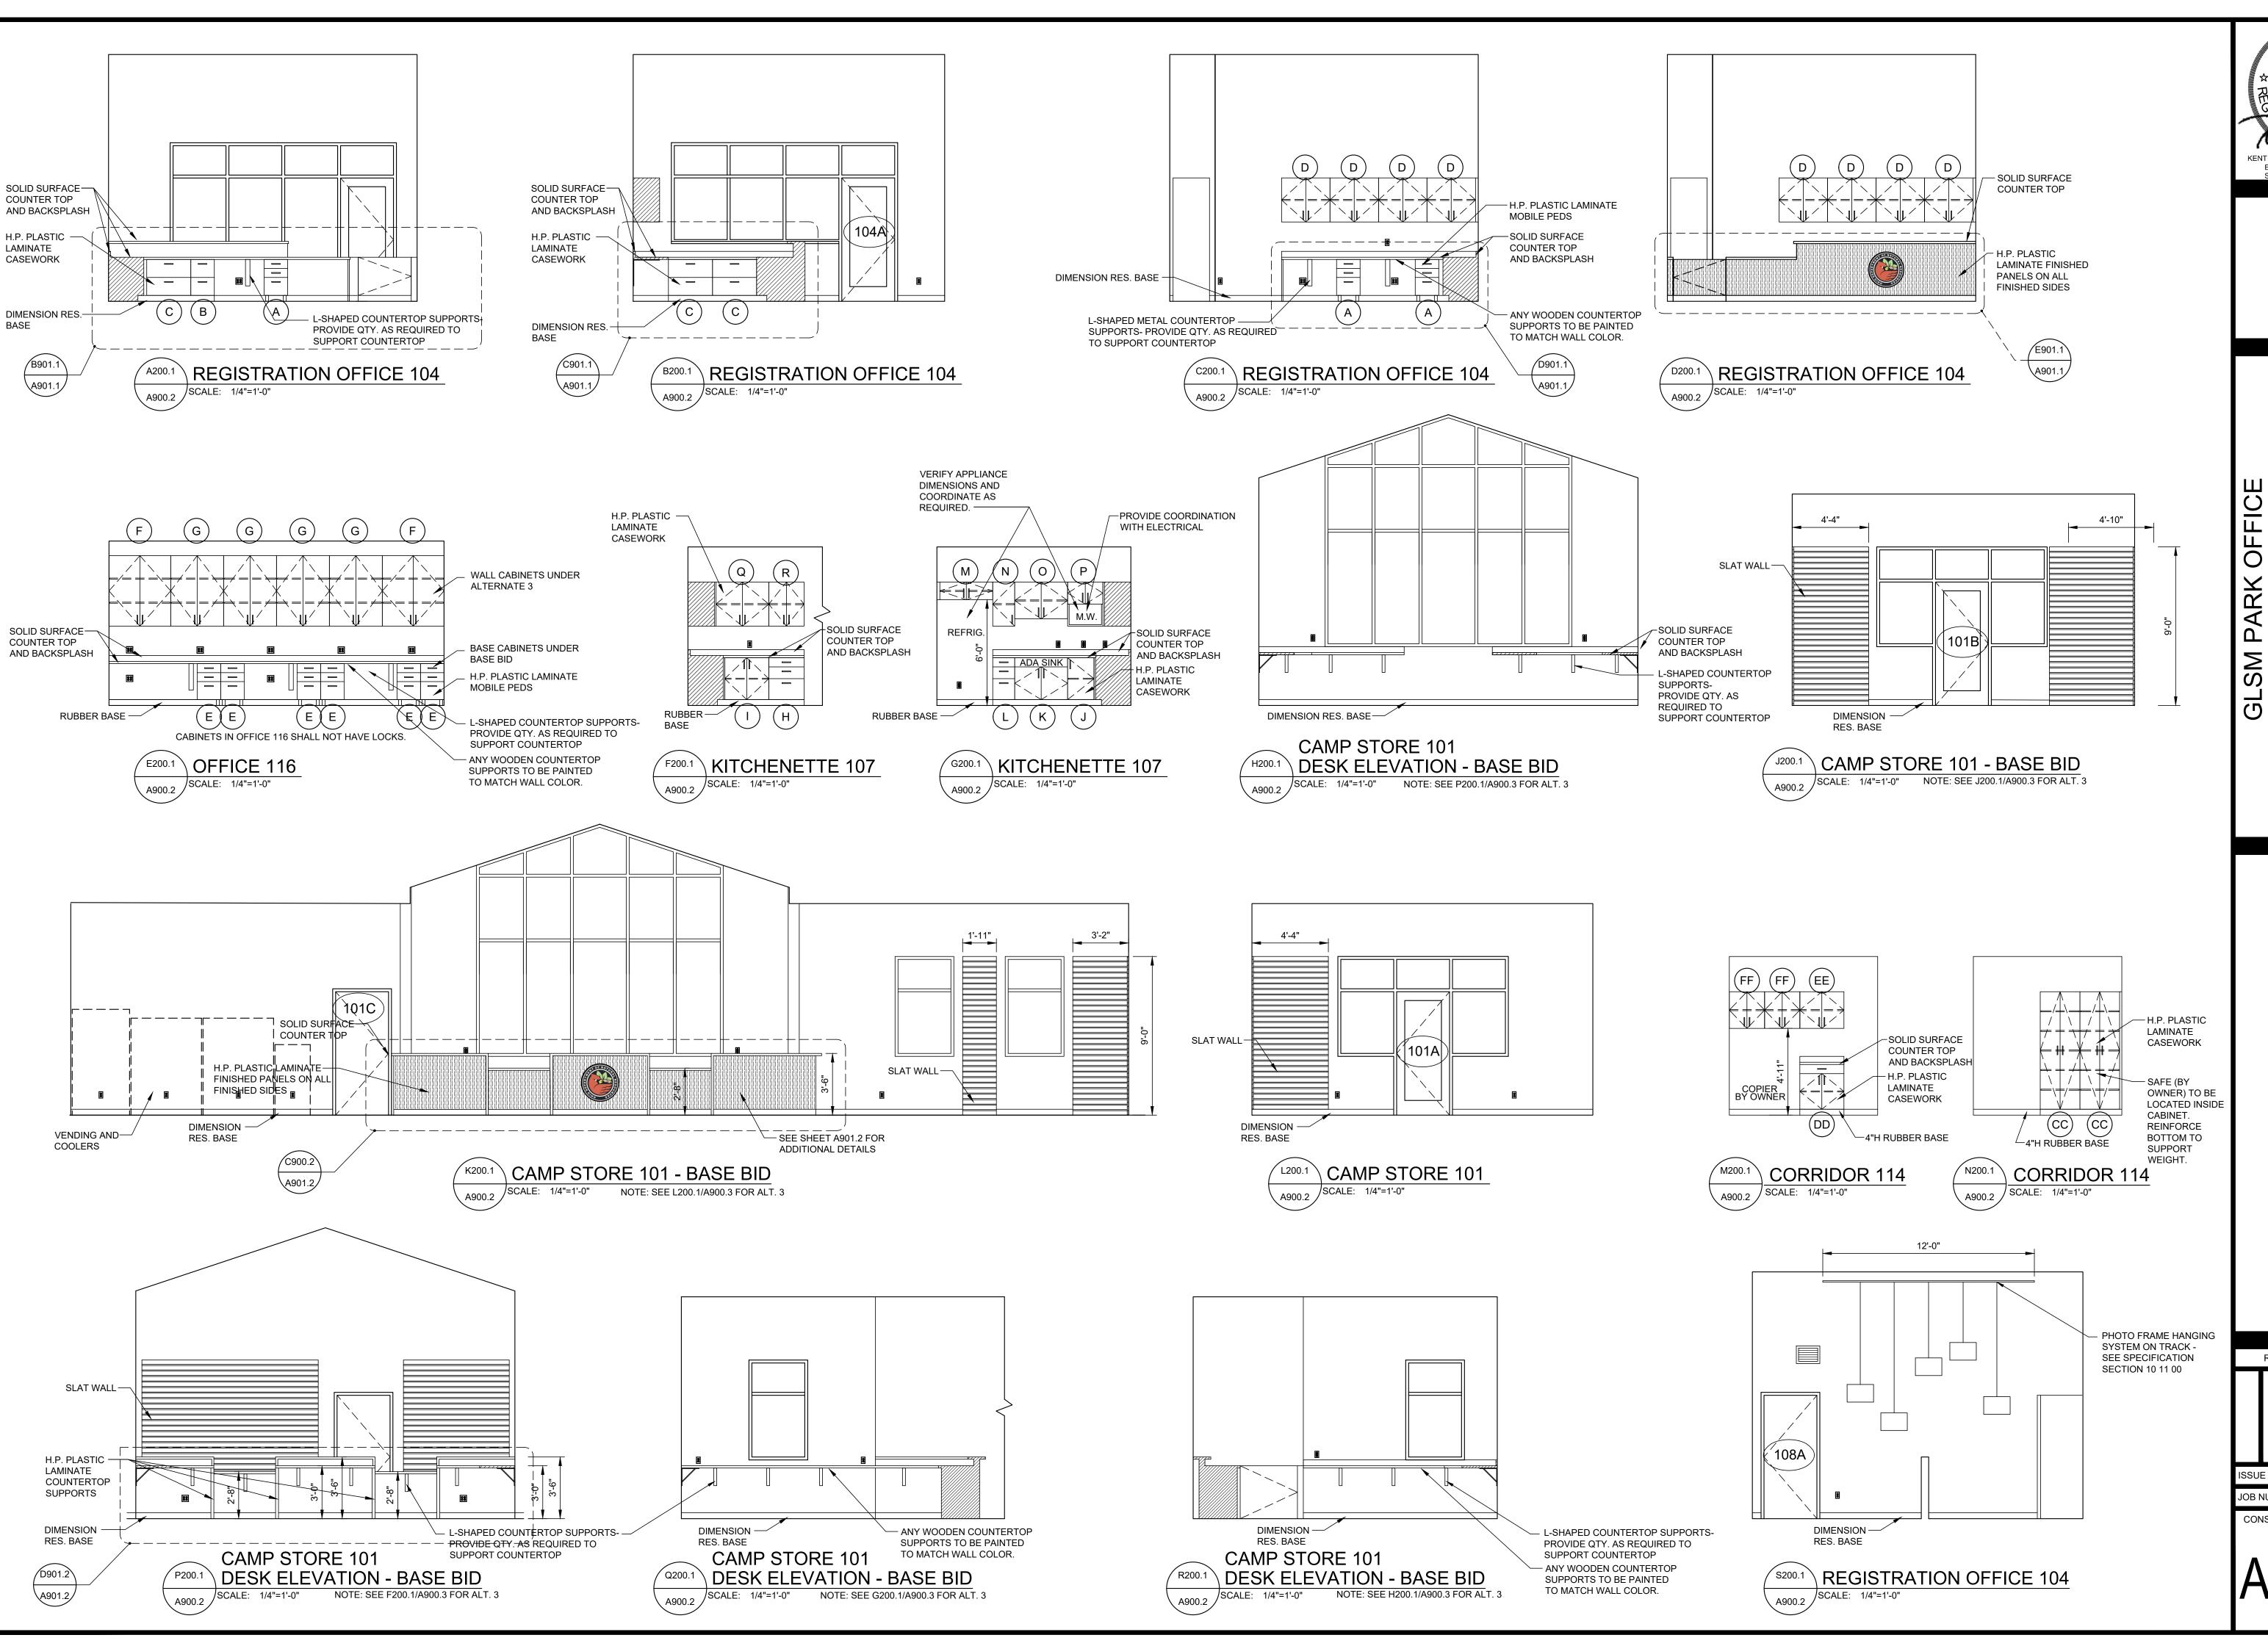

KENT D BUEHRER 11087 KENT D. BUEHRER, LICENSE #11087 EXPIRATION DATE 12/31/25 SIGNATURE DATE 09/19/25


NAT 500 OĖ PARK FOR

ering engine

REVISION SCHEDULE

ISSUE DATE: 09/19/2025

JOB NUMBER: 241224

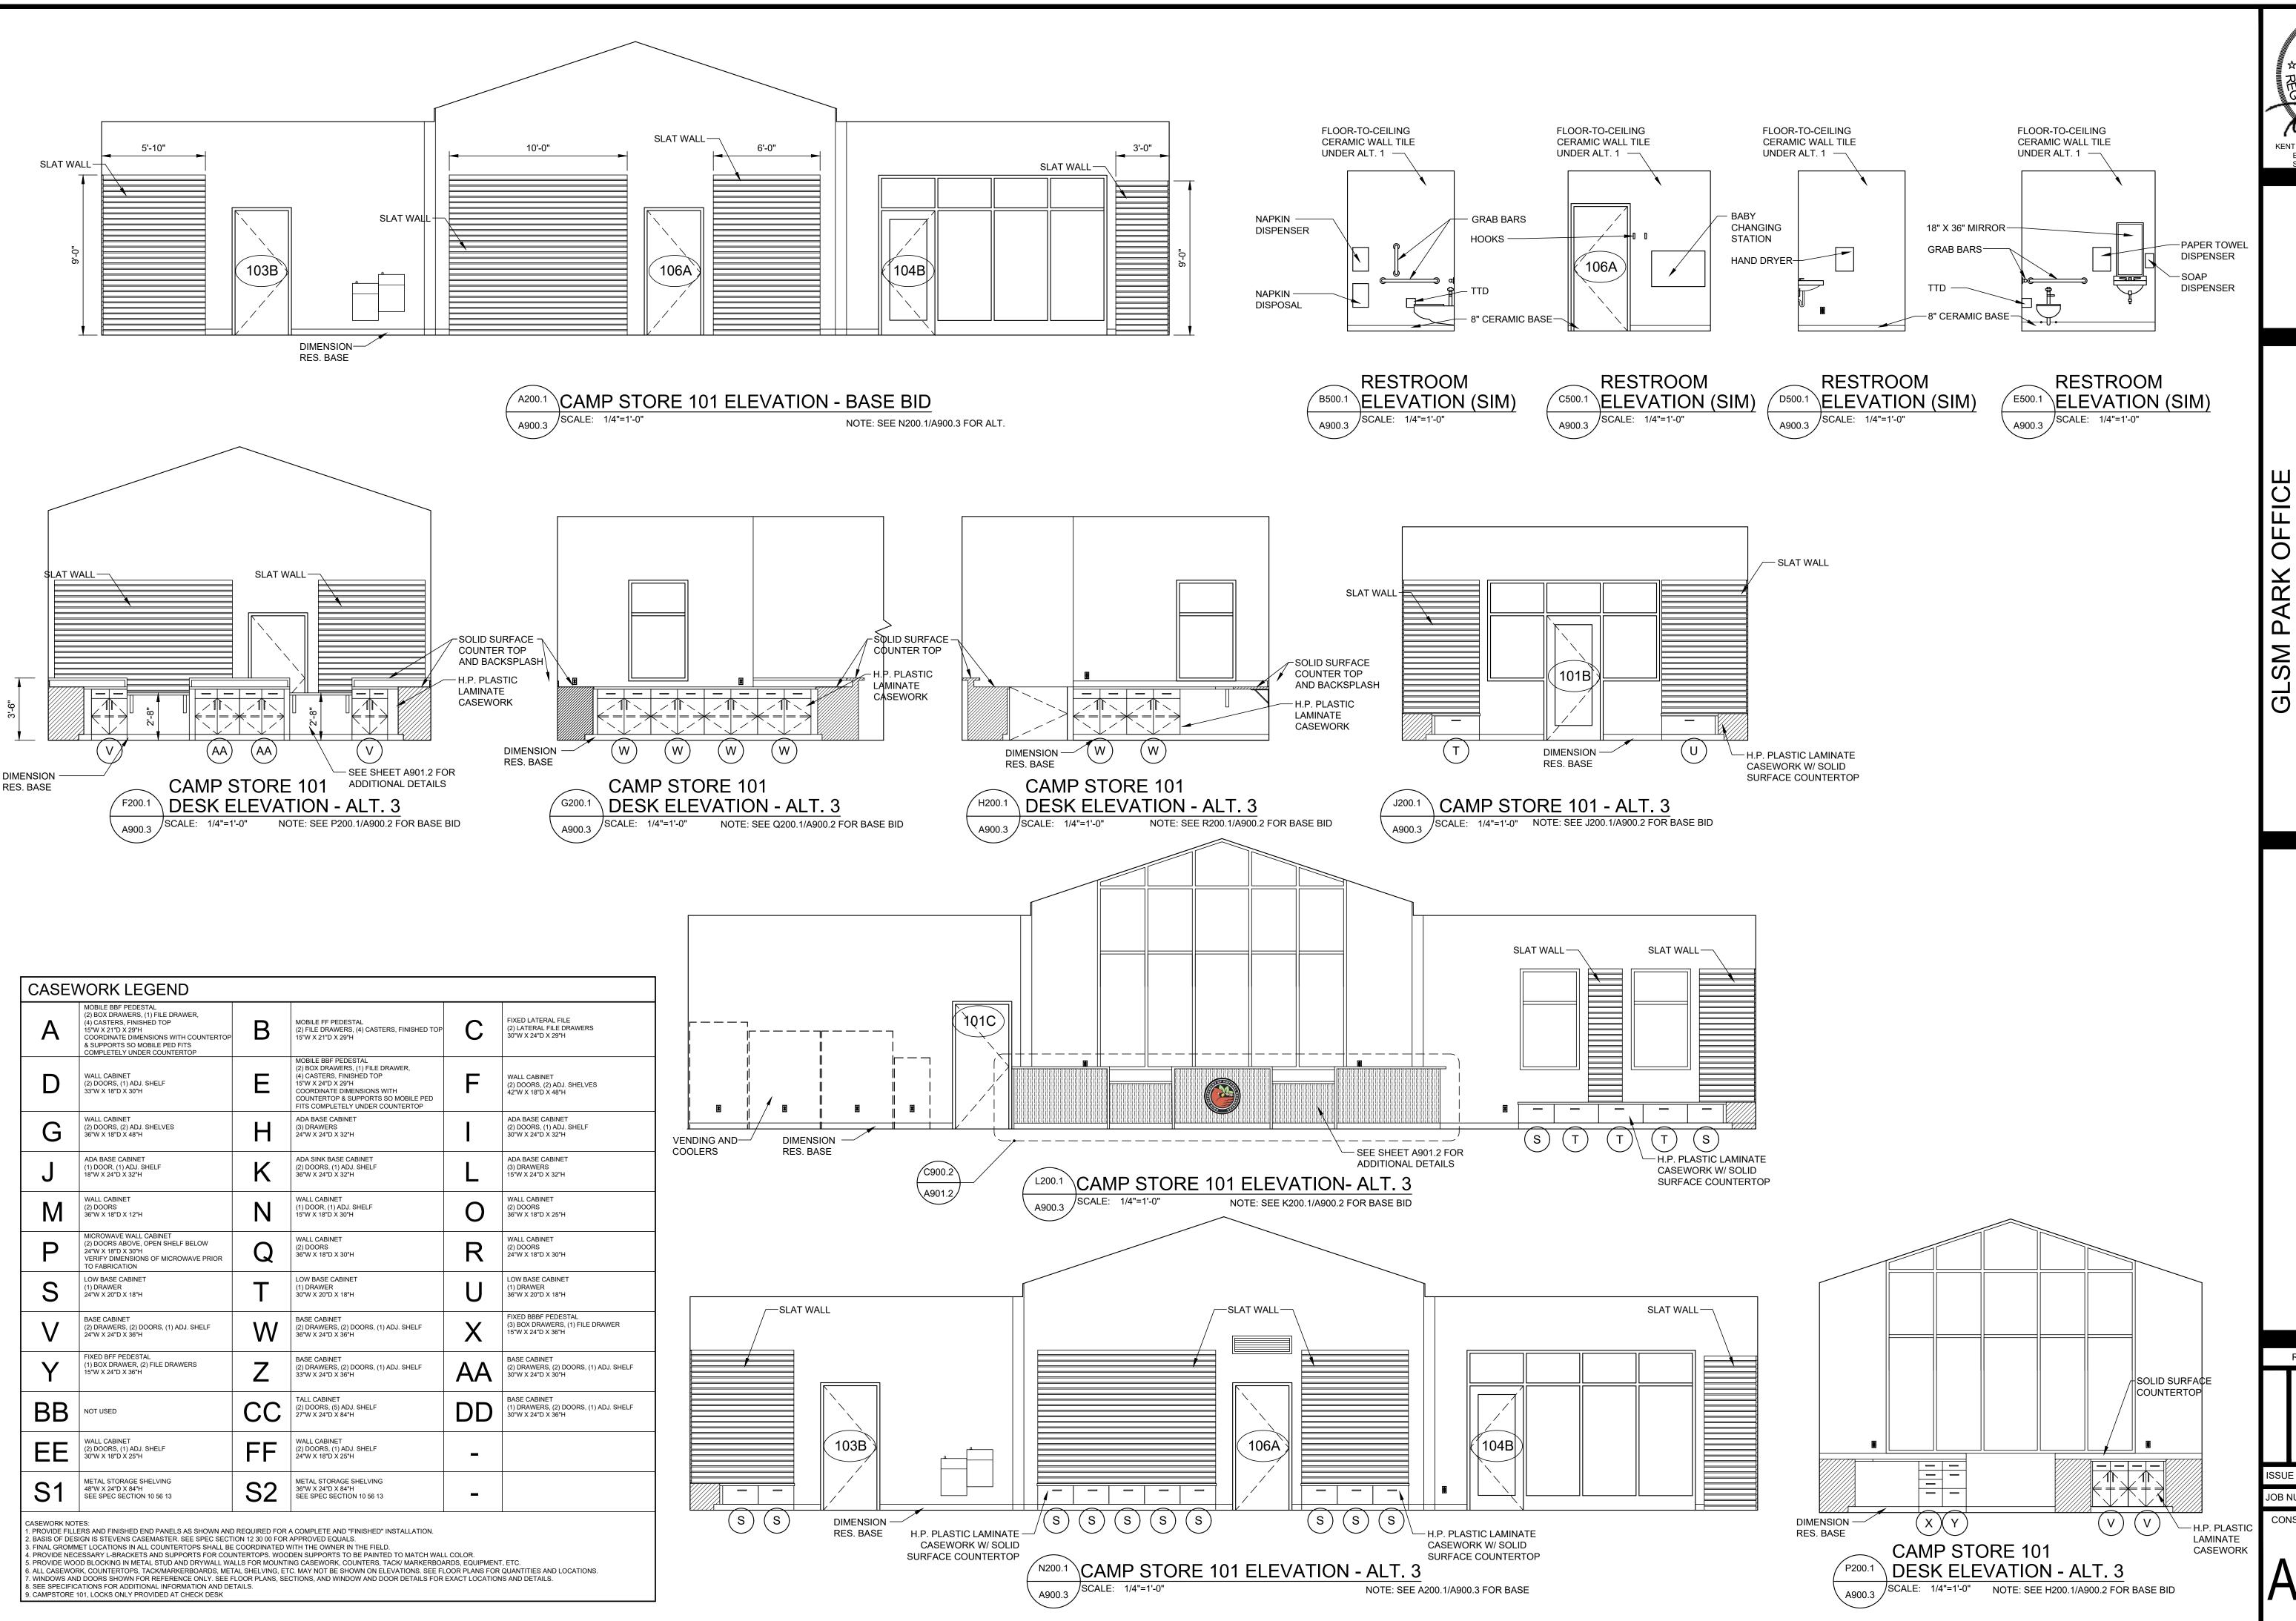



GLSM PARK OFFICE FOR OHIO DEPARTMENT OF NATURAL RESOURCES DNR-250013

BUEHRERGROUP.CM

architecture & engineering, inc.

314 CONANT ST., MAUMEE, OH 43537 I P:419,893,9027 I BUEHRERGROUP.COM

B arc


ISSUE DATE: 09/19/2025


ISSUE DATE: 09/19/2025

JOB NUMBER: 241224

CONSTRUCTION DOCUMENTS

A900.3

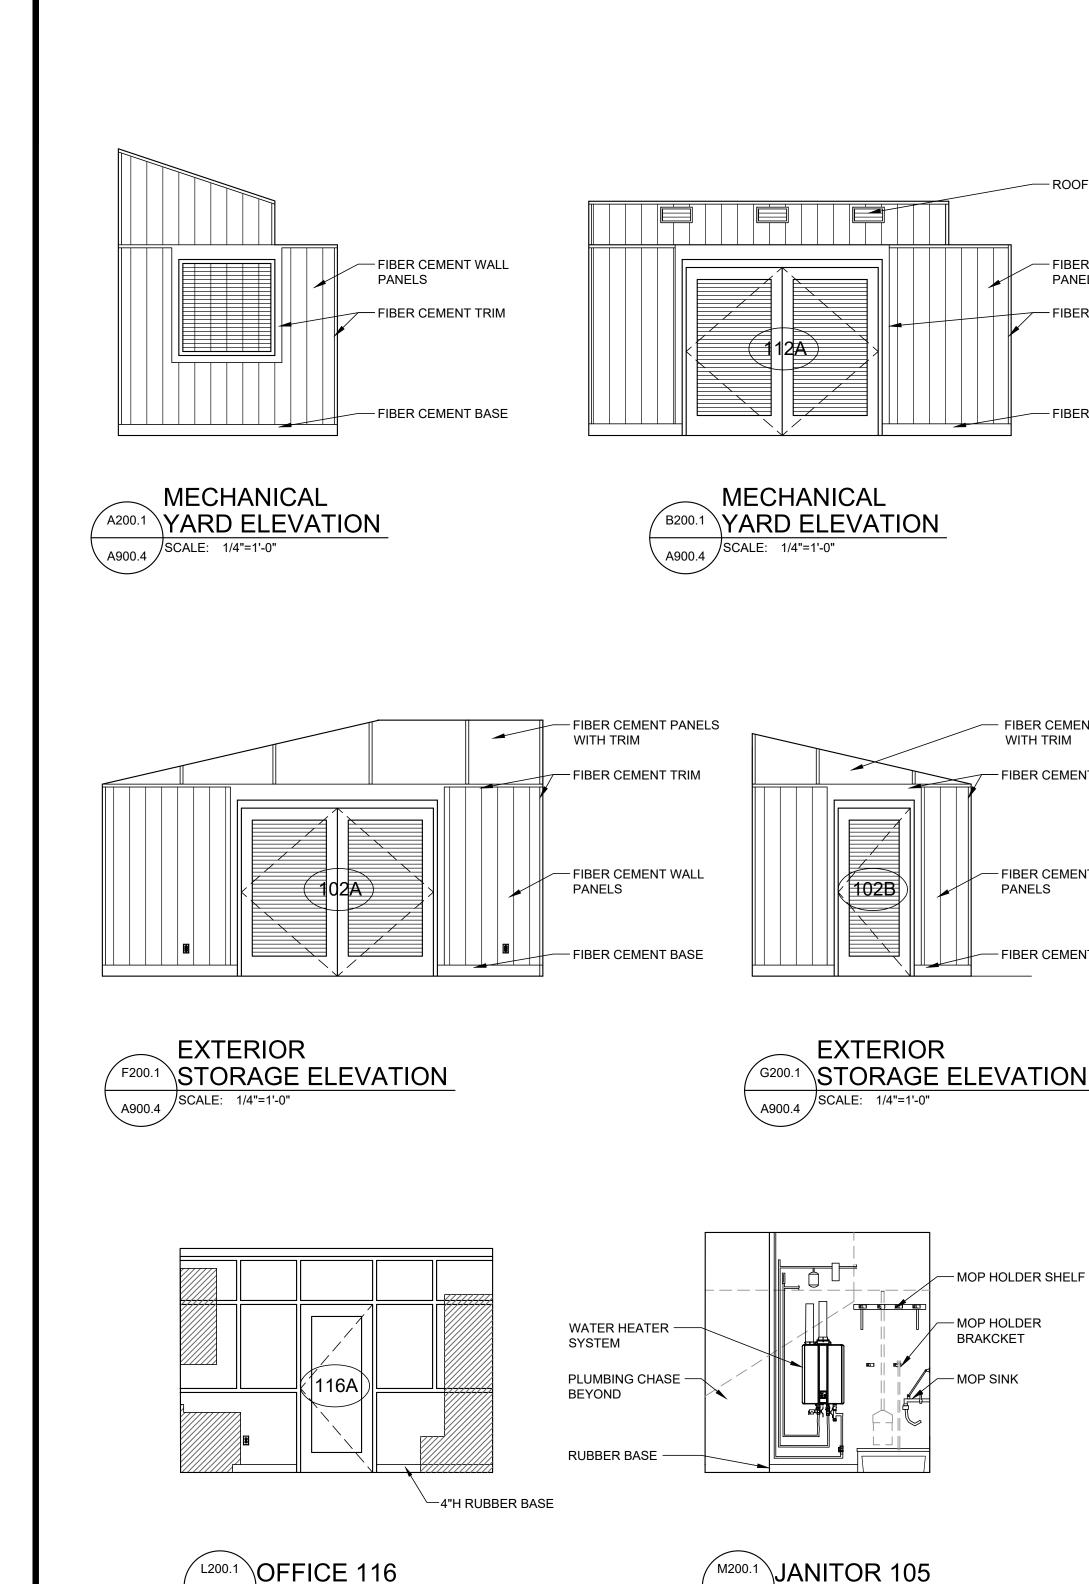

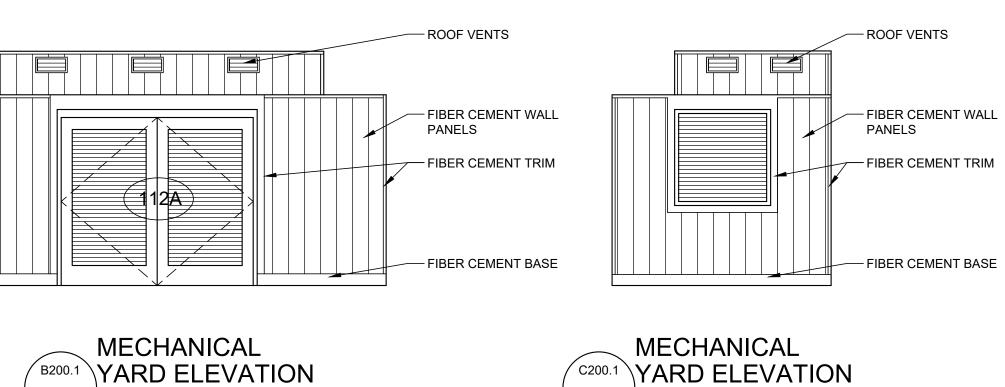

FIBER CEMENT PANELS

- FIBER CEMENT TRIM

FIBER CEMENT WALL

FIBER CEMENT BASE

(101C)


EXTERIOR


A900.4 SCALE: 1/4"=1'-0"

H200.1 STORAGE ELEVATION

WITH TRIM


PANELS

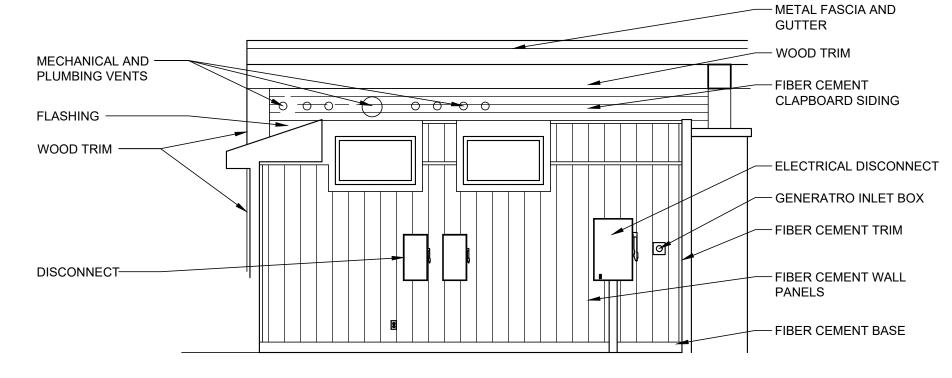


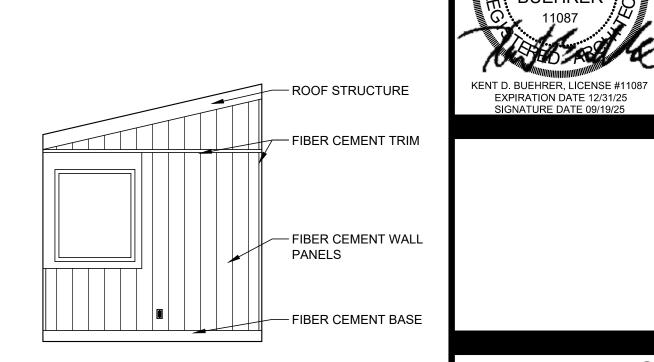






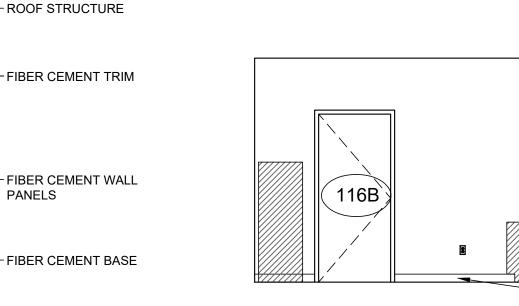

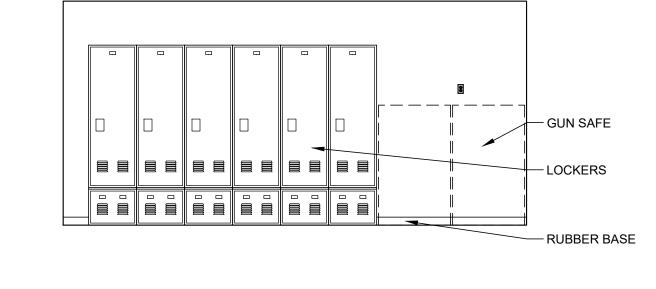






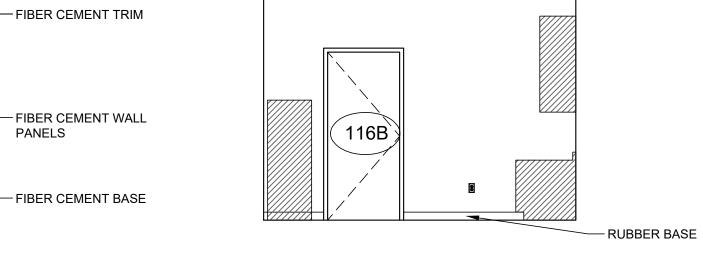



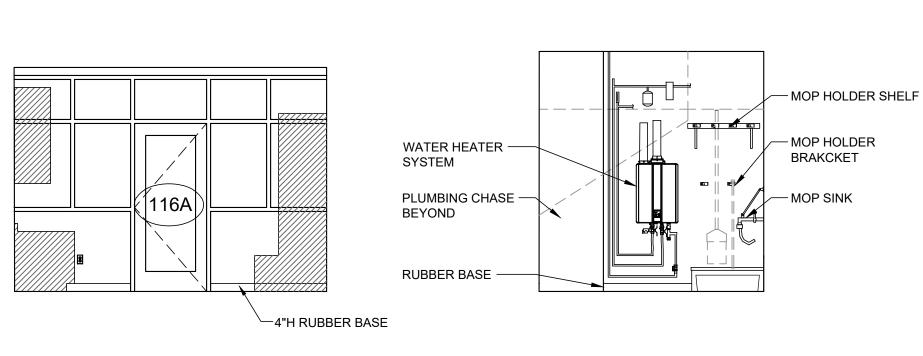







KENT D. BUEHRER

NATURAL 250013

GLSM PARK OFFIC FOR DEPARTMENT OF N ESOURCES DNR-25


DEPARTESOUR(

OHIO

OFFICE

REVISION SCHEDULE
ISSUE DATE: 09/19/2025

JOB NUMBER: 241224 CONSTRUCTION DOCUMENTS

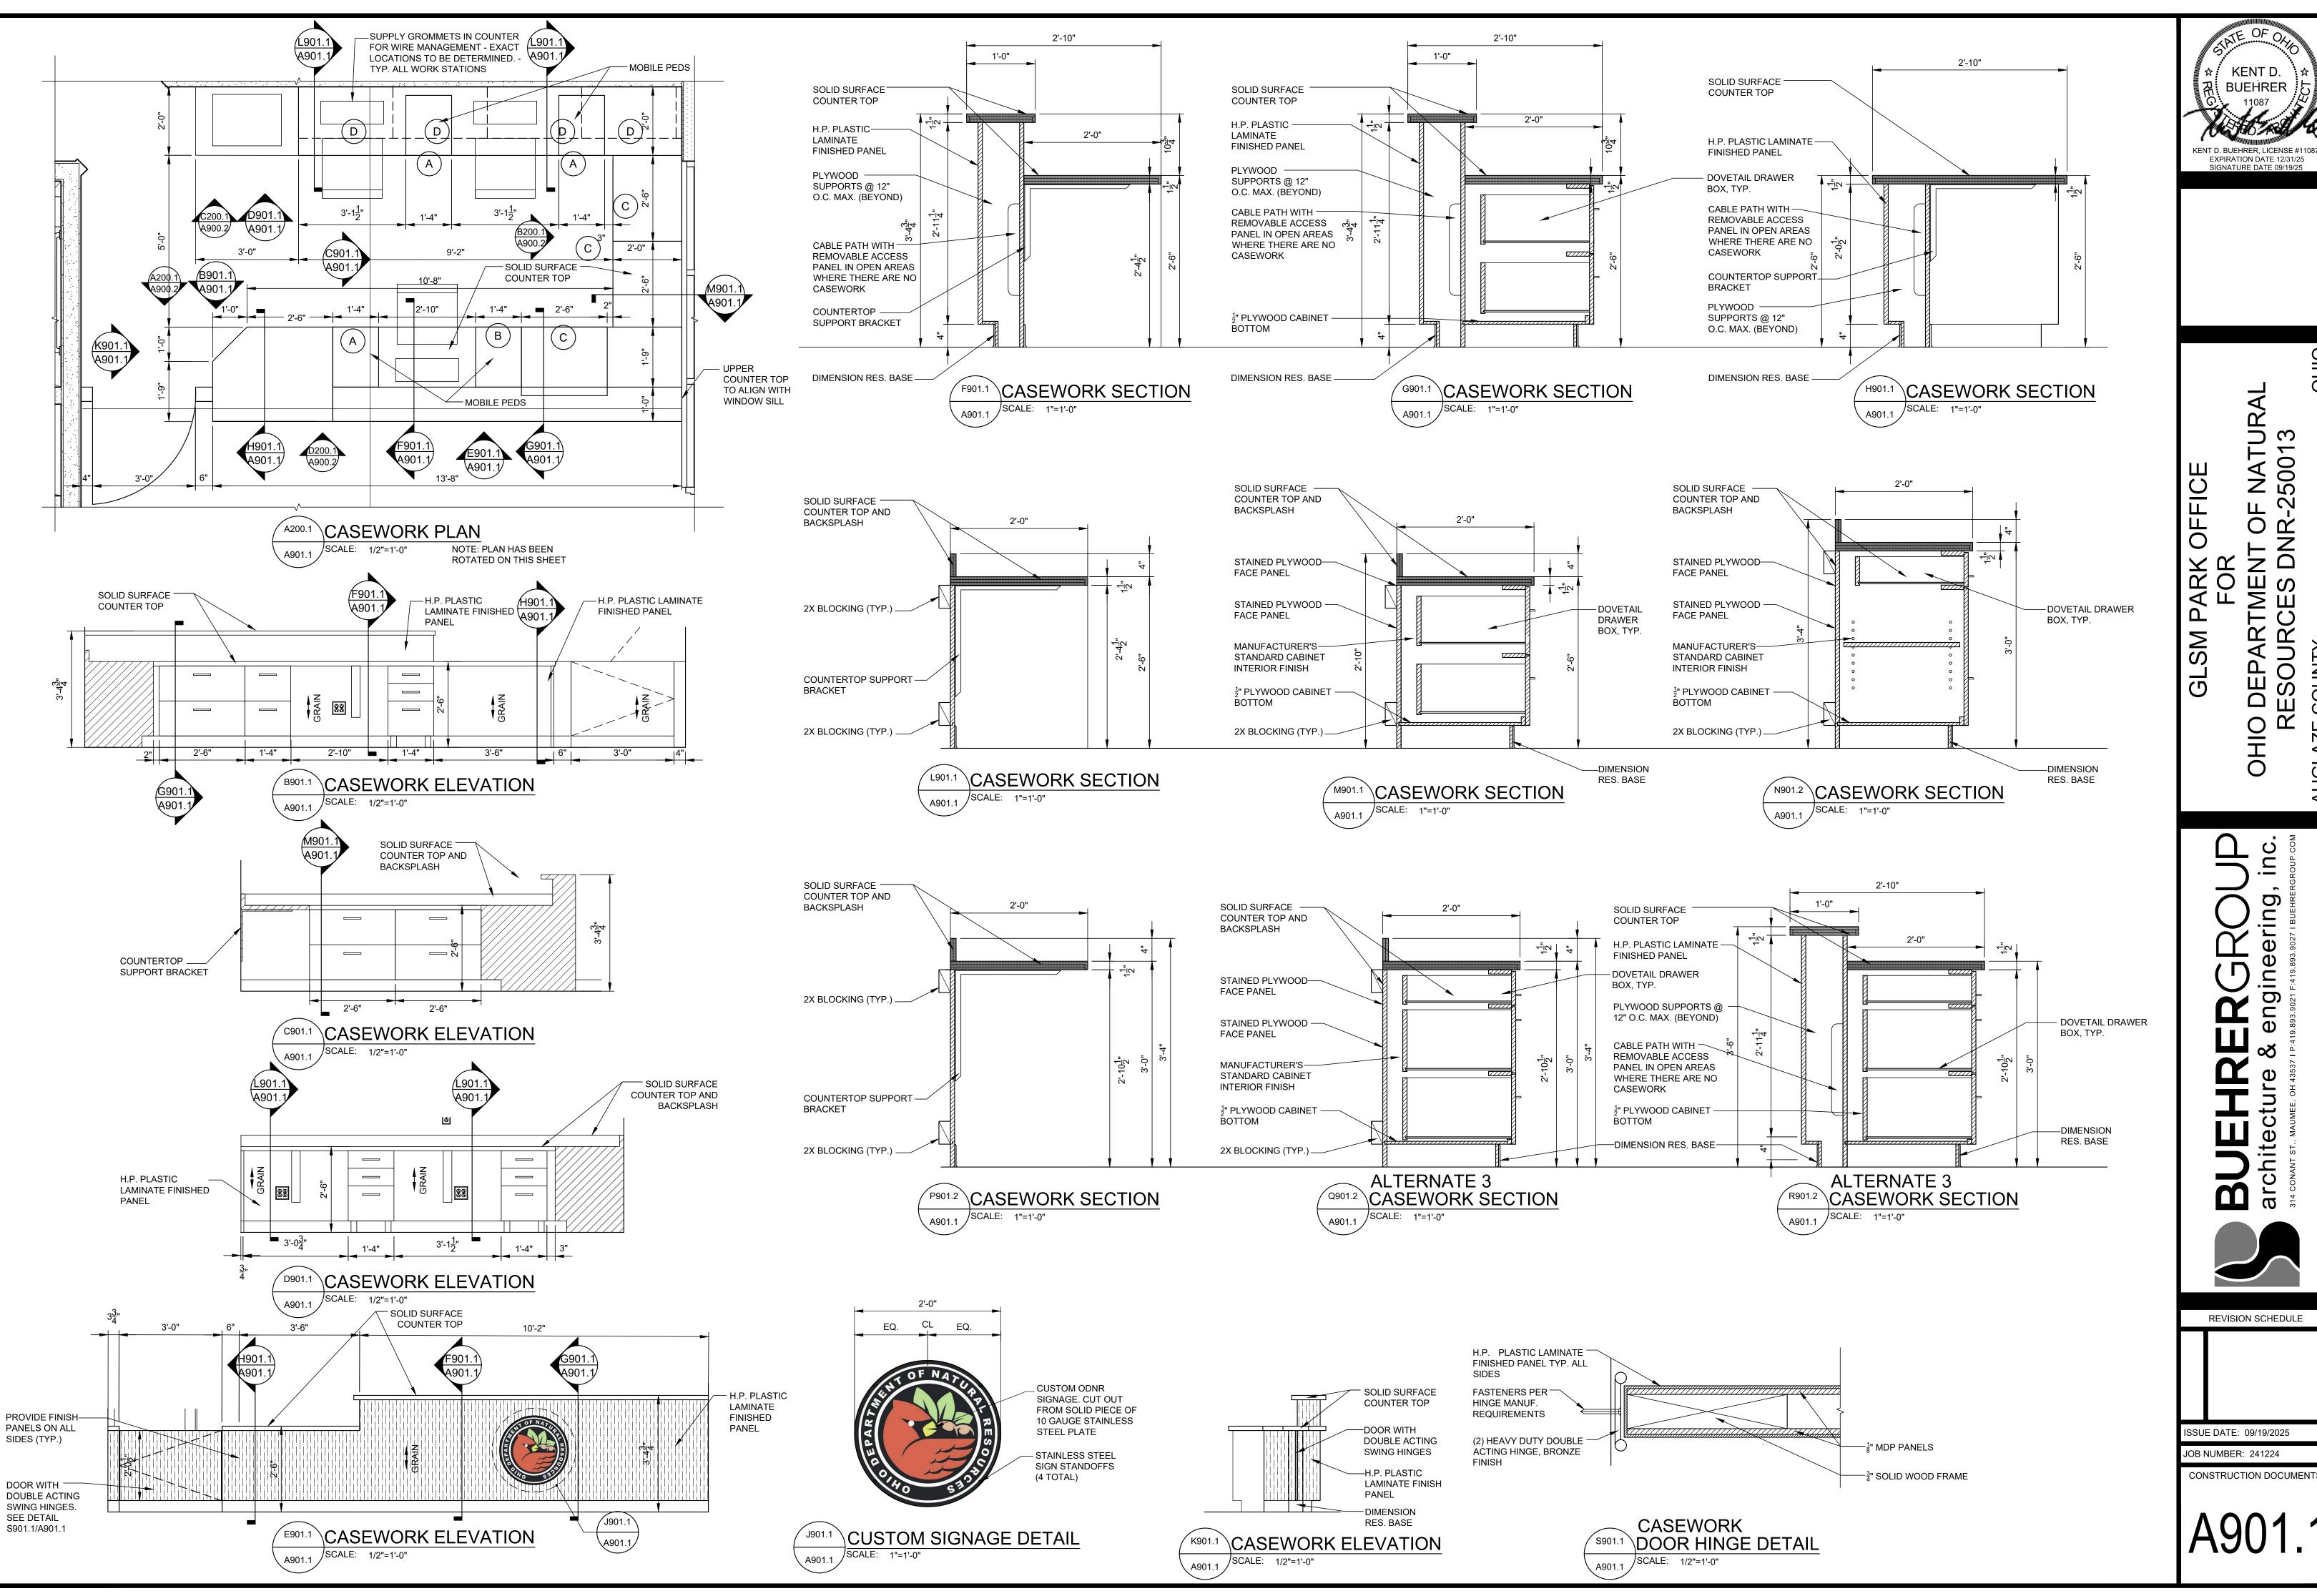




₩ Z 2 0 2 PARK 0

> ring Φ ng



REVISION SCHEDULE ISSUE DATE: 09/19/2025

JOB NUMBER: 241224

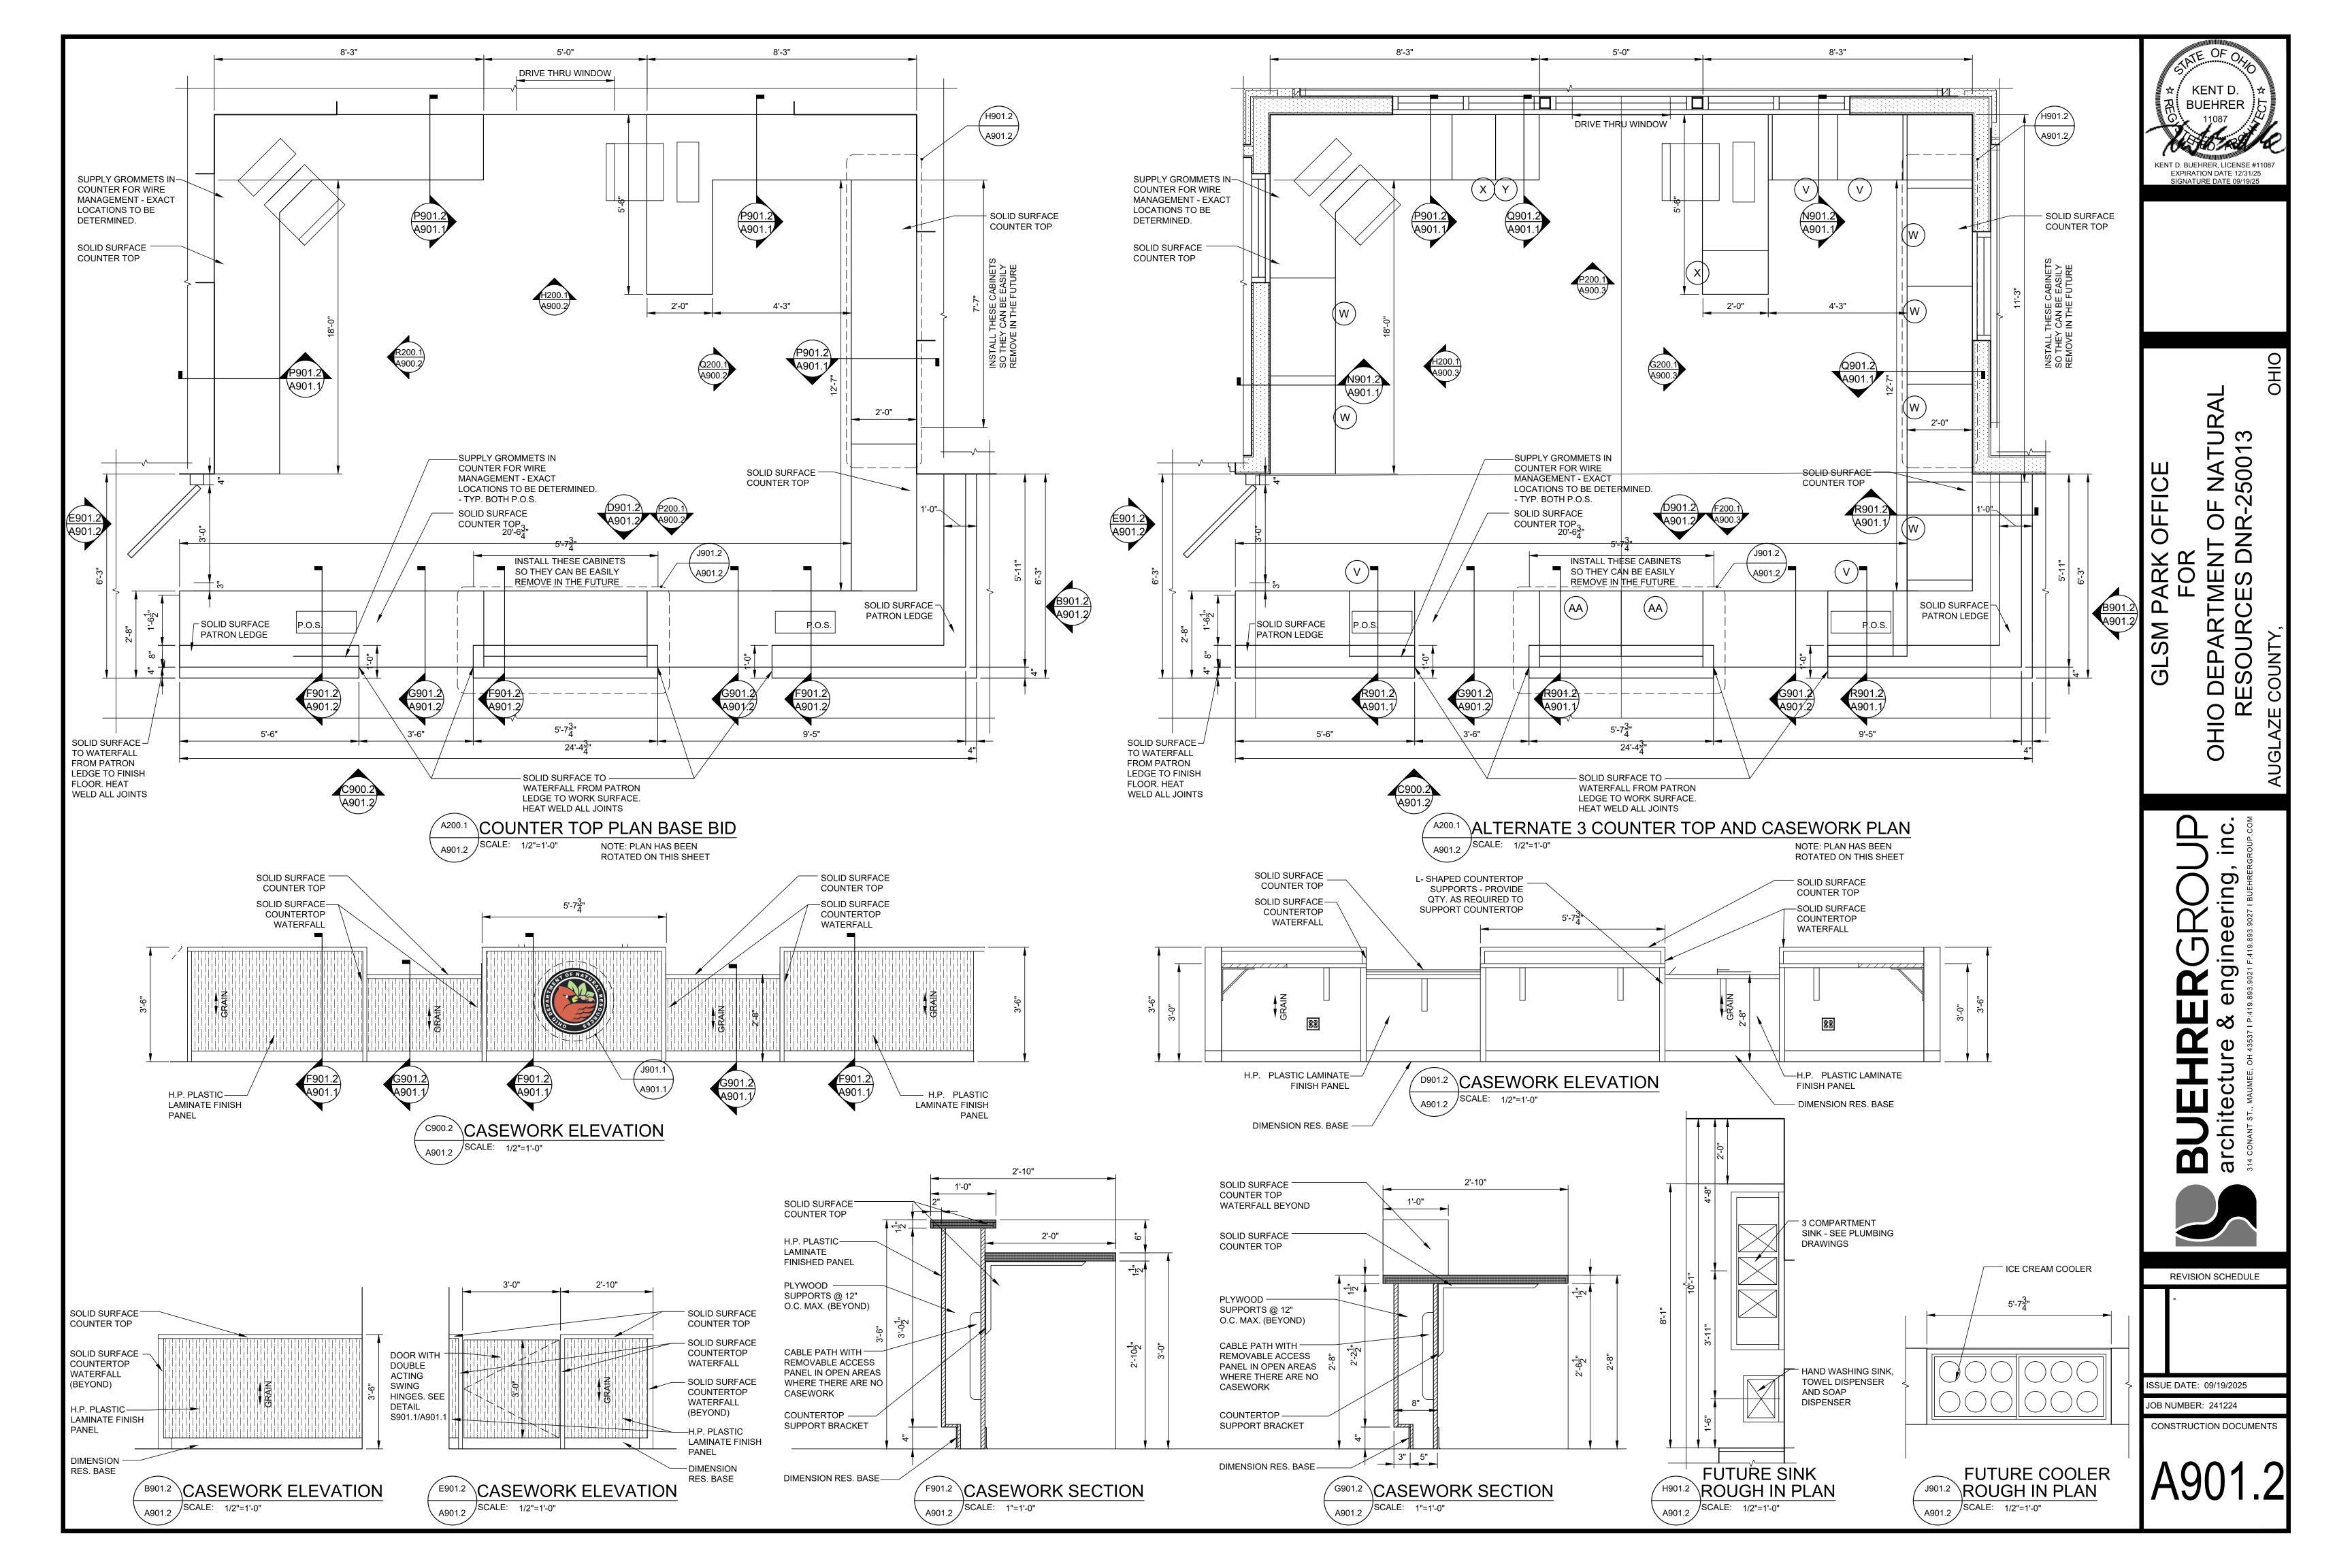

SPECIAL INSPECTIONS:

- 1 PURSUANT TO CHAPTER 17 (SPECIAL INSPECTION & TESTING) OF THE OHIO BUILDING CODE OBC 2024 IN ADDITION TO THE REGULAR INSPECTIONS THE ARCHITECT ON BEHALF OF OWNER WILL RETAIN A TESTING AGENCY TO PERFORM SPECIAL INSPECTIONS ON THE ITEMS LISTED IN THE TABLE BELOW. CONTRACTOR TO PROVIDE ACCESS AND HAVE WORK AREAS READY FOR INSPECTION AS NEEDED.
- 2. TESTING AGENCY TO SUBMIT A LIST OF THEIR QUALIFIED SPECIAL INSPECTORS AND THEIR RESUMES AND/OR CERTIFICATION TO THE ARCHITECT/ENGINEER OF RECORD TO FILE WITH THE PLAN APPROVAL APPLICATION.
- 3. INSPECTIONS SHALL NOT RELIEVE THE CONTRACTOR FROM FULL RESPONSIBILITY FOR THE ACCURACY OF THE WORK AND ALL OF ITS DETAILS

	SCHEDULE OF SPECIAL INSP	PECTION		
NO.	ITEM	REQUIRED	CONTINUOUS INSPECTION	PERIODIC INSPECTION
1	STRUCTURAL STEEL - OBC 1705.2			
	STEEL COLUMN CONNECTIONS TO WOOD BEAMS			Х
2	CONCRETE CONSTRUCTION -OBC 1705.3			
	REINFORCING STEEL PLACEMENT			×
	CONCRETE PLACEMENT			×
	SAMPLING AND CONCRETE TESTING	İ		X
	CONCRETE CURING TEMPERATURE AND TECHNIQUES			Х
	ANCHOR RODS SIZE, POSITIONING AND EMBDMENT			Х
3	MASONRY CONSTRUCTION -OBC 1705.4			
	MASONRY MORTAR JOINT			×
	MASONRY REINFORCEMENT AND CONNECTORS			Х
	MASONRY GROUTING			Х
	MASONRY ANCHORS AND TIES			X
4	WOOD CONSTRUCTION -OBC 1705.5	1		
4	PREFABRICATED WOOD TRUSSES PLACEMENT			X
	WOOD SILL PLATE CONNECTIONS			
				X
	TRUSS CONNECTION AT BEARING			X
	WOOD COLUMN CONNECTIONS			X
	I-JOISTS CONNECTION AT BEARING			X
5	SOILS AND FOUNDATION -OBC 1705.6	ı	1	
	SITE PREPARATION AND REMOVAL OF UNSUITABLE MATERIALS			X
	COMPACTED FILL MATERIALS, LIFT THICKNESS, DENSITY			Х
	SOIL LOAD BEARING CAPACITY			Х

GENERAL NOTES:

NOTE: GENERAL CONTRACTOR IS RESPONSIBLE FOR DETERMINING THE SEQUENCE OF ERECTION PROCEDURES AND BRACING (SHORING) OF WALLS, FLOORS, ROOFS AND STRUCTURAL MEMBERS (BEAMS, COLUMNS, TRUSSES,ETC.) TO INSURE THE SAFETY OF THE BUILDING AND ITS COMPONENTS DURING CONSTRUCTION.

GENERAL CONTRACTOR SHALL BE RESPONSIBLE FOR ALL MEANS AND METHODS OF CONSTRUCTION TO COMPLETE THE PROJECT ACCORDING TO THE DRAWINGS AND SPECIFICATIONS

GENERAL NOTES

- 1. COORDINATE w/ ARCHITECTURAL FLOOR PLANS AND SECTIONS FOR ANY SLAB RECESSES REQUIRED FOR DOOR MATS, FLOORING, ETC...
- 2. VERIFY LOCATIONS OF COLUMNS, WALLS, ETC. WITH THE ARCHITECTURAL DWG. BEFORE PLACING ANY FOUNDATIONS
- 3. INSTALL SLEEVES THRU BLOCKS FOR ALL UNDERGROUND PIPES. SLEEVES TO BE PROVIDED BY THE REQUIRED CONTRACTOR.
- 4. SAW CUT FLOOR SLABS INTO SECTIONS NOT GREATER THAN 15'-0"X15'-0". PROVIDE DIAMOND CUT AROUND ALL COLUMN LOCATIONS
- 5. COORDINATE WITH ARCHITECTURAL DRAWINGS FOR MISC. CONCRETE PADS REQUIRED FOR INTERIOR MECHANICAL AND ELECTRICAL EQUIPMENTS.

WOOD CONSTRUCTION NOTES:

- 1. ALL DIMENSION LUMBER AND HEAVY TIMBER SHALL COMPLY WITH THE NATIONAL DESIGN SPECIFICATIONS FOR WOOD CONSTRUCTION" NDS-2018
- 2. ALL LOAD BEARING STUDS, DOOR HEADERS, WINDOW HEADERS AND DOUBLE
- & TRIPLE STUDS SHALL BE STRUCTURAL GRADE "SPRUCE-PINE-FIR" OR APPROVED EQUAL BENDING STRESS, Fb = 1300 PSI
 - SHEAR STRESS, Fv = 70 PSI MODULUS OF ELASTICITY, E = 1,500,000 PSI - LVL BEAMS: Fv=285 PSI, Fb=2900 PSI AND E=2,000,000 PSI
- 3. ALL LOADBEARING DOOR OPENINGS TO HAVE (2) 2X8 OR (3) 2X8 HEADERS
- UNLESS NOTED OTHERWISE ON THE FRAMING PLANS AND HEADER SCHEDULE
- EACH END UNLESS NOTED OTHERWISE.

4. ALL HEADERS TO BE SUPPORTED BY A MINIMUM OF (2)-2X4'S OR (2)-2X6'S STUDS @

- 5. ALL LUMBER IN CONTACT WITH CONCRETE FLOOR SLABS OR CONCRETE BLOCK
- OR IN CONTACT WITH EARTH TO BE PRESSURE TREATED. 6. ALL LUMBER TO BE A MAXIMUM OF 19% MOISTURE CONTENT.
- 7. ALL WALL STUDS TO BE 16" O.C. UNLESS NOTED OTHERWISE.
- 8. DO NOT NOTCH, BORE, OR CUT WOOD MEMBERS FOR PIPES, DUCTS, CONDUITS OR OTHER REASONS IN SUCH A MANNER AS TO HINDER THE STRUCTURAL CAPABILITY OR INTENDED USE. STRUCTURAL MEMBERS WHOSE STRENGTH IS IMPAIRED BY IMPROPER CUTTING OR DRILLING OR EXCESSIVE DEFECTS SHALL BE REPLACED OR REINFORCED.
- 9. PROVIDE BLOCKING FOR WALL HUNG GRAB BARS, MIRRORS, WALL CABINETS, DRAPERY RODS, DOOR STOPS, ETC.
- 10. PROVIDE A MIN. OF (2) LINES OF SOLID BLOCKING IN ALL EXTERIOR WALLS.
- 11. SHEATHING FOR WALLS TO BE A MIN. OF 5/8" AND 3/4" FOR ROOF PLYWOOD OR OSB EXTERIOR APA-STRUCTURAL I GRADE. USE 8d COMMON NAILS AT 6" O/C AT EDGES AND 12" O/C AT INTERMEDIATES
- 12. SUBMIT COMPLETE SHOP DRAWINGS FOR ALL WOOD PREFAB TRUSSES SHOWING MEMBER SIZES, SPECIES, GRADE, MOISTURE CONTENT, SPAN, DIMENSIONS, BRACING REQUIREMENTS AND LOADINGS. SHOP DRAWINGS SHALL BEAR THE SEAL OF A PROFESSIONAL ENGINEER REGISTERED IN THE STATE OF OHIO.
- 13. SEE ROOF DESIGN LOADS AND SNOW DRIFT LISTED ON THIS SHEET ABOVE
- 14. TRUSS MANUFACTURERS TO SUPPLY ANY STRAIGHT AND SKEWED HANGERS
- 15. ALL PRE-ENGINEERED PRE-FABRICATED METAL PLATES CONNECTED TRUSSES SHALL BE DESIGNED, FABRICATED AND ERECTED IN COMPLIANCE WITH "NATIONAL DESIGN STANDARD FOR METAL PLATE CONNECTED WOOD TRUSS CONSTRUCTION " ANSI/TPI1-2022
- TYPICAL FOR ROOF TRUSSES: T/C LIVE LOAD = 25 PSF T/C DEAD LOAD = 10 PSF B/C DEAD LOAD = 10 PSF

STRUCTURAL STEEL CONSTRUCTION NOTES

OHIO BUILDING CODE AND AISC 360-16

OTHERWISE NOTED.

WELDING SOCIETY AWS D1.1

FOR MORTAR COVER.

- DESIGN FOR SNOW DRIFT FROM HIGHER ROOF AREAS
- -ALL TRUSSES TO BE DESIGNED IN ACCORDANCE WITH OBC -2024 & IBC -2021 AND NOT THE OHIO RESIDENTIAL CODE
- 16. ALL DAMAGED TRUSSES SHALL BE REPAIRED AND/OR REPLACED AT NO COST TO OWNER.

1. DESIGN, FABRICATE AND ERECT STRUCTURAL STEEL IN ACCORDANCE WITH THE

DRAWINGS OR REQUIRED TO COMPLETE THE INTENDED WORK.

ALL M, MC, S, C, ANGLES, PLATES AND BARS FROM (A36 STEEL).

ALL ROUND SHAPES HSS TUBING - A500 GRADE B (FY = 42 KSI)

OPENINGS AND SLAB EDGES WHERE REQUIRED.

ALL SQUARE & RECTANGULAR HSS TUBING - A500 GRADE B (FY = 46 KSI).

ALL ANCHOR RODS FOR BASE PLATES - ASTM F1554 GRADE 36 U.N.O.

LATEST (A.I.S.C) ASD EDITION AND SPECIFICATIONS AS REFERENCED IN THE 2024

2. FIELD BOLTS SHALL BE 3/4" DIA. STD. MACHINE BOLTS CONFORMING TO A.S.T.M. A325 UNLESS

3. PROVIDE ALL BOLTS, ANCHORS, STRAPS, FASTENERS, AND SIMILAR ITEMS AS SHOWN ON THE

4. ALL W SHAPES STEEL FRAMING SHALL BE FABRICATED FROM (ASTM A992 - FY= 50 KSI)

5. ALL WELDING ELECTRODES SHALL BE E-70XX AND IN ACCORDANCE WITH AMERICAN

6. ALL L'S , PL'S AND FLANGES CARRYING WALLS EXPOSED TO VIEW SHALL BE COPED

8. PROVIDE AND INSTALL ANY MISC. SCREED ANGLES FOR SUPPORT OF ROOF OR FLOOR

9. DO NOT CUT IN FIELD OR MODIFY ANY STRUCTURAL STEEL MEMBER WITHOUT APPROVAL FROM ENGINEER

7. ALL STEEL WORK, BEFORE LEAVING SHOP TO HAVE TWO GOOD COAT OF PAINT

- 17. GENERAL CONTRACTOR SHALL BE RESPONSIBLE FOR INSTALLING ALL TEMPORARY BRACING ACCORDING TO THE RECOMMENDATIONS OF "BUILDING COMPONENT SAFETY INFORMATION" BCSI
- 18. GENERAL CONTRACTOR SHALL BE RESPONSIBLE FOR INSTALLING ALL PERMANENT BRACING ACCORDING TO THE TRUSS MANUFACTURER DESIGN, RECOMMENDATIONS AND AS SHOWN ON THE TRUSS PLANS

CONCRETE REINFORCEMENT".

BUT NOT LESS THAN 12".

CONCRETE CONSTRUCTION NOTES

PLACED IN FLAT SHEETS.

WIRED TOGETHER AT LAPS.

REINFORCED CONCRETE (ACI 318-2019)

OTHERWISE NOTED:

1. ALL CONCRETE SHALL COMPLY WITH SPECIFICATIONS AND STD 6"X12" CYLINDERS SHALL TEST

2. EXTERIOR CONCRETE WALKS AND CURBS SHALL COMPLY WITH SPECIFICATIONS AND STD 6"X12"

CYLINDERS SHALL TEST 4000 PSI AIR-ENTRAINED MINIMUM AT AGE OF 28 DAYS. WALKS SHALL

6. WIRE FABRIC REINFORCING SHALL LAP ONE FULL MESH AT SIDES AND END LAPS AND SHALL BE

FORMED SURFACED EXPOSED TO WEATHER 1-1/2" FOR #5 BARS AND SMALLER

2" FOR # 6 AND LARGER

4000 psi MINIMUM AT AGE OF 28 DAYS, FOR FLOORS AND 3000 PSI FOR FOOTINGS.

B4 4" THICK W/HAVE 6"x6" -W2.1XW2.1 WELDED WIRE FABRIC PLACED AT MID DEPTH.

GRADE 60. BARS TO BE PLACED PER LATEST ACI STANDARDS.

CONCRETE SLABS AND JOISTS

3. REINFORCING BARS, UNLESS OTHERWISE SPECIFIED, SHALL MEET THE LATEST ASTM A615

4. WELDED WIRE FABRIC SHALL CONFORM TO ASTM A-185, AND SHALL BE FURNISHED AND

5. MINIMUM CONCRETE COVERS FOR REINFORCING BARS SHALL BE AS FOLLOWS UNLESS

CONCRETE DEPOSITED AGAINST GROUND 3"

7. SLABS SHALL HAVE OPENINGS VERIFIED BY MECHANICAL AND ELECTRICAL

8. CONCRETE SLABS ON GROUND SHALL BE PLACED ON BASE PER SPECIFICATIONS.

FLOATING MESH IN PLACE OR PULLING MESH UP WILL NOT BE ACCEPTABLE.

9. CONCRETE DESIGN AND REINFORCING IS BASED ON "BUILDING CODE REQUIREMENTS FOR

10. ALL INTERIOR U.N.O.CONCRETE SLABS ON GRADE SHALL BE 4" THICK REINFORCED WITH

W/6X6-W2.1XW2.1 WWF PLACED AT MID DEPTH USING REBAR CHAIRS AT A MAXIMUM OF 3' O/C.

11. WHERE CONTINUOUS BARS ARE CALLED FOR, THEY SHALL BE RUN CONTINUOUSLY AROUND

CORNERS AND LAPPED AT NECESSARY SPLICES, AND HOOKED AT DISCONTINUOUS ENDS.

12. WALLS, PIERS, AND COLUMNS SHALL BE DOWELED TO FOOTINGS. WALL FOOTINGS AND

CONCRETE COLUMN DOWELS SHALL BE SAME SIZE AS WALL AND COLUMN VERTICALS.

13. LAP ALL BARS SPLICES 24 BAR DIAMETERS MINIMUM (UNLESS OTHERWISE CALLED FOR)

14. CONTRACTOR TO SUBMIT REBAR SHOP DRAWINGS SHOWING REBAR SIZES, GRADES, PLACEMENTS,

BENDING DETAILS PREPARED ACCORDING TO THE LATEST ACI 315 "DETAILS AND DETAILING OF

CONTRACTORS BEFORE PLACING REINFORCING AND CONCRETE.

MASONRY CONSTRUCTION NOTES

- 1. MASONRY DESIGN IS BASED ON "BUILDING CODE REQUIREMENTS FOR MASONRY STRUCTURES (TMS 402-2016)
- 2. HOLLOW CONCRETE MASONRY UNITS SHALL HAVE A MINIMUM COMPRESSIVE STRENGTH OF (2,000 PSI) AND MASONRY STRENGTH OF A MINIMUM, (fm'=2,000 PSI) AND MEETS ASTM C-90 REQUIREMENTS
- 3. MORTAR SHALL MEET REQUIREMENTS OF ASTM C-270 TYPE "S" 1,800 PSI TEST AT 28 DAYS.
- 4. USE COARSE GROUT FOR FILLING CONCRETE MASONRY UNITS, 2,500 PSI TEST 28 DAYS.
- 5. USE SOLID OR CONCRETE FILLED MASONRY UNITS ALL MEMBERS BEARING MASONRY. USE HOLLOW MASONRY UNITS FILLED WITH CONCRETE FOR WALLS RECEIVING ANCHORS.
- 6. NO CHASES, RISERS, CONDUITS, OR TOOTHING IN MASONRY WALLS SHALL OCCUR WITHIN 2'-0 OF A BEARING OR OTHER LOAD CONCENTRATION.
- 7. DO NOT LAY MASONRY IN FREEZING WEATHER UNLESS SUITABLE MEANS ARE PROVIDED TO HEAT MATERIALS PROTECT WORK FROM COLD AND FROST AND INSURE MORTAR WILL CURE WITHOUT FREEZING.
- 8. MASONRY WALLS SHALL HAVE HORIZONTAL WIRE REINFORCING AT 16" VERTICAL CENTERS EQUAL TO LADDER TYPE AS MADE BY HOHMANN & BERNARD INC. OR EQUAL. COMPLYING WITH ASTM A951
- 9. MASONRY CORNERS SHALL HAVE HORIZONTAL CORNER REINFORCING AT 16" VERTICAL CENTERS EQUAL TO LADDER/CORNER TYPE AS MADE BY HOHMANN & BERNARD INC. OR EQ. COMPLYING WITH ASTM A951
- 10. PROVIDE LAP LENGTHS AT SPLICES EQUALS TO VALUES SHOWN IN THE LAP SPLICE TABLE ON THIS SHEET.
- 11. MASONRY WALLS SHALL BE SOLID GROUTED UNDER ALL COLUMN BEARING POINTS AND AT THE END OF ALL BEAMS 6' AND LONGER. TWO 8" CORES SIDE BY SIDE SHALL BE SOLID GROUTED WITH 1-#5 REBAR IN EACH CORE. GROUT CORE SOLID FROM FOUNDATION TO BEARING POINT.
- 12. DOWEL #3X12" LONG REBAR EVERY OTHER COURSE TO TIE MASONRY TO ALL CONCRETE PIERS 13. TIE ALL MASONRY WALLS TO STEEL COLUMNS WITH ADJUSTABLE 1/4" DIAM. TIESX9" STRAPS WITH 3/16" DIAMETER TRIANGULAR TIES AT 16" O/C.
- 14. THE BEARING OF AT LEAST ONE END OF DOOR AND WINDOW LINTELS SHOULD BE BUILT TO SLIDE. PLASTIC OR BITUMINOUS SHEETS OR EQUAL MATERIALS SHOULD BE USED FOR A SLIP PLATE. IF STEEL BEARING PLATES ARE USED, ONE END NOT TO BE WELDED.
- 15. PROVIDE VERTICAL REINFORCING BARS AS CALLED FOR ON THE PLANS. PROVIDE A BAR AT ALL CORNERS AND AT EACH SIDE OF CONTROL JOINTS MATCHING THE WALL REINFORCEMENT
- 16. PILASTERS AND MASONRY PIERS TO BE LAID UP SIMULTANEOUSLY AND BONDED INTO ADJOINING MASONRY
- 17. THE TOP MASONRY COURSE OF ALL WALLS TO BE A BOND BEAM REINFORCED W/2#5 CONTINUOUS REBAR.
- 18. GROUT FULL MASONRY BLOCK AT ALL WINDOW AND LOUVER SILLS.
- 19. BEARING WALLS CORNERS SHALL BE BUILT IN RUNNING BOND. SEE TYPICAL MASONRY BOND BEAM DETAILS.
- 20. VERTICAL REBAR IN MASONRY TO BE HELD IN PLACE USING HOT DIPPED GALVANIZED 9 GAUGE REBAR POSITIONERS BY HOHMANN & BARNARD, INC. OR APPROVED EQUAL.
- 21. PROVIDE HOT-DIPPED GALVANIZED TIES BETWEEN ALL MASONRY BLOCKS AND STEEL BEAMS WEBS.

GENERAL STRUCTURAL NOTES

GOVERNING CODE: OHIO BUILDING CODE, OBC-2024 BASED ON INTERNATIONAL BUILDING CODE, IBC-2021 - ASCE/SEI 7-16

PROJECT LOCATION: GRAND LAKE ST. MARYS STATE PARK 834 EDGEWATER DRIVE

1. FOUNDATIONS ARE BASED ON A SAFE CARRYING CAPACITY OF 2000 PSF FOR SPREAD FOOTINGS AND CONTINUOUS WALL FOOTINGS. AFTER EXCAVATION IS COMPLETED AND BEFORE ANY FOUNDATIONS ARE CONSTRUCTED, CONTRACTOR SHALL COMPACT AND EXAMINE THE SOIL. IF THERE IS DOUBT ABOUT ITS ABILITY TO CARRY THIS AMOUNT OF LOAD HE SHALL BRING TO THE ATTENTION OF THE ENGINEER/ARCHITECT.

PLATFORM ABOVE MEZZANINE

REFER TO THE GEOTECHNICAL SUBSURFACE REPORT BY VERDANTAS DATED MAY 2025

ST. MARY'S, AUGLAIZE COUNTY, OHIO 45885

2. DESIGN LIVE LOADS: ROOF 20 PSF (minimum) 1ST FLOOR - SLAB ON GRADE 150 PSF (minimum) MEZZANINE (STORAGE & MECHANICAL)

SNOW DESIGN DATA:

- Pg =20 PSF (GROUND SNOW LOAD)

- Pf (min.) SLOPED =12.6 PSF

- Ce= 0.9 (SNOW EXPOSURE FACTOR - PARTIALLY EXPOSED)

- Ct= 1.0 (SNOW THERMAL FACTOR)

- Is= 1.0 (SNOW IMPORTANCE FACTOR)

- SNOW DRIFT LOADS WERE INCLUDED IN THE DESIGN (Max. Snow Drift Load, Pd = 33.2 PSF, Wd= 9.93')

4. WIND DESIGN DATA:

- BASIC WIND SPEED = 107 MPH

- BUILDING RISK CATEGORY-II - EXPOSURE CATEGORY "D"

- GCpi= +/- 0.18 (INTERNAL PRESSURE COEFFICIENT)

- MAX. VELOCITY PRESSURE, qh= + 26.98 PSF

- MAX. WALL COMPONENTS & CLADDING DESIGN PRESSURE: (AT MAIN), p = +31.93 PSF & -34.63 PSF

(AT CORNERS), p = +31.93 PSF & - 42.78 PSF MAX. ROOF COMPONENTS & CLADDING DESIGN PRESSURE:

(AT EDGES), p = +23.81 PSF & -53.60 PSF(AT CORNERS), p = +23.81 PSF & -75.24 PSF

NOTE: (-) INDICATES WIND PRESSURE ACTING AWAY FROM THE SURFACE (+) INDICATES WIND PRESSURE ACTING TOWARD THE SURFACE

5. SEISMIC DESIGN DATA:

- BUILDING OCCUPANCY RISK CATEGORY II

- SEISMIC IMPORTANCE FACTOR, le = 1.0 MAPPED SPECTRAL RESPONSE ACCELERATIONS:

Ss (Short period)= 0.229

S1 (1-Second period) = 0.072

SPECTRAL RESPONSE COEFFICIENTS:

Sds (Short period) = 0.245

Sd1 (1-Second period) = 0.116

- SITE CLASS "D"- STIFF SOIL SEE VERDANTAS SOIL REPORT SECTION 5.7 -SEISMIC CONSIDERATIONS

- SEISMIC DESIGN CATEGORY "B"

- BASIC SEISMIC-FORCE RESISTING SYSTEM: - BEARING WALL SYSTEM - LIGHT-FRAMED WALL SHEATHED WITH WOOD STRUCTURAL SHEAR PANELS
- SEISMIC RESPONSE COEFFICIENT, Cs=0.02 - RESPONSE MODIFICATION FACTOR, R=6.5

(H) ANALYSIS PROCEDURE:

-EQUIVALENT LATERAL FORCE PROCEDURE

6. THE STRUCTURE IS DESIGNED TO BE SELF-SUPPORTING AND STABLE AFTER IT IS FULLY COMPLETED. IT IS THE GENERAL CONTRACTOR RESPONSIBILITY TO DETERMINE ERECTION PROCEDURE AND SEQUENCE TO INSURE THE SAFETY OF THE BUILDING AND ITS COMPONENTS DURING CONSTRUCTION

FOUNDATION AND SOIL NOTES

- 1. ANY STRUCTURAL FILL PLACED BELOW FOUNDATION AND SLAB ON GRADE SHALL BE COMPACTED TO A MINIMUM OF 95% OF THE MAXIMUM MODIFIED PROCTOR DENSITY.
- 2. STRUCTURAL FILL SHOULD BE PLACED IN LIFTS OF 6 TO 8 INCHES LOOSE MEASURE, IF HAND-OPERATED COMPACTION EQUIPMENT IS USED, THE LEFT THICKNESS SHALL BE REDUCED TO 3 TO 4 INCHES.
- 3. THE CONTRACTOR SHALL MEET ALL OSHA EXCAVATIONS AND AND TRENCH SAFETY STANDARDS SLOPE HEIGHTS, SLOPE INCLINATION, ETC..
- 4. THE CONTRACTOR SHALL BE RESPONSIBLE FOR THE MEANS, METHODS AND SEQUENCE OF CONSTRUCTION OPERATION.
- 5. PROTECT BOTTOM OF FOUNDATIONS AGAINST FREEZING. WATER SHOULD NOT BE ALLOWED TO POND IN THE EXCAVATION.
- 6. COORDINATE WITH SITE/CIVIL DRAWINGS FOR ALL UNDERGROUND UTILITY LINES LOCATIONS BEFORE EXCAVATIONS OR POURING CONCRETE.
- 7. PROVIDE A BALANCED BACKFILL AGAINST FOUNDATION WALLS TO ELIMINATE ANY LATERAL LOADS OR PROVIDE LATERAL SUPPORT AS NEEDED
- 8. FROST DEPTH AT A MINIMUM OF 3'-6" (42")
- 9. GENERAL CONTRACTOR TO REVIEW SOIL REPORT BY VERDANTAS DATED MAY 2025 FOR RECOMMENDATIONS ON SITE AND SUBGRADE SOIL CONDITION AND PREPARATION
- 10. ANY SOFT SOIL OR LOOSE SOIL ZONES ENCOUNTERED AT THE BOTTOM OF THE FOOTING EXCAVATION SHALL BE REMOVED DOWN TO GOOD NATURAL SOILS AND REPLACED WITH 1500PSI LEAN CONCRETE
- 11. THE BEARING SURFACE AT THE BOTTOM OF ALL FOOTING EXCAVATION SHALL BE INSPECTED DURING CONSTRUCTION BY A GEOTECHNICAL ENGINEER OR QUALIFIED REPRESENTATIVE
- 12. GENERAL CONTRACTOR TO PROVIDE ANY DEWATERING SYSTEM, PUMPS NEEDED TO REMOVE ANY WATER FROM THE BOTTOM OF EXCAVATION



AR FO Ш (A

D



REVISION SCHEDULE

ISSUE DATE: 09/19/2025

OB NUMBER: 241224 CONSTRUCTION DOCUMENTS

B/BRG. = BEAM BEARING BP# = BASE PLATE BRG. = BEARING B/S = BOTH SIDES B/FTG. = BOTTOM OF FOOTING CL/CL = CENTER TO CENTER C.M.U. = CONCRETE MASONRY UNIT CONC. = CONCRETE

CONT. = CONTINUOUS

COOR. = COORDINATE

DIA. or \sim = DIAMETER E/S = EACH SIDE E.C. = ELECTRICAL CONTRACTOR ELEV. = ELEVATION EQ. = EQUAL F# = COLUMN FOOTING NUMBER F/FLR. = FINISH FLOOR FND. = FOUNDATION GA. = GAUGE

GALV. = GALVINIZED


G.C. = GENERAL CONTRACTOR I.C.F. = INSULATED CONCRETE FORMS IN/IN = INSIDE TO INSIDE PRE-FAB LGST= PRE-FABRICATED LIGHT GAUGE STEEL TRUSS M.C. = MECHANICAL CONTRACTOR MTL. = METAL MISC. = MISCELLANOUS M.O. = MASONRY OPENING PL. = PLATE


STRUCTURAL LEGEND


P.C. = PLUMBING CONTRACTOR PR# = CONC. PIER # O.C. = ON CENTER O/O = OUTSIDE TO OUTSIDE O.H. = OVER HANG REINF. = REINFORCED SLP. = SLOPE ST. = STEEL


T&B = TOP AND BOTTOM T/FTG. = TOP OF FOOTING T/ST. = TOP OF STEEL TYP. = TYPICAL U.N.O. = UNLESS NOTED OTHERWISE W.W.F. = WELDED WIRE FABRIC W/ = WITHW/O = WITHOUT

STP. FTG. = STEP FOOTING

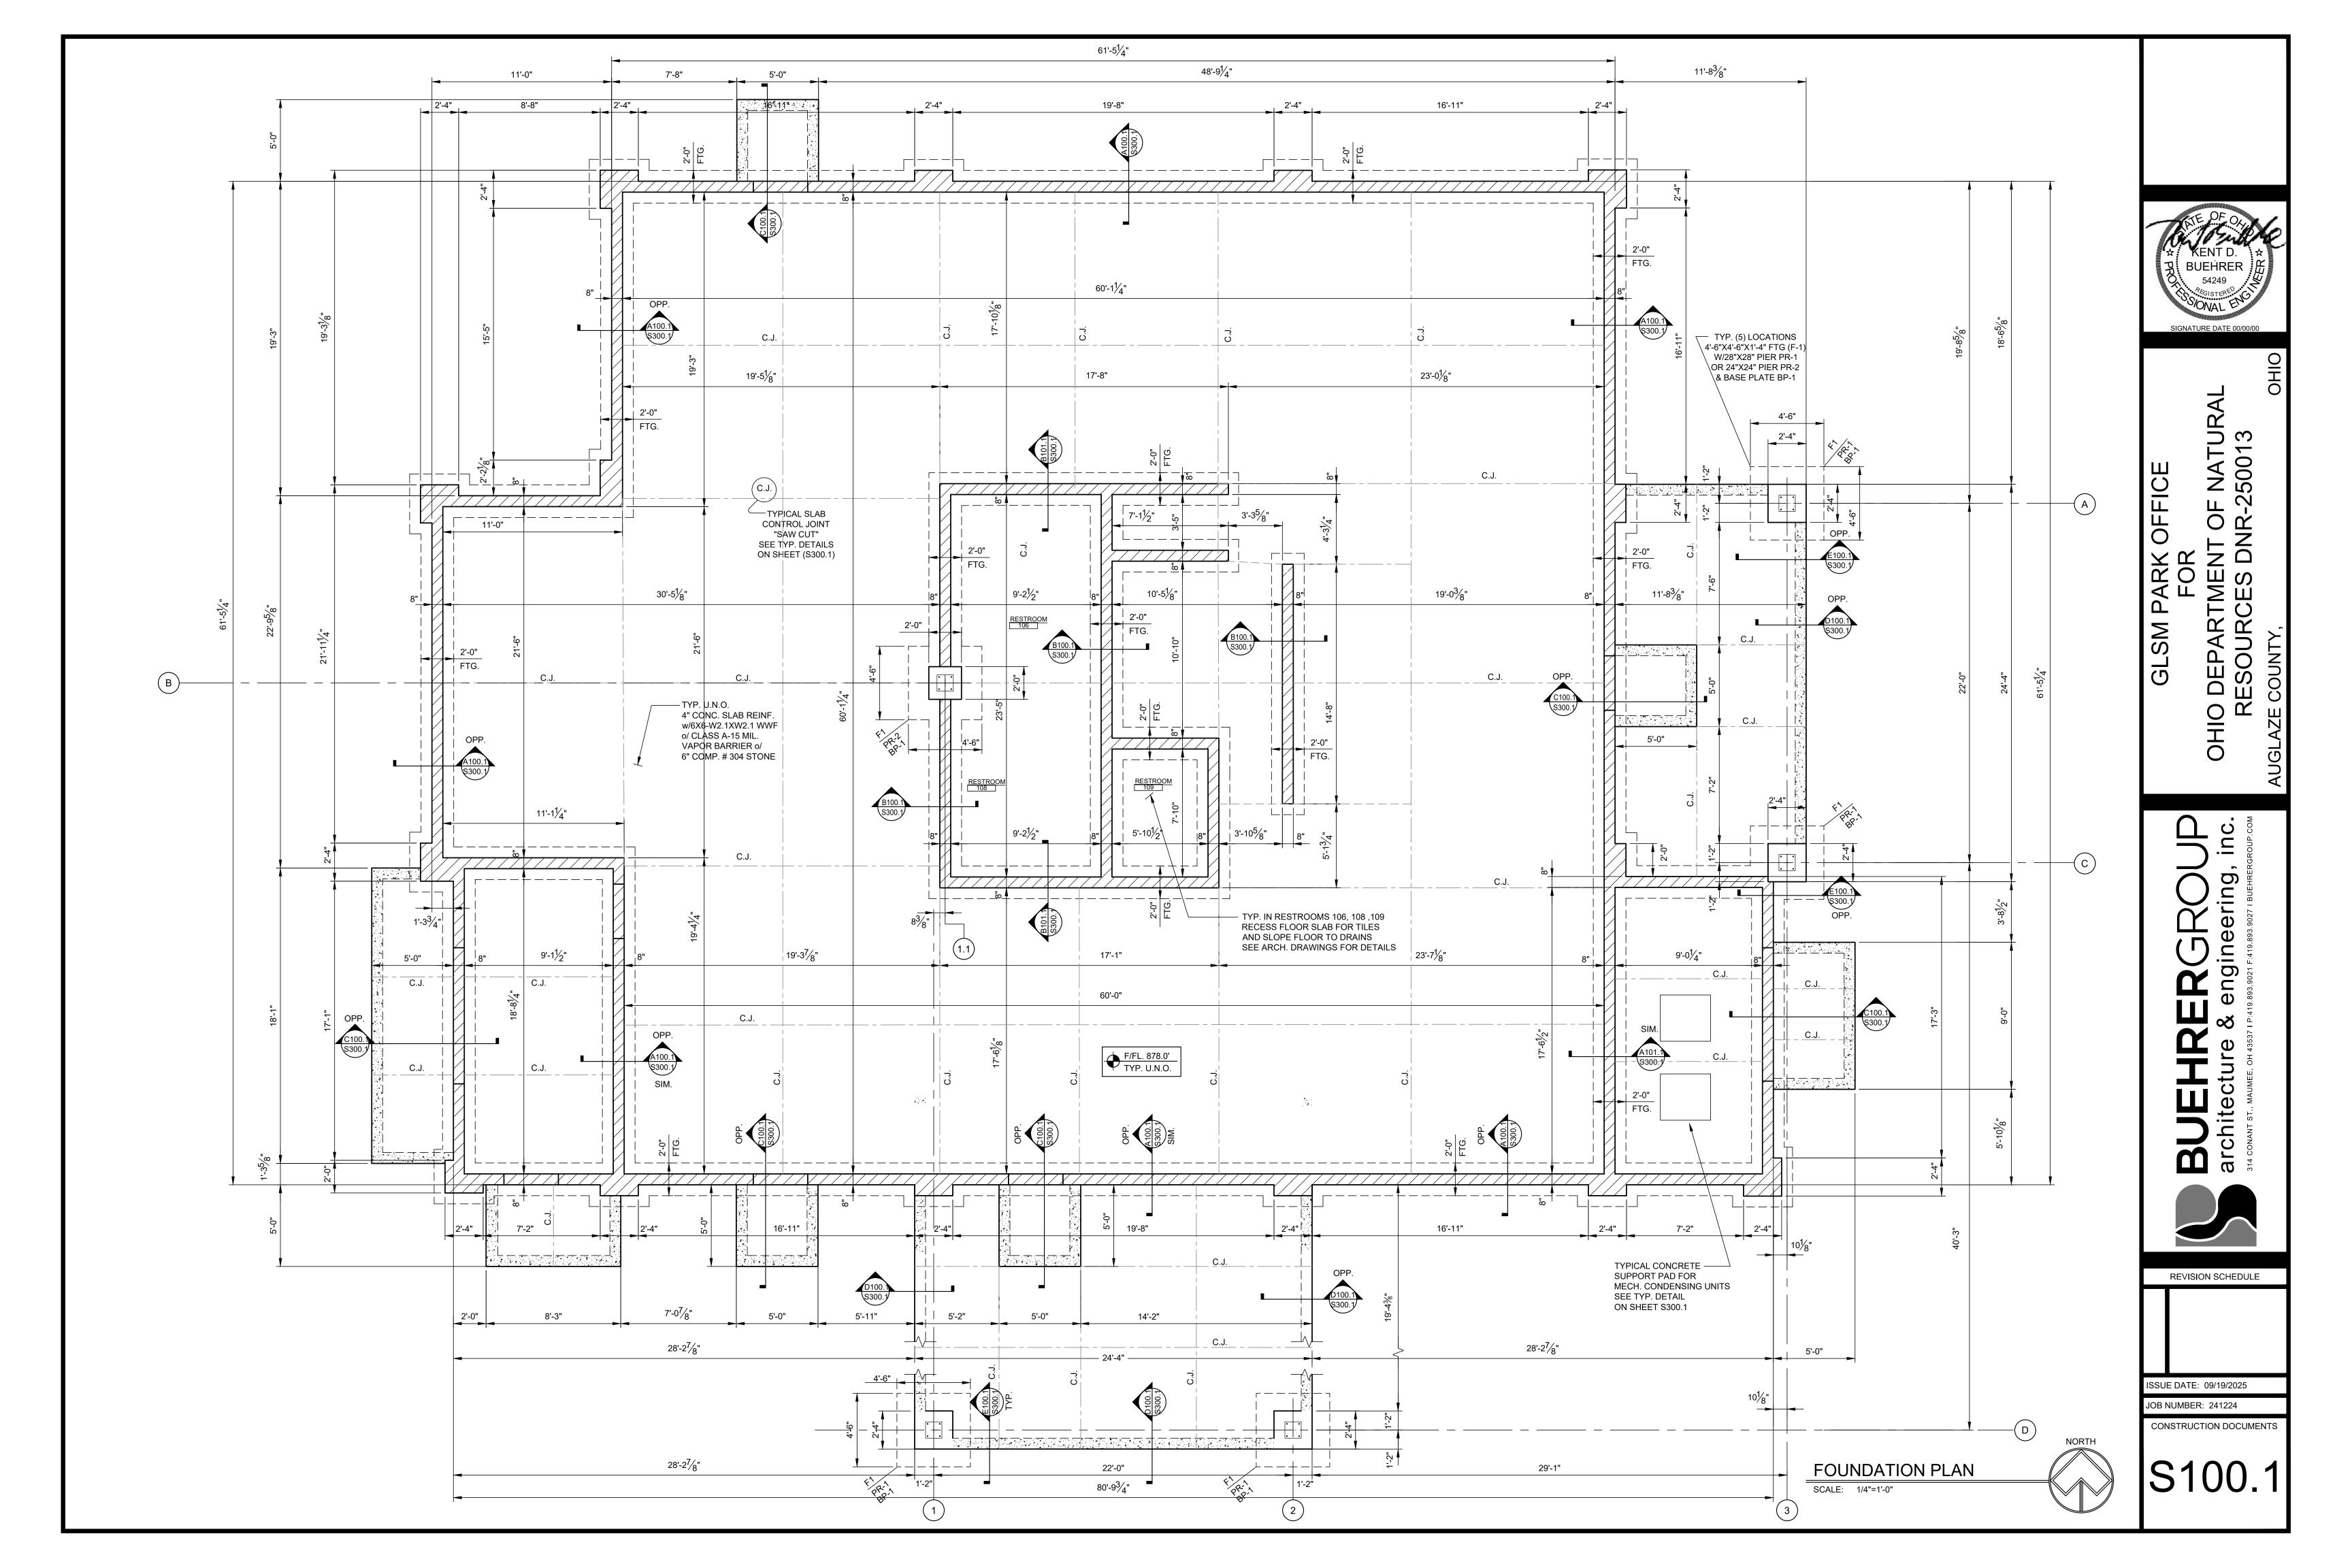

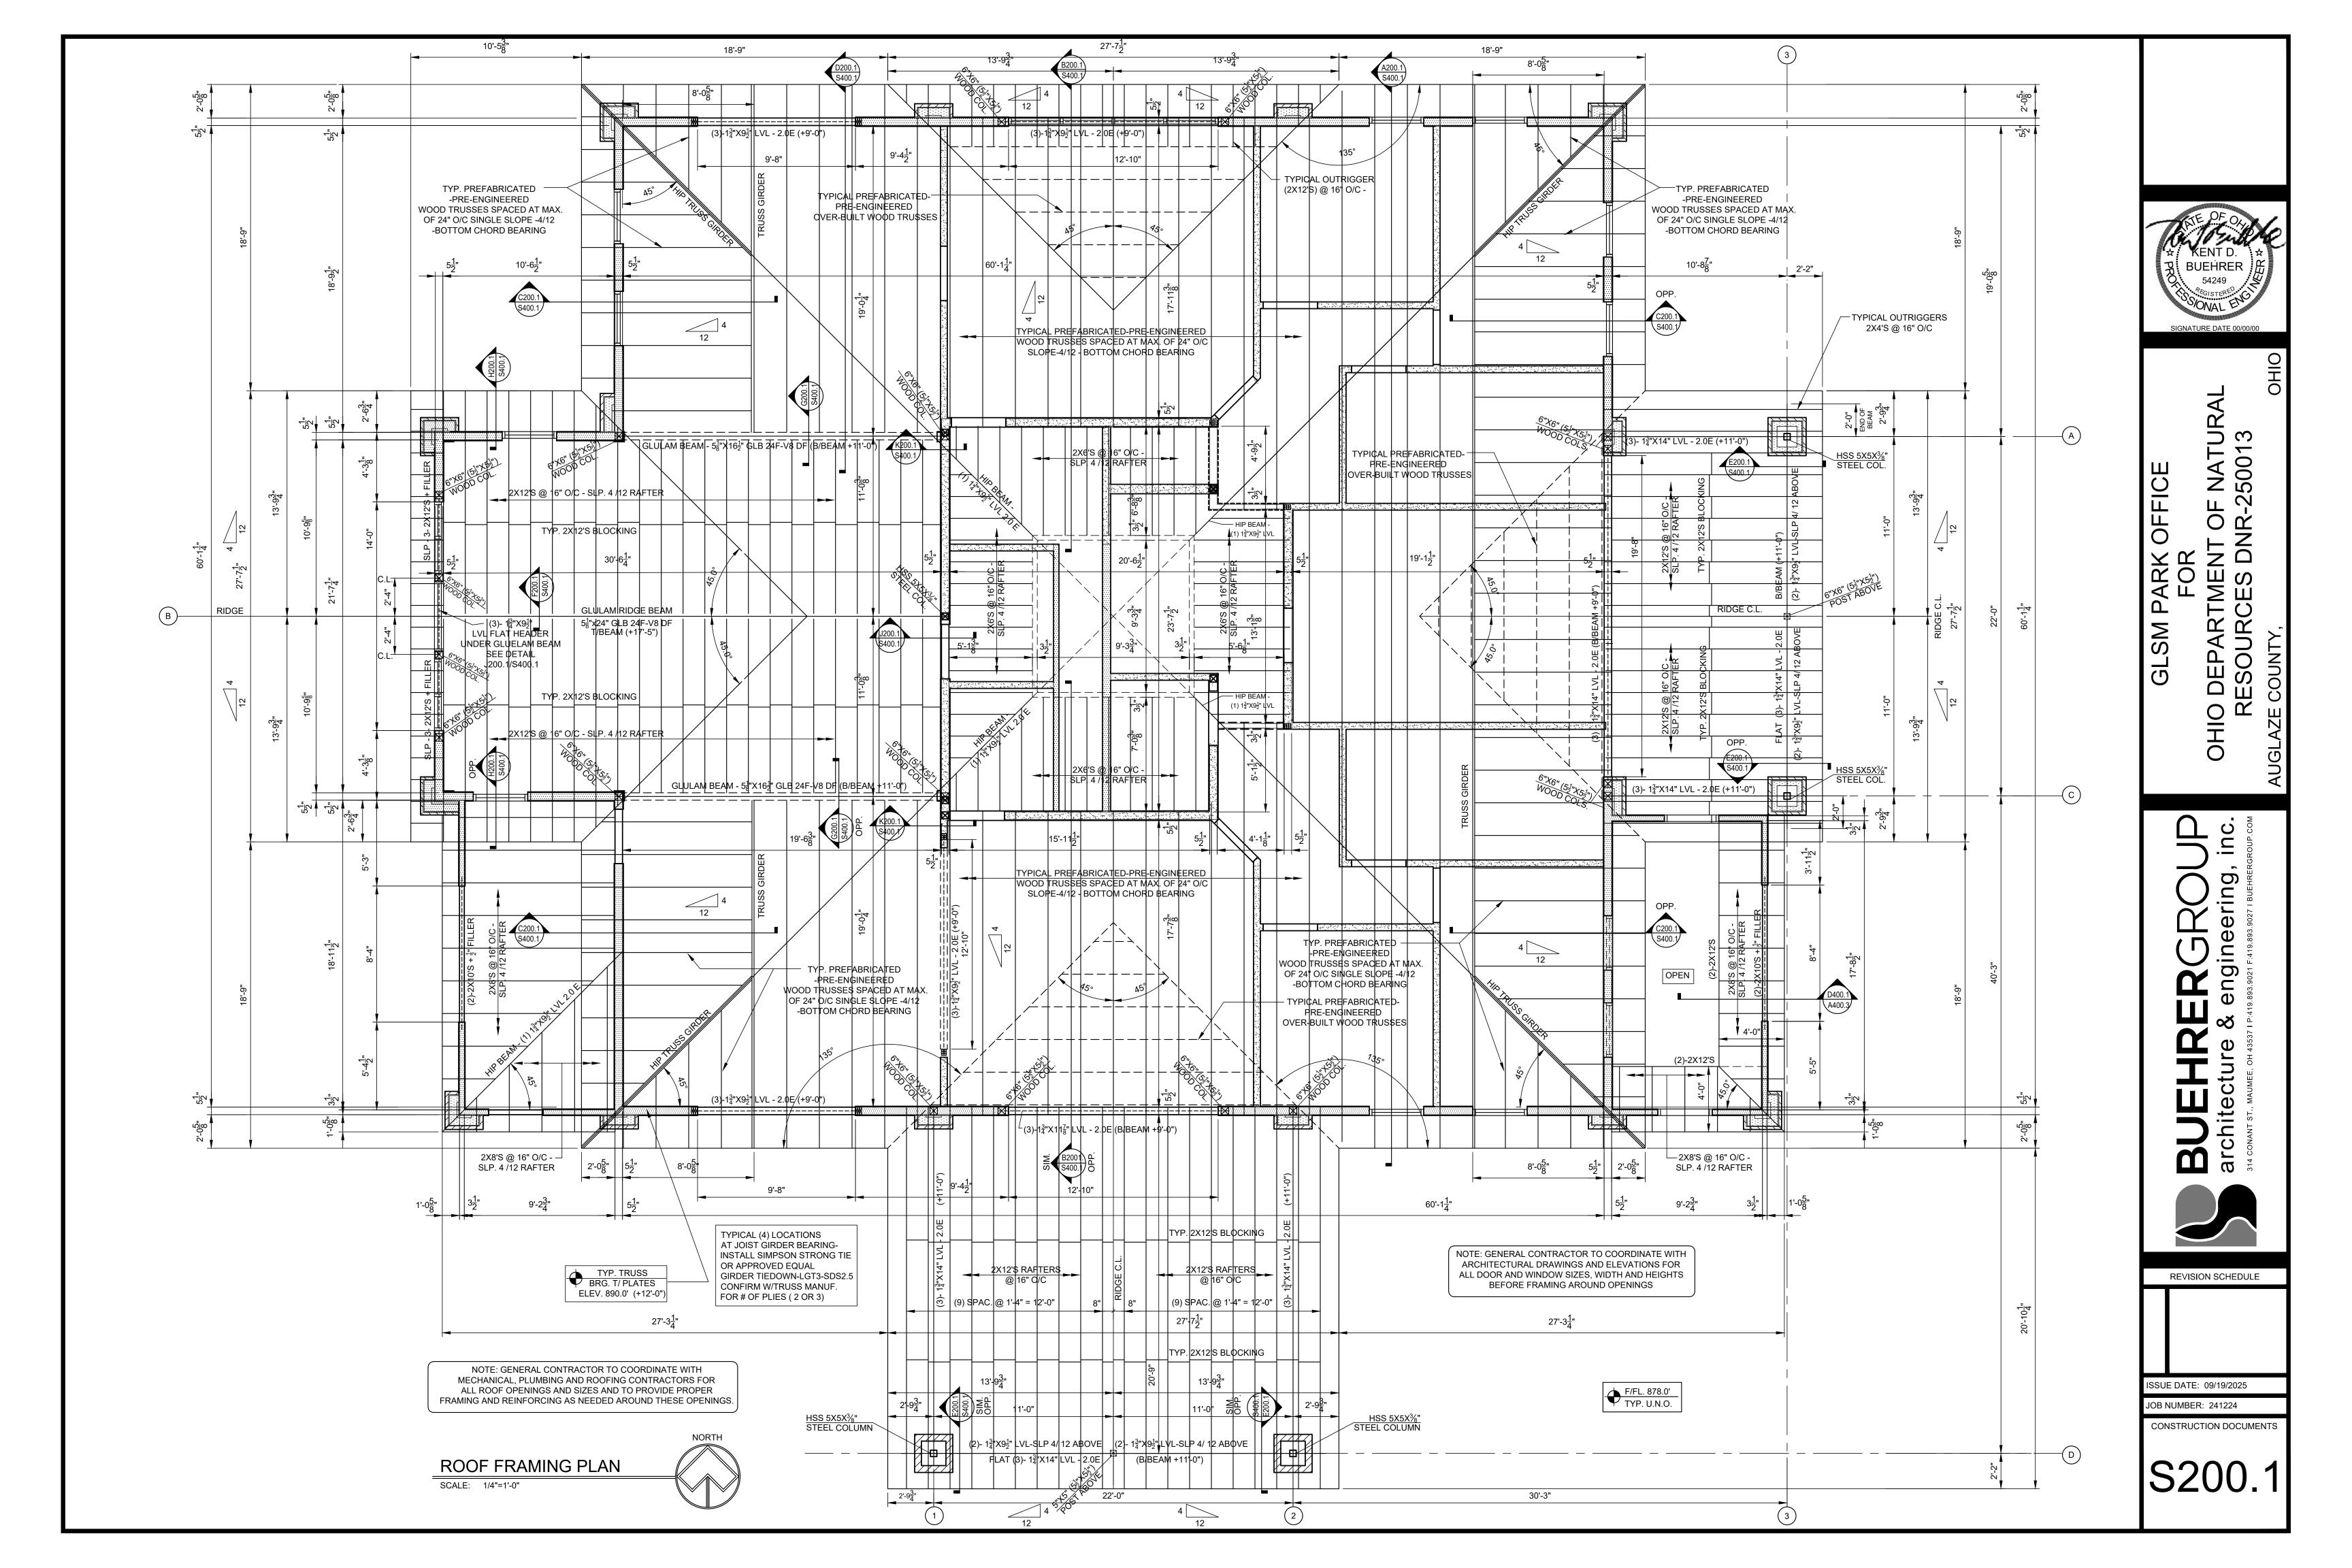

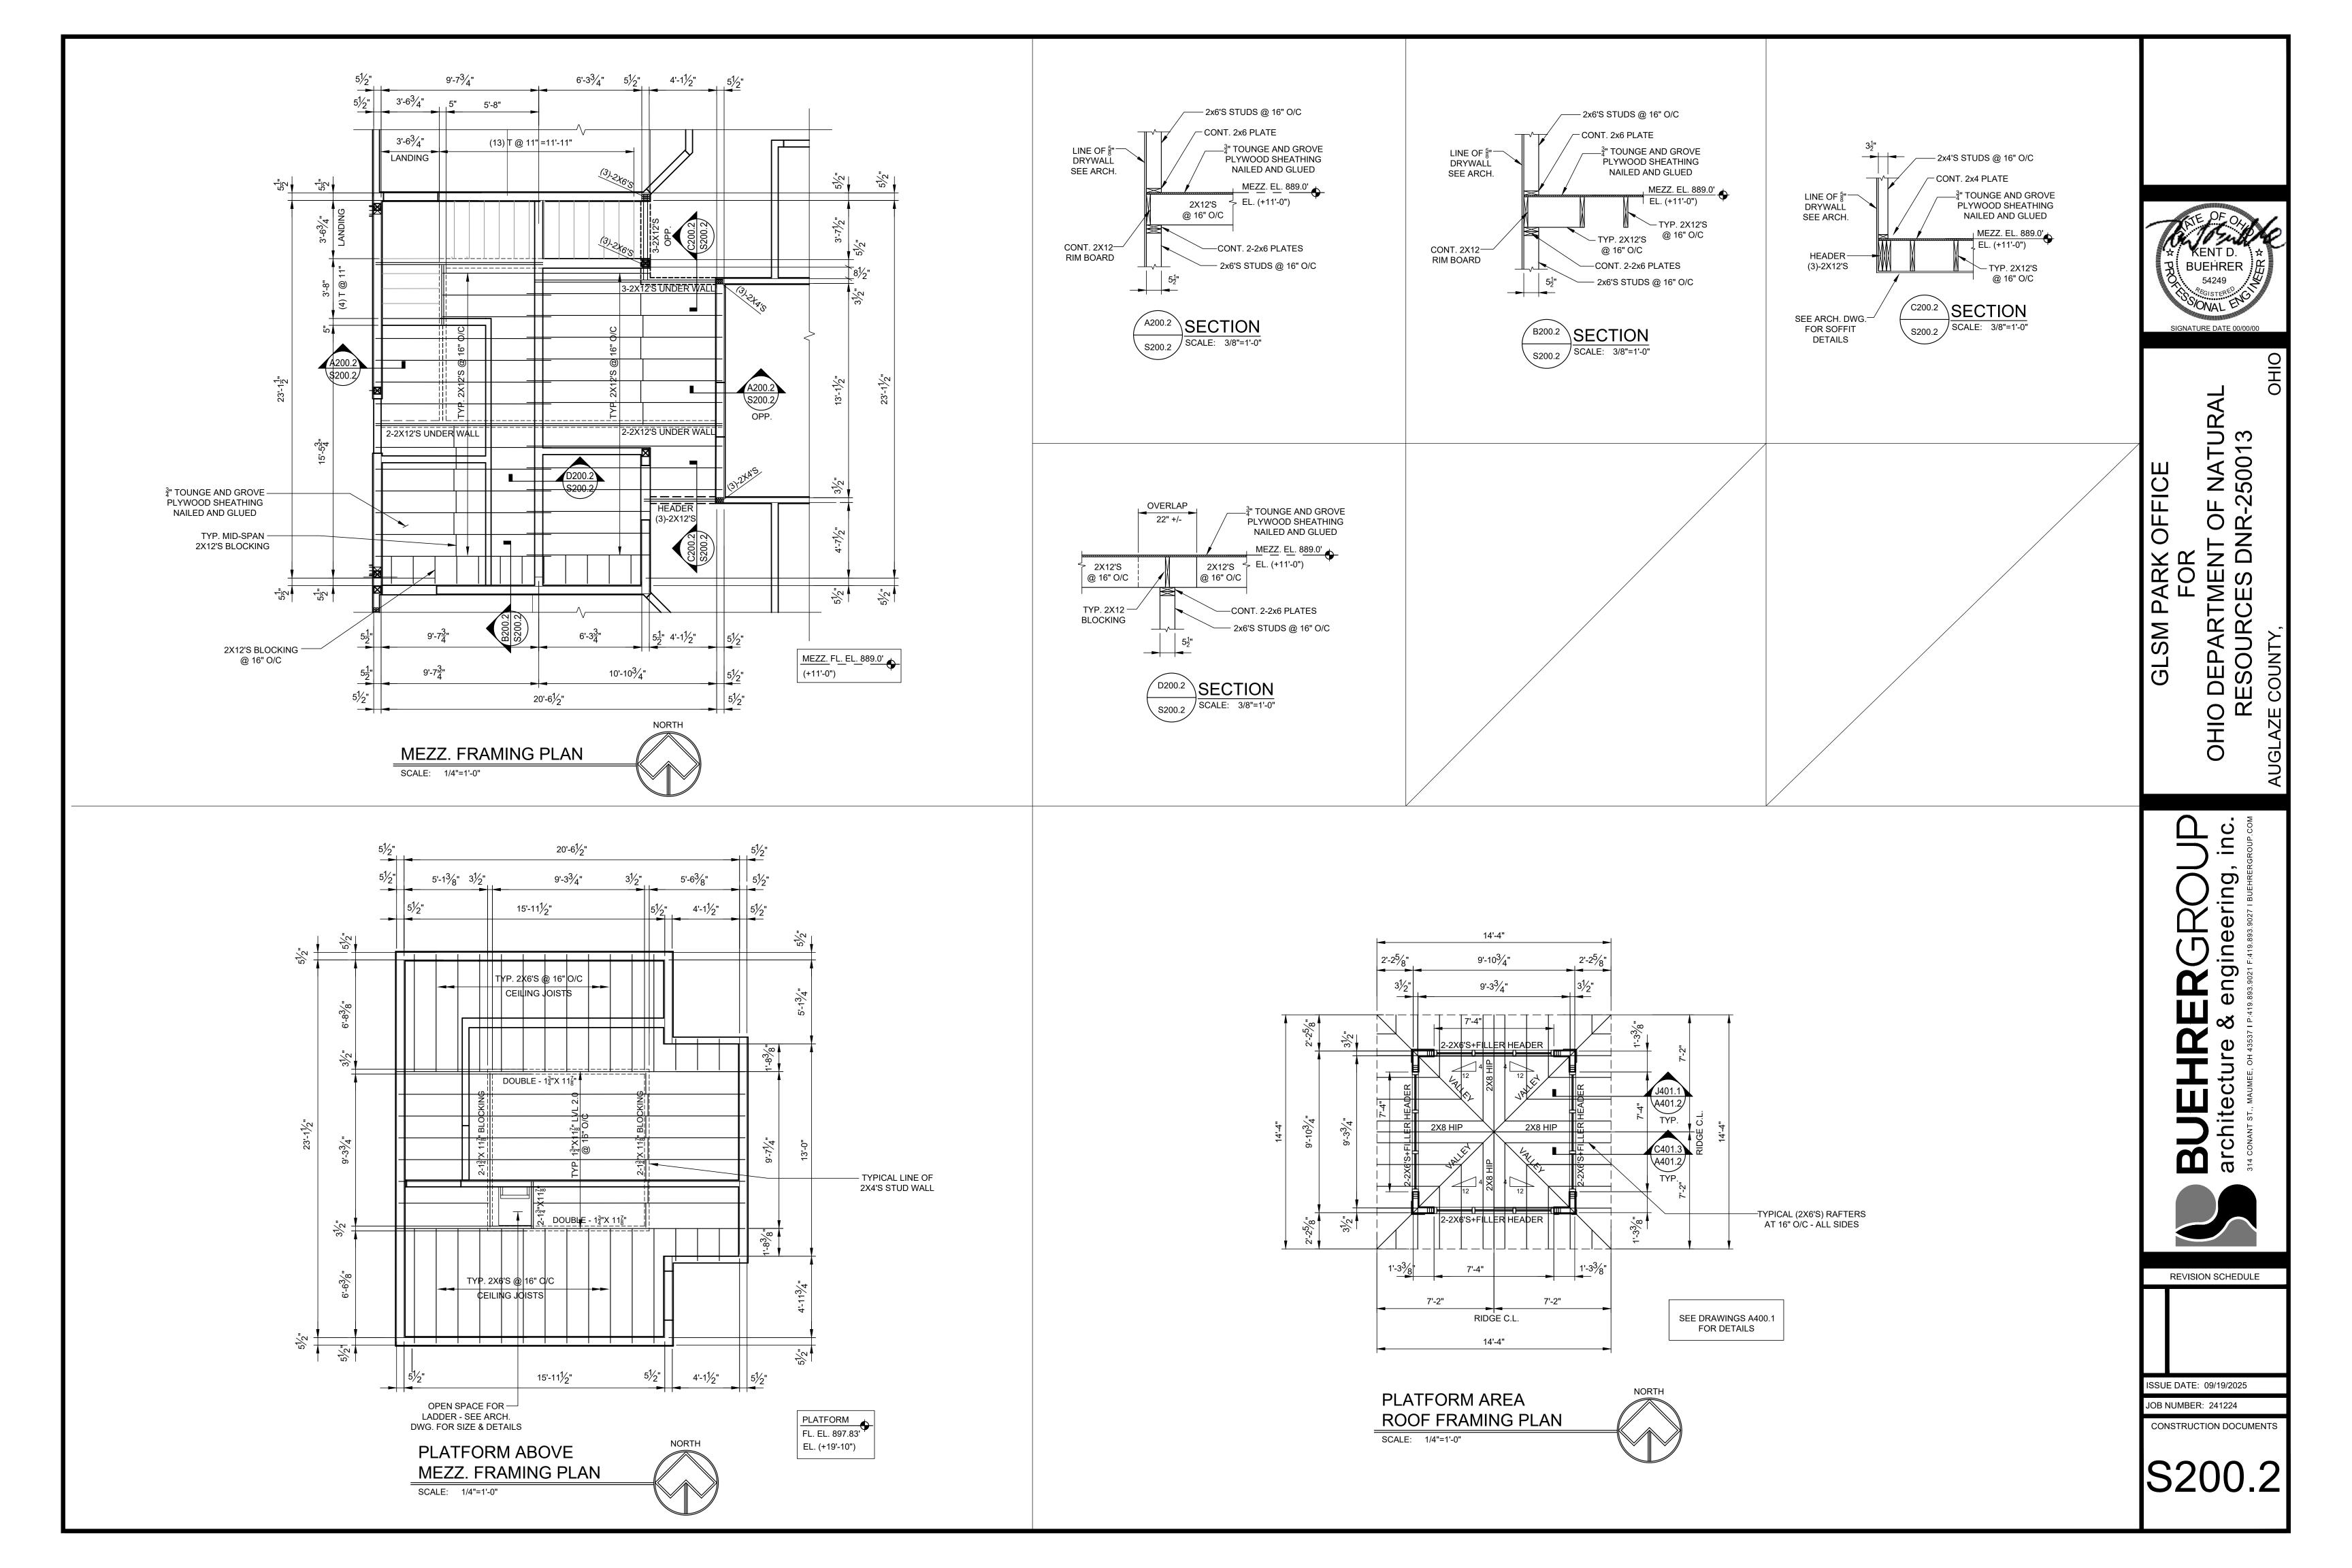

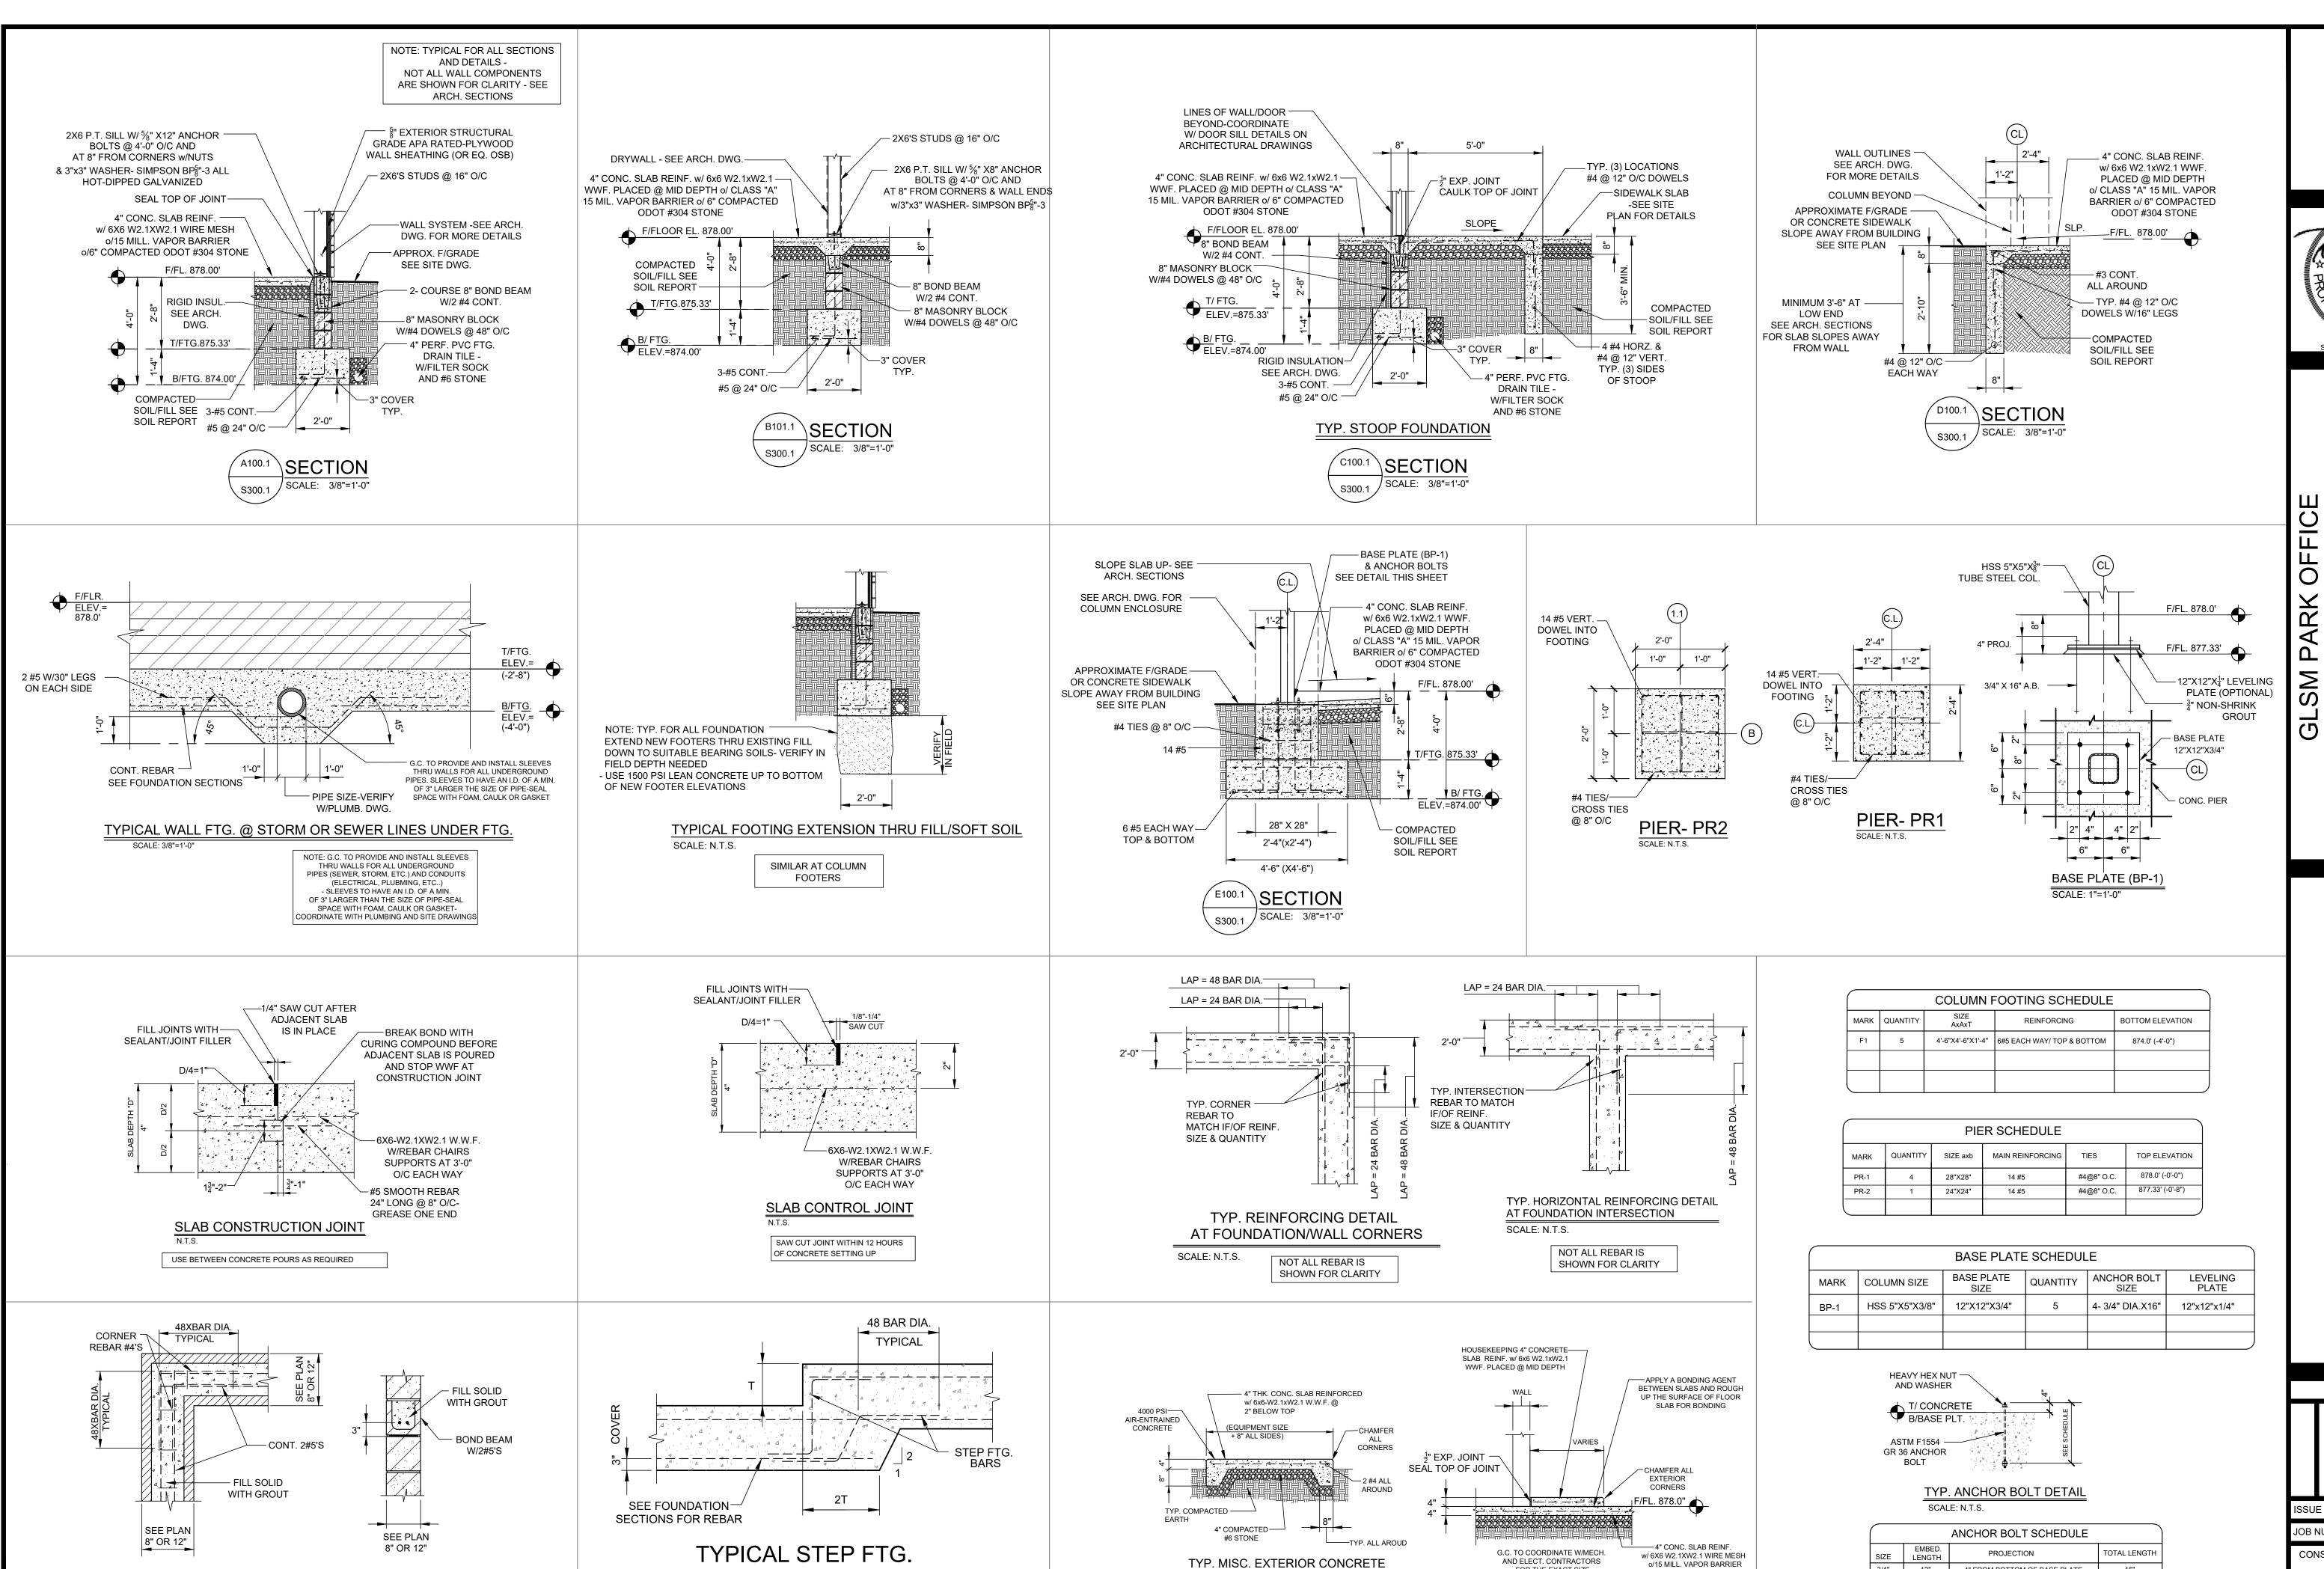

EQUIP. SUPPORT PAD

(VERIFY SIZES, LOCATIONS WITH MECHANICAL &

ELECTRICAL CONTRACTORS)

PLAN @ CORNER

SECTION

TYPICAL MASONRY FOUNDATION BOND

BEAM REINFORCING DETAILS

SCALE: NONE

NOT ALL REBAR IS

SHOWN FOR CLARITY

FOR THE EXACT SIZE

AND LOCATION OF PADS

TYPICAL INTERIOR HOUSEKEEPING

CONCRETE PAD DETAIL

SCALE: N.T.S.

o/6" COMPACTED

ODOT #304 STONE

12"

4" FROM BOTTOM OF BASE PLATE

- ALL ANCHOR BOLTS, NUTS, WASHERS TO BE HOT DIPPED GALVANIZED

- ALL ANCHOR BOLTS TO MEET OR EXCEED ASTM F1554 GR36

- ALL ANCHOR BOLTS TO HAVE HEAVY HEX NUTS & WASHERS

16"

SIGNATURE DATE 00/00/00 0


D (I)


ISSUE DATE: 09/19/2025

JOB NUMBER: 241224

CONSTRUCTION DOCUMENTS

S300.

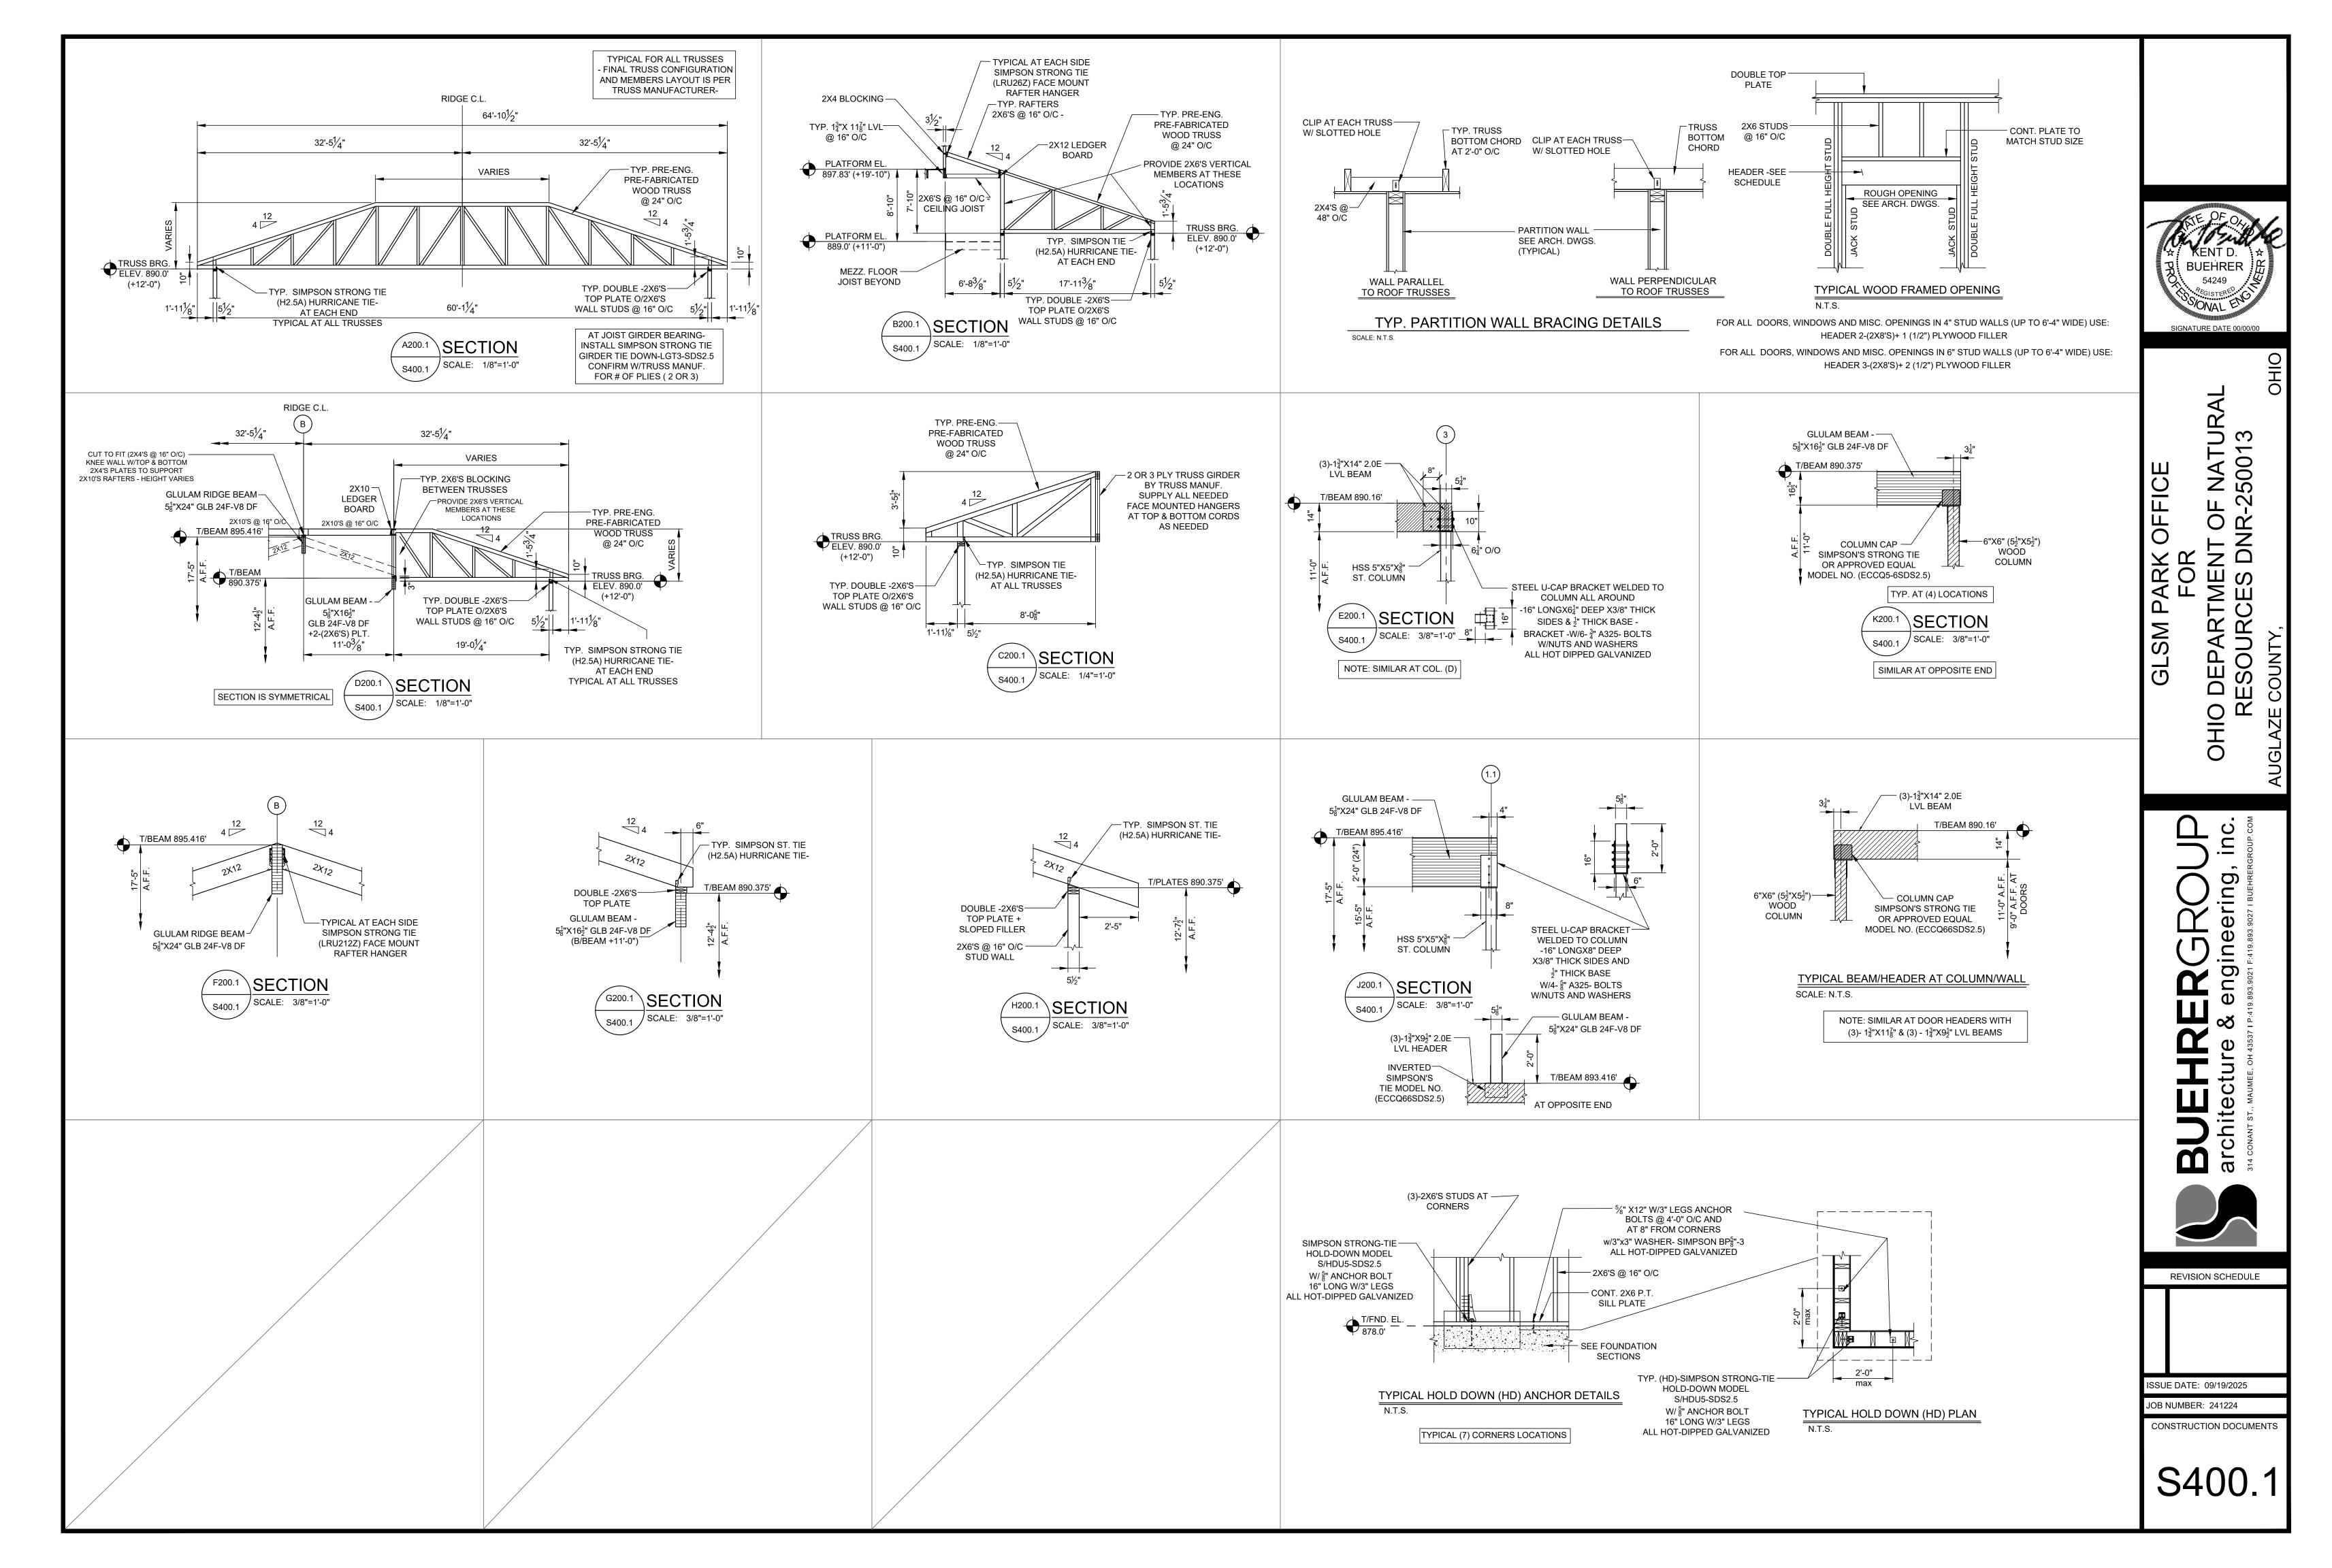

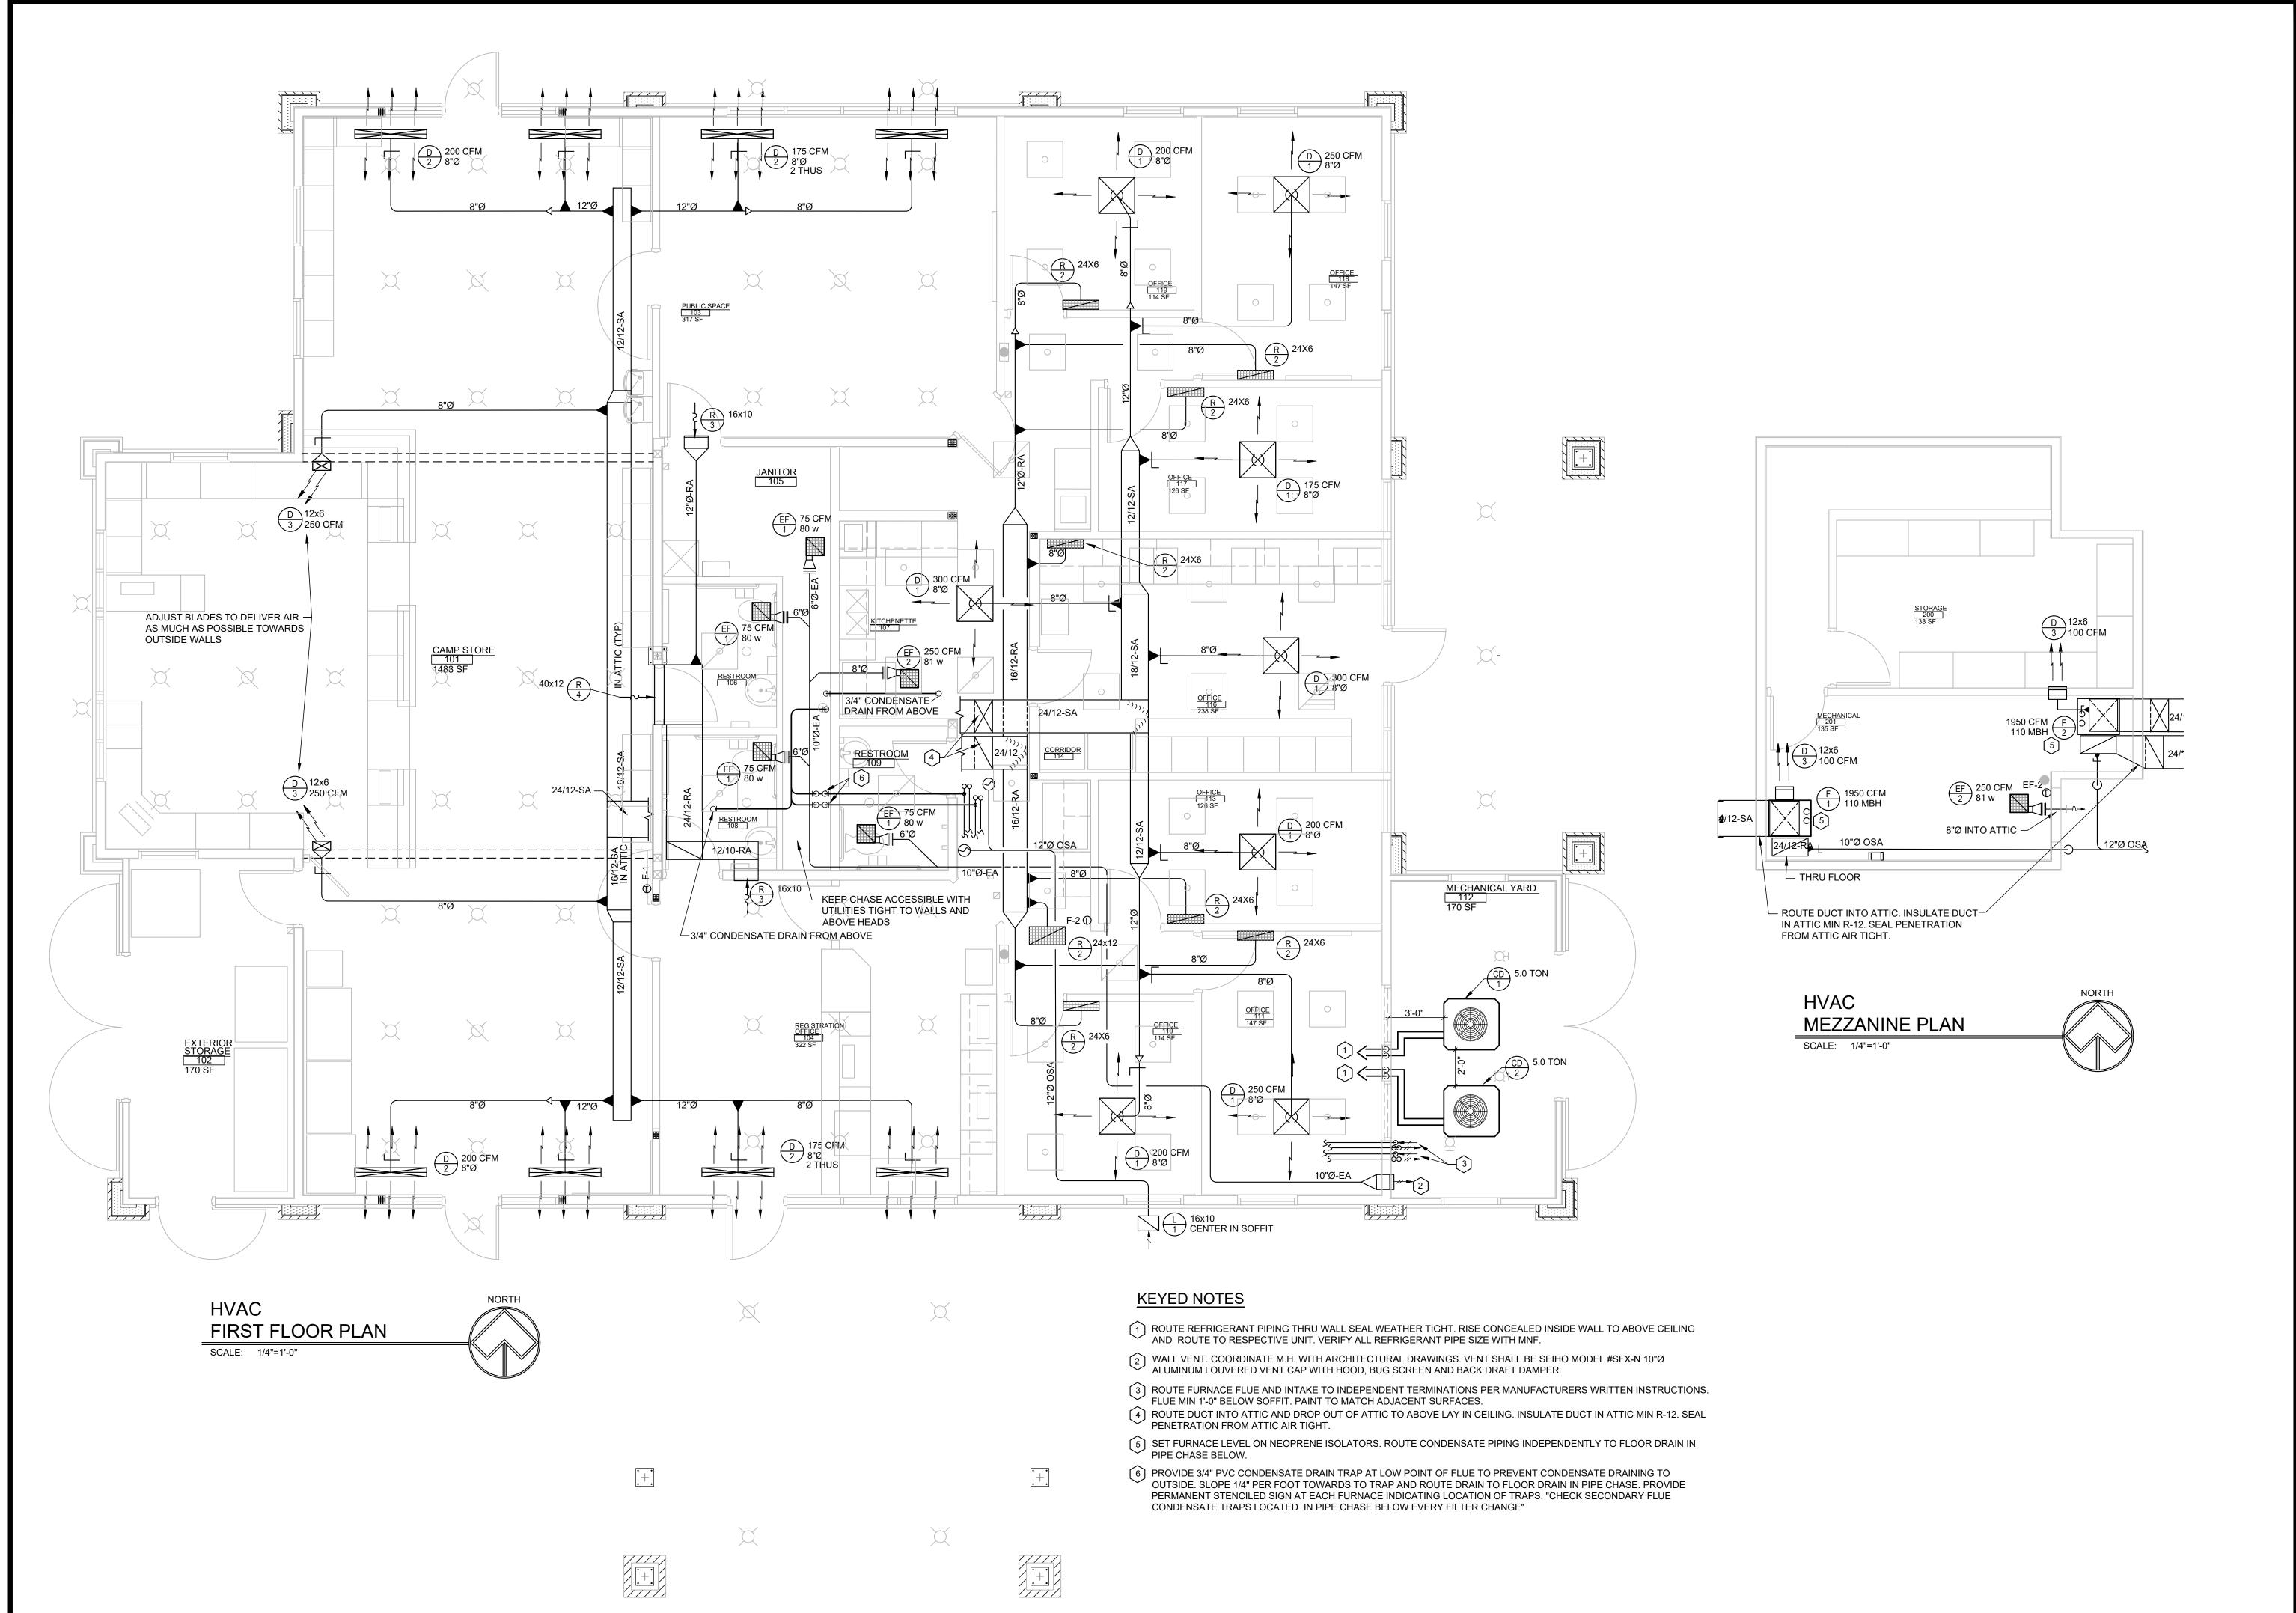

GLSM PARK OFFICE FOR O DEPARTMENT OF NATURAL RESOURCES DNR-250013

ering



ISSUE DATE: 09/19/2025

JOB NUMBER: 241224

MINIMUM OUTSIDE AIR CA ASHRAE STD. 62.1-2016 CO MULTIPLE ZONE SYSTEM W/O ZONE	OMPLIANCE					
ZONE	F-1	F-2				
OCCUPANCY CATEGORY	RETAIL	OFFICE				
SUPPLY AIR VOLUME	1950 CFM	1950 CFM				
PEOPLE OUTDOOR AIR RATE (CFM/PERSON) (Rp)	7.5 CFM	5.0 CFM				
`AREA OUTDOOR AIR RATE (CFM/SQ. FT.) (Ra)	0.12	0.06				
ARÉA (SQ. FT.) (Az)	2127 SF	1194 SF				
CALCULATED ÓCCUPANCY (NUMBER OF PEOPLE) (Pz)	10 PPL	8 PPL				
ZONE AIR DISTRIBUTION EFFECTIVENESS (Ez)	0.8	0.8				
PEOPLE OUTDOOR AIR (Rp x Ap)	75 CFM	40 CFM				
AREA OUTDOOR AIR (Ra x Az)	255 CFM	72 CFM				
BREATHING ZONE OUTDOOR AIR (Ra+Az)	330 SF	112 CFM				
ZONE OUTDOOR AIR FLOW (Voz)	413 CFM	140 CFM				
\ _ /						

■ BALANCE TO INDICATED CFM AT RESPECTIVE UNIT

		T _	
FLEX CONNECTION —	SA ins ext	~	
		10"Ø OSA	
			AMPER TO OPEN BLOWER ATION
RUN 3/4" CONDENSATE DRAIN LINE — TO NEAREST FLOOR DRAIN ROUTED TO AVOID BEING A TRIPPING HAZARD			NNECTION
12" HIGH R.A. PLENUM. SUPPORT — UNIT WITH LEGS OR PROVIDE MFR. SUPPLIED R.A. BASE.			
SET ON NEOPRENE ISOLATOR PADS _		1.5 RADIUS	
2" HIGH SECONDARY CONDENSATE — DRAIN PAN WITH AND WATER SENSOR T SHUT OFF FURNACE IN THE EVENT		MERV 11 — AIR FILTER	
OF A LEAK	FURNACE DE	<u>ETAIL</u>	

	AIR COOLED CONDENSING UNIT SCHEDULE (DUCANE)														
MARK	MODEL	STAGES	SEER	NOM TONS	ELECT.	MCA	FUSE	OPERATING WEIGHT							
CD-1	4AC16L60P-53	2	15.2	5.0	230V-1Ø	29.6 AMPS	50 AMPS	215 LBS							
CD-2	4AC16L60P-53	2	15.0	5.0	230V-1Ø	29.6 AMPS	50 AMPS	215 LBS							

□ SUPPLY W/ RUBBER ISOLATOR KIT & ANTI SHORT CYCLE TIMER□ R-454B REFRIGERANT

Q EQUAL BY DAIKIN, TRANE or YORK

		<u> </u>			1					
MARK NO.	MAX CFM	STATIC PRESS. (IN H ₂ O)	DAMP.	NECK SIZE	AIR PATTERN	FINISH	THROW (FT)	N.C.	DESCRIPTION PRICE	COMMENTS
D-1	300	.12	-	8"Ø	4-WAY	WHT	12-20	25	SMD 24x24 face	INSULATE BACK OF PAN
D-2	300	.06	-	8"Ø	2-WAY	WHT	8-20	28	TBD4100 - 2 SLOT	48" LONG (2) - SLOT 1" SLOT WIDTH
D-3	350	.06	VOL	12x6	ADJ	WHT	17-32	29	520L	DOUBLE DEFLECTION
R-1	350	.10	-	24x12	-	WHT	-	25	85-TSF	EGG CRATE 45° SIGHT RESISTANT
R-2	500	.10	-	24x6	-		-	25	85-TSF	EGG CRATE 45° SIGHT RESISTANT
R-3	500	.08	-	16x10	-	\	-	25	530L	1/2" SPACING LOUVERED FACE
L-1	600	.04	-	16x12		BY ARCH	-	-	ALUMINUM 635	W/INSECT SCREEN OSA SOFFIT INTAKE
									GREENHECK	

OPERATING I			
WEIGHT	MARK NO.	F-1	F-2
215 LBS			
215 LBS	TYPE	UP FLOW	UP FLOW
210 250	MODEL	97G2E	97G2E
	FUEL	NAT GAS	NAT GAS
	MFG	DUCANE	DUCANE
	APROX WEIGHT	200 LBS	200 LBS
	FAN PERFORMANCE	<u> </u>	
	TYPE	VARIABLE	VARIABLE
ENTS	CFM@0.5 wg	1950 CFM	1950 CFM
ENIS	E.S.P.	0.50	0.50
ACK OF PAN	MOTOR H.P.	1.0 HP	1.0 HP
	VOLTAGE	115-1Ø	115-1Ø
) - SLOT IDTH	FLA	10.9 AMPS	10.9 AMPS
	COOLING COILS		
EFLECTION	CAPACITY@AHRI	52.5 MBH	52.5 MBH
	COIL	MATCH TO CD	MATCH TO CD
	HEAT EXCHANGER STAINLESS STEEL	2-STAGE	2-STAGE
ATE	AFUE	95.0%	95.0%
SISTANT	FLUE/INTAKE	3"Ø	3"Ø
ATE	TEMP RISE	44°F	44°F
SISTANT	INPUT MBH	110/72 MBH	110/72 MBH
CING	OUTPUT MBH	108/71 MBH	108/71 MBH
FACE CREEN	MISC.		
INTAKE	FILTERS		
		MERV 8	MERV 8
	FLUE /INTAKE	CONCENTRIC	CONCENTRIC
	THERMOSTAT	TOUCH SCREEN 4H/2C DEHUMID	TOUCH SCREEN 4H/2C DEHUMID
	MIN OSA	PER OSA SCHEDULE	PER OSA SCHEDULE


FURNACE SCHEDULE


- ASHRAE 2019 COMPLIANT
- SET ON RIBBED OR WAFFLED NEOPRENE PADEQUAL BY DAIKIN, TRANE or YORK

			<u></u>		FAN	SCHEDULE				
MARK NO.	CFM	S.P. (IN H ₂ O)	HP	ELECT.	DAMPER	DESCRIPTION GREENHECK	INLET SONES	COMMENTS		
EF-1	75	.250	12w	115-1Ø	BDD	SP-B110	1.5	TIED TO OCC SENSOR IN SPACE		
F-2	250	.250	83w	115-1Ø	BDD	SP-A250	2.5	(1) LINE VOLTAGE THERMOSTAT		

☐ EQUAL BY ACME, PENN OR COOK

HVAC DUCTWORK INSULATION SCHEDULE											
AREA AND SERVICE	INSULATION TYPE	THICKNESS	MIN R-VALUE								
SA CONCEALED ABOVE CEILING	1-1/2# W/FRK	1-1/2"	R-6								
SA EXPOSED	NONE UNLESS NOTED	-	-								
SA IN RETURN AIR CEILING PLENUM	1-1/2# W/FRK	1-1/2"	R-5								
SA EXPOSED IN MECHANICAL ROOMS	3# RIGID FRK	1-1/2"	R-6								
SA & RA EXPOSED OUTSIDE	3# RIGID ASJ W/ALUMINUM JACKET	3"	R-12								
SA & RA IN VENTILATED ATTICS	1-1/2# W/FRK	4"	R-12								
RELIEF AIR EXPOSED	1-1/2# W/ASJ 6# RIGID FRK	1-1/2"	R-6								
OSA INTAKE EXPOSED	1-1/2# W/ASJ 6# RIGID FRK	1-1/2"	R-6								
EXHAUST AIR WHERE NOTED	1-1/2# W/FRK	1-1/2"	R-6								
RA INTERNAL WHERE NOTED	1-1/2# LINER W/REINFORCED COATING	1"	R-4								

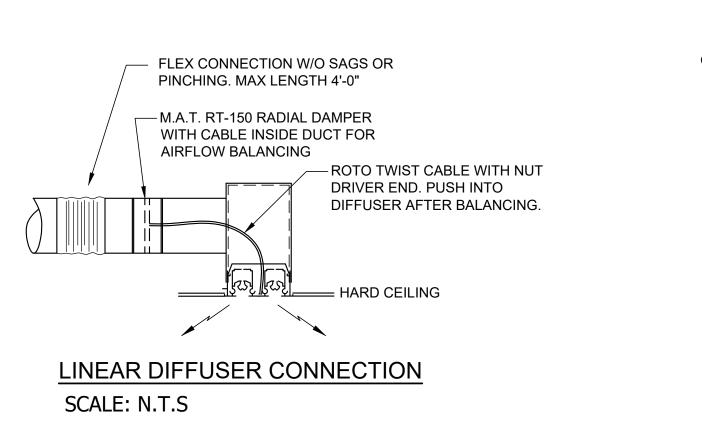

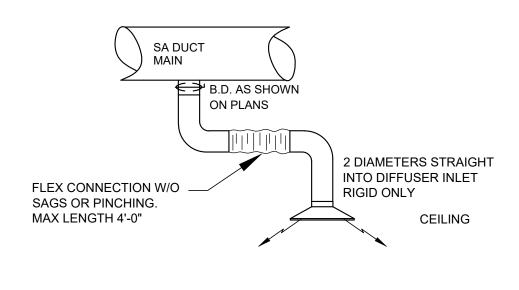

TYPICAL DIFFUSER CONNECTION
NO SCALE

3" THREADED ROD TO STRUCTURE

EA DUCT


EXHAUST

FAN

TYPICAL EXHAUST FAN DETAIL
NO SCALE


ABOVE W/NEOPRENE ISOL -

FLEX CONNECTION -

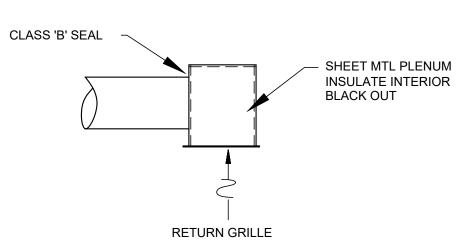

RETURN AIR GRILLE DETAIL
NO SCALE

RECTANGULAR TO ROUND TRANSITION

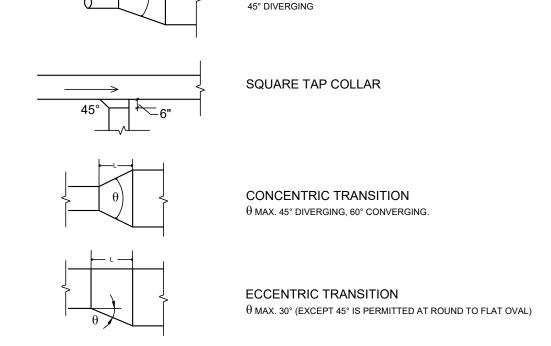

DUCT TRANSITIONS & CONNECTIONS

NO SCALE

LEGEND THERMOSTAT AND DEVICE CONTROLLED F-# 🗇 WITH LOCKING THERMOSTAT GUARD TENNANT IMPROVEMENTS CONTRACTOR MOUNTING HEIGHT TO BOTTOM OF DEVICE RETURN AIR SUPPLY AIR EXHAUST AIR OUT SIDE AIR TRANSFER AIR E.C. ELECTRIC CONTRACTOR RETURN AIR EXHAUST AIR OUTSIDE INTAKE AIR SUPPLY AIR 24/12 DUCT SIZE (WIDTH/HEIGHT) ins int INSULATE INTERIOR OF DUCT ins ext INSULATE EXTERIOR OF DUCT MOTOR OPERATED DAMPER BALANCE DAMPER RETURN/EXH AIR

SUPPLY AIR

DUCT AIR


TURNING VANES

SD FIRE/SMOKE DAMPER

FD 90 MIN FIRE DAMPER

FLEXIBLE CONNECTION

ACCESS DOOR IN DUCT

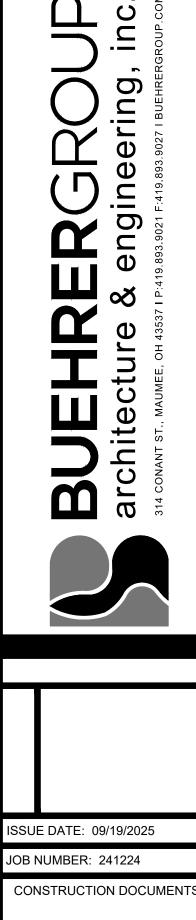


SIGNATURE DATE 00/00/00


FMENT OF I


OFFICE

PARK FOR

GLSM

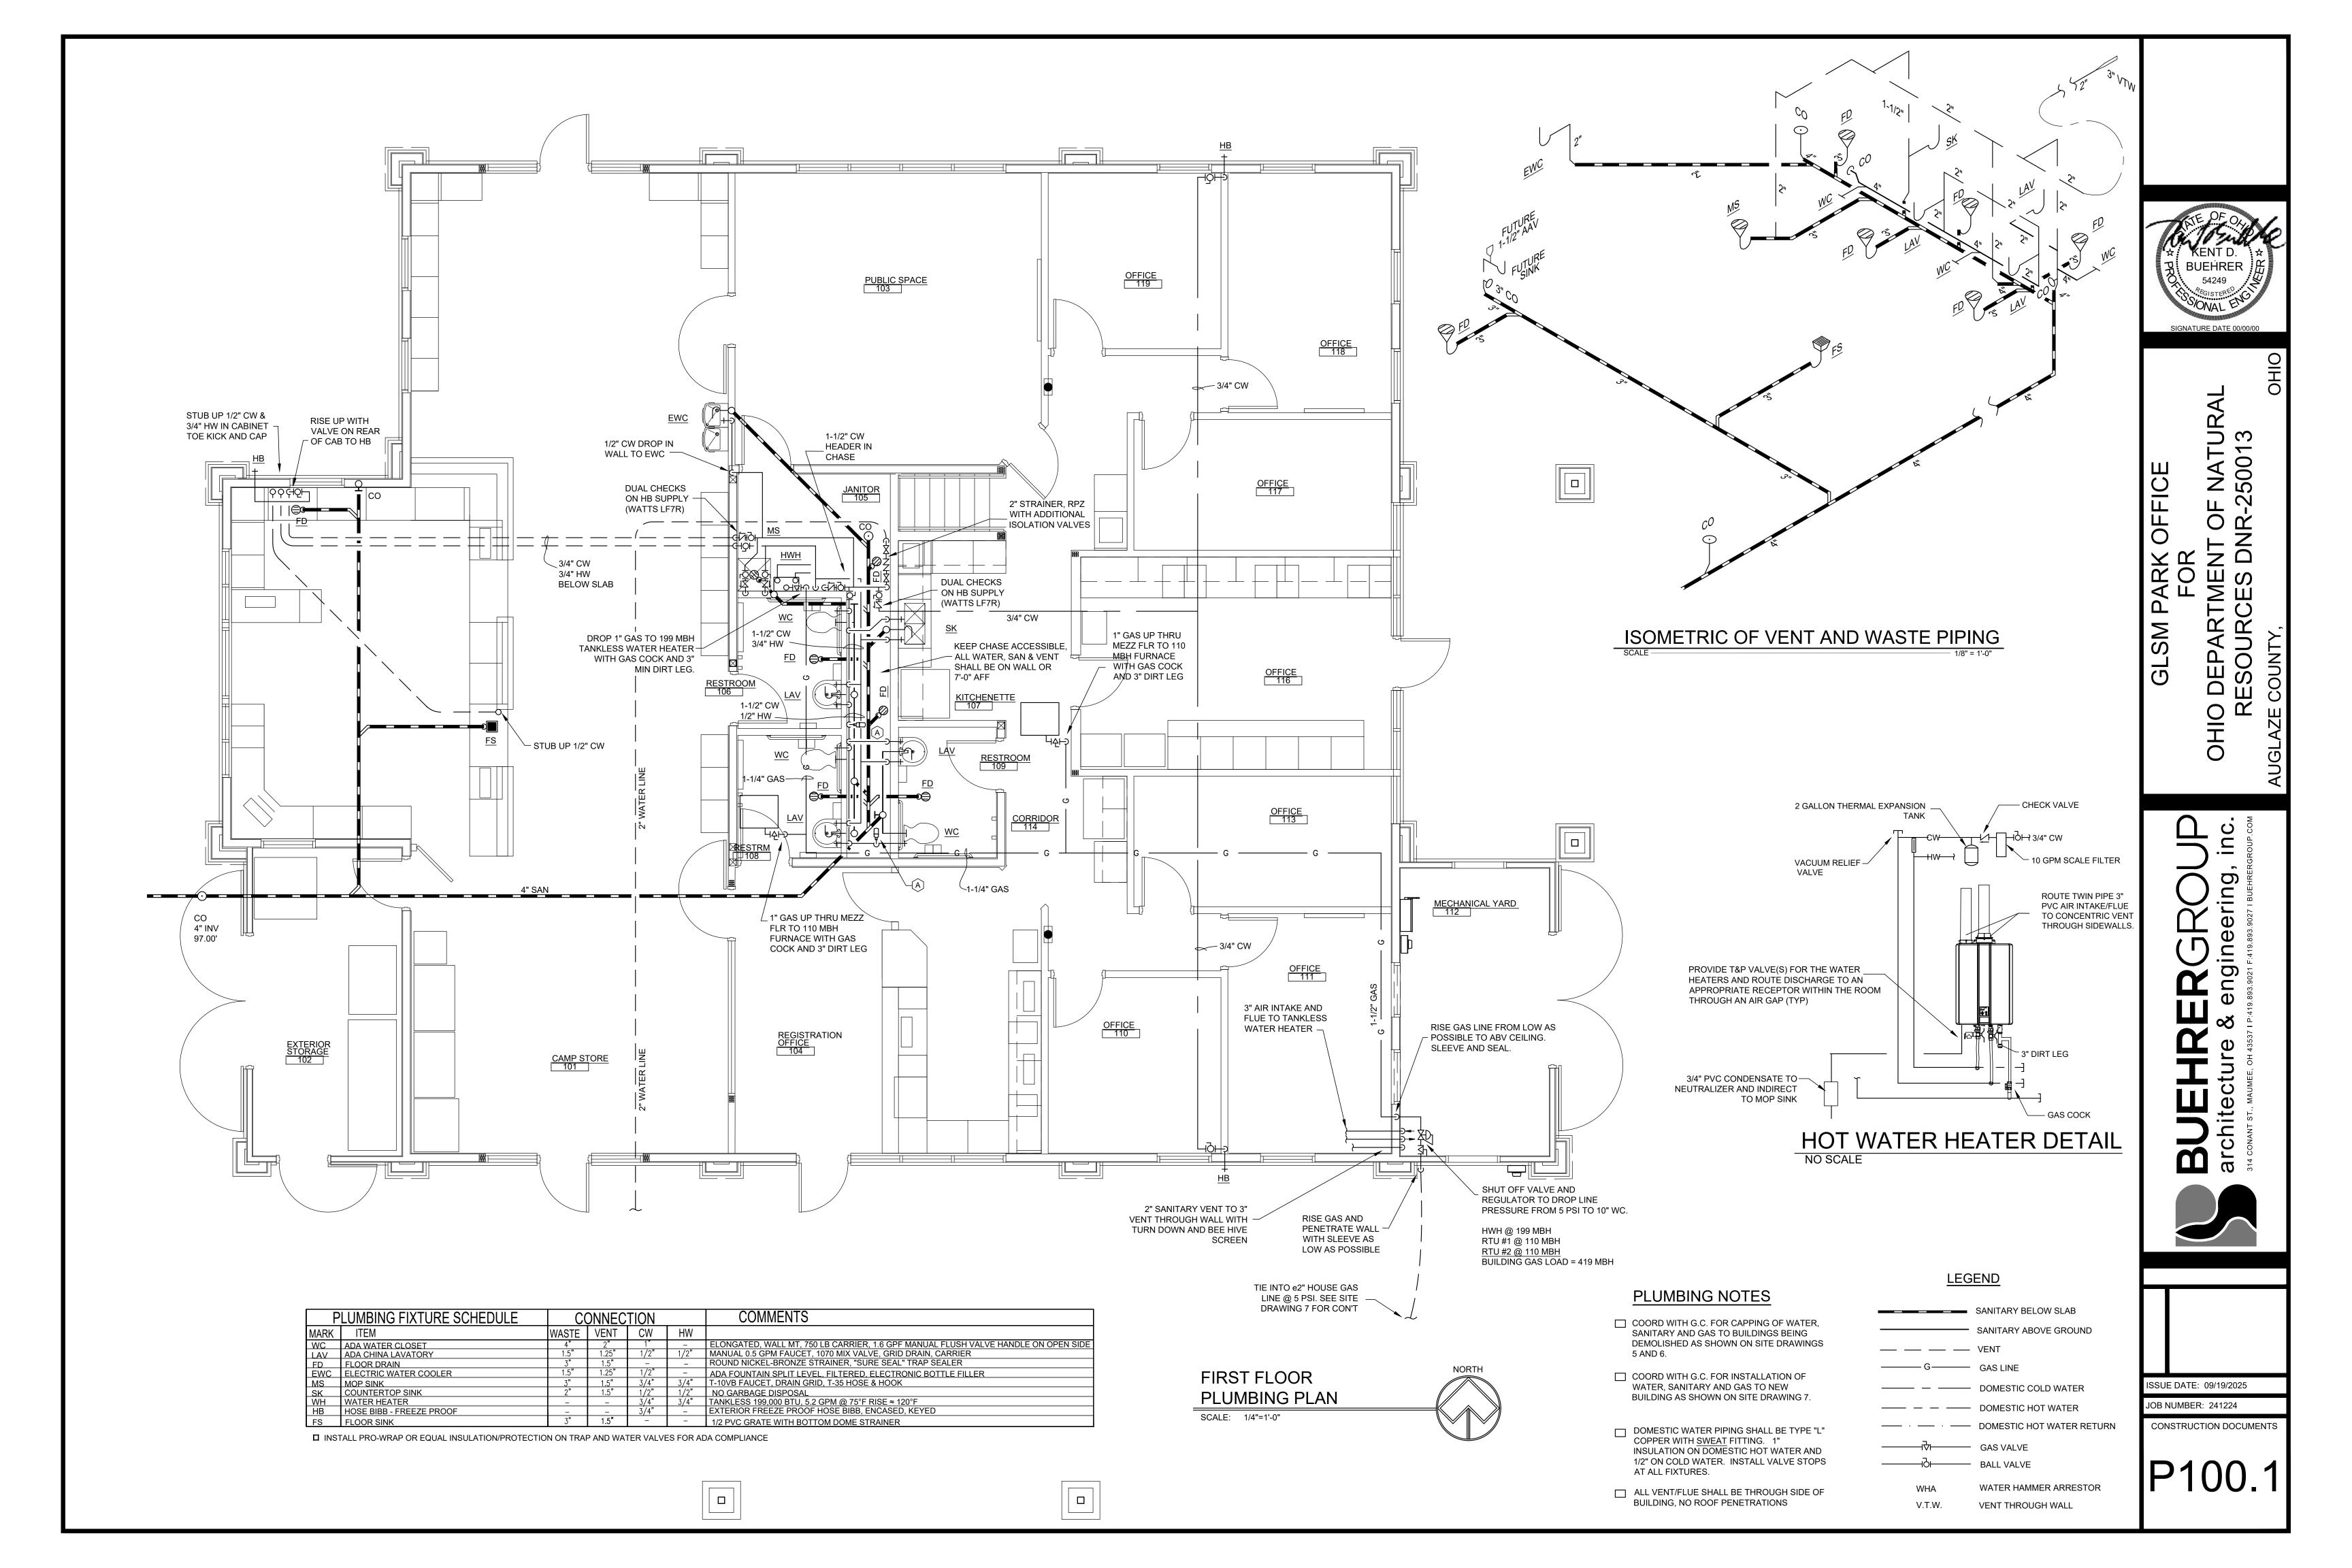

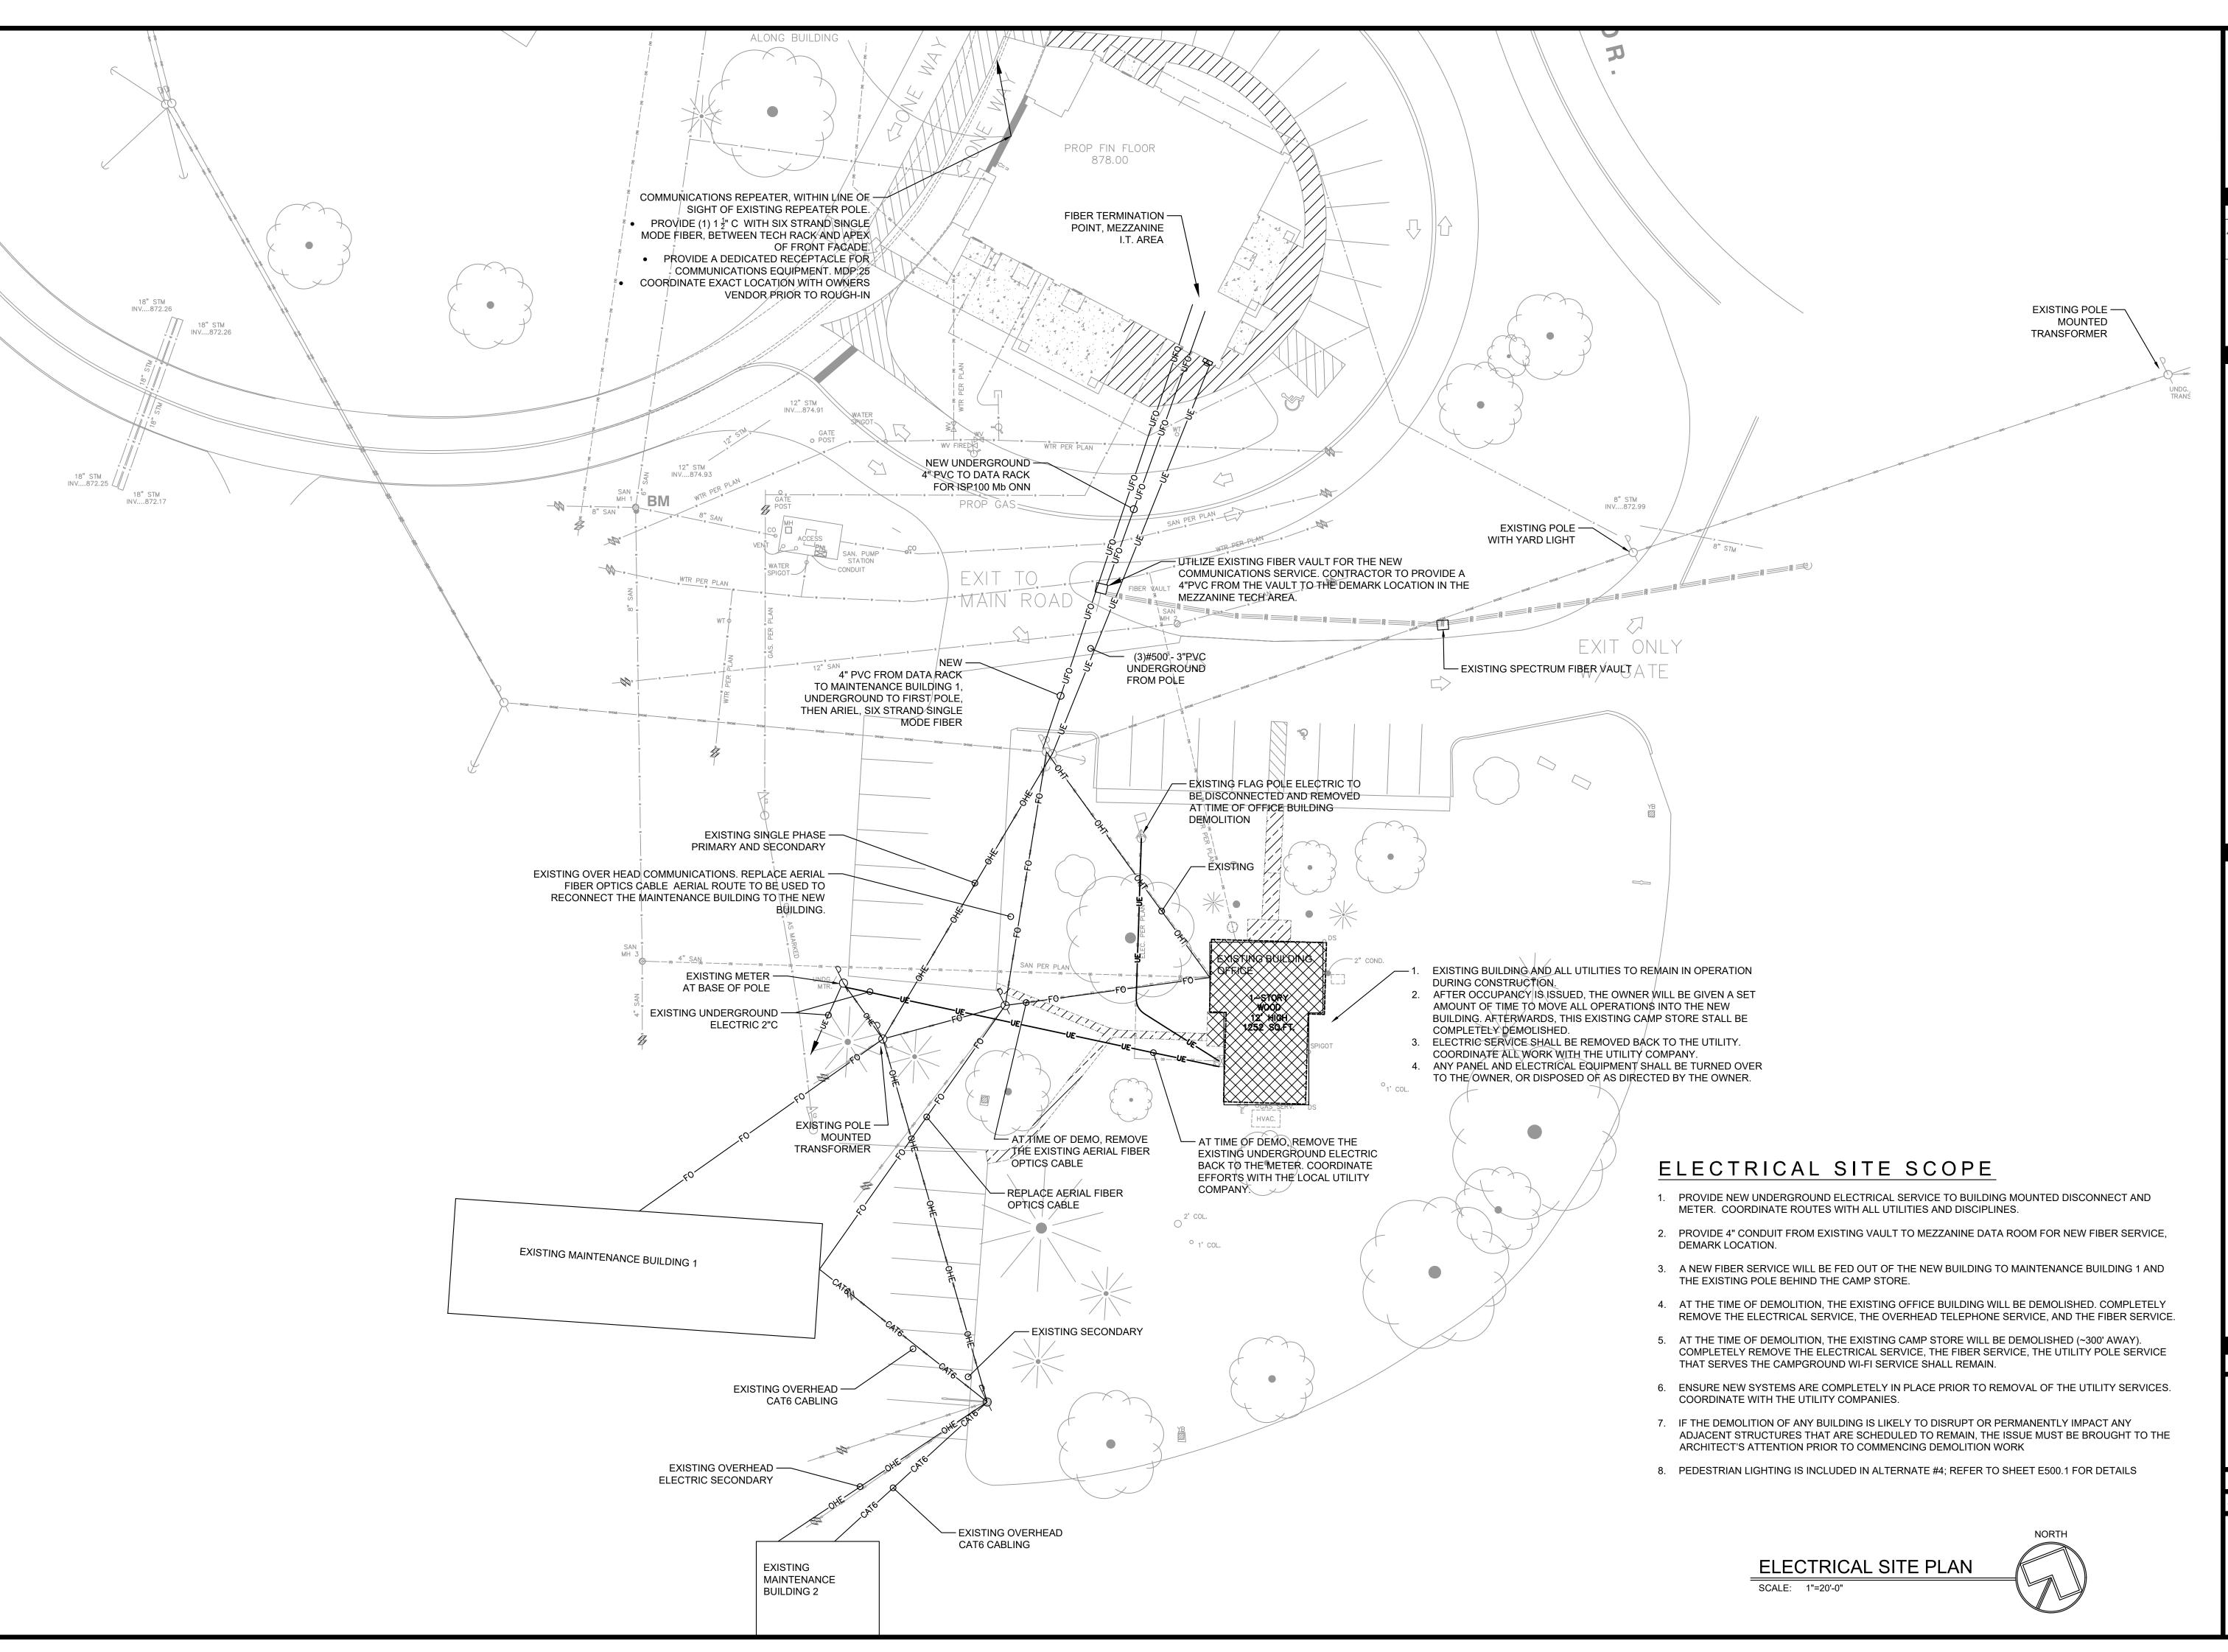

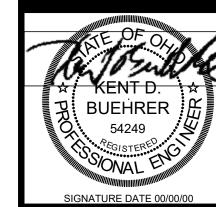

NAT 500 ЩÄ MENT (ES DNF

> C D




SSUE DATE: 09/19/2025

JOB NUMBER: 241224

CONSTRUCTION DOCUMENTS

ESP1

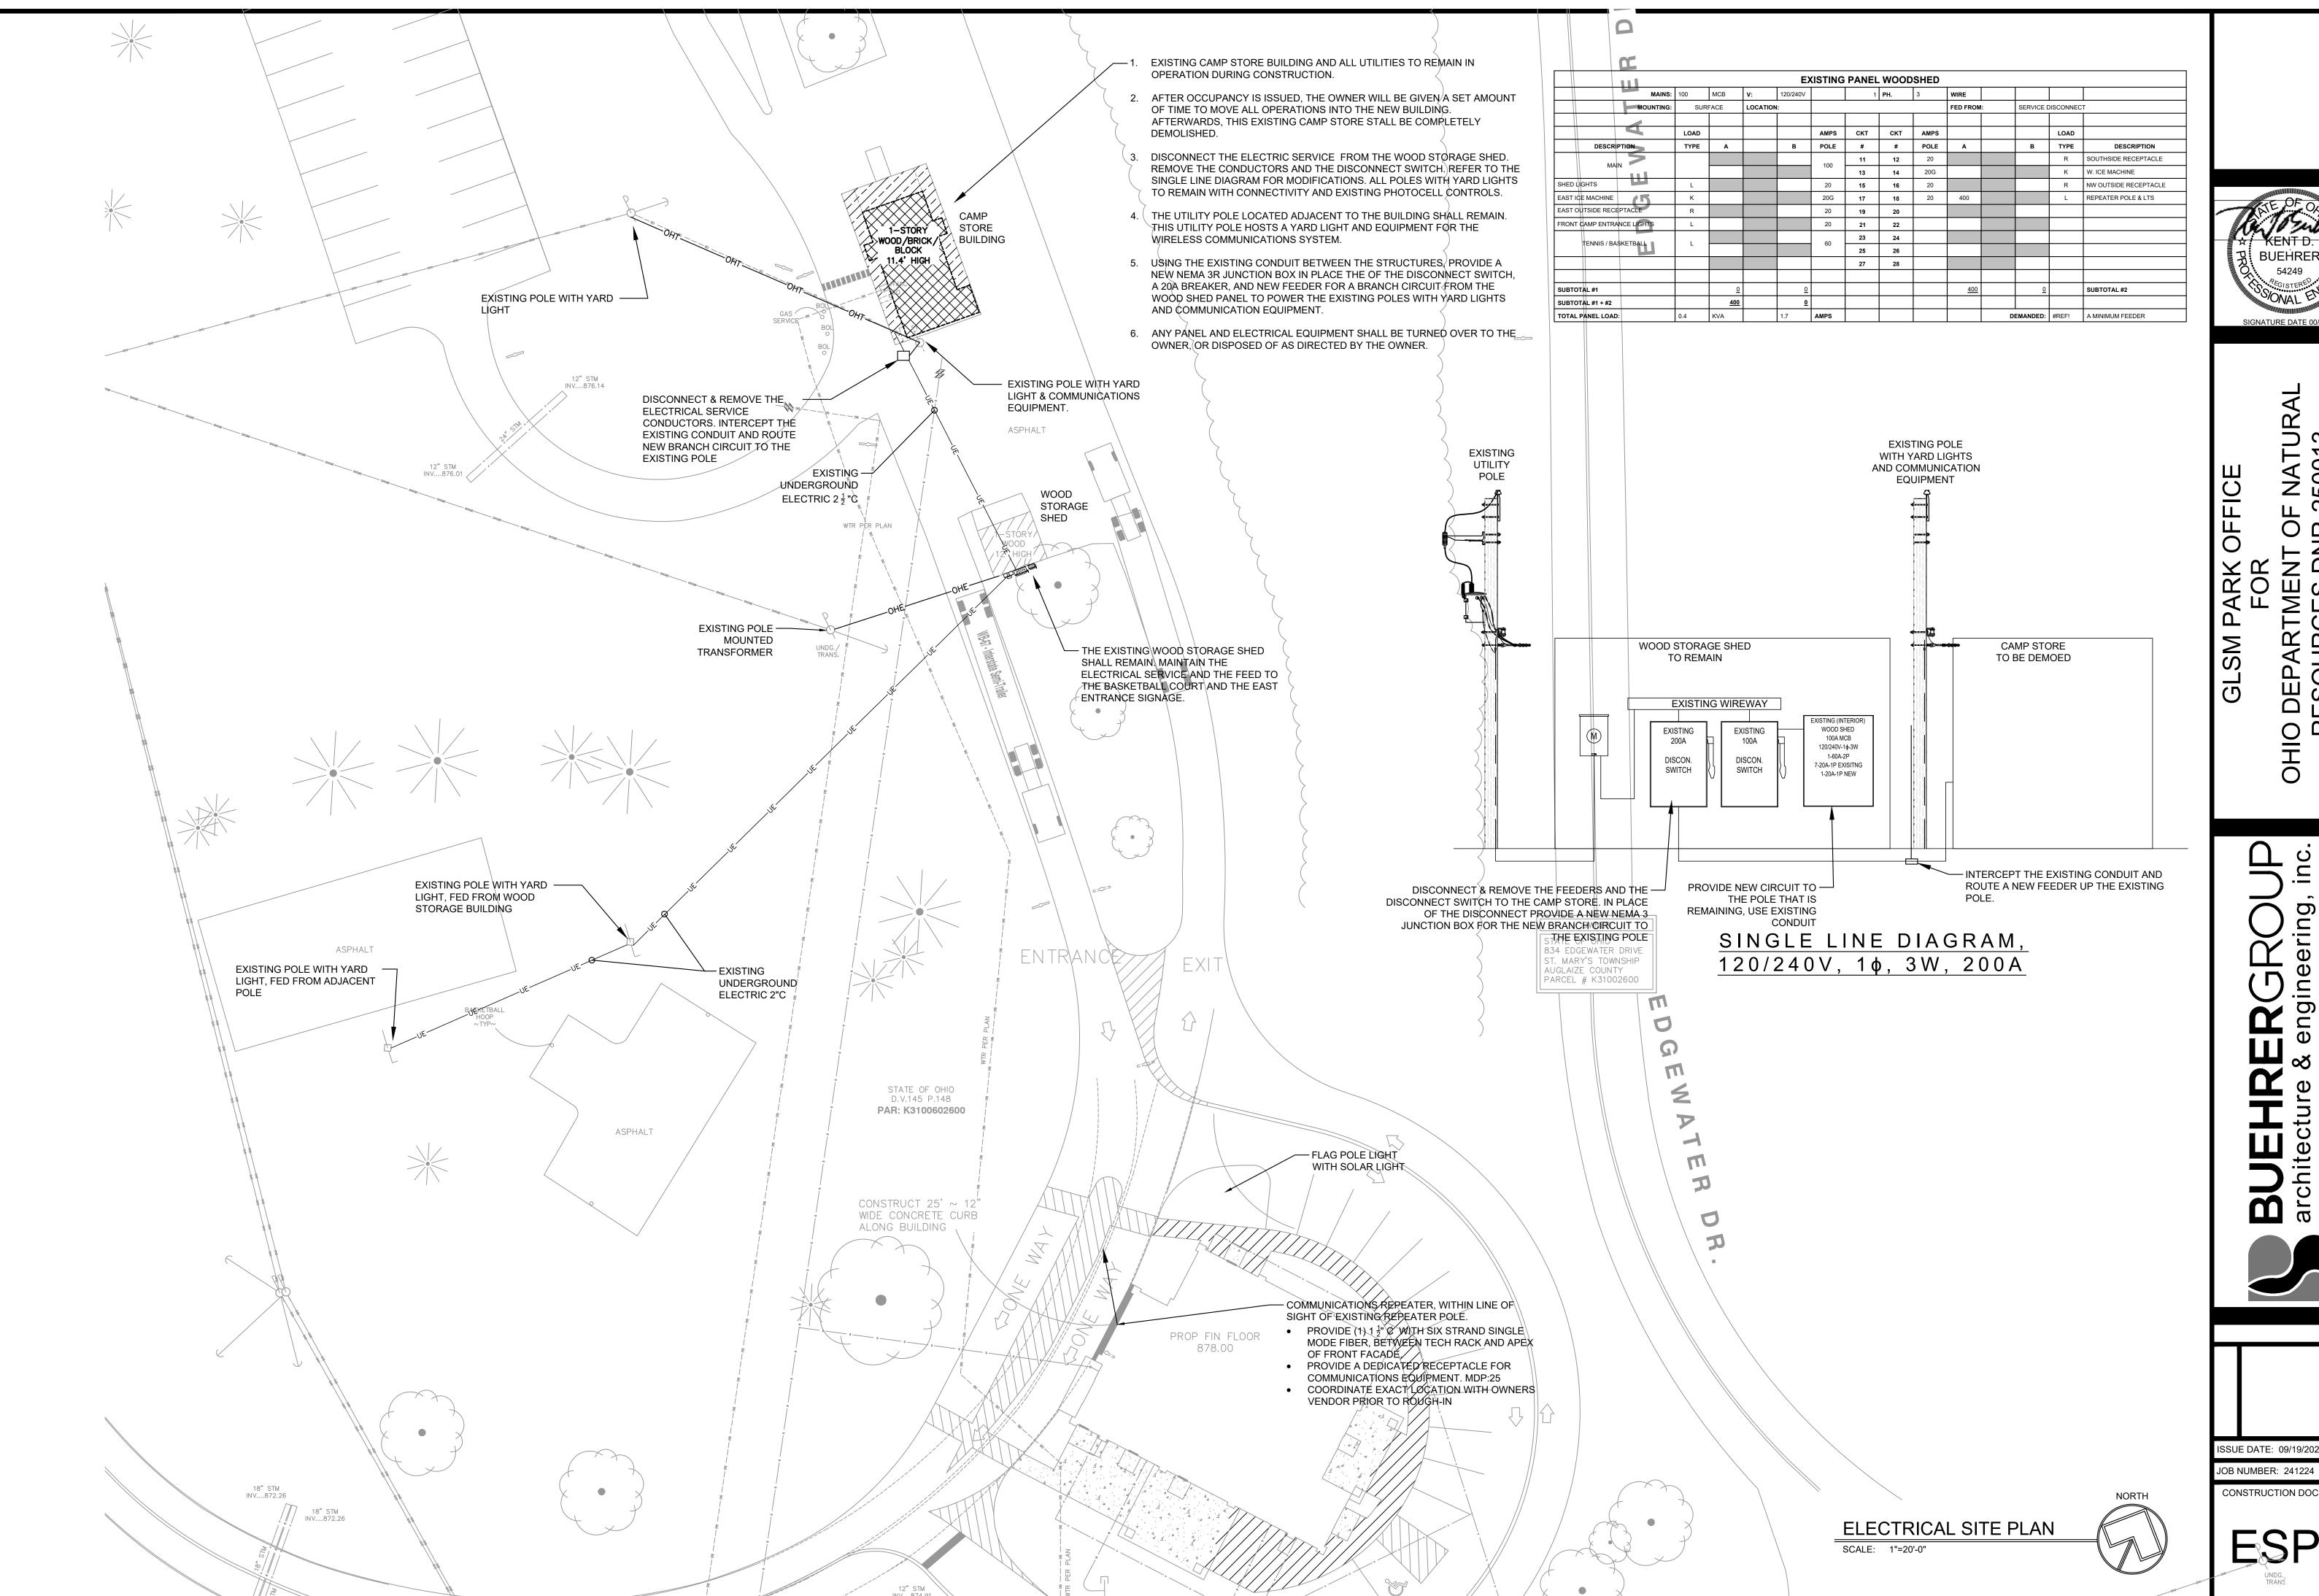


NAT 500 ТŚ

> inc ering



SSUE DATE: 09/19/2025



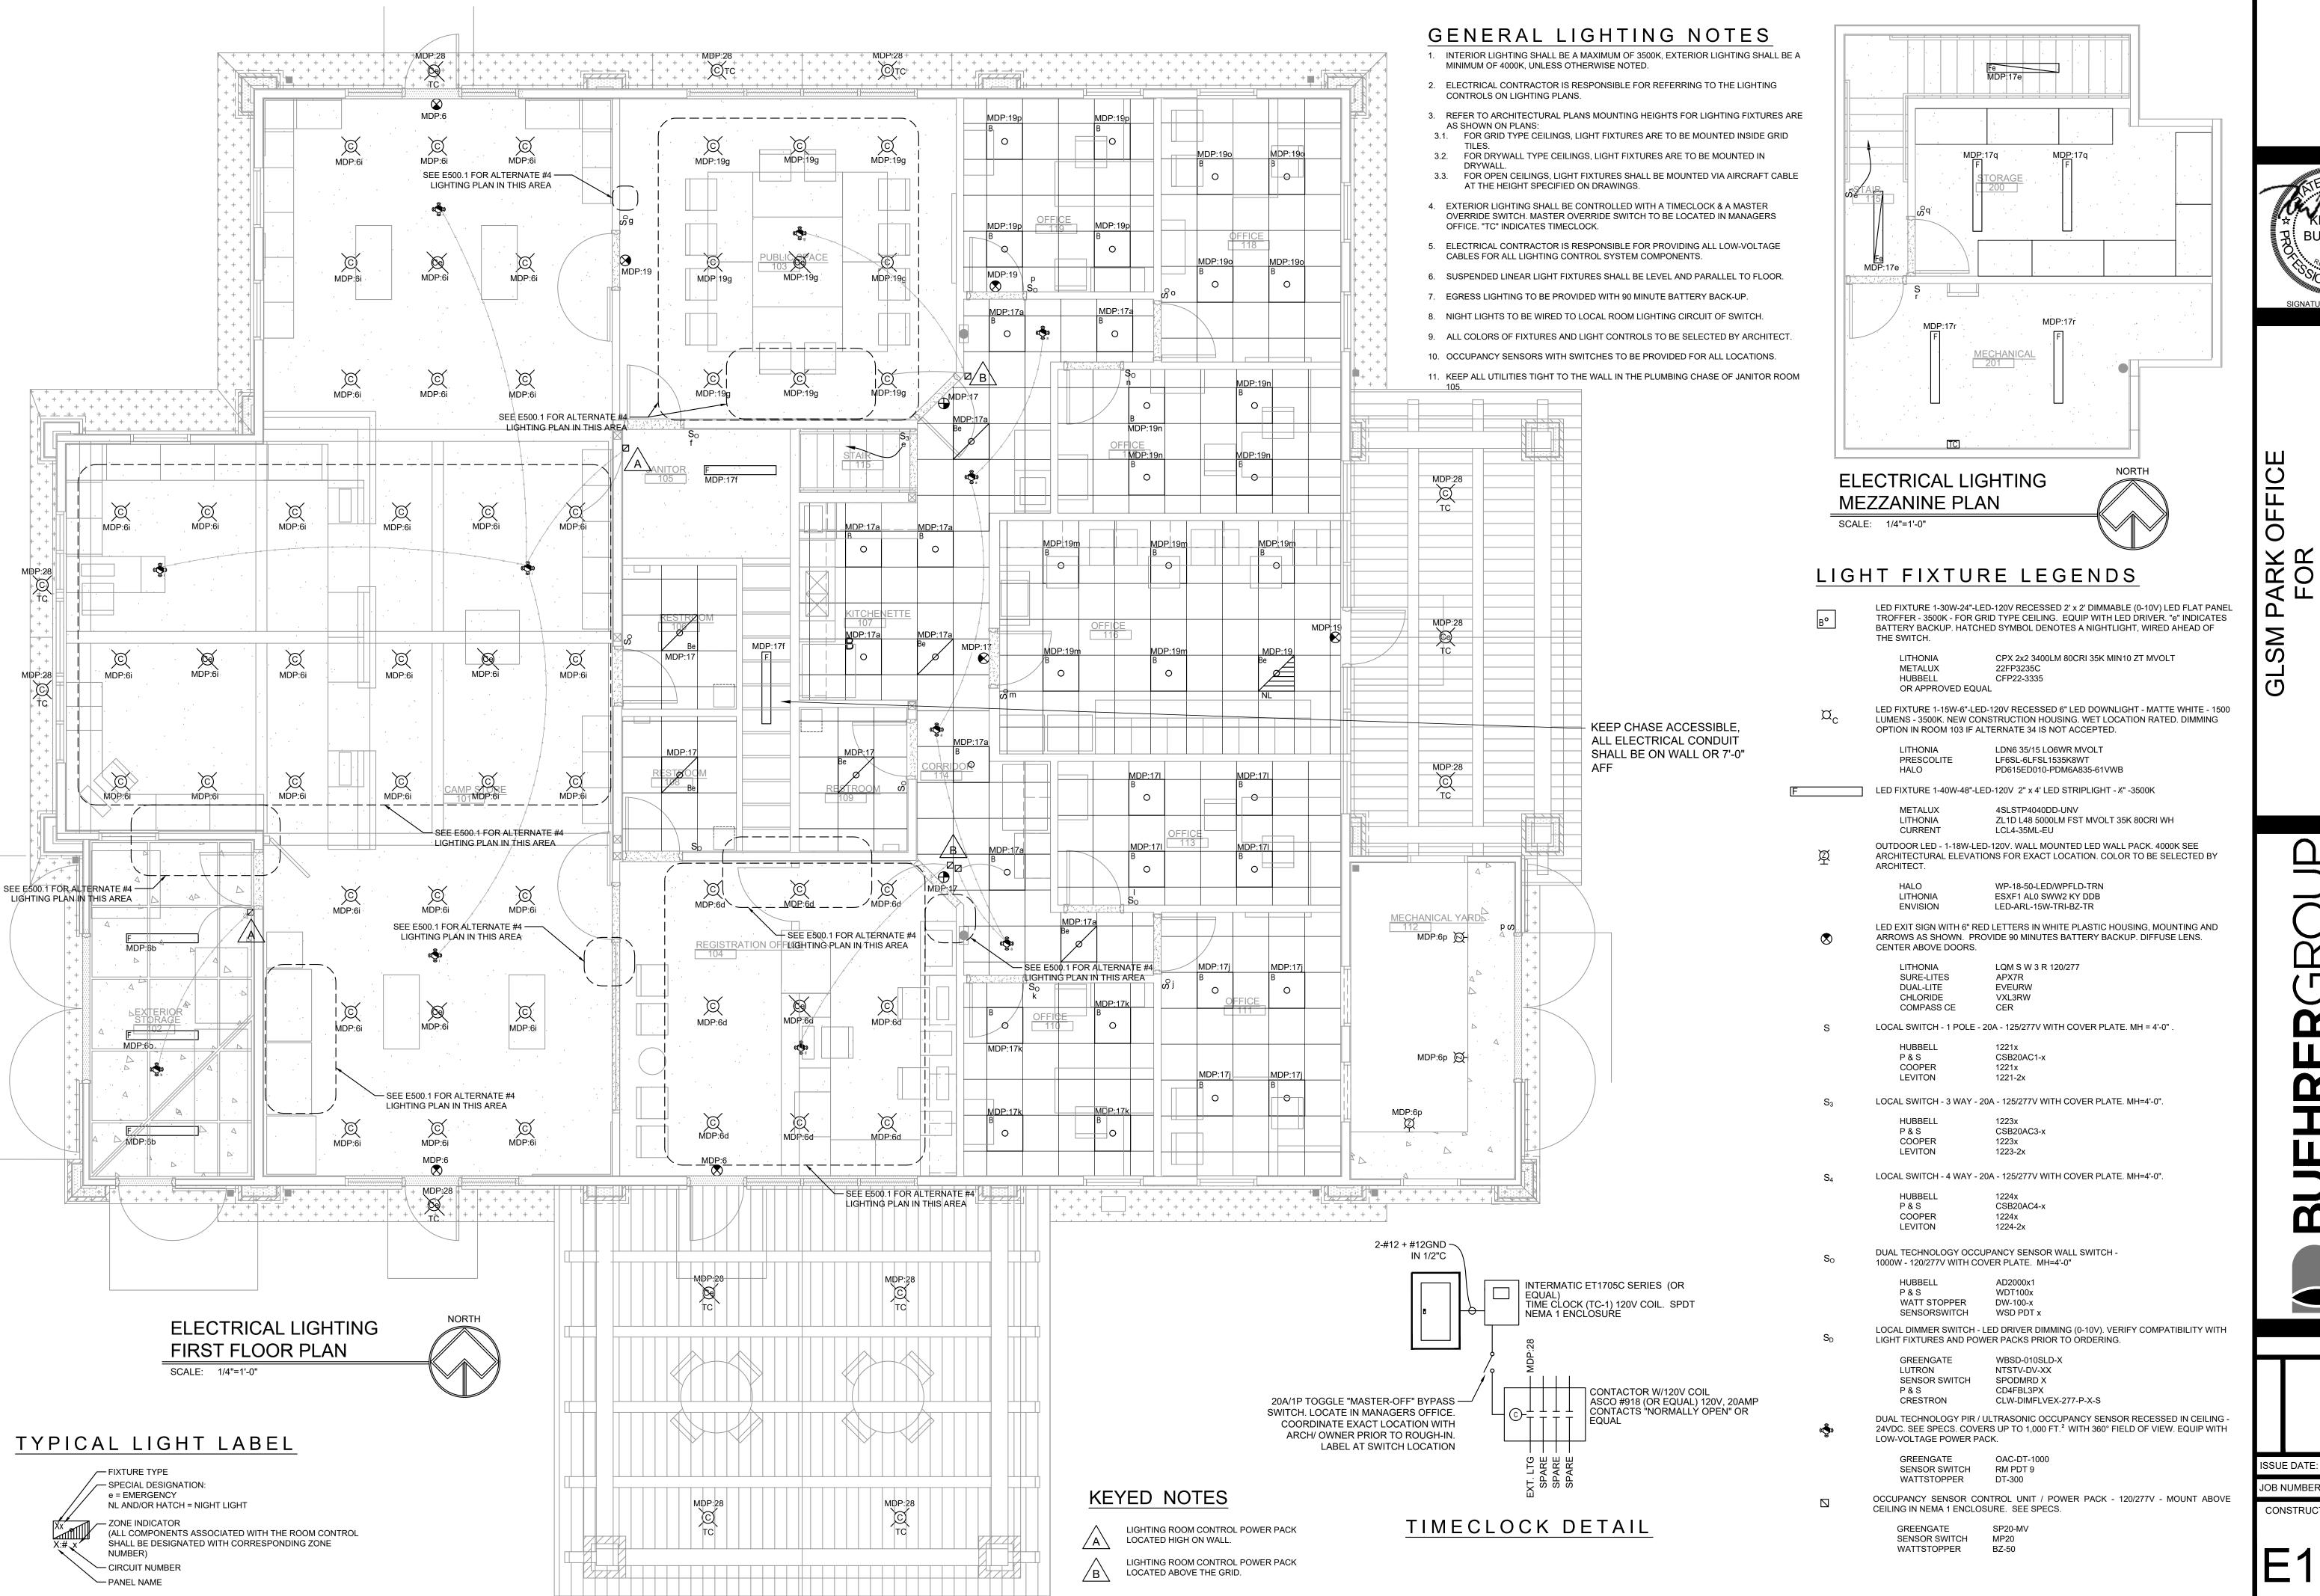

0 2


D


ISSUE DATE: 09/19/2025

OB NUMBER: 241224

CONSTRUCTION DOCUMENTS

E100.

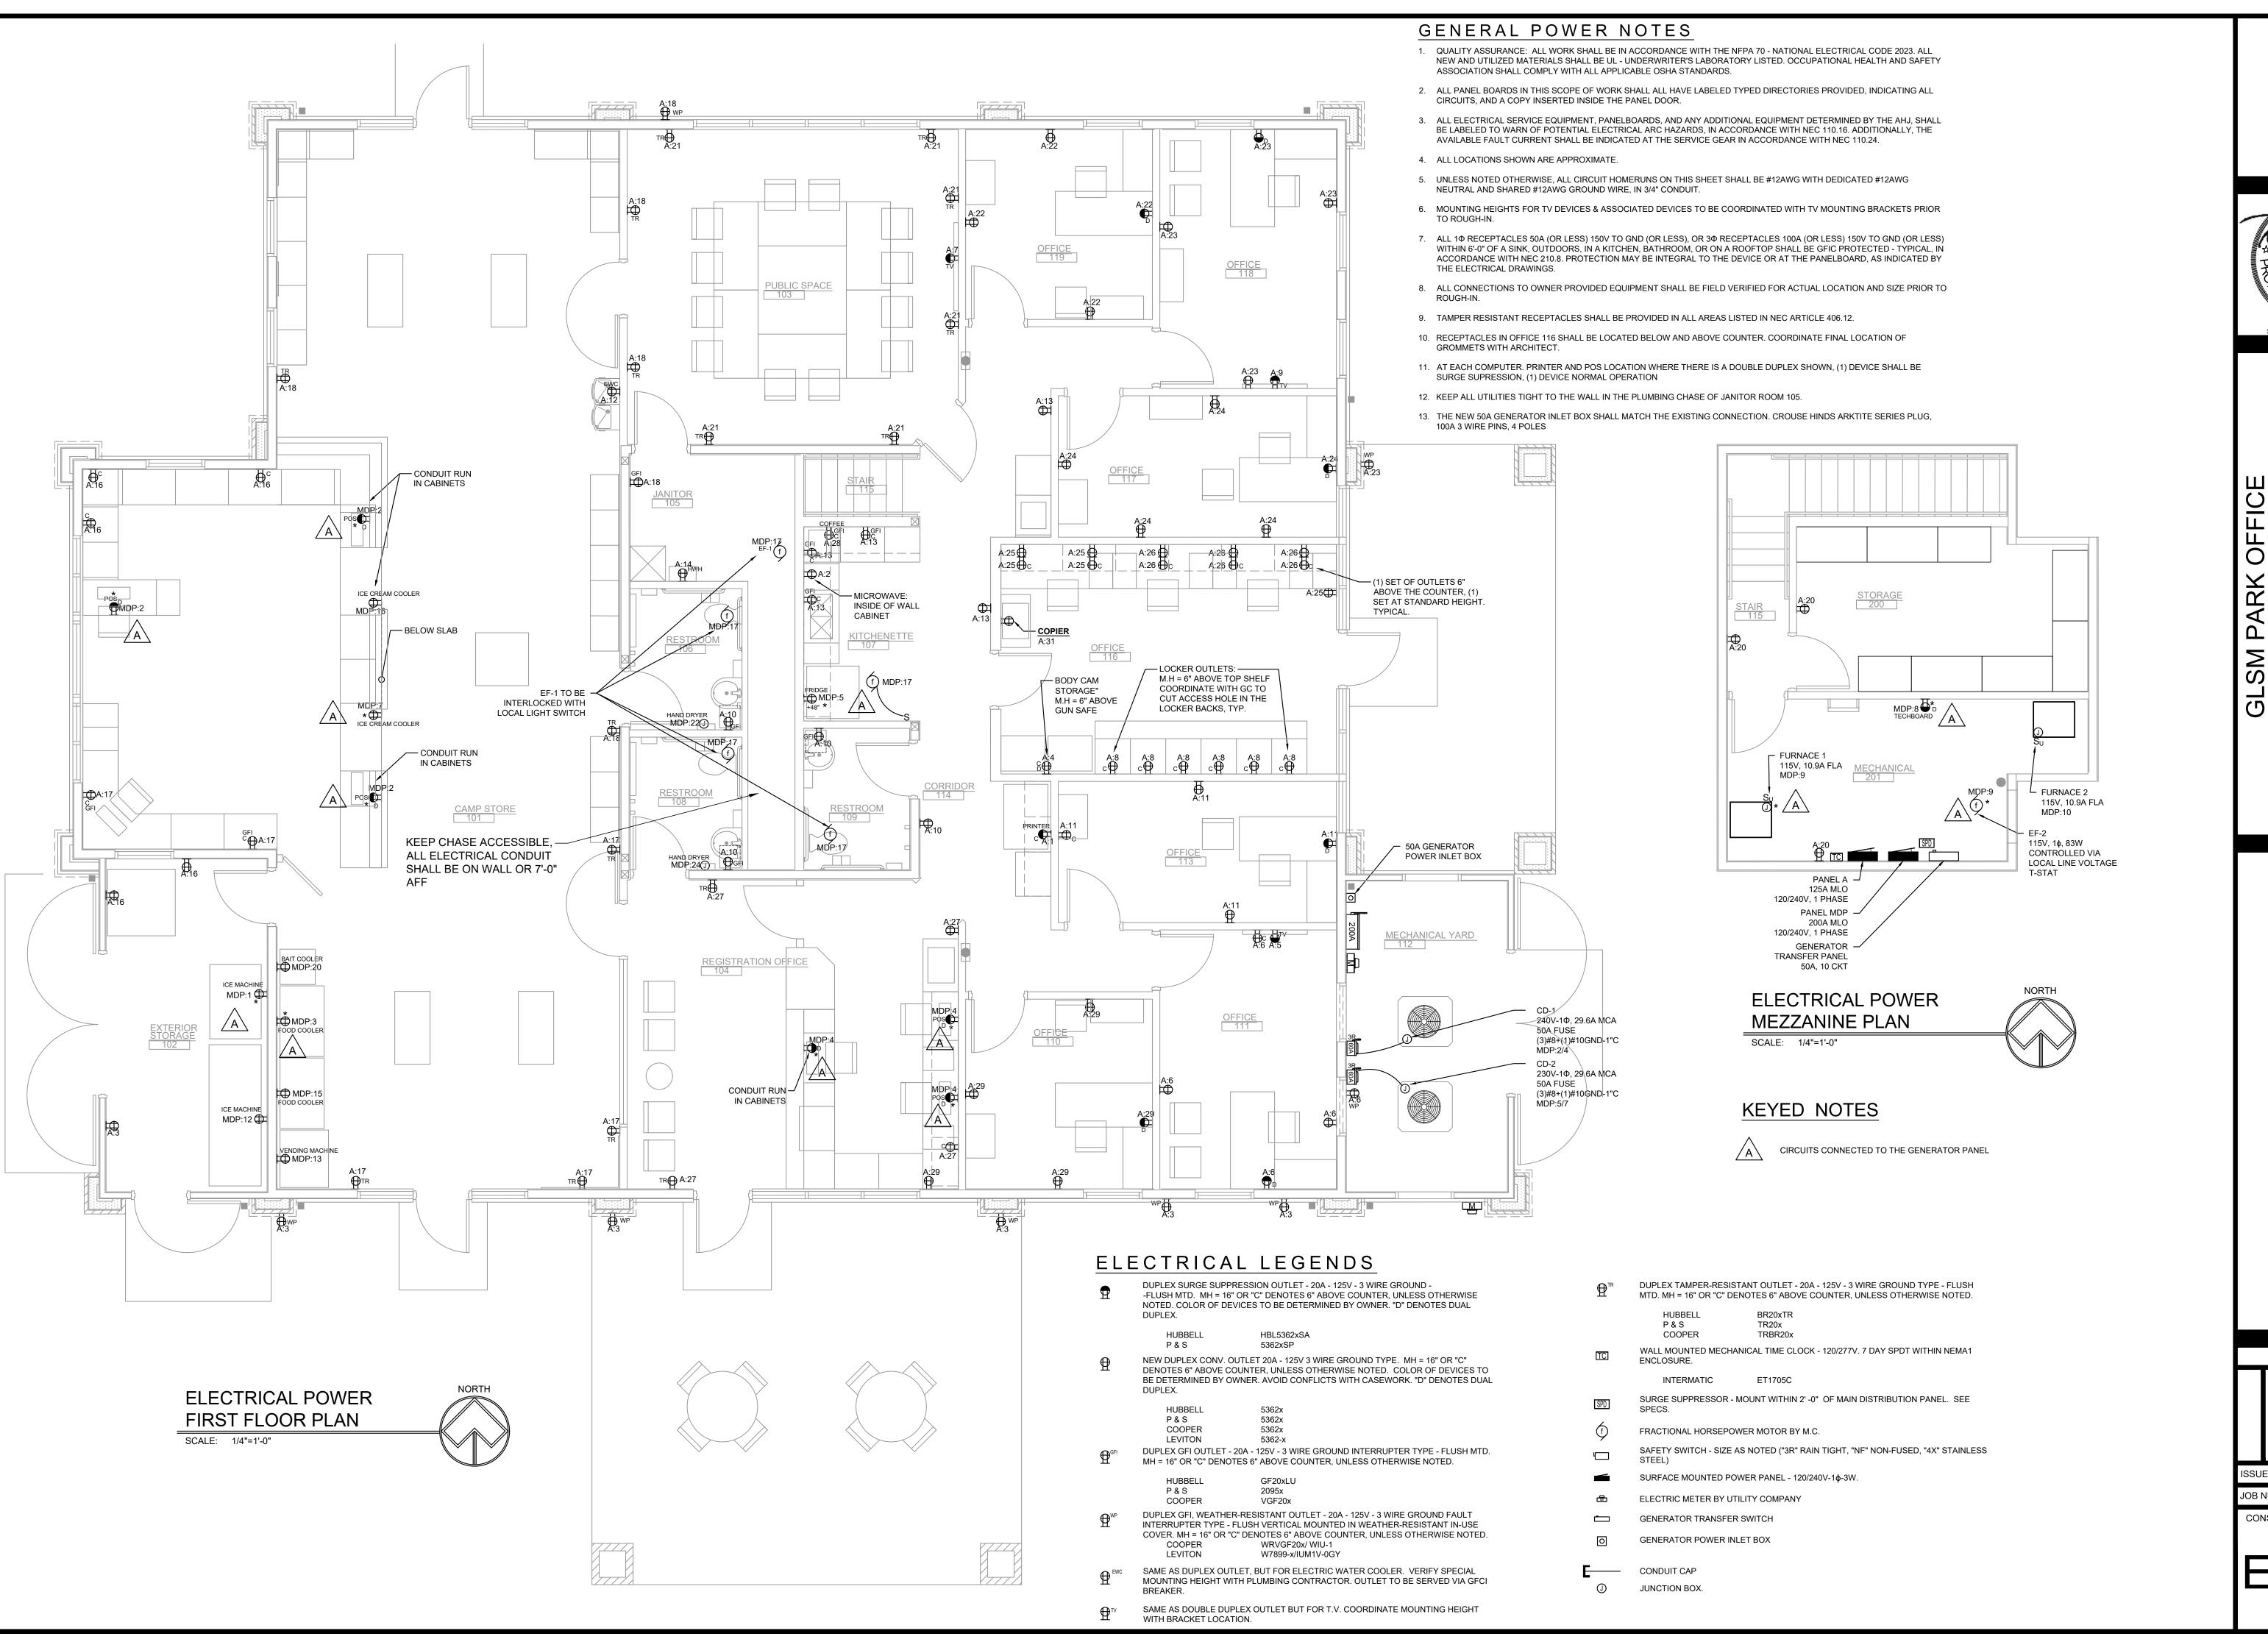

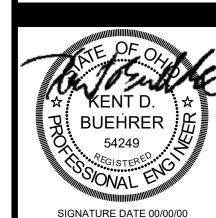

OFFICE 0 2 PARK FOR $\mathbb{S}^{\mathbb{N}}$

D




ISSUE DATE: 09/19/2025

JOB NUMBER: 241224

CONSTRUCTION DOCUMENTS

E200.

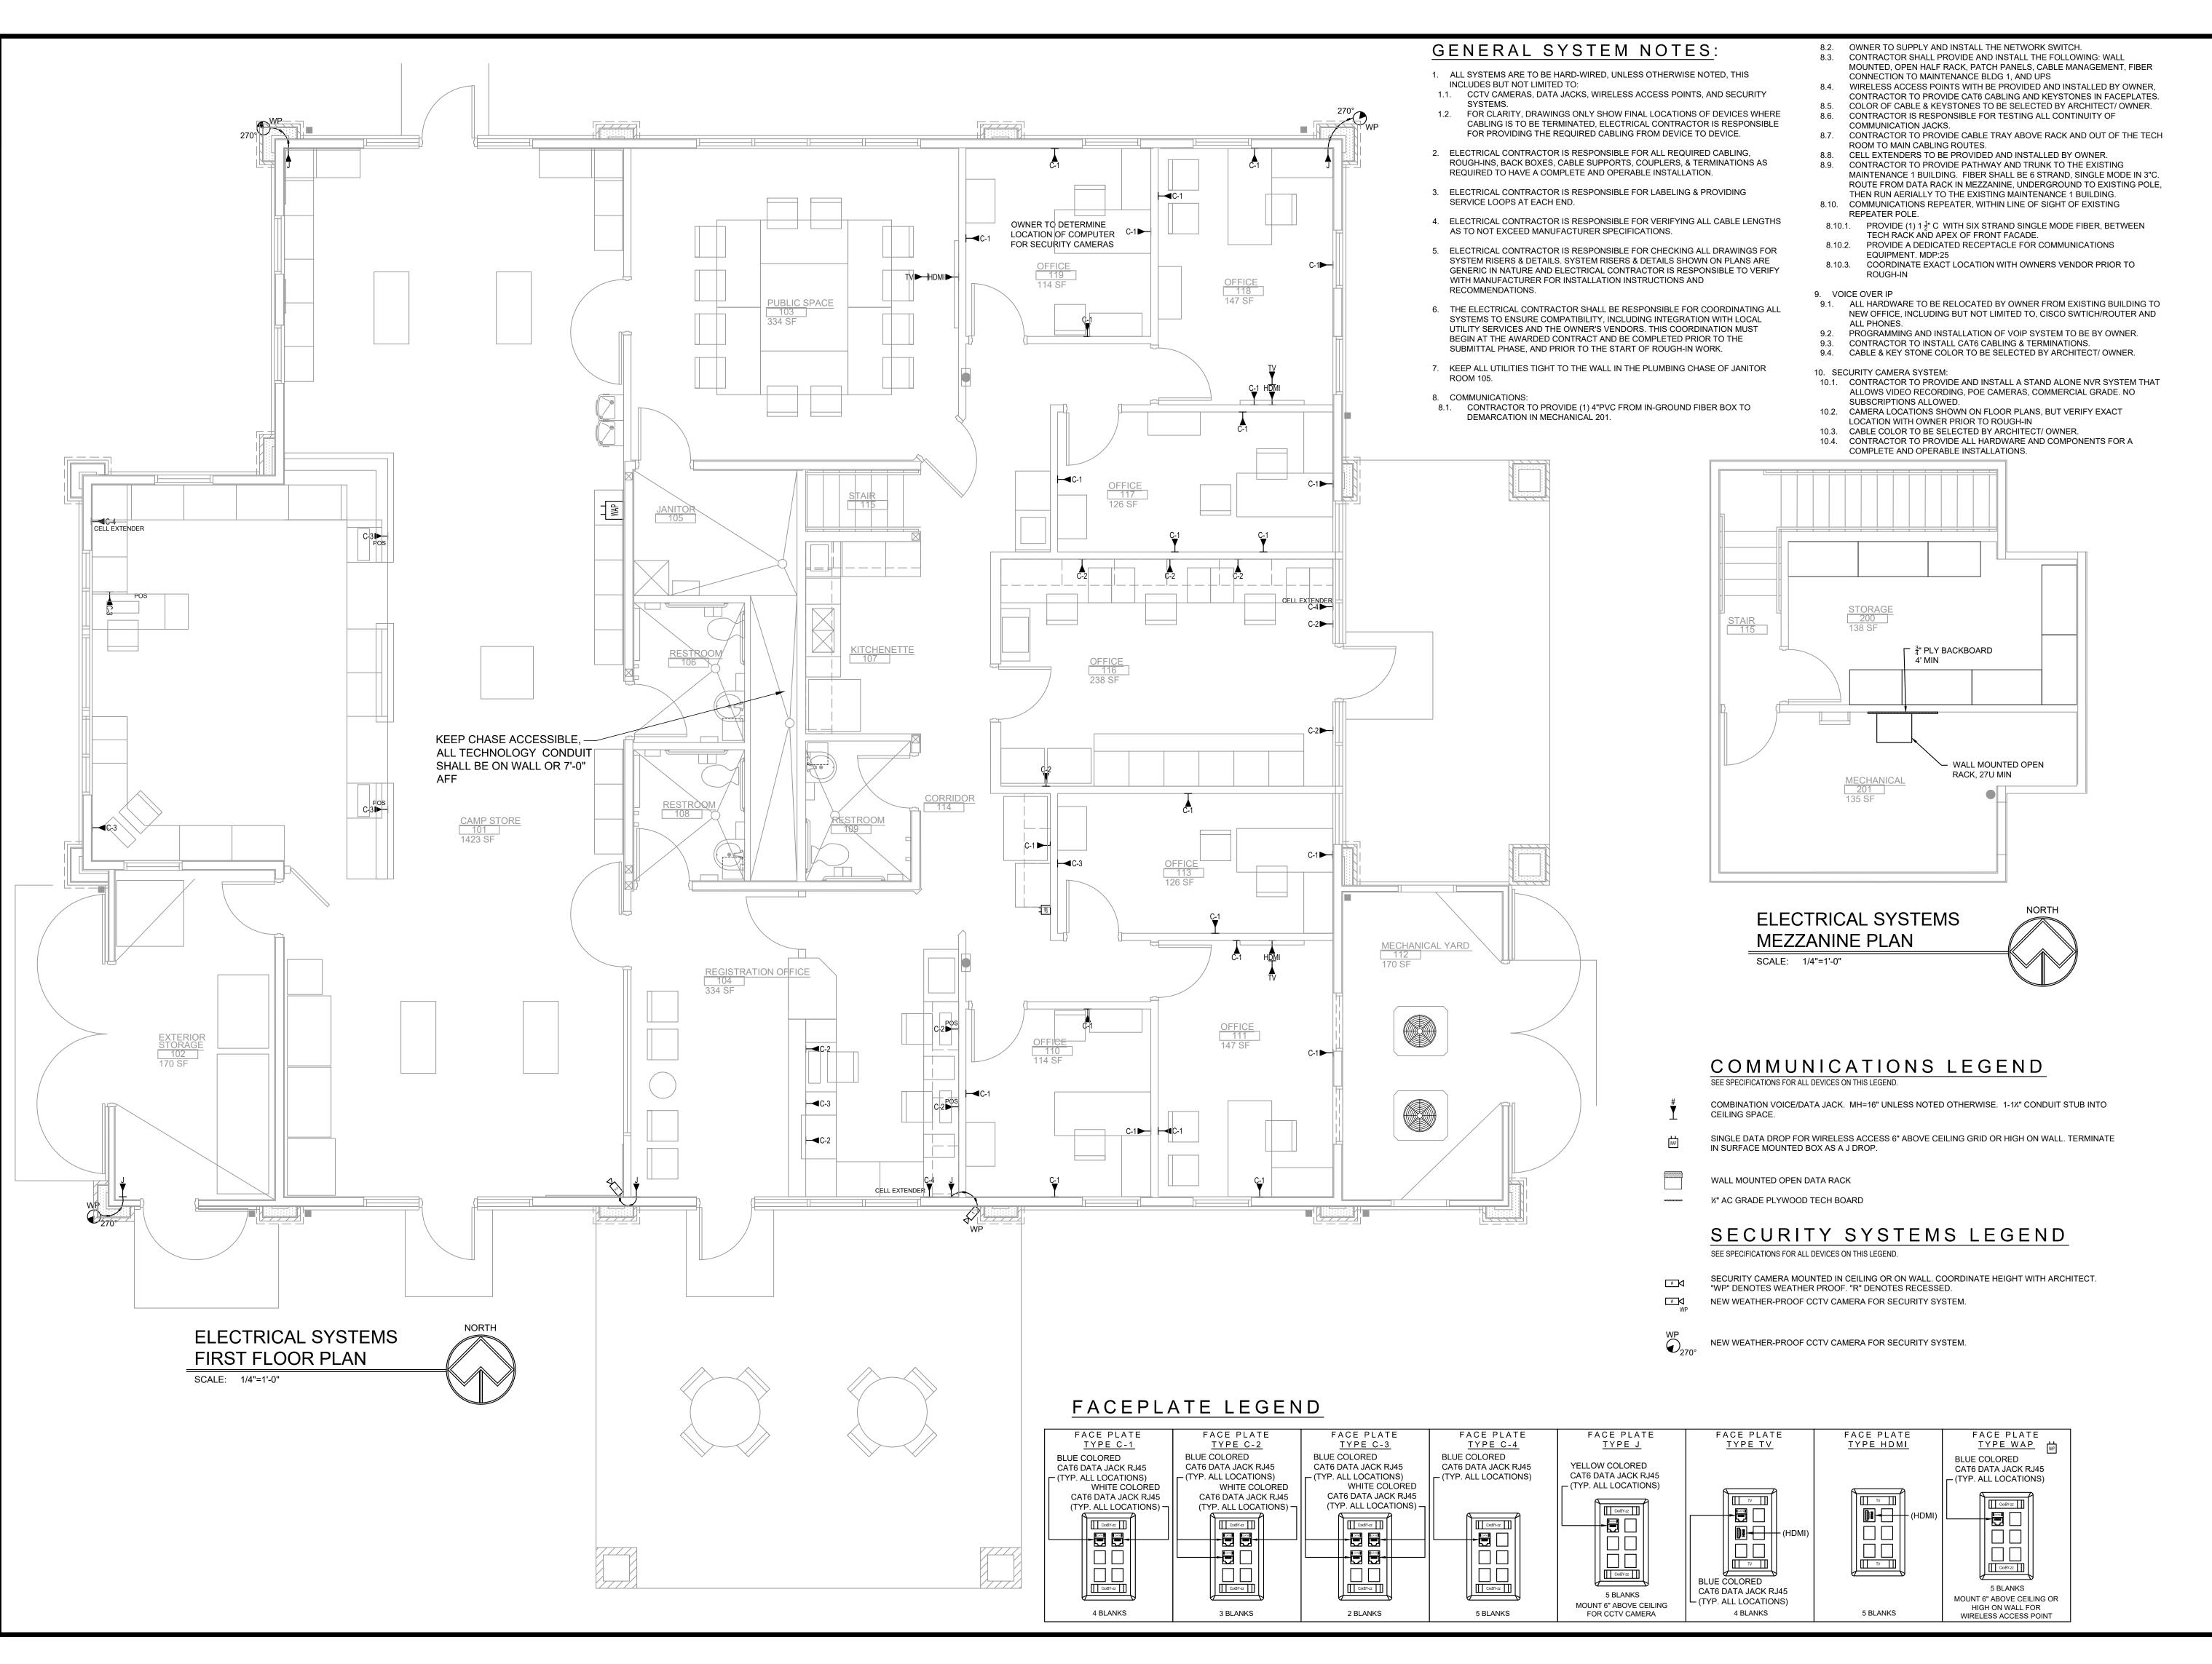

OFFICE 0 2 PARK FOR


D

ISSUE DATE: 09/19/2025

JOB NUMBER: 241224

CONSTRUCTION DOCUMENTS

E300.

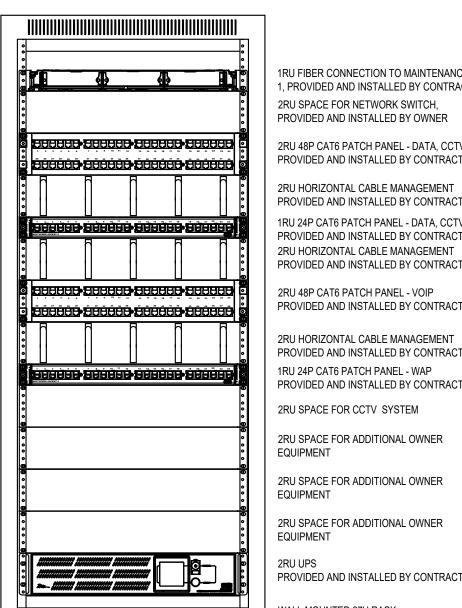

RACK DETAIL

ENSURE ALIGNMENT WITH CURRENT REQUIREMENTS.

THE FINAL ARRANGEMENT OF THE TECH RACK IS SUBJECT TO CHANGE BASED ON SUBMITTED EQUIPMENT

SPECIFICATIONS AND OWNER-PROVIDED DEVICES. COORDINATE WITH THE OWNER'S IT TEAM PRIOR TO INSTALLATION TO

RU FIBER CONNECTION TO MAINTENANCE BLDG PROVIDED AND INSTALLED BY CONTRACTOR 2RU SPACE FOR NETWORK SWITCH, PROVIDED AND INSTALLED BY OWNER

2RU 48P CAT6 PATCH PANEL - DATA, CCTV PROVIDED AND INSTALLED BY CONTRACTOR

PRU HORIZONTAL CABLE MANAGEMENT PROVIDED AND INSTALLED BY CONTRACTOR 1RU 24P CAT6 PATCH PANEL - DATA, CCTV PROVIDED AND INSTALLED BY CONTRACTOR 2RU HORIZONTAL CABLE MANAGEMENT PROVIDED AND INSTALLED BY CONTRACTOR

2RU 48P CAT6 PATCH PANEL - VOIP PROVIDED AND INSTALLED BY CONTRACTOR

PROVIDED AND INSTALLED BY CONTRACTOR 1RU 24P CAT6 PATCH PANEL - WAP PROVIDED AND INSTALLED BY CONTRACTOR

2RU SPACE FOR ADDITIONAL OWNER

2RU SPACE FOR ADDITIONAL OWNER


PROVIDED AND INSTALLED BY CONTRACTOR

WALL MOUNTED 27U RACK PROVIDED AND INSTALLED BY CONTRACTOR


C-1 | C-2 | C-3 | C-4 | J | TV | HDMI | WAP ROOM NUMBER OFFICE 119 OFFICE 118 4 1 1 1 OFFICE 117 OFFICE 116 OFFICE 113 3 OFFICE 111 OFFICE 110 4 CORRIDOR 114 **REGISTRATION OFFICE 104** 1 | 1 CAMP STORE 101 1 | 1 **EXTERIOR STORAGE 102** PUBLIC SPACE 103 1 CUPOLA TOTAL 25 | 10 | 6 | 4 | 5 | 3 | 3 | 2 | 58 TOTAL FACEPLATES T.DATA JACKS 12 | 4 | 5 | 3 | 0 | 2 | 71 T.VOICE JACKS **HDMI JACKS** 0 | 0 | 3 | 3 | 0 | 6 TOTAL NUMBER OF JACKS 124

LOAD

THE QUANTITIES INDICATED ARE APPROXIMATE AND PROVIDED SOLELY FOR GENERAL REFERENCE. IT IS THE RESPONSIBILITY OF THE CONTRACTOR TO VERIFY AND FURNISH THE ACCURATE QUANTITIES AND APPROPRIATE TYPES OF CONNECTIONS REQUIRED FOR THE SCOPE OF WORK.

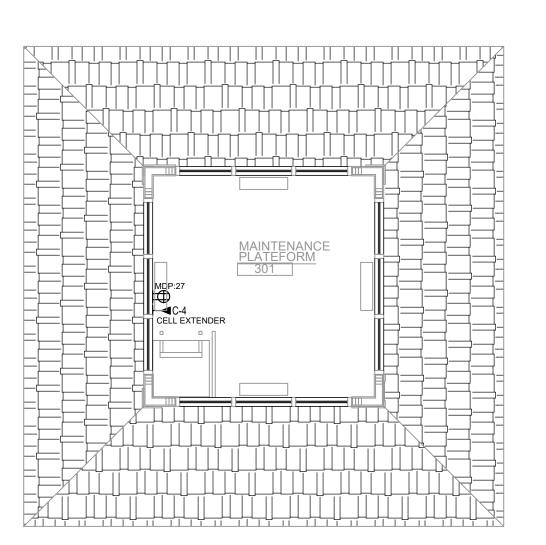




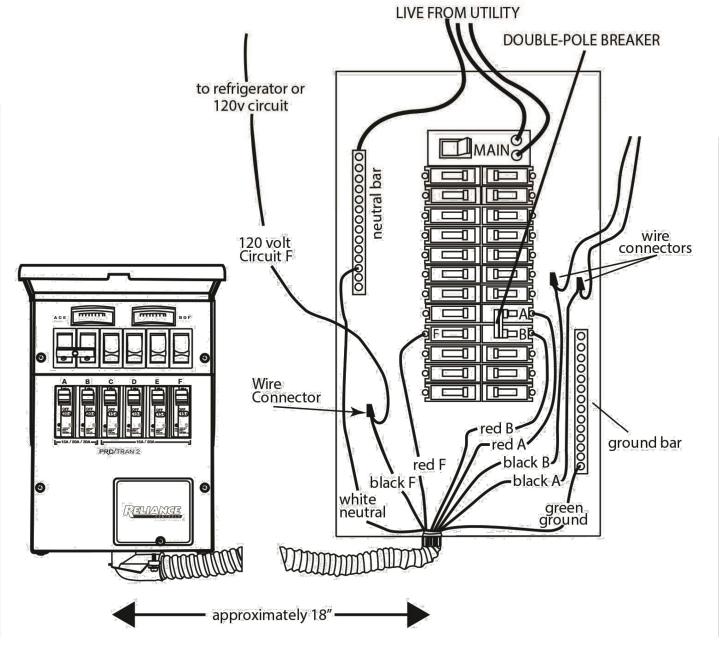


GENERATOR PANEL WIRING

GENERATOR PANEL WIRING DIAGRAM IS GENERAL IN NATURE. REFER TO MANUFACTURERS INSTALLATION INSTRUCTIONS.

¾"C — 'TV' OUTLET — — 'TV' JACK ACCOMMODATE TV MOUNTING BRACKET ✓ 'HDMI' JACK

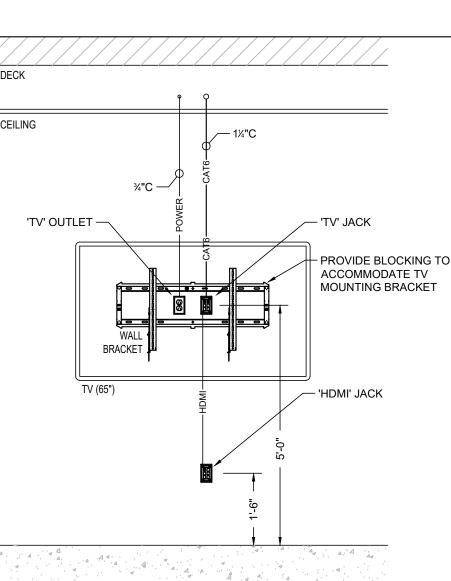

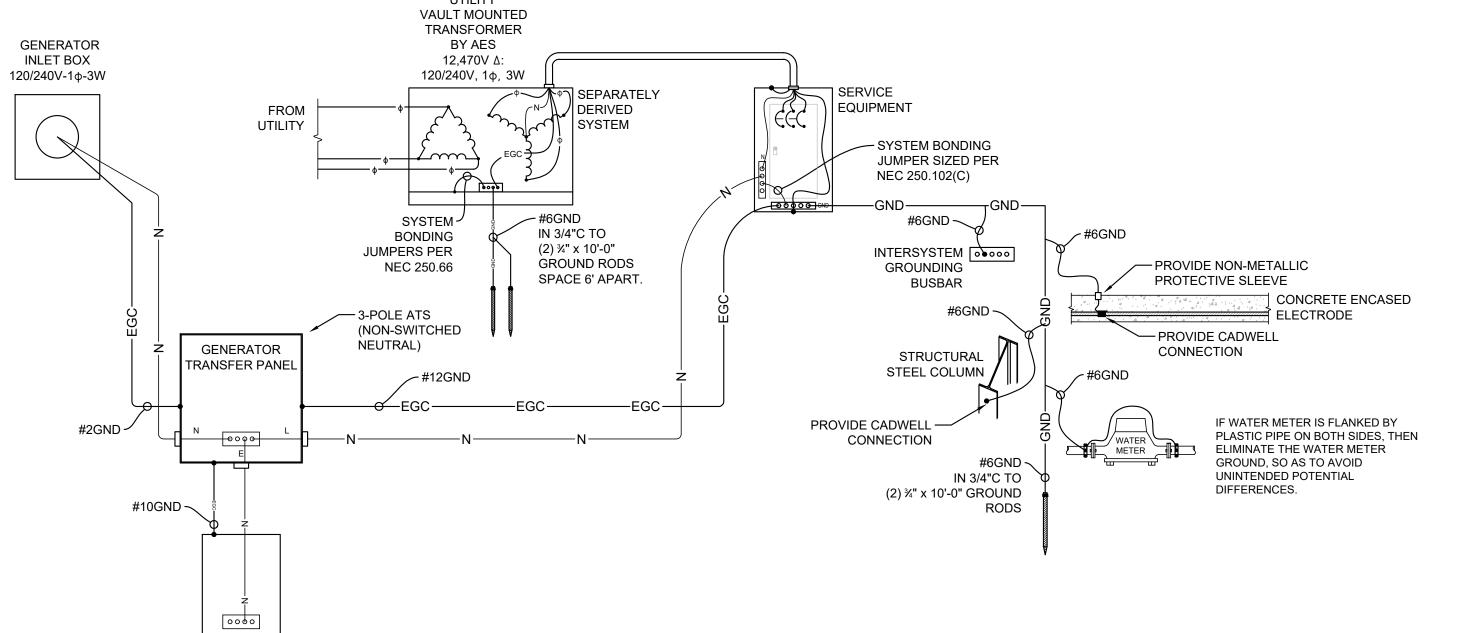

GENERATOR GROUNDING DETAIL

GROUNDING NOTES:

- CONNECT THE SERVICE NEUTRAL CONDUCTOR ACCORDING TO NEC 250.24(A)(1), AND AS IDENTIFIED IN NEC 250.26.
- IF AN OUTDOOR TRANSFORMER IS SUPPLYING SERVICE TO THE BUILDING, AT LEAST ONE ADDITIONAL GROUNDING CONNECTION SHALL BE MADE FROM THE GROUNDED SERVICE
- CONDUCTOR TO A GROUNDING ELECTRODE PER NEC 250.24(A)(2). THE MAIN BONDING JUMPER AS WELL AS THE SYSTEM BONDING JUMPER AS IDENTIFIED BY 205.28 SHALL BE SIZED PER 250.102(C)(1).
- WHEN GROUNDING A SEPARATELY DERIVED SYSTEM FOR A GROUNDED SYSTEM, ALL GROUNDING SHALL BE INSTALLED IN ACCORDANCE WITH 250.30(A).
- PER NEC 250.52, ELECTRODES PERMITTED FOR GROUNDING INCLUDE: METAL UNDERGROUND WATER PIPE, THE METAL FRAME OF THE BUILDING OR STRUCTURE, AND CONCRETE ENCASED
- 5.1. WHEN USING THE METAL UNDERGROUND WATER PIPE AS THE GROUNDING ELECTRODE, THE BONDING SHALL BE MADE WITHIN THE FIRST 5 FEET OF ENTERING THE BUILDING.
- IF A SINGLE GROUND ROD IS BEING USED AS A SUPPLEMENTAL ELECTRODE TO A METAL UNDERGROUND WATER PIPE PER 250.53(D)(2) AND HAS A RESISTANCE OF LESS THAN 25Ω , THEN A SUPPLEMENTAL GROUND ROD IS REQUIRED AND BE SPACED AT 6' APART PER NEC 250.53(A)
- EXCEPTION AND 250.53(B). THE BONDING JUMPER USED TO CONNECT THE GROUNDING ELECTRODES TOGETHER SHALL BE
- SIZED PER TABLE 250.66. THE BONDING JUMPER WHERE CONNECTED TO THE SUPPLEMENTAL GROUND ROD IS NOT
- REQUIRED TO BE LARGER THAN #6 AWG CU OR #4 AWG AL. GROUNDING ELECTRODE CONDUCTOR(S) AND BONDING JUMPERS INTERCONNECTING GROUNDING ELECTRODES SHALL BE INSTALLED IN ACCORDANCE WITH 250.64(F)(1),(2), OR (3).
- THE GROUNDING ELECTRODE CONDUCTOR SHALL BE PERMITTED TO BE RUN TO ONE OR MORE GROUNDING ELECTRODE(S) INDIVIDUALLY.
- BONDING JUMPER(S) FROM GROUNDING ELECTRODE(S) SHALL BE PERMITTED TO BE CONNECTED TO AN ALUMINUM OR COPPER BUS BAR NOT LESS THAN 1" x 2" AND FASTENED SECURELY TO AN



SIGNATURE DATE 00/00/00

ing


OFFICE

PARK FOR

ISSUE DATE: 09/19/2025

JOB NUMBER: 241224

UNDERGROUND TRENCHING DETAIL

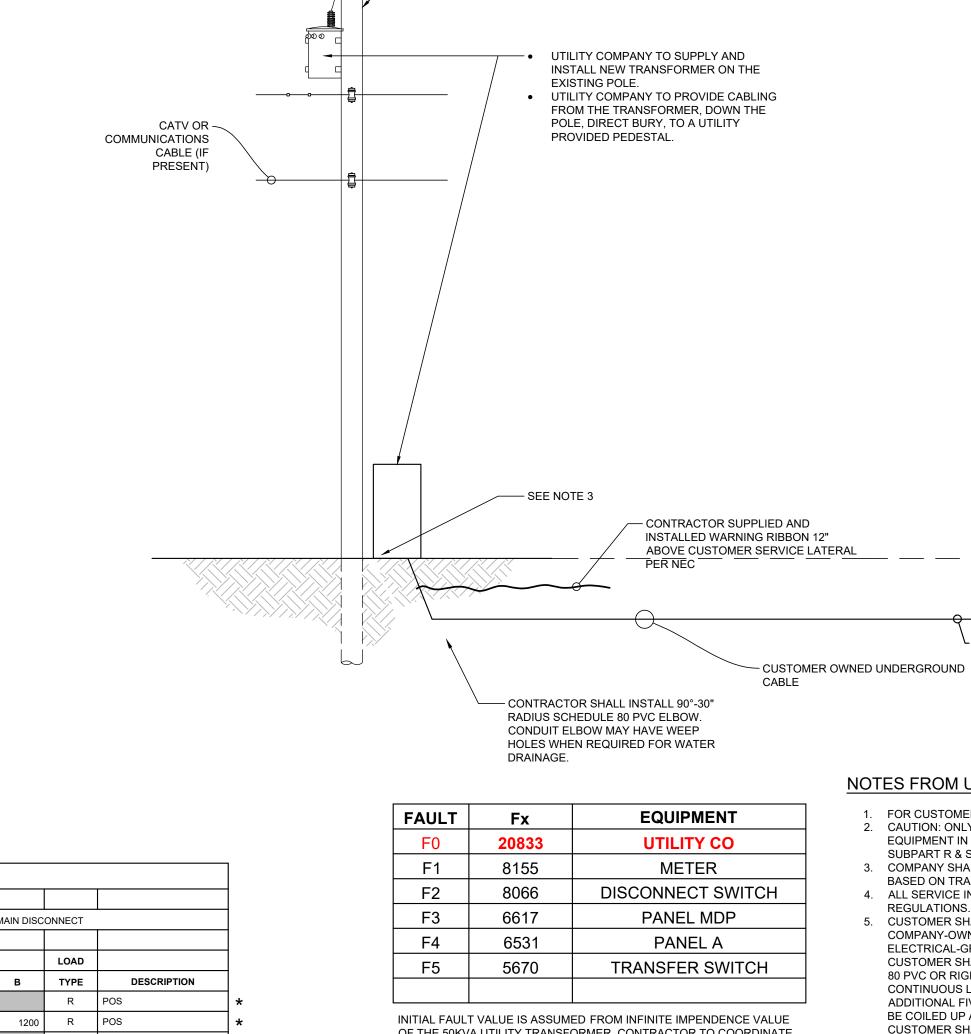

- POLE ON PRIVATE

						PANE	L MDP					
MAINS:	200A	MLO	V:	120/240V		1	PH.	3	WIRE			
MOUNTING:	SURF	ACE	LOCATION	:	MECHANIC	CAL ROOM 2	01		FED FROM:	MAIN DISC	ONNECT	
	LOAD				AMPS	СКТ	СКТ	AMPS			LOAD	
DESCRIPTION	TYPE	Α		В	POLE	#	#	POLE	Α	В	TYPE	DESCRIPTION
ICE MACHINE	К	1500			20G	1	2	20	1200		R	POS
FOOD COOLER	К			1000	20G	3	4	20		1200	R	POS
FRIDGE	К	1500			20G	5	6	20	855		L	LIGHTS
ICE CREAM COOLER	К			1000	20G	7	8	20		400	R	TECHBOARD
F-1 & EF-2	HVAC	1391			20	9	10	20	1391		HVAC	F-2
SPARE					20	11	12	20G		1500	К	ICE MACHINE
VENDING MACHINE	К	1500			20G	13	14	20G	1500		К	FRIDGE
FOOD COOLER	К			1000	20G	15	16	20G		500	К	ICE CREAM COOLER
LIGHTS	L	1070			20	17	18	20				SPARE
LIGHTS	L			675	20	19	20	20G		500	к	BAIT COOLER
SPARE					20	21	22	20G	1800		R	HAND DRYER
SPARE					20	23	24	20G		1800	R	HAND DRYER
REPEATER	R	200			20	25	26	20	200		R	TIMECLOCK
CUPOLA	R			200	20	27	28	20		195	L	EXT LTG
		13400				29	30	20				SPARE
PANEL A				10700	125	31	32	20				SPARE
		2504				33	34	20				SPARE
CD-2	HVAC			2504	50	35	36	20				SPARE
		0				37	38		2504			
SPD				0	30	39	40	50		2504	HVAC	CD-1
SPACE						41	42			2004		SPACE
						71						
SUBTOTAL #1		23065		17079					9450	8599		SUBTOTAL #2
SUBTOTAL #1 + #2		32515		25678					3400	0000		30BTOTAL #2
TOTAL PANEL LOAD:	58.2	KVA		242.5	AMPS					DEMANDED:	192	A MINIMUM FEEDER
TOTAL PANEL LOAD.	36.2	KVA		242.5	AWIFS					DEMIANDED.	192	A MINIMOM FEEDER
	T			D 100								
	Total Conne	ected Load		Demand %		De	mand Load					
RECEPTACLES	10.0			100%			10.0					
RECEPTACLES	19.8			50%			9.9				-	
LIGHTING	2.8			100%			2.8					
KITCHEN	11.5			65%			7.5					
WATER & ELEC HEAT	0.0			100%			0.0					
HVAC	12.7			100%			12.7					
LARGEST MTR	0.0			125%			0.0					
OTHER MOTORS	0.0			100%			0.0					
	56.8	kw					42.87	kw				
	236.6	Amps @ 24	10V				178.63	Amps @ 2	40V			
Continuous	12.8	х	125%				15.99	kw				
Non-continuous	30.1	х	100%				30.08	kw				
							46.07	kw				
		i e	I		l	İ		ı	1 1		1	1

DISCONNECT SWITCH

INITIAL FAULT VALUE IS ASSUMED FROM INFINITE IMPENDENCE VALUE OF THE 50KVA UTILITY TRANSFORMER. CONTRACTOR TO COORDINATE EXACT VALUE WITH UTILITY COMPANY.

NOTES FROM UTILITY GUIDELINES:

(3)#3/0 - 2"PVC

- FOR CUSTOMER / COMPANY RESPONSIBILITIES. REFER TO AES HANDBOOK. CAUTION: ONLY QUALIFIED PERSONNEL ARE PERMITTED TO INSTALL ELECTRICAL SUBPART R & S.
- 3. COMPANY SHALL DETERMINE THE LOCATION / POSITION OF VERTICAL RISERS ON THE POLE BASED ON TRAFFIC FLOW AND LOCATION OF CATV, OR TELEPHONE CO. ATTACHMENTS. 4. ALL SERVICE INSTALLATIONS SHALL MEET NEC, STATE, AND LOCAL CODES AND
- 5. CUSTOMER SHALL CONTACT THE COMPANY BEFORE INSTALLING ANY FACILITIES ON THE COMPANY-OWNED POLE. CUSTOMER SHALL SUPPLY ALL OF THE REQUIRED ELECTRICAL-GRADE CONDUIT, BRACKETS / CLAMPS, WEATHERHEAD, AND CABLE. THE CUSTOMER SHALL BE RESPONSIBLE FOR INSTALLING THE FIRST TEN (10) FEET OF SCHEDULE 80 PVC OR RIGID METALLIC CONDUIT ON THE POLE. CUSTOMER SHALL SUPPLY A CONTINUOUS LENGTH OF CABLE TO REACH THE OVERHEAD POWER SOURCE PLUS AN ADDITIONAL FIVE (5) FEET REQUIRED FOR DROP LOOP AND TERMINATION. THE CABLE SHALL BE COILED UP AND TEMPORARILY ATTACHED ON THE POLE TEN (10) FEET ABOVE GROUND.

CUSTOMER SHALL COORDINATE THE INSTALLATION WITH THE COMPANY.

6. CONDUIT SIZE IS LIMITED TO 3" OR 4" DIA. CONDUIT.

GENERAL PROJECT NOTES:

EXTERIOR - INTERIOR

(3)#8 & (1)#10GND -3/4"C -

MECHANICAL YARD

50A

GENERATOR POWER INLET

200A NEMA 3R 200AF

DISCON. SWITCH

SINGLE LINE DIAGRAM, 120/240V, 1¢, 3W, 200A

2 SETS 0F

GENERATOR

TRANSFER

SWITCH

50A,10 CKT

- (3)#3/0&(1)#6GND-2"C

(10)#12&(1)#12GND-3/4"C

1. ALL CONDUIT SHALL BE INSTALLED WITHIN WALLS. ANY CONDUIT THAT MUST REMAIN EXPOSED REQUIRES PRIOR EXPLICIT APPROVAL.

PANEL MDP

200A-MLO

120/240V-1φ-3W

11-20A-1P

9-20A-GFI-1P

1-30A-2P

2-50A-2P

1-200A-2P #### kVA

MEZZANINE MECHANICAL ROOM 201

- (3)#1&(1)#6GND-11/2"C

125A-MLO

120/240V-1φ-3W

38-20A-1P

4-20A-GFI-1P

1-30A-2P

kVA


2. IF THERE'S A CONFLICT BETWEEN THE DRAWINGS AND THE SPECIFICATIONS, THE CONTRACTOR SHALL BASE THEIR BID ON THE MORE DEMANDING OR COSTLY

						PAN	IEL A					
MAINS:	125	MLO	V:	120/240V			PH.	3	WIRE			
MOUNTING:	SUR	FACE	LOCATION:		MECHANIC	CAL ROOM	201	<u>'</u>	FED FROM:	MDP		
	LOAD				AMPS	скт	СКТ	AMPS			LOAD	
DESCRIPTION	TYPE	A		В	POLE	#	#	POLE	A	В	TYPE	DESCRIPTION
PRINTER	R	500			20	1	2	20G	1500	_	R	MICROWAVE
RECEPTACLES	R			1200	20	3	4	20		400	R	BODY CAM STORAGE
TV	R	300			20	5	6	20	1200		R	RECEPTACLES
TV	R			300	20	7	8	20		1200	R	RECEPTACLES
TV	R	300			20	9	10	20	800		R	RECEPTACLES
RECEPTACLES	R			1000	20	11	12	20G		500	R	EWC
RECEPTACLES	R	1000			20G	13	14	20G	500		R	HWH
SPARE					20	15	16	20		1000	R	RECEPTACLES
RECEPTACLES	R	1200			20	17	18	20	1200		R	RECEPTACLES
SPARE					20	19	20	20		600	R	RECEPTACLES
RECEPTACLES	R	1200			20	21	22	20	1000		R	RECEPTACLES
RECEPTACLES	R			1200	20	23	24	20		1200	R	RECEPTACLES
RECEPTACLES	R	800			20	25	26	20	1200		R	RECEPTACLES
RECEPTACLES	R			800	20	27	28	20		1000	R	COFFEE
RECEPTACLES	R	1200			20	29	30	20				SPARE
COPIER	R			1500	20	31	32	20				SPARE
SPARE					20	33	34	20				SPARE
SPARE					20	35	36	20				SPARE
SPARE					20	37	38	20				SPARE
SPARE					20	39	40	20				SPARE
SPARE					20	41	42	20				SPARE
SUBTOTAL #1		6000		4800					<u>7400</u>	5900		SUBTOTAL #2
SUBTOTAL #1 + #2		13400		10700								

	GENERATOR PANEL													
MAINS:	50A		MANUAL	TRANSFER	SWITCH									
MOUNTING:	SUR	FACE	LOCATION	l:	MECHANIC	CAL ROOM 2	01	•	FED FROM	l:	MDP			
	LOAD				AMPS	скт	СКТ	AMPS				LOAD		
DESCRIPTION	TYPE	Α		В	POLE	#	#	POLE	Α		В	TYPE	DESCRIPTION	
ICE MACHINE	К	1500			20G	1	2	20	1200			R	POS	
FOOD COOLER	К			1000	20G	3	4	20			1200	R	POS	
FRIDGE	К	1500			20G	5	6	20	855			L	LIGHTS	
ICE CREAM COOLER	К			1000	20G	7	8	20			400	R	TECHBOARD	
F-1 & EF-2	HVAC	1391			20	9	10	20	1391			HVAC	F-2	
SUBTOTAL #1		<u>4391</u>		2000					3446		<u>1600</u>		SUBTOTAL #2	
SUBTOTAL #1 + #2		<u>7837</u>		<u>3600</u>										
TOTAL PANEL LOAD:	11.4	KVA		47.7	AMPS					D	EMANDED:	47.71	A MINIMUM FEEDER	

G SPECIFIES A GFCI BREAKER REQUIRED

SPECIFIES CIRCUITS TO BE ROUTED THROUGH GENERATOR TRANSFER PANEL FOR * EMERGENCY POWER AS SEEN ON GENERATOR PANEL.
ALL RECEPTACLES CONNECTED TO THE EMERGENCY PANEL SHALL BE THE COLOR RED.

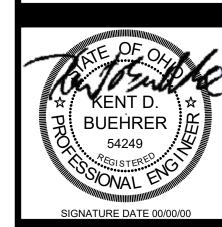


OFFICE PARK FOR



ISSUE DATE: 09/19/2025

JOB NUMBER: 241224

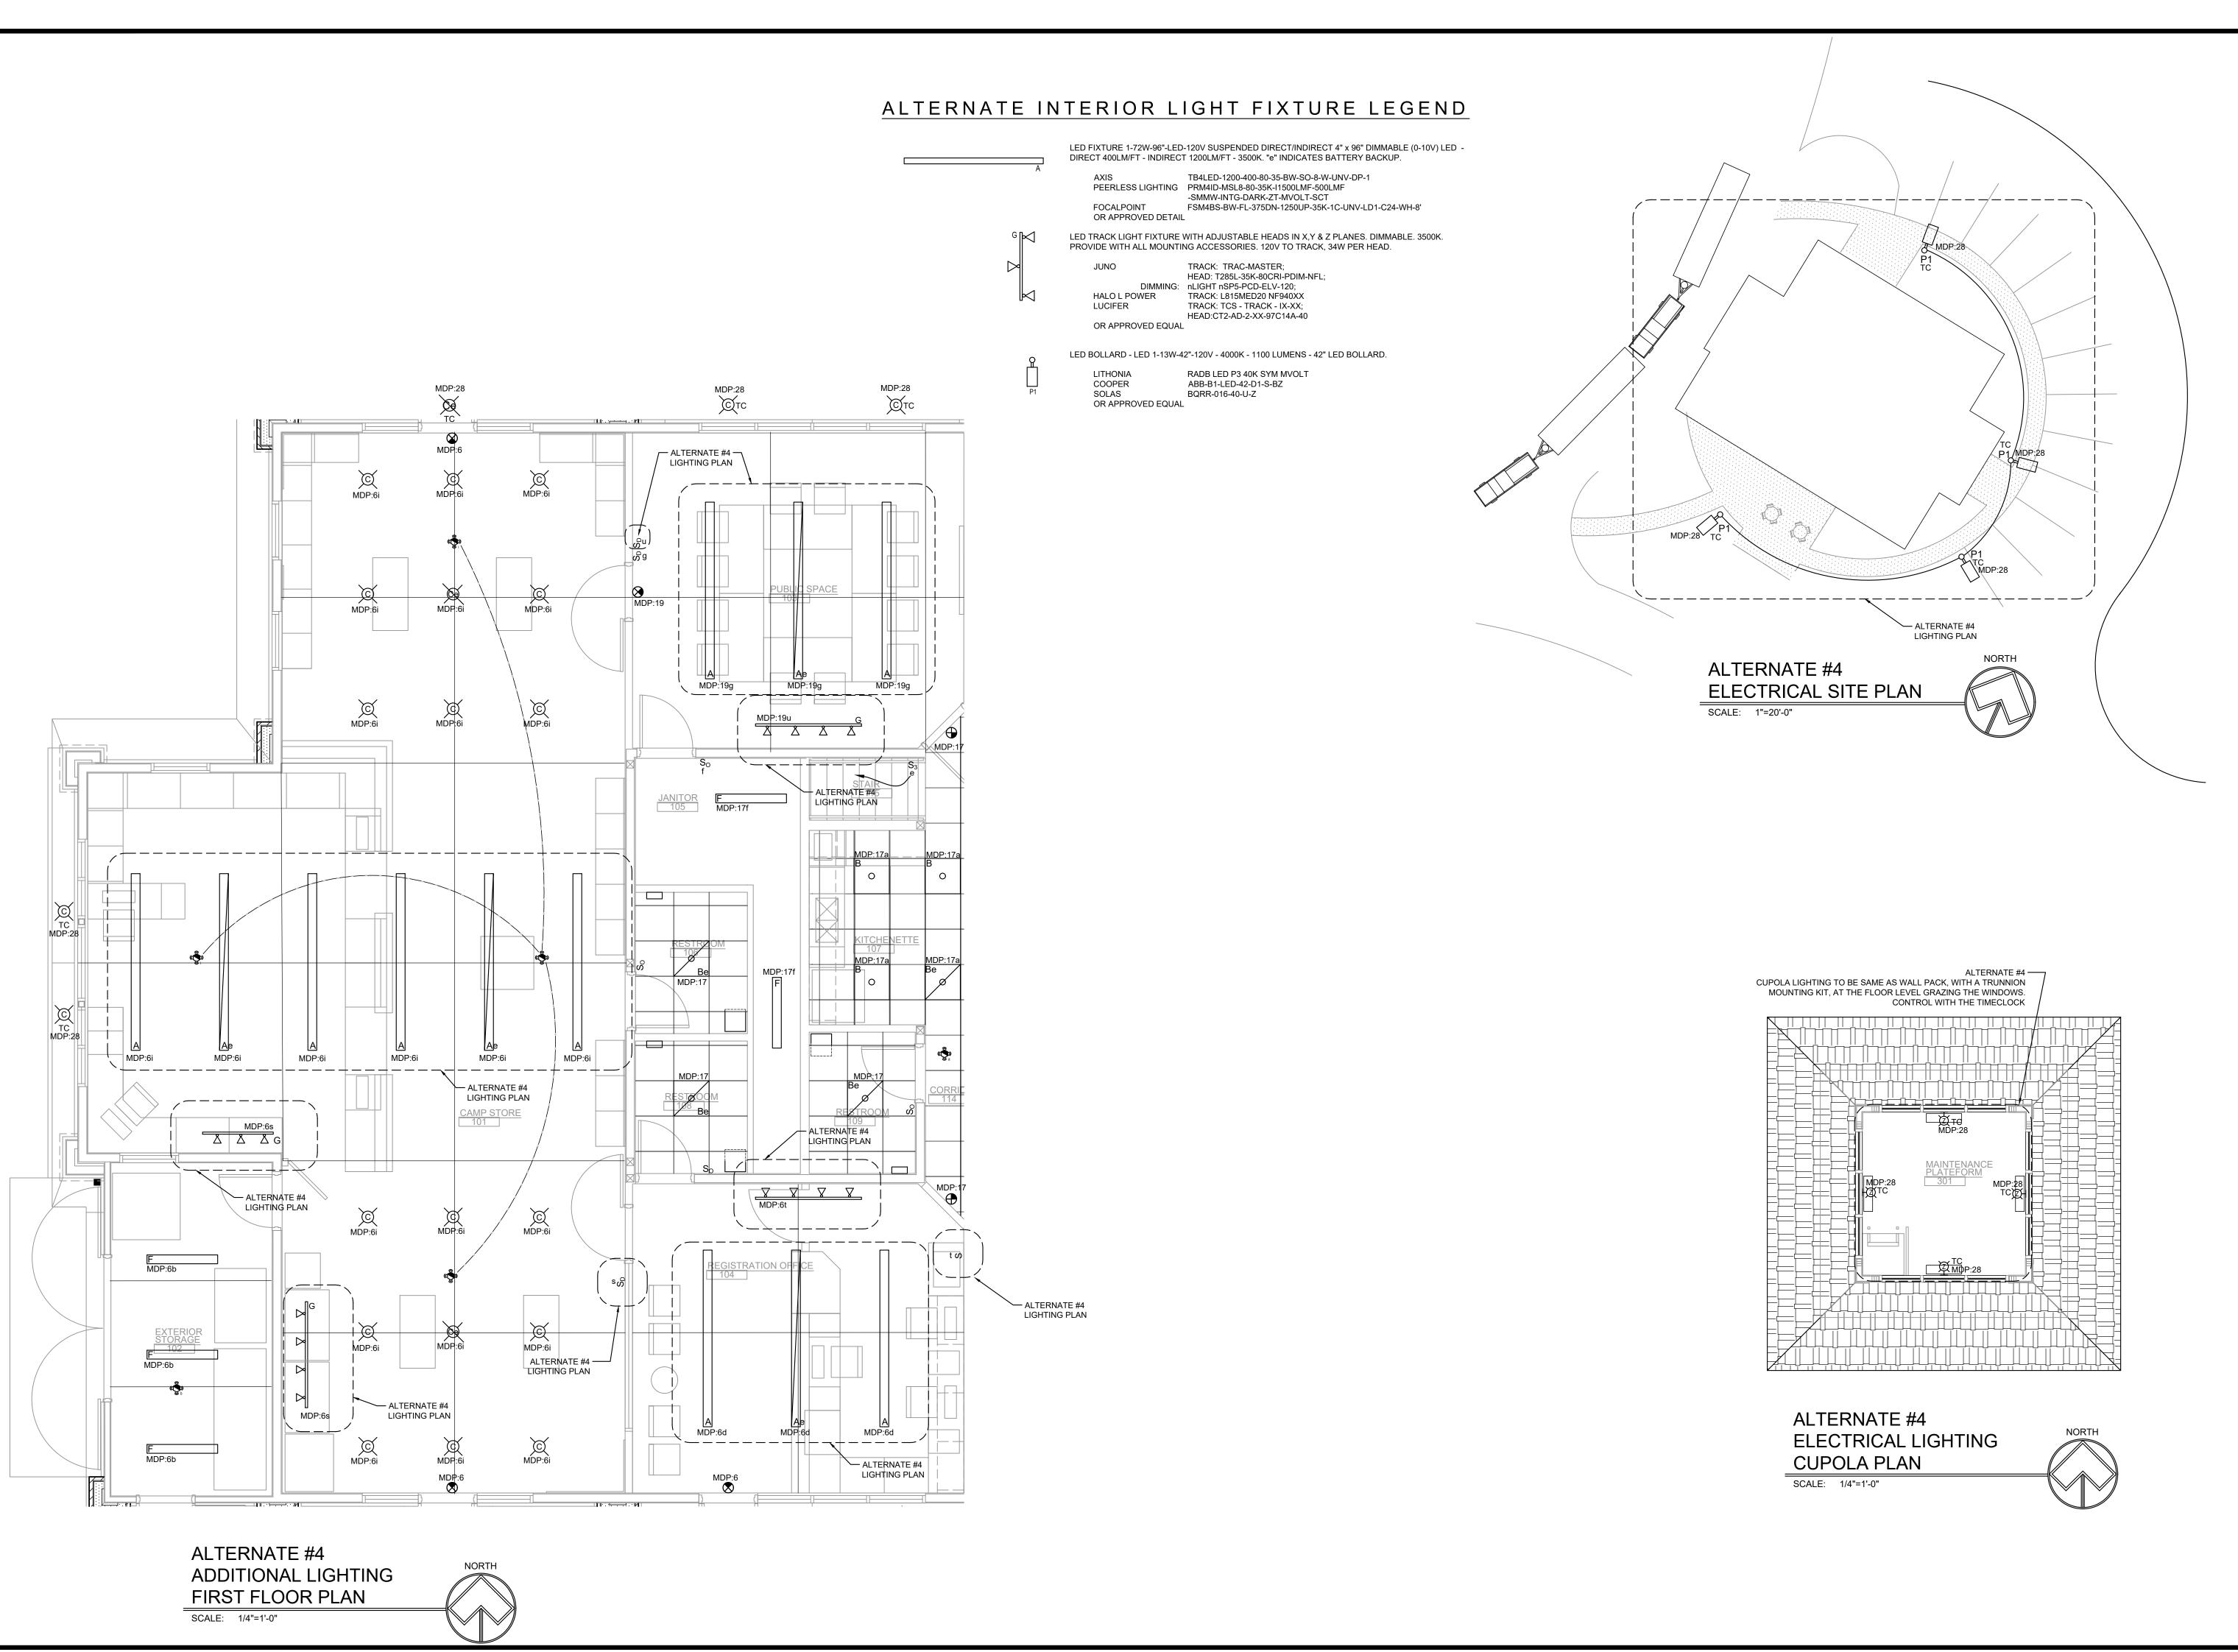

OFFICE PARK O FOR TMENT (CES DNF

ering



ISSUE DATE: 09/19/2025

JOB NUMBER: 241224

CONSTRUCTION DOCUMENTS

E500.