




ALL PLANS, DRAWINGS, SPECIFICATIONS, SCHEDULES AND OTHER INSTRUMENTS OF SERVICE, INCLUDING ELECTRICAL, MECHANICAL, PLUMBING, AND HVAC, SHALL BE THE PROPERTY OF BENCO. BENCO RESERVES THE RIGHT TO MODIFY OR AMEND ANY INSTRUMENT OF SERVICE AT ANY TIME WITHOUT NOTICE. BENCO SHALL NOT BE RESPONSIBLE FOR ANY INSTRUMENTS OF SERVICE THAT ARE NOT SHOWN ON THESE PLANS. BENCO SHALL NOT BE RESPONSIBLE FOR ANY INSTRUMENTS OF SERVICE THAT ARE NOT SHOWN ON THESE PLANS. BENCO SHALL NOT BE RESPONSIBLE FOR ANY INSTRUMENTS OF SERVICE THAT ARE NOT SHOWN ON THESE PLANS.

### DENTAL EQUIPMENT LEGEND

ITEM	DESCRIPTION	STATUS	LOCATION
1	MIDMARK P32 AIR COMPRESSOR	EXT	MECH. ROOM
2	RAM VAC AREAS 8 AIR COMPRESSOR	NEW	MECH. ROOM
3	AIR TECH MOJAVE V7M VACUUM PUMP	NEW	MECH. ROOM
4	AIR TECH ACADIA PLUS AMALGAM SEPARATOR	NEW	MECH. ROOM
5	AJAX REMOTE WATER CONTROL VALVE	NEW	MECH. ROOM
6	AIR TECH. 3-BUTTON REMOTE CONTROL PANEL (A/W/V)	NEW	TEAM ROOM
7	ADEC DECADE DENTAL CHAIR W/ SWING MTD LIGHT, DRS/ASST DELIV	EXT	HYG #1-3
8	PELTON & CRANE DENTAL CHAIR W/SWING MTD LIGHT, DRS/ASST DELIV	EXT	HYG #4
9	MIDMARK DENTAL CHAIR W/SWING MTD LIGHT, DRS/ASST DELIV	EXT	SURGERY
10	AJAX AJ16 DENTAL CHAIR W/ MTD DRS/ASST DELIV	NEW/FUT	TR #1-7
11	MODULAR 36" CUSTOM REAR CABINETS	NEW	HYG #1-4
12	MODULAR 42" CUSTOM REAR CABINETS	NEW/FUT	TR #1-7
13	GENDEX 770 INTRAORAL X-RAY w/ 72" REACH	EXT	HYG #1-4 & SURGERY
14	DEXIS FOCUS INTRAORAL X-RAY w/ 75" REACH	EXT	TR #1-7
15	SIRONA 2D PAN X-RAY	EXT	PAN
16	MODULAR 12' DIRTY CUSTOM STERILIZATION CENTER	NEW	STERILE
17	MODULAR 11' 2" CLEAN CUSTOM STERILIZATION CENTER	NEW	STERILE
18	MISCELLANEOUS STERILIZATION EQUIPMENT: QUICKCLEAN ULTRASONIC, STATCLAVE AUTOCLAVE, M11 AUTOCLAVE, & VISTAPURE	EXT/NEW	STERILE (VERIFY LOCATIONS)
19	MISCELLANEOUS LAB EQUIPMENT: DISPOSABLE PLASTER TRAP, MODEL TRIMMER, & LATHE	EXT	LAB (VERIFY LOCATIONS)
-	NOMAD HANDHELD XRAY	EXT	-
-	REMAINING MISCELLANEOUS CABINETRY & MILLWORK BY OTHERS	NEW	AS SHOWN ON EQUIPMENT PLAN

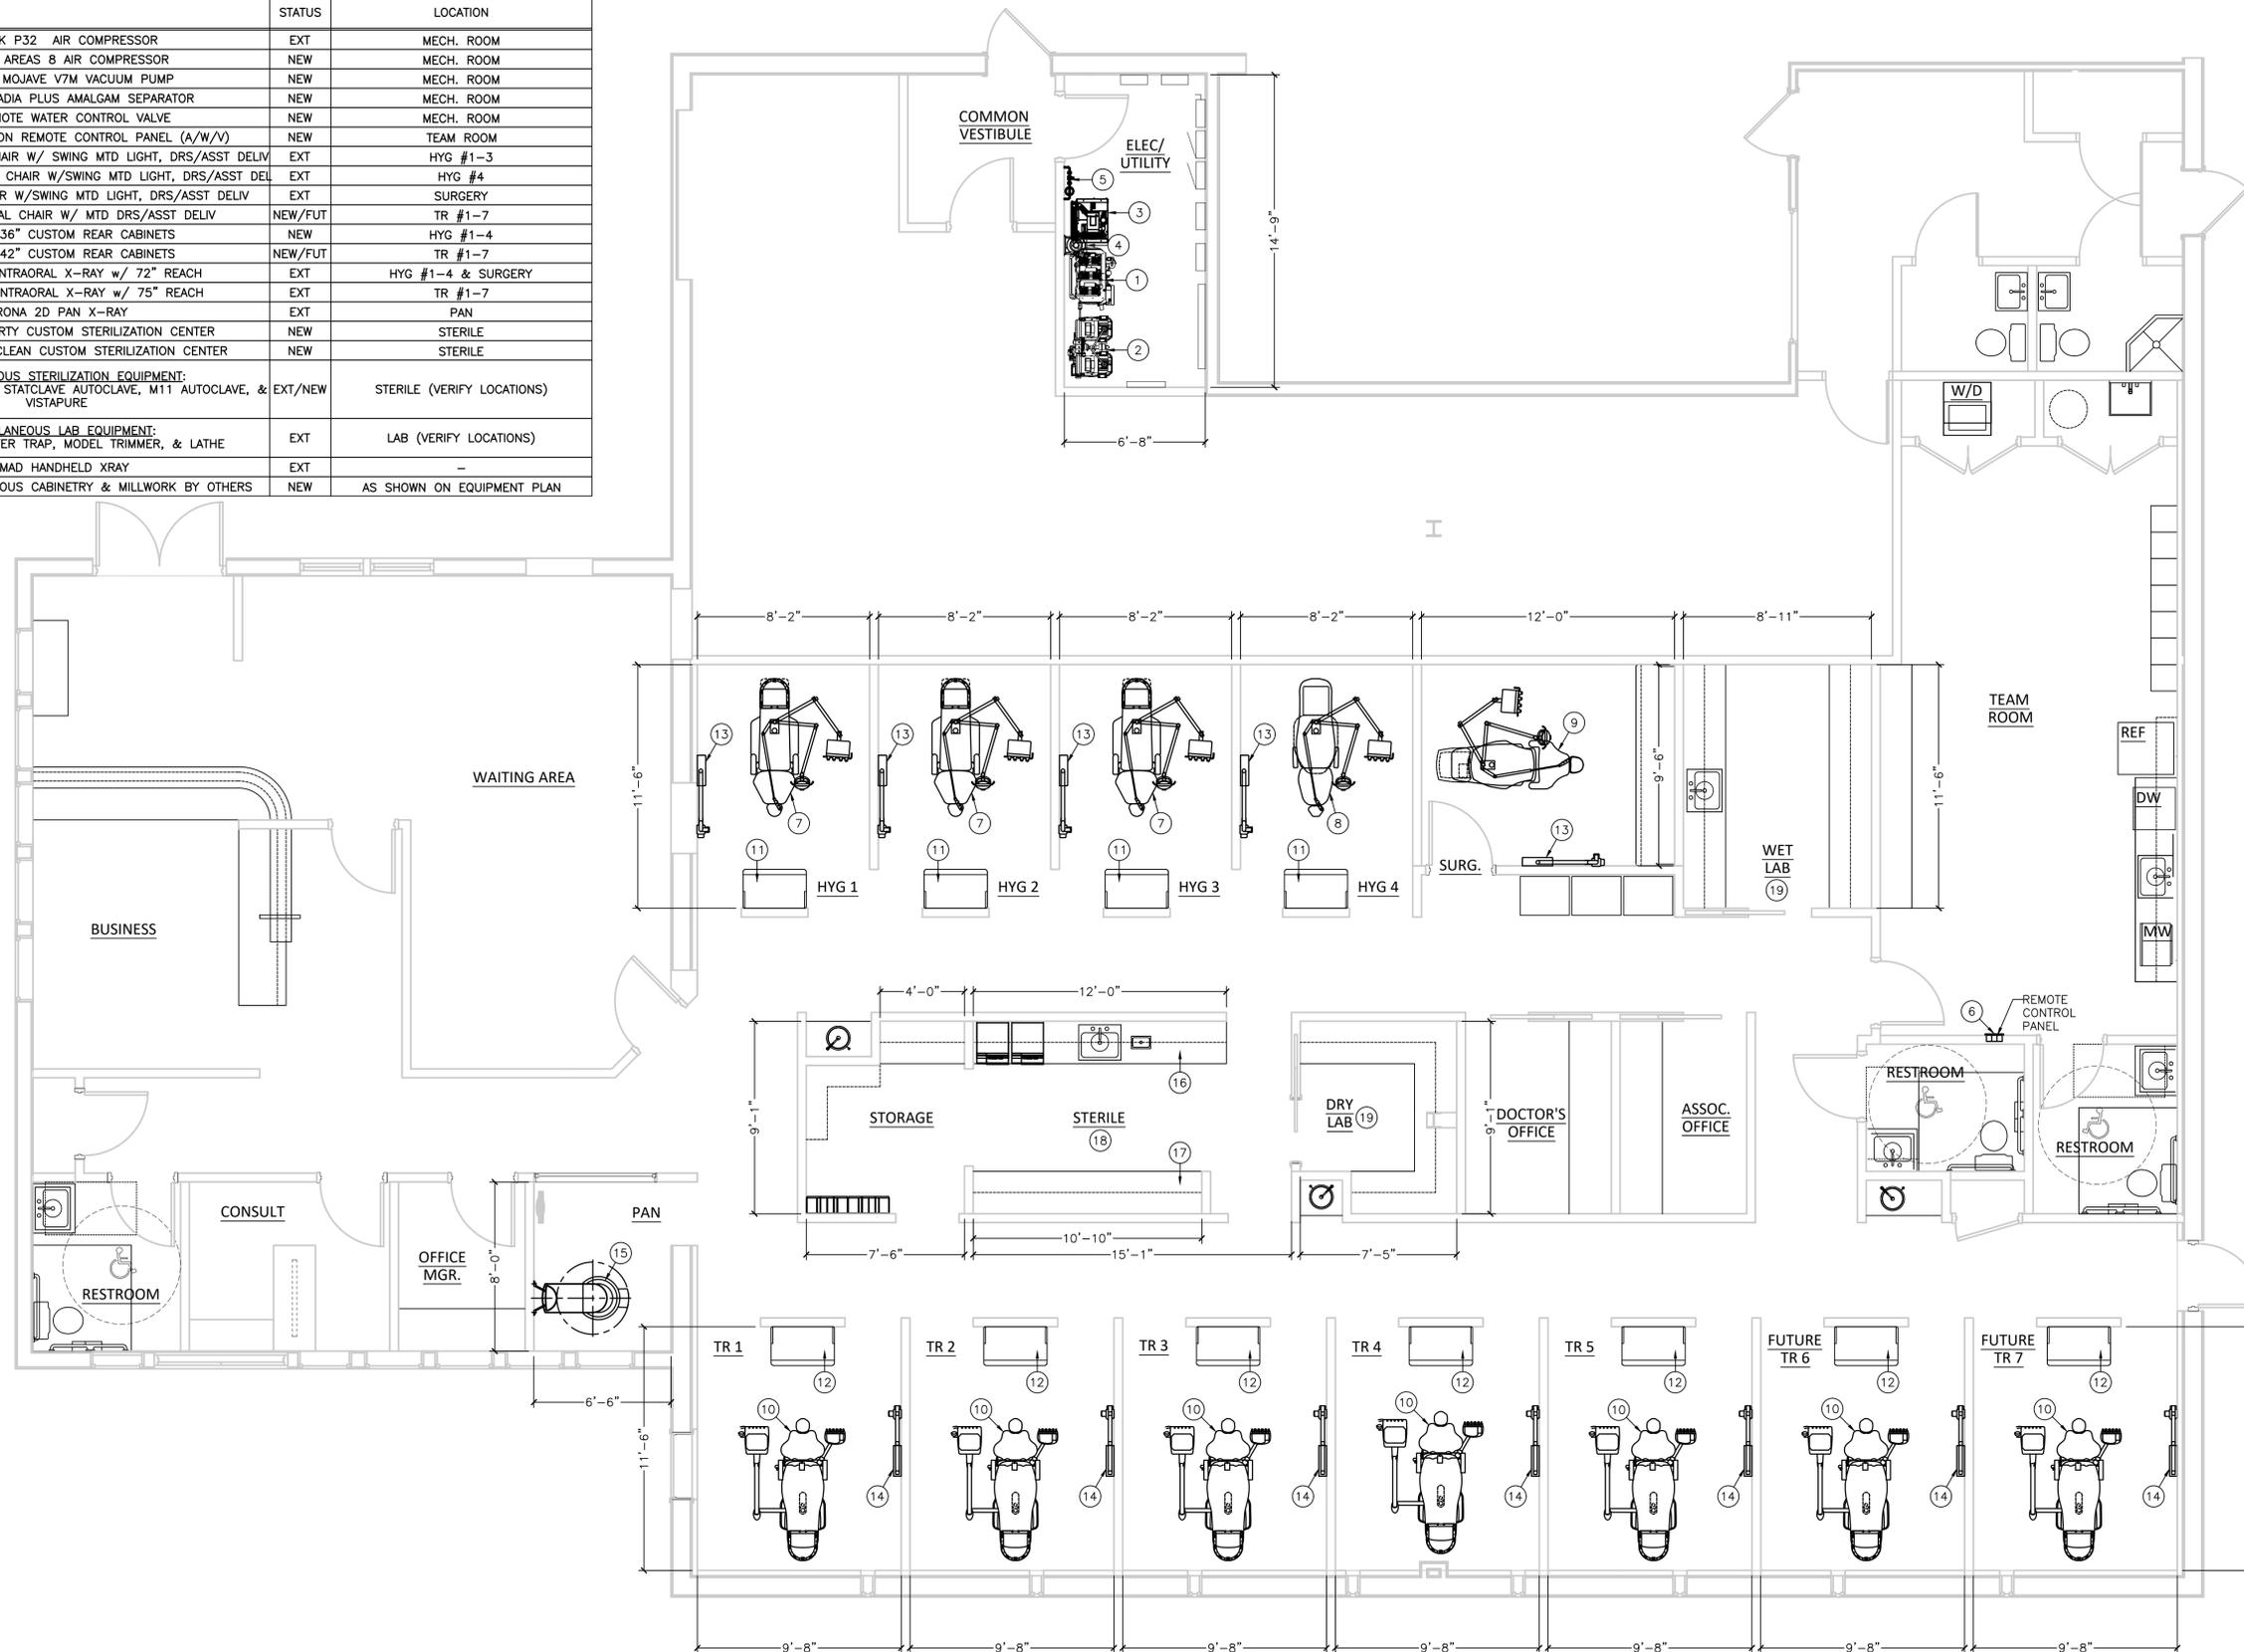

**1 DENTAL EQUIPMENT PLAN**  
SCALE: 1/4" = 1'-0"



**WHARTON DENTAL**  
1718 W. High St.  
Piqua, Ohio 45356

ISSUED:	DATE:
ZONE STUDY	MM/DD/YY
DESIGN SCHEMATIC REV 5	11/10/2025
EDS	MM/DD/YY
DCD (FOR REVIEW)	01/08/2026
DCD	01/08/2026
DCD REV 1	01/14/2026


PROJECT #:	CHECKED BY:
26-OV31753-TH	TH
DRAWN BY / REVIEWED BY:	
EM	

DRAWING TITLE:	SHEET:
DENTAL EQUIPMENT PLAN	Q1.1

ALL PLANS, DRAWINGS, SPECIFICATIONS, SCHEDULES AND OTHER INSTRUMENTS OF SERVICE, INCLUDING ELECTRICAL, MECHANICAL, PLUMBING, AND HVAC, SHALL BE THE INSTRUMENTS OF SERVICE FOR ANY PERMITS, ORDINANCES, REGULATIONS, AND ANY OTHER APPLICABLE CODES, STANDARDS, AND GOOD PRACTICE. THE INSTRUMENTS OF SERVICE FOR ANY PERMITS, ORDINANCES, REGULATIONS, AND ANY OTHER APPLICABLE CODES, STANDARDS, AND GOOD PRACTICE, SHALL BE THE INSTRUMENTS OF SERVICE FOR ANY PERMITS, ORDINANCES, REGULATIONS, AND ANY OTHER APPLICABLE CODES, STANDARDS, AND GOOD PRACTICE. THE INSTRUMENTS OF SERVICE FOR ANY PERMITS, ORDINANCES, REGULATIONS, AND ANY OTHER APPLICABLE CODES, STANDARDS, AND GOOD PRACTICE, SHALL BE THE INSTRUMENTS OF SERVICE FOR ANY PERMITS, ORDINANCES, REGULATIONS, AND ANY OTHER APPLICABLE CODES, STANDARDS, AND GOOD PRACTICE.

**CARPENTRY NOTES**

1. THE DRAWING IS DIMENSIONED FROM THE FACE OF A FINISH WALL TO THE FACE OF A FINISH WALL, UNLESS OTHERWISE NOTED. THE DENTAL EQUIPMENT WILL BE DIMENSIONED FROM THE FACE OF A FINISH WALL TO THE CENTERLINE OF THE EQUIPMENT, UNLESS OTHERWISE NOTED.
2. PARTITIONS SHOWN ARE 5" NOMINAL.
3. ALL BLOCKING WILL BE INSTALLED FLUSH WITH THE FACE OF THE STUDS.
4. THE GENERAL CONTRACTOR WILL BE RESPONSIBLE TO BRACE AND PROTECT ALL WORK DURING CONSTRUCTION AGAINST DAMAGE, BREAKAGES, COLLAPSE, DISTORTIONS, AND OFF-ALIGNMENT ACCORDING TO APPLICABLE CODES, STANDARDS, AND GOOD PRACTICE.
5. THE CARPENTER WILL BE RESPONSIBLE FOR BOTH THE STRUCTURAL INTEGRITY AND THE STABILITY OF ALL BLOCKING AND WALL SUPPORT.
6. THE CARPENTER WILL COMPLY WITH ALL BENCO INSPECTIONS, AS NOTED IN THE GENERAL NOTES IN THE FIRST SECTION OF THESE DOCUMENTS.
7. VERIFY LOCAL & STATE X-RAY SHIELDING REQUIREMENTS WITH ARCHITECT, CONTRACTOR OR CLIENT.

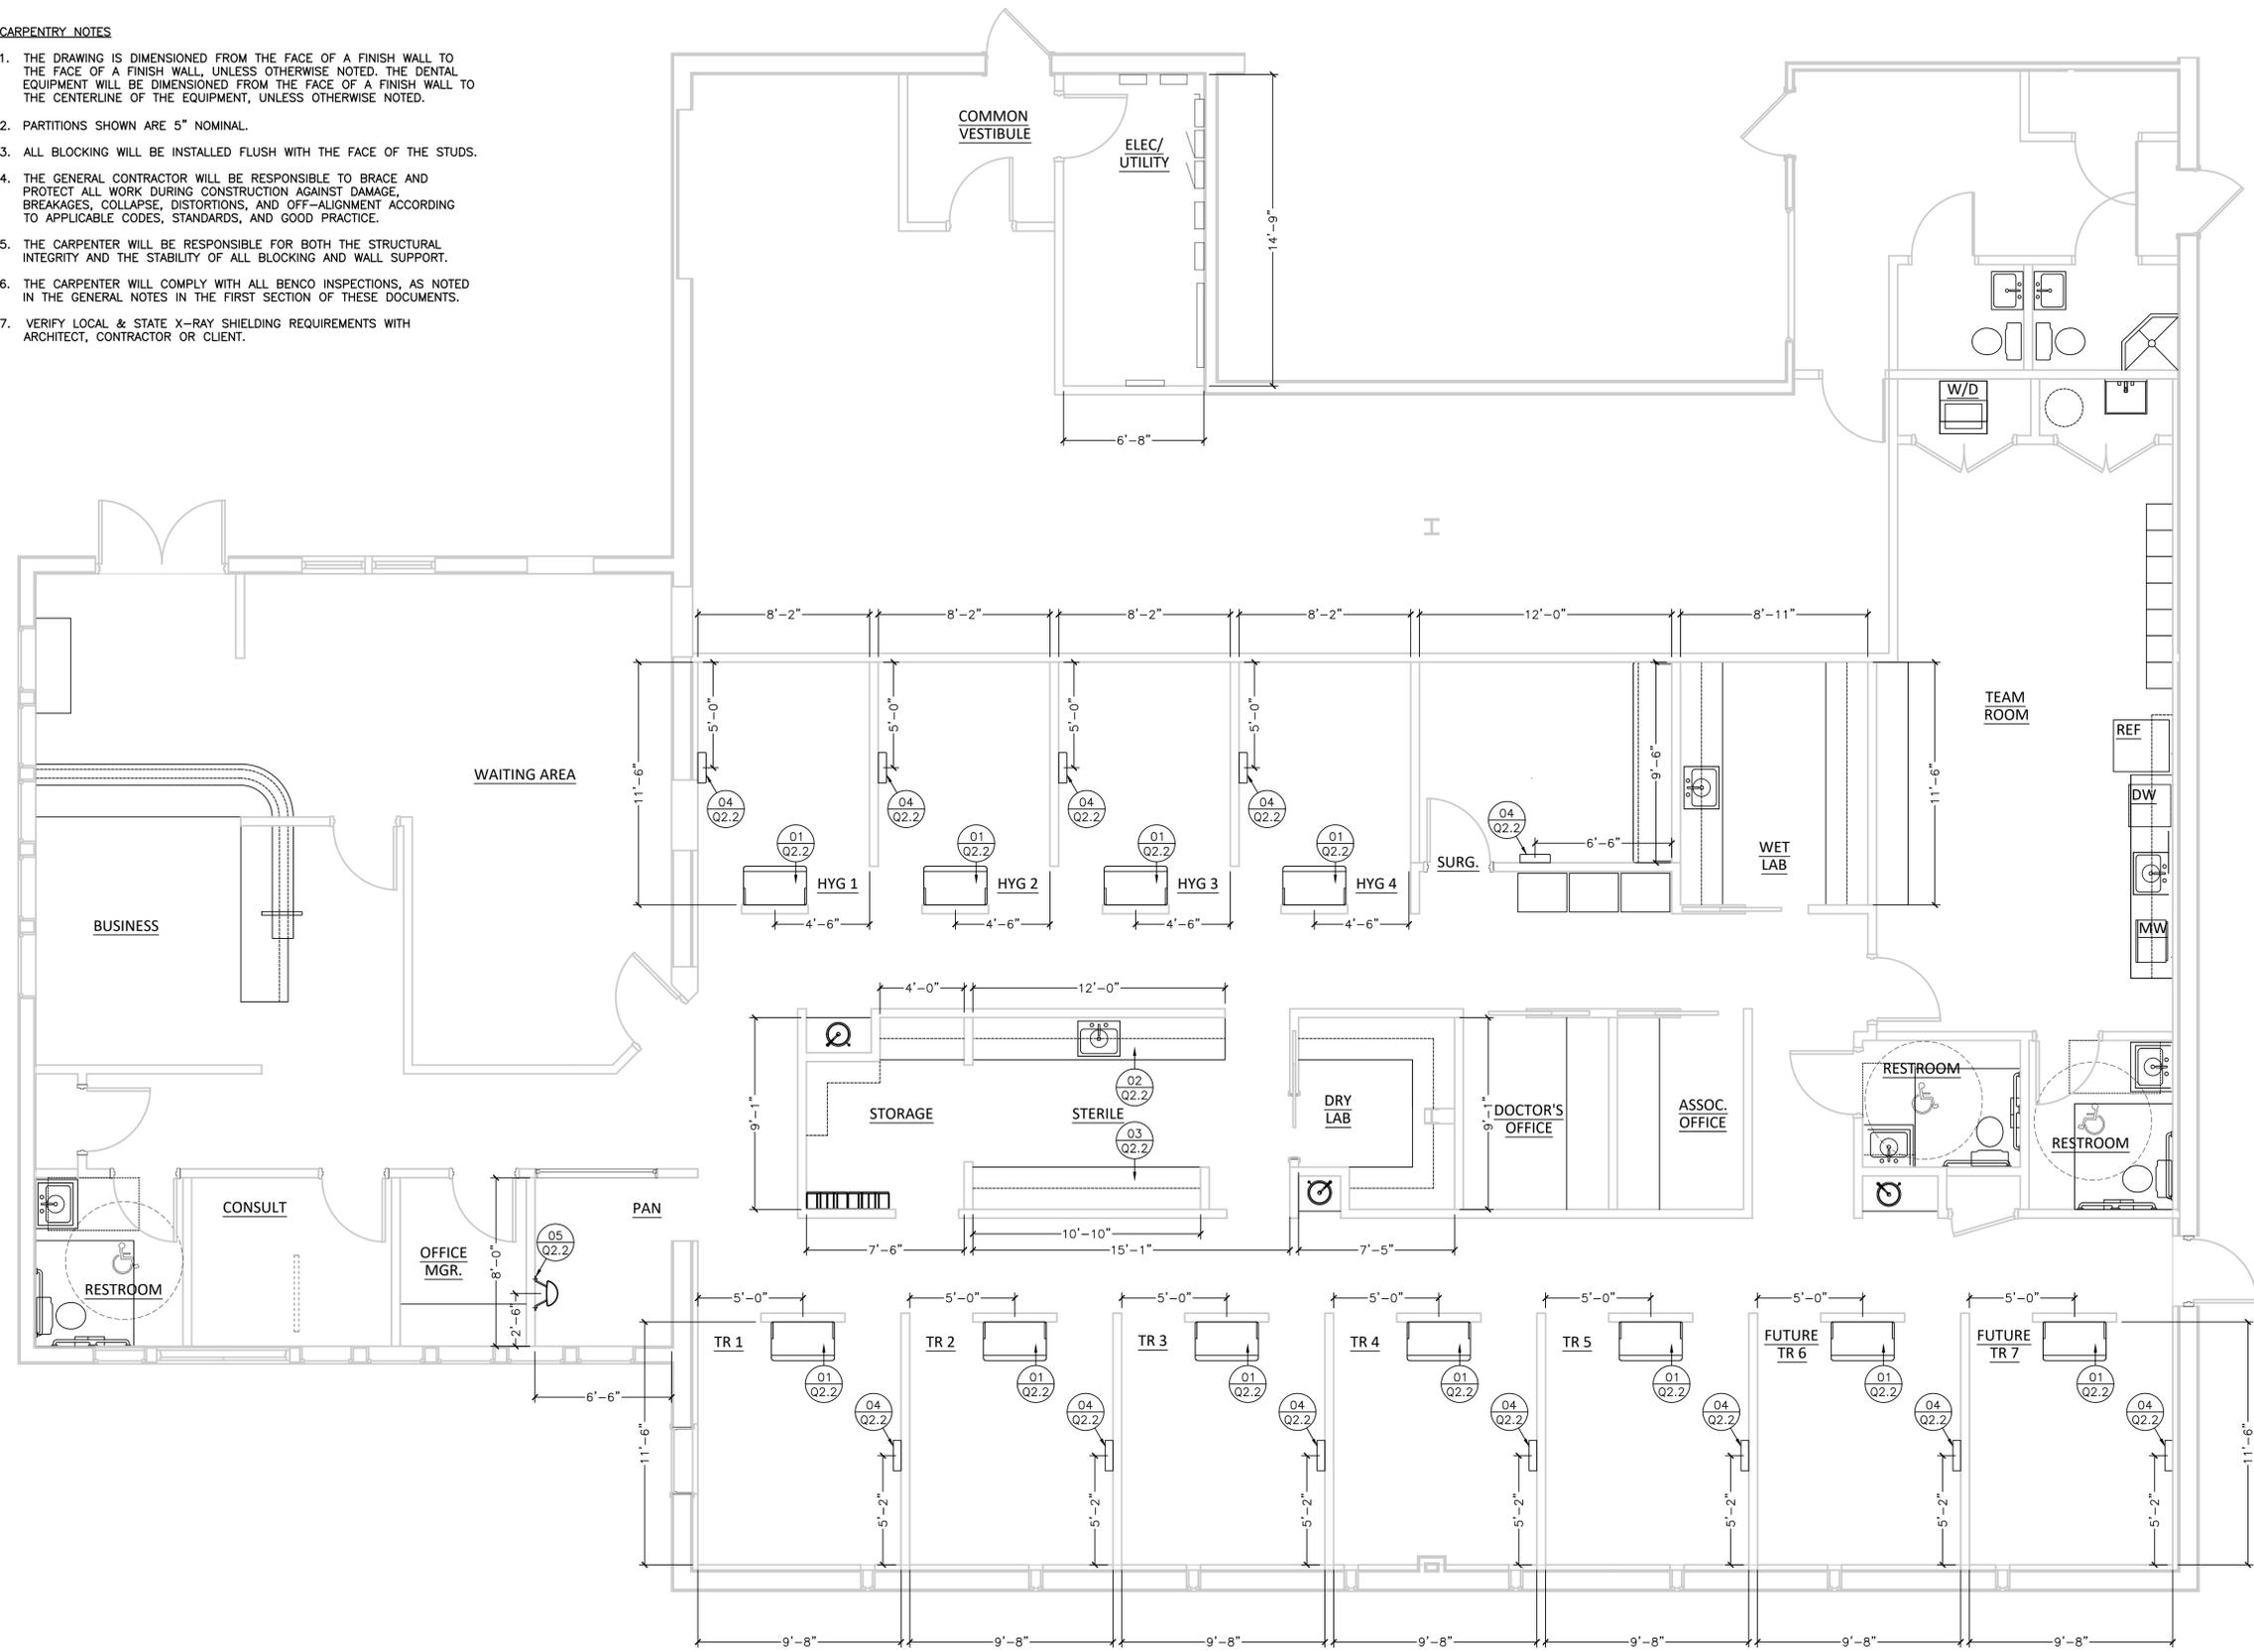

**1 DENTAL CARPENTRY PLAN**  
SCALE: 1/4" = 1'-0"



**WHARTON DENTAL**  
1718 W. High St.  
Piqua, Ohio 45356

ISSUED:	DATE:
ZONE STUDY	MM/DD/YY
DESIGN SCHEMATIC REV 5	11/10/2025
EDS	MM/DD/YY
DCD (FOR REVIEW)	01/08/2026
DCD	01/08/2026
DCD REV 1	01/14/2026

PROJECT #:	DATE:
26-OV31753-TH	
DRAWN BY / REVIEWED BY:	CHECKED BY:
EM	TH

DRAWING TITLE:  
**DENTAL CARPENTRY PLAN**  
SHEET:  
**Q2.1**



**MCC** Modular & Custom Cabinets  
 PHONE: (905) 832-8311  
 FAX: (905) 832-0732

**CUSTOM REAR Hyg Ops**

**YELLOW COPY**  
By CAD OFFICE

DEALER: BENCO DENTAL  
 LOC:  
 DOCTOR: WHARTON DENTAL / CRAIG  
 P.O.#: 57071061  
 W/O #: UQ23928  
 P/O DATE: 31 DEC 2025  
 PROCESS DATE: 08 JAN 2026  
 APPROX SHIP:  
**SET UPS: 4**  
 TOP COLOUR: Snow White - 033A  
 1/2" THICK  
 CAB COLOUR: Wilkinson RainHigh Walnut 17019K-67  
**TOE KICK: PLYWOOD BASE WITH STAINLESS STEEL LAMINATE**  
 HANDLES: ALLURE HANDLES  
 PVC EDGE: MATCH  
 HARDWARE: SOFT CLOSE DOORS  
 METABOX DRAWERS  
 SKETCH #: UQ23928 - Q01-4  
 OPTIONS INCLUDED:  
 MCCPINSID SLIDING MONITOR MOUNT  
 0001 GLOVE BOX INSERTS  
 MBS100 MEDIUM WASTE PAIL 7.30" X 11" X 12" 100 LIT (65% FOR SINK, 35% FOR STERIL) MBS WASTE DRIP

155 DEGREE HINGES ON ALL DOORS (EXCEPT STERI SINK CABINETS)

11/19/26

NOTE: PLUMBING & ELECTRICAL SPECS WILL BE PROVIDED AT THE TIME OF ORDER. PLUMBING & ELECTRICAL HOODS NOT BY MCC.

REVISIONS: 10 OCT 2025 18 DEC 2025 12 DEC 2025 23 DEC 2025 15 DEC 2025

CONFIRM THIS ORDER TO BE CORRECT: DEALER AUTHORIZED SIGNATORY / DATE

MCC RESERVES THE RIGHT TO CHANGE / MODIFY CABINET DESIGNS WITHOUT NOTICE. DUPLICATION OF MCC DESIGNS ARE PROHIBITED. NO CHANGES WILL BE ACCEPTED AFTER ORDER IS RECEIVED WITHOUT WRITTEN CONSENT FROM MCC.

**MCC** Modular & Custom Cabinets  
 PHONE: (905) 832-8311  
 FAX: (905) 832-0732

**CUSTOM REAR Treatment Ops and Surgery Op**

**YELLOW COPY**  
By CAD OFFICE

AGAINST WALL, UNFINISHED BACK.

DEALER: BENCO DENTAL  
 LOC:  
 DOCTOR: WHARTON DENTAL / CRAIG  
 P.O.#: 57071061  
 W/O #: UQ23928  
 P/O DATE: 31 MARCH 2025  
 PROCESS DATE: 08 JAN 2026  
 APPROX SHIP:  
**SET UPS: 5**  
 TOP COLOUR: Snow White - 033A  
 1/2" THICK  
 CAB COLOUR: Wilkinson RainHigh Walnut 17019K-67  
**TOE KICK: PLYWOOD BASE WITH STAINLESS STEEL LAMINATE**  
 HANDLES: ALLURE HANDLES  
 PVC EDGE: MATCH  
 HARDWARE: SOFT CLOSE DOORS  
 METABOX DRAWERS  
 SKETCH #: UQ23928 - Q04-5  
 OPTIONS INCLUDED:  
 MCCPINSID SLIDING MONITOR MOUNT  
 0001 GLOVE BOX INSERTS  
 MBS100 MEDIUM WASTE PAIL 7.30" X 11" X 12" 100 LIT (65% FOR SINK, 35% FOR STERIL) MBS WASTE DRIP

155 DEGREE HINGES ON ALL DOORS (EXCEPT STERI SINK CABINETS)

11/19/26

NOTE: PLUMBING & ELECTRICAL SPECS WILL BE PROVIDED AT THE TIME OF ORDER. PLUMBING & ELECTRICAL HOODS NOT BY MCC.

REVISIONS: 10 OCT 2025 18 DEC 2025 12 DEC 2025 23 DEC 2025 15 DEC 2025

CONFIRM THIS ORDER TO BE CORRECT: DEALER AUTHORIZED SIGNATORY / DATE

MCC RESERVES THE RIGHT TO CHANGE / MODIFY CABINET DESIGNS WITHOUT NOTICE. DUPLICATION OF MCC DESIGNS ARE PROHIBITED. NO CHANGES WILL BE ACCEPTED AFTER ORDER IS RECEIVED WITHOUT WRITTEN CONSENT FROM MCC.

**MCC** Modular & Custom Cabinets  
 PHONE: (905) 832-8311  
 FAX: (905) 832-0732

**CUSTOM STERI**

**YELLOW COPY**  
By CAD OFFICE

DEALER: BENCO DENTAL  
 LOC:  
 DOCTOR: WHARTON DENTAL / CRAIG  
 P.O.#: 57071061  
 W/O #: UQ23928  
 P/O DATE: 31 MARCH 2025  
 PROCESS DATE: 08 JAN 2026  
 APPROX SHIP:  
**SET UPS: 1**  
 TOP COLOUR: M024 Modern Concrete  
 1/2" THICK  
 CAB COLOUR: Glossy White AGT 601 / 5000B  
**TOE KICK: PLYWOOD BASE WITH STAINLESS STEEL LAMINATE**  
 HANDLES: ALLURE HANDLES  
 PVC EDGE: MATCH  
 HARDWARE: SOFT CLOSE DOORS  
 METABOX DRAWERS  
 SKETCH #: UQ23928 - Q05-4  
 OPTIONS INCLUDED:  
 "UNDERMOUNT"  
 MBS100 ST SINK 23.5" X 18" X 18" 100 LIT  
 MBS100 ON FANJET MBS100 GSK  
 MBS100 EXTRA LARGE WASTE PAIL 11" X 15" X 20" 140 LIT  
 MBS100 MULTI-FOLD TOWEL DISP. 6000 L GLOVE BOX INSERTS

155 DEGREE HINGES ON ALL DOORS (EXCEPT STERI SINK CABINETS)

OVERALL DIMENSIONS:  
 LENGTH: 144"  
 DEPTH: 25 1/8"  
 TOTAL HEIGHT: 83"

11/19/26

NOTE: PLUMBING & ELECTRICAL SPECS WILL BE PROVIDED AT THE TIME OF ORDER. PLUMBING & ELECTRICAL HOODS NOT BY MCC.

REVISIONS: 10 OCT 2025 18 DEC 2025 12 DEC 2025 23 DEC 2025 15 DEC 2025

CONFIRM THIS ORDER TO BE CORRECT: DEALER AUTHORIZED SIGNATORY / DATE

MCC RESERVES THE RIGHT TO CHANGE / MODIFY CABINET DESIGNS WITHOUT NOTICE. DUPLICATION OF MCC DESIGNS ARE PROHIBITED. NO CHANGES WILL BE ACCEPTED AFTER ORDER IS RECEIVED WITHOUT WRITTEN CONSENT FROM MCC.

**MCC** Modular & Custom Cabinets  
 PHONE: (905) 832-8311  
 FAX: (905) 832-0732

**CUSTOM STERI**

**YELLOW COPY**  
By CAD OFFICE

155 DEGREE HINGES ON ALL DOORS (EXCEPT STERI SINK CABINETS)

DEALER: BENCO DENTAL  
 LOC:  
 DOCTOR: WHARTON DENTAL / CRAIG BRUNS  
 P.O.#: 57071061  
 W/O #: UQ23928  
 P/O DATE: 31 MARCH 2025  
 PROCESS DATE: 08 JAN 2026  
 APPROX SHIP:  
**SET UPS: 1**  
 TOP COLOUR: M024 Modern Concrete  
 1/2" THICK  
 CAB COLOUR: Glossy White AGT 601 / 5000B  
**TOE KICK: PLYWOOD BASE WITH STAINLESS STEEL LAMINATE**  
 HANDLES: ALLURE HANDLES  
 PVC EDGE: MATCH  
 HARDWARE: SOFT CLOSE DOORS  
 METABOX DRAWERS  
 SKETCH #: UQ23928 - Q05-4

6" TOE KICK

11/19/26

NOTE: PLUMBING & ELECTRICAL SPECS WILL BE PROVIDED AT THE TIME OF ORDER. PLUMBING & ELECTRICAL HOODS NOT BY MCC.

REVISIONS: 10 OCT 2025 18 DEC 2025 12 DEC 2025 23 DEC 2025 15 DEC 2025

CONFIRM THIS ORDER TO BE CORRECT: DEALER AUTHORIZED SIGNATORY / DATE

MCC RESERVES THE RIGHT TO CHANGE / MODIFY CABINET DESIGNS WITHOUT NOTICE. DUPLICATION OF MCC DESIGNS ARE PROHIBITED. NO CHANGES WILL BE ACCEPTED AFTER ORDER IS RECEIVED WITHOUT WRITTEN CONSENT FROM MCC.

**MCC** Modular & Custom Cabinets  
 PHONE: (905) 832-8311  
 FAX: (905) 832-0732

**CUSTOM STERI CLEAN SIDE**

**YELLOW COPY**  
By CAD OFFICE

DEALER: BENCO DENTAL  
 LOC:  
 DOCTOR: WHARTON DENTAL / CRAIG BRUNS  
 P.O.#: 57071061  
 W/O #: UQ23928  
 P/O DATE: 31 MARCH 2025  
 PROCESS DATE: 08 JAN 2026  
 APPROX SHIP:  
**SET UPS: 1**  
 TOP COLOUR: M024 Modern Concrete  
 1/2" THICK  
 CAB COLOUR: Glossy White AGT 601 / 5000B  
**TOE KICK: PLYWOOD BASE WITH STAINLESS STEEL LAMINATE**  
 HANDLES: #Allure Pull - 9350-128-BSN  
 PVC EDGE: MATCH  
 HARDWARE: SOFT CLOSE DOORS  
 FULL EXTENSION  
 SOFT CLOSE (DTC Double Wall)  
 SKETCH #: UQ23928 - Q08

6" TOE KICK

11/19/26

NOTE: PLUMBING & ELECTRICAL SPECS WILL BE PROVIDED AT THE TIME OF ORDER. PLUMBING & ELECTRICAL HOODS NOT BY MCC.

REVISIONS: 10 OCT 2025 18 DEC 2025 12 DEC 2025 23 DEC 2025 15 DEC 2025

CONFIRM THIS ORDER TO BE CORRECT: DEALER AUTHORIZED SIGNATORY / DATE

MCC RESERVES THE RIGHT TO CHANGE / MODIFY CABINET DESIGNS WITHOUT NOTICE. DUPLICATION OF MCC DESIGNS ARE PROHIBITED. NO CHANGES WILL BE ACCEPTED AFTER ORDER IS RECEIVED WITHOUT WRITTEN CONSENT FROM MCC.

**WHARTON DENTAL**  
 1718 W. High St.  
 Piqua, Ohio 45356

ISSUED:	DATE:
ZONE STUDY	MM/DD/YY
DESIGN SCHEMATIC REV 5	11/10/2025
EDS	MM/DD/YY
DCD (FOR REVIEW)	01/08/2026
DCD	01/08/2026
DCD REV 1	01/14/2026

PROJECT #:	DATE:
26-OV31753-TH	
DRAWN BY / REVIEWED BY:	CHECKED BY:
EM	TH


DRAWING TITLE:  
 DENTAL CABINET DRAWINGS

SHEET:  
 Q2.3

ALL PLANS, DRAWINGS, SPECIFICATIONS, SCHEDULES AND OTHER INSTRUMENTS OF SERVICE, INCLUDING ELECTRICAL, MECHANICAL, PLUMBING, AND HEATING, SHALL BE THE INSTRUMENTS OF SERVICE FOR ANY PURPOSES, INCLUDING BUT NOT LIMITED TO, BIDDING, CONSTRUCTION AND ANY OTHER PURPOSE. Benco Practice Design, Inc. (Benco) represents that the instruments of service have been prepared in accordance with applicable laws, rules, regulations and codes, and that Benco is not responsible for any errors, omissions, or other deficiencies in the instruments of service. Benco Practice Design, Inc. (Benco) represents that the instruments of service have been prepared in accordance with applicable laws, rules, regulations and codes, and that Benco is not responsible for any errors, omissions, or other deficiencies in the instruments of service. Benco Practice Design, Inc. (Benco) represents that the instruments of service have been prepared in accordance with applicable laws, rules, regulations and codes, and that Benco is not responsible for any errors, omissions, or other deficiencies in the instruments of service.

**ELECTRICAL NOTES**

- ALL EQUIPMENT WILL BE SINGLE PHASE, UNLESS OTHERWISE NOTED.
- ALL WIRING WILL BE CONCEALED WITHIN THE WALLS AND/OR FLOOR, UNLESS OTHERWISE NOTED.
- THE ELECTRICIAN WILL TAG ALL WIRES AT TERMINATION POINTS.
- THE ELECTRICIAN WILL REMOVE ALL EXISTING RECEPTACLES AND SWITCHES IN THE AREA OF WORK. THE ELECTRICIAN WILL EITHER INSTALL A BLANK PLATE OVER RECEPTACLE OR SWITCH BOX OR REMOVE BOX ENTIRELY. THE ELECTRICIAN WILL TERMINATE WIRING AND CONDUIT IN A MANNER IN ACCORDANCE WITH NATIONAL ELECTRICAL CODE.
- THE ELECTRICIAN WILL INSTALL COMPLETE AND MAKE FINAL HOOK-UP TO THE FOLLOWING DENTAL EQUIPMENT, SUPPLIED BY EITHER THE DOCTOR OR BENCO DENTAL, INCLUDING, BUT NOT LIMITED TO:
  - AIR COMPRESSOR
  - VACUUM PUMP
  - WATER CONTROL VALVE
  - CONTROL PANEL
- THE ELECTRICIAN WILL BE ONSITE ON THE DAY(S) OF INSTALLATION TO WORK WITH THE BENCO REPRESENTATIVE ON FINAL HOOK-UP. THE ELECTRICIAN WILL SUPPLY AND INSTALL ANY AND ALL MATERIALS INDICATED IN THE ELECTRICAL DETAILS SHOWN AND MANUFACTURER'S INSTALLATION INSTRUCTION SHEETS.
- IN THE EVENT OF ANY EQUIPMENT BEING RELOCATED TO ANOTHER LOCATION, ANY AND ALL CIRCUITS MUST BE TERMINATED BY THE ELECTRICIAN IN ACCORDANCE WITH LOCAL CODE. VERIFY RESPONSIBILITY WITH THE OWNER.
- THE ELECTRICIAN WILL SEAL ALL PENETRATIONS THROUGH THE FLOOR WITH A FIRESTOP OR EQUIVALENT WATERPROOFING.
- THE ELECTRICIAN WILL COMPLY WITH ALL BENCO INSPECTIONS, AS NOTED IN THE GENERAL NOTES ON THE FIRST PAGE OF THESE DOCUMENTS.
- ALL 120 VOLT, 20 AMP OUTLETS INSTALLED WITHIN 6 FEET OF A SINK AND THOSE LOCATED OUTDOORS SHALL HAVE GFCI PROTECTION.
- ALL 120 VOLT, 20 AMP DENTAL EQUIPMENT OUTLETS INSTALLED WITHIN 6 FEET OF A WATER SOURCE SHALL HAVE GFCI PROTECTION.

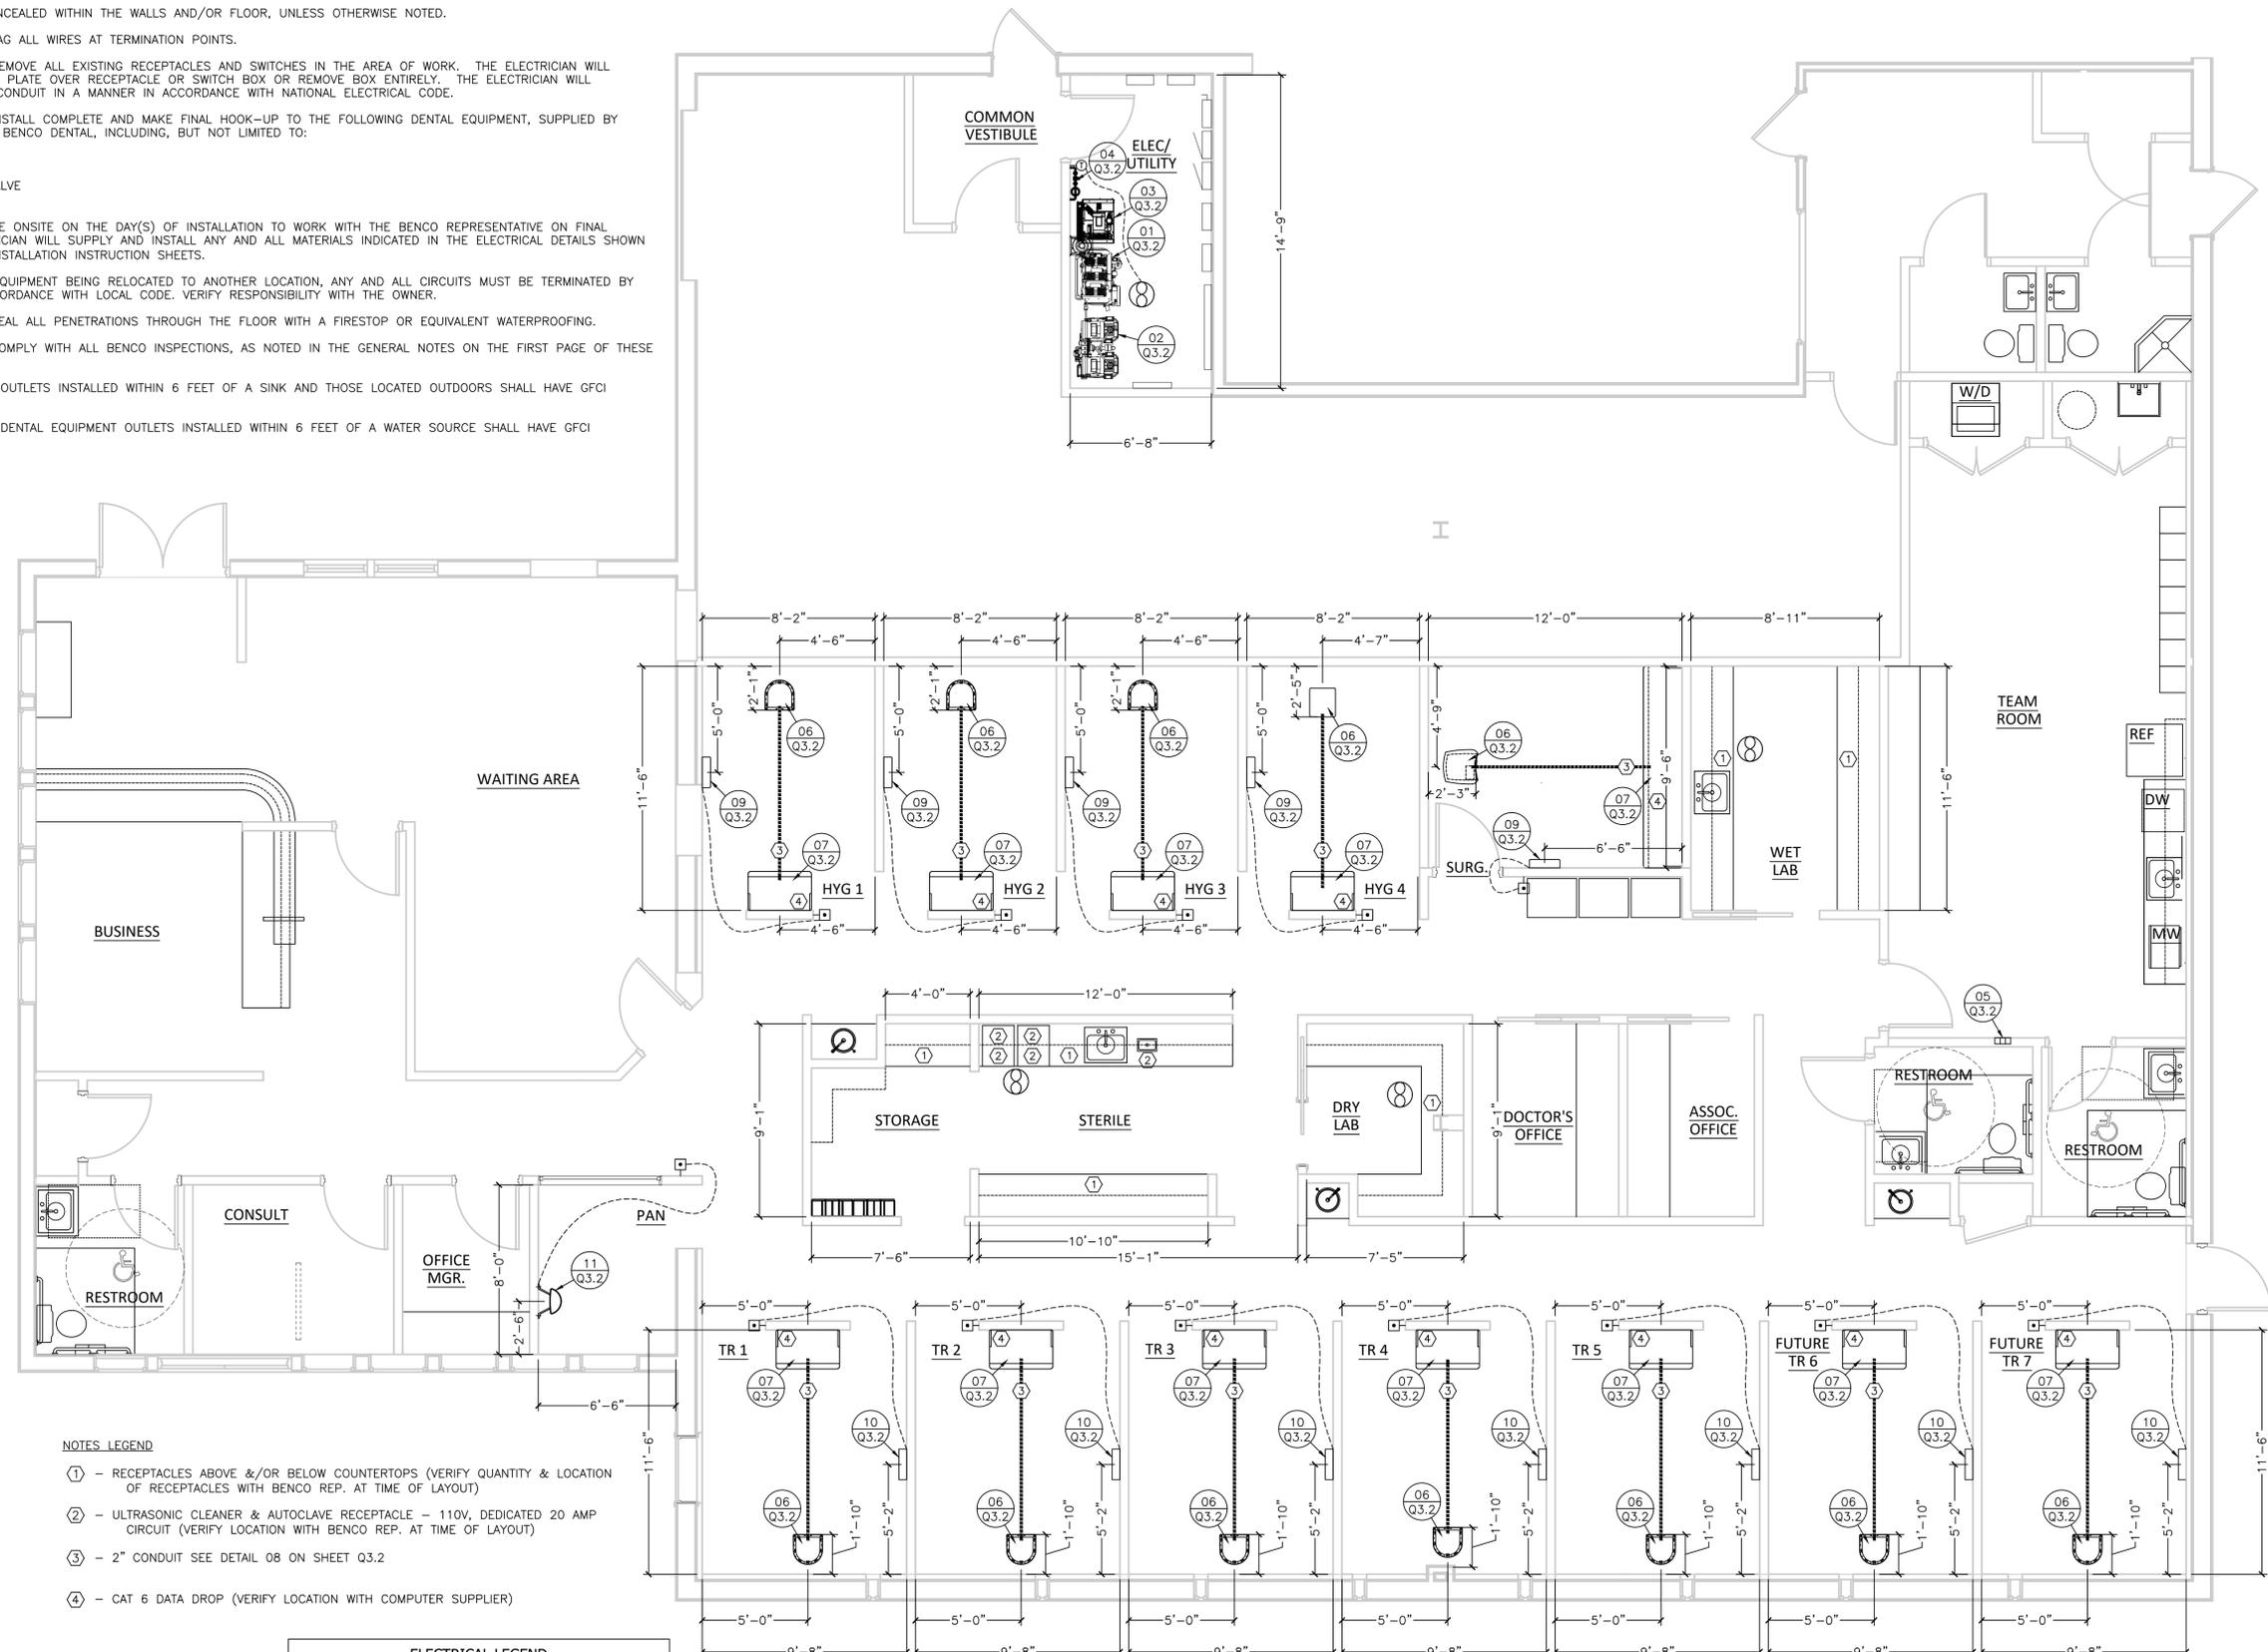

- NOTES LEGEND**
- ① - RECEPTACLES ABOVE &/OR BELOW COUNTERTOPS (VERIFY QUANTITY & LOCATION OF RECEPTACLES WITH BENCO REP. AT TIME OF LAYOUT)
  - ② - ULTRASONIC CLEANER & AUTOCLAVE RECEPTACLE - 110V, DEDICATED 20 AMP CIRCUIT (VERIFY LOCATION WITH BENCO REP. AT TIME OF LAYOUT)
  - ③ - 2" CONDUIT SEE DETAIL 08 ON SHEET Q3.2
  - ④ - CAT 6 DATA DROP (VERIFY LOCATION WITH COMPUTER SUPPLIER)

ELECTRICAL LEGEND	
SYMBOL	DESCRIPTION
⊕	THERMOSTATIC ON/OFF SWITCH
---	WIRING, CONCEALED IN WALL OR CEILING
⊗	EXHAUST FAN MOUNTED IN CEILING (VERIFY CFM REQUIREMENTS WITH ARCHITECT)
⊠	EXPOSURE BUTTON
----	CONDUIT, CONCEALED IN FLOOR

**1 DENTAL ELECTRICAL PLAN**  
SCALE: 1/4" = 1'-0"



**WHARTON DENTAL**  
1718 W. High St.  
Piqua, Ohio 45356

ISSUED:	DATE:
ZONE STUDY	MM/DD/YY
DESIGN SCHEMATIC REV 5	11/10/2025
EDS	MM/DD/YY
DCD (FOR REVIEW)	01/08/2026
DCD	01/08/2026
DCD REV 1	01/14/2026

















PROJECT #:	DRAWN BY / REVIEWED BY:	CHECKED BY:
26-OV31753-TH	EM	TH

DRAWING TITLE:  
**DENTAL ELECTRICAL PLAN**

SHEET:

**Q3.1**

ALL DRAWINGS, SPECIFICATIONS, SCHEDULES AND OTHER INSTRUMENTS OF SERVICE INCLUDING ELECTRICAL SCHEDULES, SHALL BE THE PROPERTY OF Benco. Benco reserves the right to make any amendments or changes to these instruments of service at any time without notice. Benco is not responsible for any errors or omissions in these instruments of service. Benco is not responsible for any damage to property or injury to persons resulting from the use of these instruments of service. Benco is not responsible for any damage to property or injury to persons resulting from the use of these instruments of service. Benco is not responsible for any damage to property or injury to persons resulting from the use of these instruments of service.

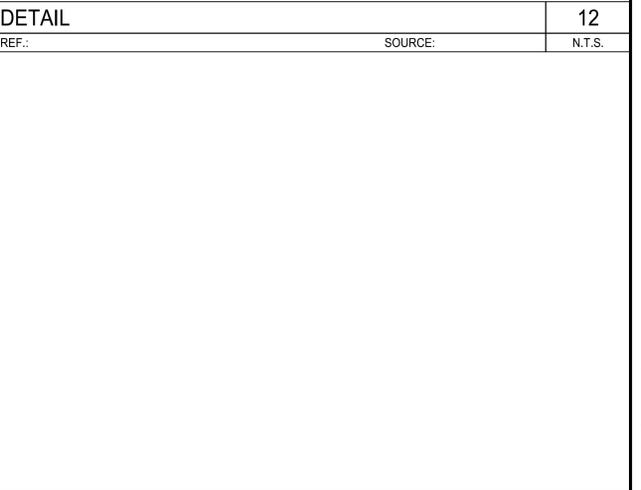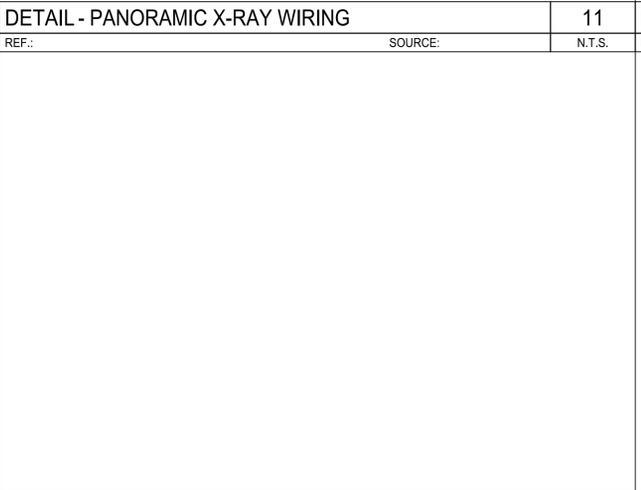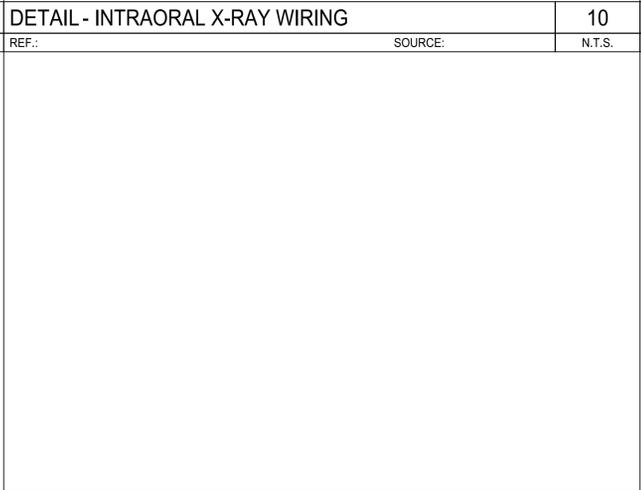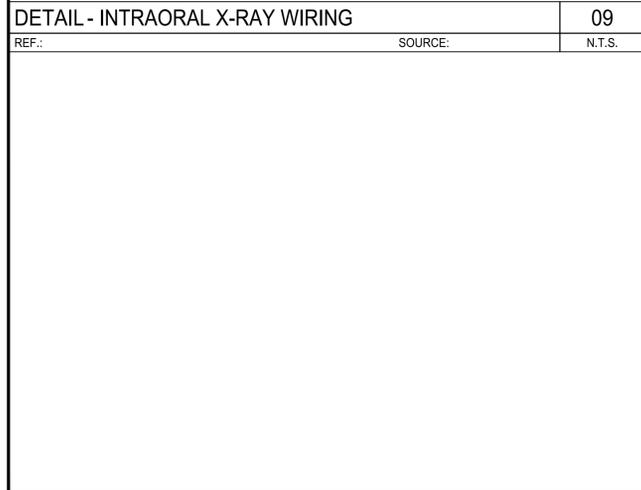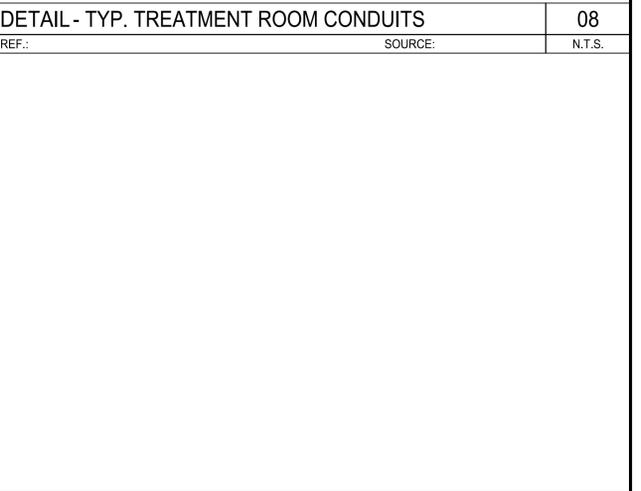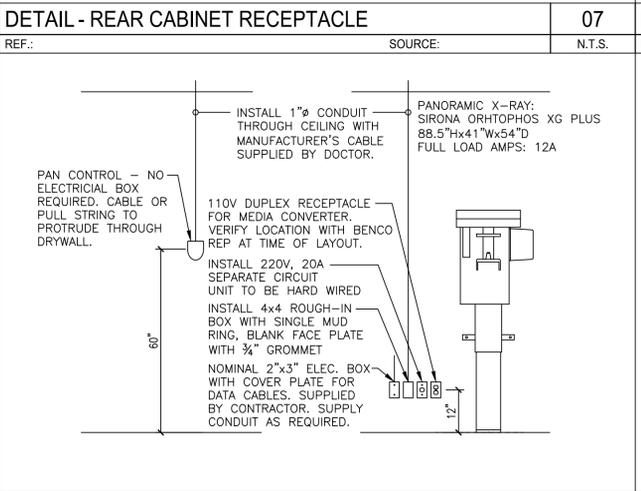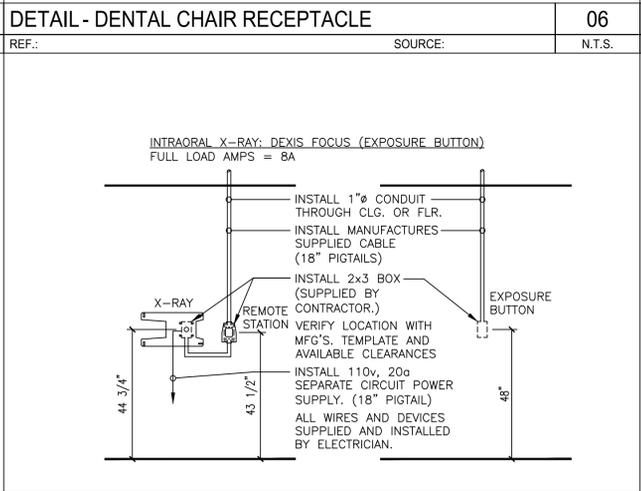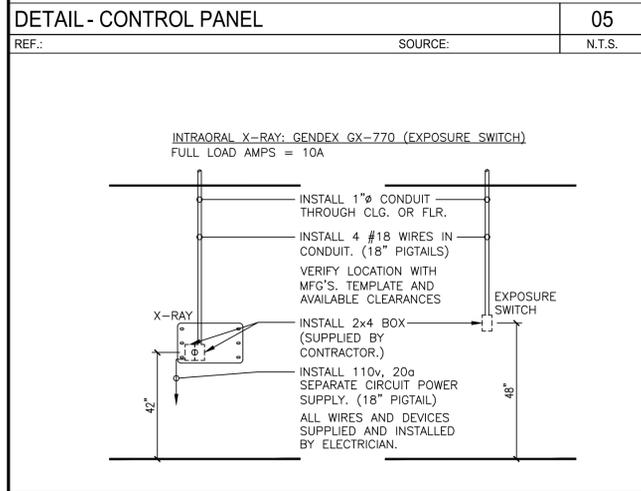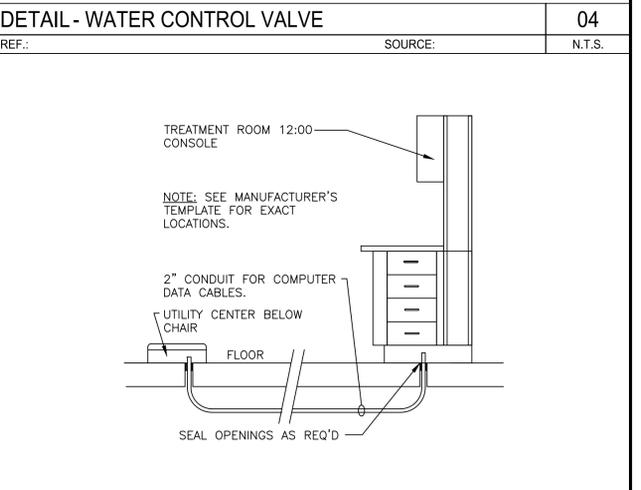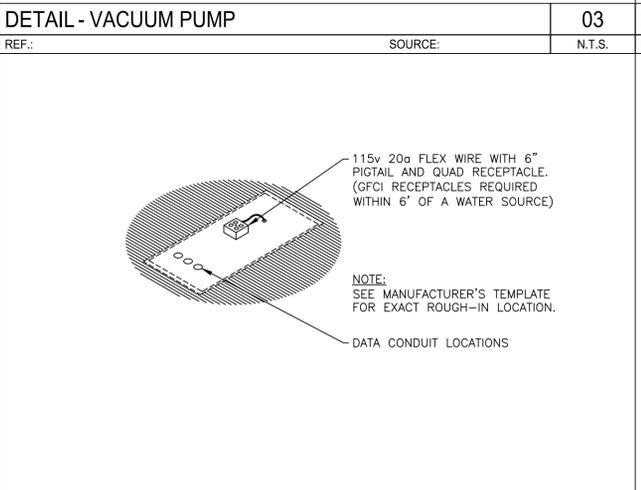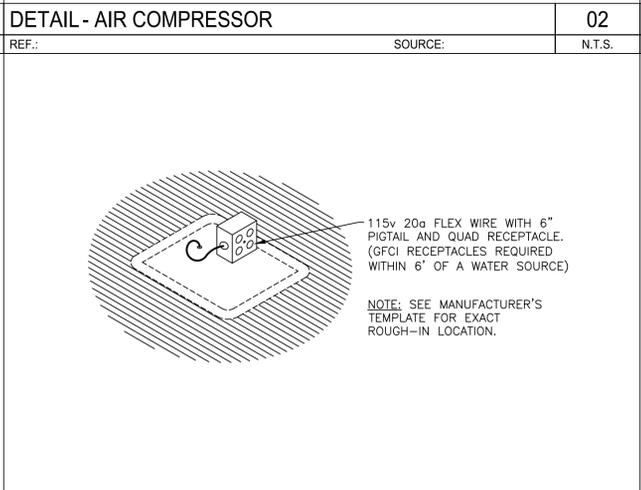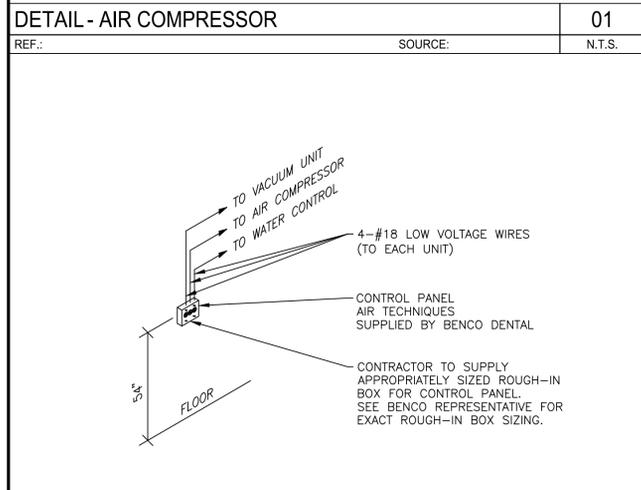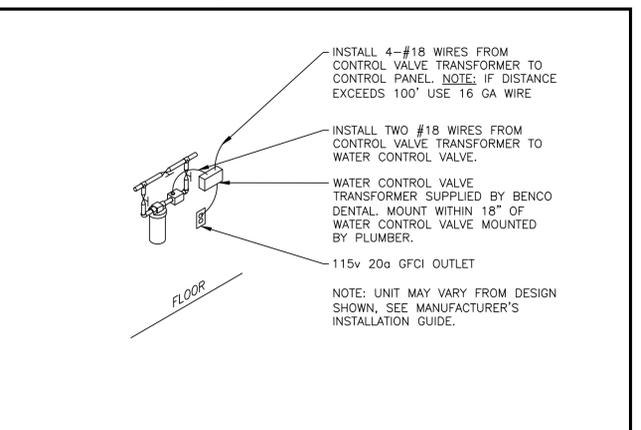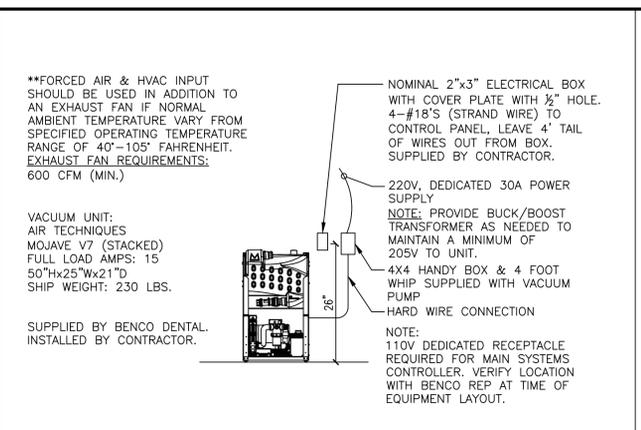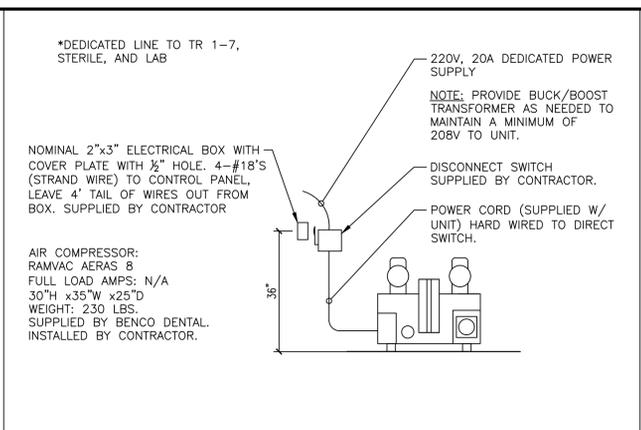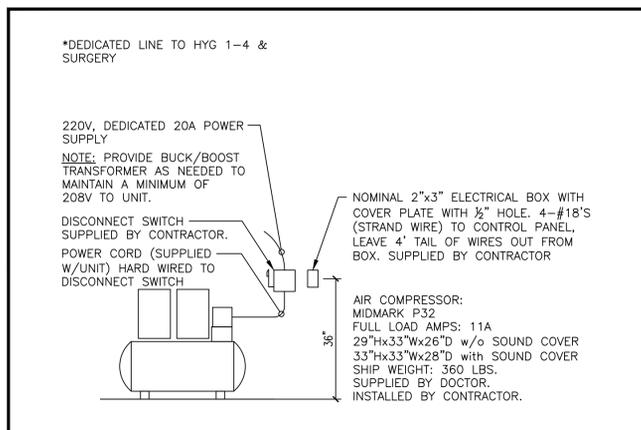

**WHARTON DENTAL**  
1718 W. High St.  
Piqua, Ohio 45356

ISSUED:	DATE:
ZONE STUDY	MM/DD/YY
DESIGN SCHEMATIC REV 5	11/10/2025
EDS	MM/DD/YY
DCD (FOR REVIEW)	01/08/2026
DCD	01/08/2026
DCD REV 1	01/14/2026

PROJECT #:	CHECKED BY:
26-OV31753-TH	TH
DRAWN BY / REVIEWED BY:	
EM	

DRAWING TITLE:  
DENTAL ELECTRICAL DETAILS

SHEET:  
Q3.2

PLUMBING NOTES

1. THE PLUMBER WILL SUPPLY AND INSTALL A WATER PRESSURE REGULATOR ON INCOMING WATER SUPPLY. THE PLUMBER WILL SET THE REGULATOR NOT TO EXCEED 65 PSI.
2. THE PLUMBER WILL INSTALL THE WATER FILTER (AND THE WATER SOFTENER, AS NEEDED) ON THE COLD WATER MAIN ENTERING THE DENTAL SUITE. THE WATER FILTER WILL BE SUPPLIED BY EITHER BENCO DENTAL OR THE DOCTOR.
3. THE PLUMBER WILL SUPPLY AND INSTALL SEPARATE MANUAL SHUT-OFF VALVES ON ALL SINKS, DENTAL UNITS, AND OUTLETS REQUIRING WATER AND/OR AIR.
4. ALL SINKS AND FAUCETS WILL BE CONNECTED BY THE PLUMBER.
5. ALL PIPES WILL BE CONCEALED WITHIN THE WALLS AND/OR THE FLOOR, UNLESS OTHERWISE NOTED ON THE BENCO DRAWINGS.
6. THE PLUMBER WILL SEAL ALL PENETRATIONS THROUGH THE FLOOR WITH A FIRESTOP OR EQUIVALENT WATERPROOFING.
7. ALL PIPES WILL BE FLUSHED CLEAR OF ALL DEBRIS BY THE PLUMBER.
8. THE PLUMBER WILL BE ONSITE ON THE DAY(S) OF INSTALLATION TO WORK WITH THE BENCO REPRESENTATIVE ON THE FINAL HOOK-UP. THE PLUMBER WILL SUPPLY AND INSTALL ANY AND ALL MATERIALS INDICATED IN THE PLUMBING DETAILS SHOWN AND THE MANUFACTURER'S INSTALLATION INSTRUCTION SHEETS.
9. THE PLUMBER WILL PROVIDE AND INSTALL ALL WATER SAFETY DEVICES (I.E. CHECK VALVES, BACKFLOW PREVENTERS, ETC.) IN ACCORDANCE WITH LOCAL CODE.
10. THE PLUMBER WILL INSTALL COMPLETE AND MAKE FINAL HOOK-UP TO THE FOLLOWING DENTAL EQUIPMENT, SUPPLIED BY THE DOCTOR AND/OR BENCO DENTAL, INCLUDING, BUT NOT LIMITED TO:
  - AIR COMPRESSOR
  - VACUUM PUMP
  - AIR/WATER SEPARATORS
  - WATER CONTROL VALVE AND FILTER ASSEMBLY

\*\*\*PLEASE NOTE: THE VACUUM PUMP DOES NOT APPLY TO NFPA CATEGORY 1 SYSTEM.

11. AN ELECTRIC MASTER WATER CONTROL VALVE AND FILTER ASSEMBLY IS REQUIRED FOR ANY/ALL COLD WATER LINES FEEDING ALL DENTAL EQUIPMENT. THIS WATER CONTROL VALVE AND FILTER ASSEMBLY IS REQUIRED WHETHER SUPPLIED BY BENCO, THE DOCTOR, OR THE PLUMBER. THE PLUMBER IS TO VERIFY THE EXACT LOCATION OF THE WATER CONTROL VALVE AND FILTER ASSEMBLY WITH THE DOCTOR/OWNER, AND A BENCO REP AT THE TIME OF LAYOUT AND PRIOR TO EQUIPMENT SELECTION.
12. THE PLUMBER WILL COMPLY WITH ALL BENCO INSPECTIONS, AS NOTED IN THE GENERAL NOTES ON THE FIRST PAGE OF THESE DOCUMENTS.
13. GENERAL DENTAL PLUMBING TERMINATION LOCATIONS SHOWN ARE FOR GRAPHICALLY DISPLAYING ORIENTATION AND TERMINATION POINTS. FIELD CONDITIONS MAY ALTER PLUMBING LINE LAYOUT, PER PLUMBERS DISCRETION. THE FINAL LAYOUT OF THE PLUMBING LINES IS THE RESPONSIBILITY OF THE PLUMBER.
14. IN ACCORDANCE WITH NFPA 99 DENTAL COMPRESSED AIR SHALL NOT BE USED FOR RESPIRATION.
15. NFPA, 99.15.3.3.5 VACUUM PIPING
16. NFPA, 99.15.3.3.6 NITROUS OXIDE SCAVENGING (CATEGORY 2 ONLY)

SINK LEGEND




SINK - SINK, FAUCET AND STRAINER SUPPLIED BY OTHERS. PLUMBER SHALL INSTALL HOT AND COLD WATER LINES, WASTE AND TRAP ROUGH-IN PER LOCAL CODES.



SINK - SINK, FAUCET AND STRAINER PROVIDED WITH CABINETRY SUPPLIED BY BENCO. PLUMBER SHALL INSTALL HOT AND COLD WATER LINES, WASTE AND TRAP ROUGH-IN PER LOCAL CODES. PLUMBER SHALL BE RESPONSIBLE FOR FINAL HOOKUP. SEE MANUFACTURER'S SPECIFICATIONS FOR EXACT LOCATION AND REQUIREMENTS.

1 DENTAL PLUMBING PLAN  
SCALE: 1/4" = 1'-0"

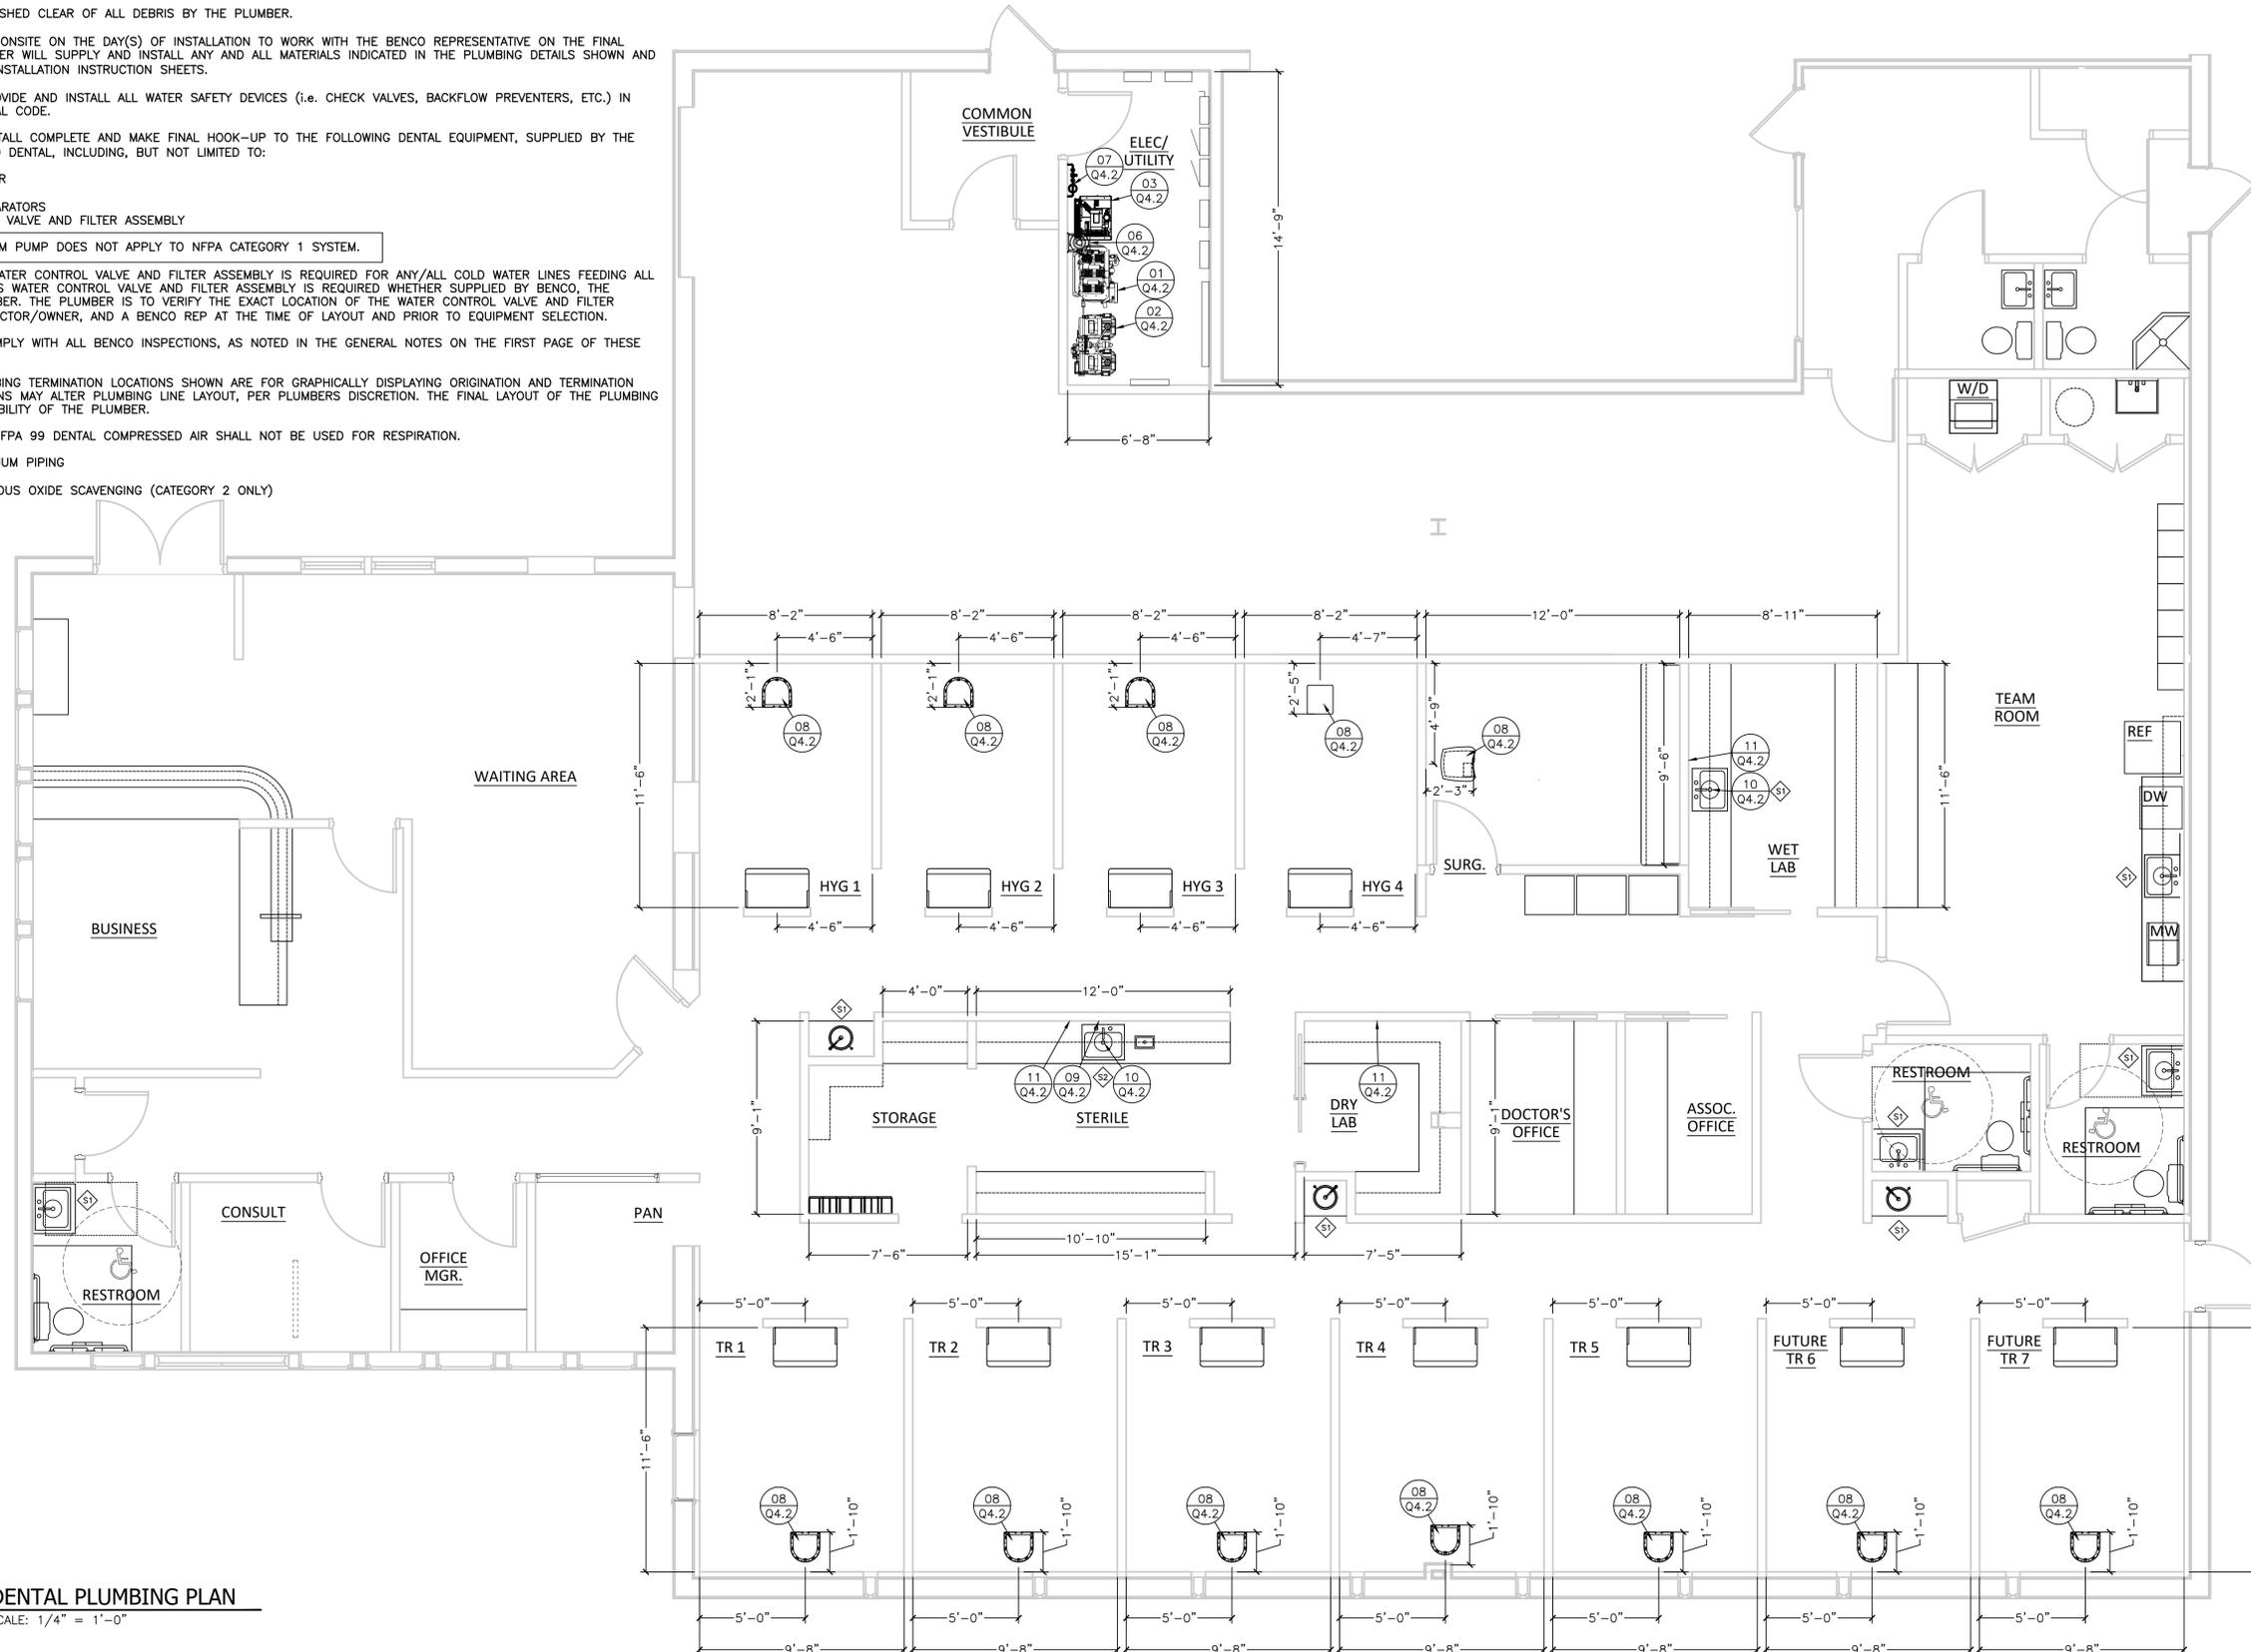

ALL PLUMBING, ELECTRICAL, AND OTHER INSTRUMENTS OF SERVICE, INCLUDING ELECTRICAL, SHALL BE INSTALLED IN ACCORDANCE WITH THE INSTRUMENTS OF SERVICE FOR ANY EXPENSE, INCLUDING BUT NOT LIMITED TO, FILING, CONSTRUCTION AND ANY OTHER EXPENSE. BENCO DESIGN PROVIDES BENCO DESIGN'S SERVICES AND DOES NOT REPRESENT THAT THE INSTRUMENTS OF SERVICE HAVE BEEN REVIEWED FOR COMPLIANCE WITH ANY ZONING OR LOCAL BUILDING CODES. BENCO DESIGN SPECIFICALLY DISCLAIMS ALL LIABILITY FOR ANY ZONING OR LOCAL BUILDING CODES. BENCO DESIGN SPECIFICALLY DISCLAIMS ALL LIABILITY FOR ANY ZONING OR LOCAL BUILDING CODES. BENCO DESIGN SPECIFICALLY DISCLAIMS ALL LIABILITY FOR ANY ZONING OR LOCAL BUILDING CODES.



**WHARTON DENTAL**  
1718 W. High St.  
Piqua, Ohio 45356

ISSUED:	DATE:
ZONE STUDY	MM/DD/YY
DESIGN SCHEMATIC REV 5	11/10/2025
EDS	MM/DD/YY
DCD (FOR REVIEW)	01/08/2026
DCD	01/08/2026
DCD REV 1	01/14/2026

PROJECT #:	DATE:
26-OV31753-TH	
DRAWN BY / REVIEWED BY:	CHECKED BY:
EM	TH

DRAWING TITLE:  
**DENTAL PLUMBING PLAN**  
SHEET:  
**Q4.1**

