

Addendum

DATE: March 27, 2026

615 Woodside Drive, Englewood, Ohio 45322

T 937.836.8898 F 937.832.3696

PROJECT: Family Health Services of Darke County
POD 3 Interior Renovation

www.app-arch.com

PROJECT ADDRESS: 5735 Meeker Road
Greenville, OH 45331

ADDENDUM NO. 1

RECEIPT OF THIS ADDENDUM MUST BE NOTED ON THE FORM OF PROPOSAL

TO ALL BIDDERS:

This addendum supplements and amends the original Plans and Specifications and shall be taken into account in preparing proposals and shall become part of the Contract Documents.

GENERAL ITEMS:

- ITEM G1 **PREBID MINUTES AND SIGN-IN SHEET**
Prebid minutes are attached. Items noted in the minutes, inclusive of Pre-Bid Questions and Answers and Post Pre-Bid RFI Questions, are to be considered as part of the construction documents and to be included in the scope of work for the above referenced project.
- ITEM G2 **BID DATE AND SUBMISSION**
1. Bid Date: April 3, 2026.
2. Bid Time: 11:00 AM, local time.
3. Submit bids electronically to maria.schertler@app-arch.com AND jyoung@familyhealthservices.org , followed up with an original signed copy via USPS, to App Architecture, 615 Woodside Drive, Englewood, OH 45322.

ARCHITECTURAL DRAWINGS:

- ITEM A1 Drawing Sheet A0.3 DOOR FRAME AND WINDOW SCHEDULE
REVISE opening W138
- ITEM A2 Drawing Sheet A1.1 DEMOLITION FLOOR PLAN
ADD CONSTRUCTION NOTE #9 to opening W134
- ITEM A3 Drawing Sheet A1.2 REFERENCE PLAN
REVISE Detail E1/A1.2 ENLARGED NEW WORK PLAN
Details and Dimensions @ Nurses Table

- ITEM A4 Drawing Sheet A1.4 STRUCTURAL PLAN & DETAILS
ADD NOTE @ Detail C2/A1.4 HEADER ELEVATION
- ITEM A5 Drawing Sheet A7.1 INTERIOR ELEVATIONS
REVISE CONSTRUCTION NOTES (Sheet A7.1, A7.2, A7.3)
REVISE Elevations B4/A7.1 & B5/A7.1
- ITEM A6 Drawing Sheet A7.2 INTERIOR ELEVATIONS
REVISE CONSTRUCTION NOTES (Sheet A7.1, A7.2, A7.3)
REVISE Elevations E3/A7.2, E5/A7.2, F1/A7.2 & F3/A7.2
- ITEM A7 Drawing Sheet A7.3 INTERIOR ELEVATIONS
REVISE CONSTRUCTION NOTES (Sheet A7.1, A7.2, A7.3)
REVISE Elevations D1/A7.3, E2/A7.3
- ITEM A8 Drawing Sheet A8.1 CASEWORK DETAILS
REVISE Details: A1/A8.1, B2/A8.1 & D6/A8.1

CONTRACTOR RFI QUESTIONS (Received after Pre-Bid):

This section addresses questions that can be clarified currently and should additional information be required it will be issued in a future Addendum. Questions received and not listed here are currently under review and will be addressed in a future Addendum.

- a. **Q.** W2 on A0.4 calls for a double layer of gypsum board on the toilet room/room side. This wall separates multiple patient rooms, should it be a double layer of drywall on both sides?
A. Each Toilet and Exam/Patient/Procedure Room has a double layer of drywall on one side and a resilient channel with drywall on the second side. See attached floor plan.
- b. **Q.** Note 8 on page A7.1 calls for a contractor furnished & installed toilet paper dispenser, note 6 on page A1.1 calls for existing toilet paper dispensers to be salvaged & reused? .
A. Three Restrooms are being removed, contractor shall salvage toilet dispensers for reinstallation. If additional toilet paper dispensers are required they will be Owner Furnished, Contractor Installed. (Note 8 (A7.1/A7.2/A7.3) is updated.
- c. **Q.** Will the solid surface countertops, being provided & installed by Midmark, have sink openings already cut in them? General Note B on Page A7.1 calls for the general contractor to cut sink openings in – typically the solid surface countertop provider will cut the sink opening & faucet openings in before installing.
A. Openings in solid surface countertops will be cut by Midmark – this is a change covered in Addendum #2 to be issued 3/30.
- d. **Q.** Whose responsibility will it be to install the undermount sinks at the solid surface countertops being provided & installed by Midmark? Typically, the solid surface countertop provider/installer will install the undermount sinks with the countertop.
A. Undermount sinks will be installed by Midmark. – this is a change covered in Addendum #2 to be issued 3/30.

- e. **Q** Who services or installed the existing sprinkler system?
A. See contractors noted in Prebid Minutes.
- f. **Q** Who services or installed the existing fire alarm system?
A. See contractors noted in Prebid Minutes.
- g. **Q.** Can we use metal studs in lieu of wood studs?
A. Wood / metal stud usage:
 - a. **Structural stud framing shall be with wood stud construction as detailed on Sheet A1.4 STRUCTURAL PLAN AND DETAIL.**
 - b. **Infill framing at north wall WAITNG #131 and south wall of BACK HALL #128 shall be wood stud to match existing stud profiles.**
 - c. **Metal studs maybe used on new non load bearing walls.**

END OF ADDENDUM NO. 1

ATTACHMENTS:

- Pre-Bid Minutes and Sign-in Sheet
- Architectural Site Plan for Contractor Staging Information.
- ARCHITECTURAL Drawings: (Full Set of Architectural Sheets are included sheets with revisions are noted below:
 - A0.3 DOOR FRAME AND WINDOW SCHEDULE
 - A1.1 DEMOLITION FLOOR PLAN
 - A1.2 REFERENCE PLAN
 - A1.4 STRUCTURAL PLAN & DETAILS
 - A7.1 INTERIOR ELEVATONS
 - A7.2 INTERIOR ELEVATONS
 - A7.3 INTERIOR ELEVATONS
 - A8.1 CASEWORK DETAILS

Pre-Bid Agenda

DATE: March 18, 2026

615 Woodside Drive, Englewood, Ohio 45322

T 937.836.8898 F 937.832.3696

PROJECT: Family Health – Facility Renovation

www.app-arch.com

SIGN-IN & INTRODUCTIONS: Family Health – App Architecture – Contractors – Subcontractors

GENERAL SCOPE OF PROJECT:

- Single Prime Contract covering all branches of Work.
- Work under other contracts: As defined in the Specifications Section Summary
 1. Interior signage.
 2. Furnishings.
 3. All new Midmark casework and countertops
 4. Low Voltage Cabling and systems equipment installation, including but not limited to the following:
 - a. a. Voice
 - b. b. Data
 - c. c. Wireless
 - d. d. Security
 - e. e. Audio/Visual Equipment

BID REQUIREMENTS:

- Bid due date: March 31, 2026 @ 2:00 p.m. EST
- Bids due:

“Submit bids electronically to maria.schertler@app-arch.com and jyoung@familyhealthservices.org, followed up with an original signed copy via drop off or USPS, to App Architecture, 615 Woodside Drive, Englewood, OH 45322.”
- Substitution Request: March 25, 2026 at 12:00 PM
- Questions: March 24, 2026 at 12:00 PM.
- Last Addendum will be issued: March 26, 2026 at 12:00 PM
- Use bid forms provided in the Project Manual.
- **Surety Bond is required.**
 - **Written in AIA Document A310 Bid Bond – See Specifications AIA Document Instructions to Bidders Section 4.2.3**
- Performance and Payment Bond required. – Yes, See Specifications and AIA document.
- Use of local subcontractors and suppliers is encouraged.

Contractor's familiar with Family Health Facility:

- **Sarver Plumbing** 2006 Plumbing Subcontractor
Phillip D Jones
7113 Alternate St Rt 49 2023/24 Plumbing Subcontractor
Arcanum, OH, 454304
937.947.2200
- **Bolyard Heating & Cooling Inc.** 2006 Mechanical Subcontractor
1480 Sweitzer St. Current Mech. Maintenance Contract
(937) 548-6772

- Saturn Electric 2023/24 Electrical Subcontractor
2628 Nordic Rd.
937.278.2580

- GMT Roofing 2023/2024 Roofing Subcontractor
Carlena Sneed
1220 Martin St
Greenville, OH, 45331
Current shingle roof under warranty until February 28, 2027.

- Bud's Electric Electrical Service

- ProPoint Owner's IT/AV Vendor (for Coordination)
Franklin Hesson
8613 N. Dixie Dr.
Dayton OH 45414-2403
(937) 573-3423

- OVIS Fire Alarm Service/Supervisor
2005 Commerce Dr, Sidney, OH 45365
(888) 999-6847

- Response Fire Protection 2023/24 FP Subcontractor
Chris Gough
233 Leo St, Dayton, OH
937-252-7400

- Alternates:
 1. Back Hall Ceiling pad replacement

SUPPLEMENTARY CONDITIONS:

- Permits
- Building Permit: Owner submitting for General Permit only
 - Allowance for Building Permit – **See Specifications**
- Trade Permits: By contractors.
- Owner is sales tax exempt.
- Payment of “Prevailing Wages” is not required.
- Notice of Commencement. **Owner will issue once Board approval of bid.**

TEMPORARY FACILITIES:

- Utilities: See Specifications
 1. Water and Sewer: From Owner's existing service Contractor to provide connections and extensions of service.
 2. Electrical: From Owner's existing service Contractor to provide connections and extensions of service.
- Field offices, storage trailers. **Locate in North Lot**
- Temporary toilets. **GC to provide – locate in North lot.**
- Use of site. – **See attached Site Plan**

- Front lot will be available for drop-off and unloading.
- Porte Cochere Entry will be closed to public and staff.
- Porte Cochere will always be available to contractors
- (10) spaces in North lot will be made available to GC for Staging
- Remainder of parking and storage can be located at the south end of the south lot.

OWNER COMMENTS:

1. This work area is adjacent to medical suites, dust control is very important. Sealing both the east and west extents of the work area will be required.
2. HEPA filters should be used during construction to mitigate airborne particulates.

CONTRACTOR QUESTIONS:

Direct all bid questions, architectural, structural and site, mechanical and electrical, to App Architecture emailed to Maria Schertler: maria.schertler@app-arch.com .

Existing conditions site walk thru/additional access to site? 2nd Site Visit?

All necessary clarifications will be made by Addendum.

Pre-Bid Sign-In Sheet

DATE: March 18, 2026

PROJECT: Family Health Facility Renovation

Name	Company	Address	Communication Numbers
Maria Schertler	App Architecture		Phone: 937.836.8898 Mobile: E-Mail: maria.schertler@app-arch.com
Jean Young	Family Health		Phone: Mobile: E-Mail: jyoung@familyhealthservices.org
Jay Pearson	Family Health		Phone: Mobile: E-Mail:
Brandon Forsthoefel	H.A.Dorsten		Phone: 567.644.8966 Mobile: E-Mail: bforsthoefel@hadorsteninc.com
Steve Elsass	H.A.Dorsten		Phone: 419.628.2327 Mobile: E-Mail: selsass@hadorsteninc.com

Name	Company	Address	Communication Numbers
Chris Robinson	Brumbaugh Construction		Phone: 937.692.5107 Mobile: E-Mail: chris@brumbaughconstruction.com
Matt Hass	Complete Detail		Phone: 937.774.0821 Mobile: E-Mail: Matt@completedetail.net
Adam May	Complete Detail		Phone: 937.613.4862 Mobile: E-Mail: adam.completedetail3@gmail.com
			Phone: Mobile: E-Mail:
			Phone: Mobile: E-Mail:

POD 3 INTERIOR RENOVATION FAMILY HEALTH SERVICES OF DARKE COUNTY

5735 MEEKER ROAD, GREENVILLE, OH 45331

ARCHITECT

App Architecture

615 Woodside Drive
Englewood, Ohio 45322
(937) 836-8898

MECHANICAL, ELECTRICAL & PLUMBING

Nauman & Zelinski, LLC

204 South Ludlow Street, Suite 400
Dayton, Ohio 45402
(937) 223-3821

DRAWING INDEX

GENERAL	
G0.1	COVER SHEET
G0.2	LIFE SAFETY PLAN
G0.3	OCCUPANT LOAD PLAN
ARCHITECTURAL	
A0.1	ABBREVIATIONS AND SYMBOLS
A0.2	ROOM FINISH SCHEDULE
A0.3	DOOR, FRAME, AND WINDOW SCHEDULE
A0.4	WALL TYPES
A1.1	DEMOLITION FLOOR PLAN
A1.2	REFERENCE PLAN
A1.3	DIMENSION PLAN
A1.4	STRUCTURAL PLAN AND DETAILS
A2.1	NEW WORK REFLECTED CEILING PLAN
A7.1	INTERIOR ELEVATIONS
A7.2	INTERIOR ELEVATIONS
A7.3	INTERIOR ELEVATIONS
A8.1	CASEWORK DETAILS
FIRE PROTECTION	
F0.1	LEGENDS AND SCHEDULES
F1.2	FIRST FLOOR PLAN - FIRE SUPPRESSION
PLUMBING	
P0.1	LEGENDS AND SCHEDULES
P1.0	BELOW SLAB DEMOLITION PLAN
P1.1	FIRST FLOOR DEMOLITION PLAN
P2.0	BELOW SLAB NEW WORK PLAN
P2.1	FIRST FLOOR NEW WORK PLAN
P3.1	SOIL, WASTE, AND VENT DIAGRAM
MECHANICAL	
H0.1	LEGENDS AND SCHEDULES
H1.1	FIRST FLOOR DEMOLITION PLAN
H2.1	FIRST FLOOR NEW WORK PLAN
H3.1	DETAILS
ELECTRICAL	
E0.1	LEGENDS
E0.2	SCHEDULES
E1.1	DEMOLITION
E2.1	NEW LIGHTING PLAN
E3.1	NEW POWER AND SYSTEMS PLAN

App Architecture
creative focused design

615 Woodside Drive, Englewood, Ohio 45322
T 937.836.8898 F 937.832.3696
www.app-arch.com

POD 3 INTERIOR RENOVATION
**FAMILY HEALTH SERVICES OF
DARKE COUNTY**

5735 MEEKER ROAD, GREENVILLE, OH 45331

CODE INFORMATION

GOVERNING CODE:
2024 OHIO EXISTING BUILDING CODE (OEBG)
COMPLIANCE METHOD:
2024 OHIO EXISTING BUILDING CODE (OEBG)
SECTION 301.3.1 PRESCRIPTIVE COMPLIANCE METHOD
COMPLIANCE WITH OEBG SECTIONS 302-309 AND CHAPTER 5.
ALTERATIONS TO COMPLY WITH REQUIREMENTS OF THE CODE FOR NEW
CONSTRUCTION (OBC 2024).

PROJECT DESCRIPTION
INTERIOR RENOVATION IN AN EXISTING MEDICAL BUILDING RENOVATION OF A
FORMER PHARMACY AND LAB SPACE INTO A MEDICAL CLINIC, INCLUSIVE OF
PATIENT ROOMS, PROCEDURE ROOM, LAB, TOILET, NURSE AND DOCTOR WORK
AREAS AND RECEPTION. WORK INCLUDES GENERAL TRADES (PARTITIONS,
DOORS, INTERIOR WINDOWS, CASEWORK, AND FINISHES) AND FIRE PROTECTION,
MECHANICAL, AND ELECTRICAL WORK ASSOCIATED WITH THE NEW LAYOUT.

USE GROUP CLASSIFICATION
OBC (302) USE GROUP: B - BUSINESS
OUTPATIENT CLINIC & OFFICE
SCOPE OF WORK WILL NOT MODIFY USE GROUP CLASSIFICATION.

CONSTRUCTION TYPE CLASSIFICATION
OBC (602) CONSTRUCTION TYPE: VB - WOOD FRAME SLAB ON GRADE
OBC (T601) FIRE RESISTANCE RATING FOR BUILDING ELEMENTS = 0 HOURS.

HEIGHT AND AREA LIMITATIONS
OBC (504) BUILDING HEIGHT AND NUMBER OF STORIES:
UNCHANGED BY THIS PROJECT
OBC (506) BUILDING AREA:
UNCHANGED BY THIS PROJECT
BUILDING DESCRIPTION:
EXISTING WEST BUILDING: 46,226 SF*
* EXISTING (2) HR FIRE BARRIER SEPARATES THIS TOTAL AREA INTO 2 FIRE
AREAS: 18,150 SF & 28,076 SF
RENOVATED AREA: 7,300 SF

OCCUPANT LOAD
EXISTING OCCUPANCY CALCULATION WILL NOT BE IMPACTED BY SCOPE OF WORK.
OBC (1004)
OCCUPANT LOAD IS UNCHANGED BY THIS PROJECT
WEST BUILDING EXISTING OCCUPANCY = 462 OCCUPANTS
AREA OF RENOVATION EXISTING ACTUAL OCCUPANCY = 101 OCCUPANTS
AREA OF RENOVATION NEW ACTUAL OCCUPANCY = 96 OCCUPANTS
SEE SHEET G0.2 LIFE SAFETY PLAN
SEE SHEET G0.2.1 OCCUPANT LOAD PLAN (EXITS & CORRIDORS)

MEANS OF EGRESS
OBC (1017)
EXIT ACCESS TRAVEL DISTANCE
B-BUSINESS (SPRINKLERED) = 300 FEET
ACTUAL MAX TRAVEL DISTANCE = 150'-0"
OBC (T1020.3) CORRIDOR WIDTH 44 IN. MIN. - B OCCUPANCY
OBC (1020.4) DEAD END CORRIDORS 50 FT. MAX. - B, OCCUPANCIES WITH
SPRINKLER SYSTEM.


FIRE PROTECTION
OBC (903) AUTOMATIC SPRINKLER SYSTEMS
BUILDING DESCRIPTION: FULLY SPRINKLERED
OBC (907) FIRE ALARM AND DETECTION SYSTEMS
PROVIDED
REFER TO ELECTRICAL DRAWINGS

INTERIOR FINISHES
OBC (803) INTERIOR WALL & FINISHES:
ASSEMBLY USE MOST RESTRICTIVE
EXIT PASSAGEWAY (SPRINKLERED) = CLASS B
CORRIDORS (SPRINKLERED) = CLASS B
ROOMS (SPRINKLERED) = CLASS C
OBC (804) INTERIOR FLOOR FINISH:
FLOOR FINISH = CLASS II

ACCESSIBILITY STANDARD
EXISTING BUILDINGS: OBC 2024, CHAPTER 11, ACCESSIBILITY AND ICC A117.1-2009

PLUMBING FIXTURES
OBC (T2902)
B BUSINESS: MALE / FEMALE: (1/50) UNISEX (1/25) LAV (1/80) DF (1/100)
TOTAL OCCUPANTS AREA OF WORK 101 (50 MEN + 51 WOMEN)
WATERCLOSETS 1 MENS + 1 WOMENS + 2 UNISEX PROVIDED
4 PROVIDED > 3 REQUIRED
LAVATORIES 4 PROVIDED > 2 REQUIRED
DRINKING FOUNTAINS 1 PROVIDED* = 1 REQUIRED
SERVICE SINKS 1 PROVIDED* = 1 REQUIRED
*PROVIDED OUTSIDE AREA OF WORK BUT WITHIN EXISTING BUILDING.

VICINITY MAP

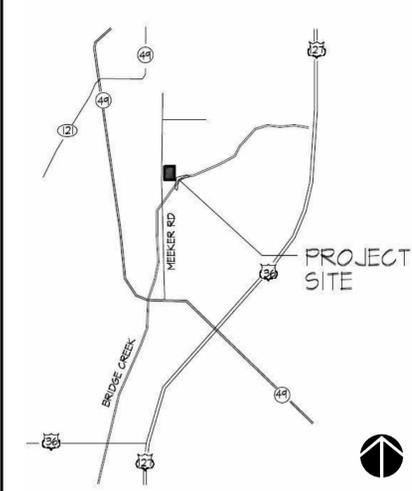

ISSUE

NO.	DATE	DESCRIPTION
03.16.2026	FOR BID & PERMIT	

DATE 3.16.26
JOB NO. 3853.04
DRAWN RNL
CHECKED MES/TAG
COPYRIGHT © 2026 - App Architecture, Inc.
TITLE
COVER SHEET
SHEET NO.
GO.1

1

2

3

4

5

6

7

A

B


C

D

E


F

EAST BUILDING

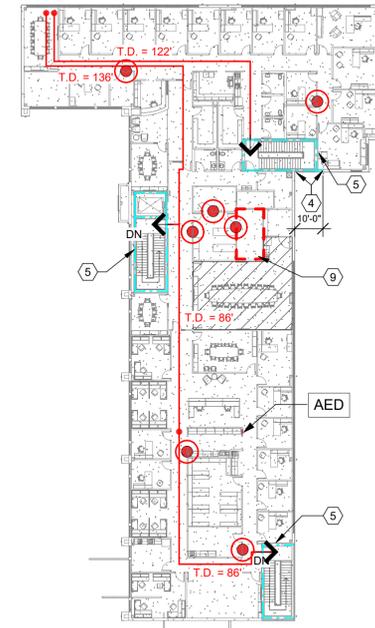

C4 LIFE SAFETY SECOND FLOOR PLAN
1" = 30'-0"

WEST BUILDING EAST BUILDING

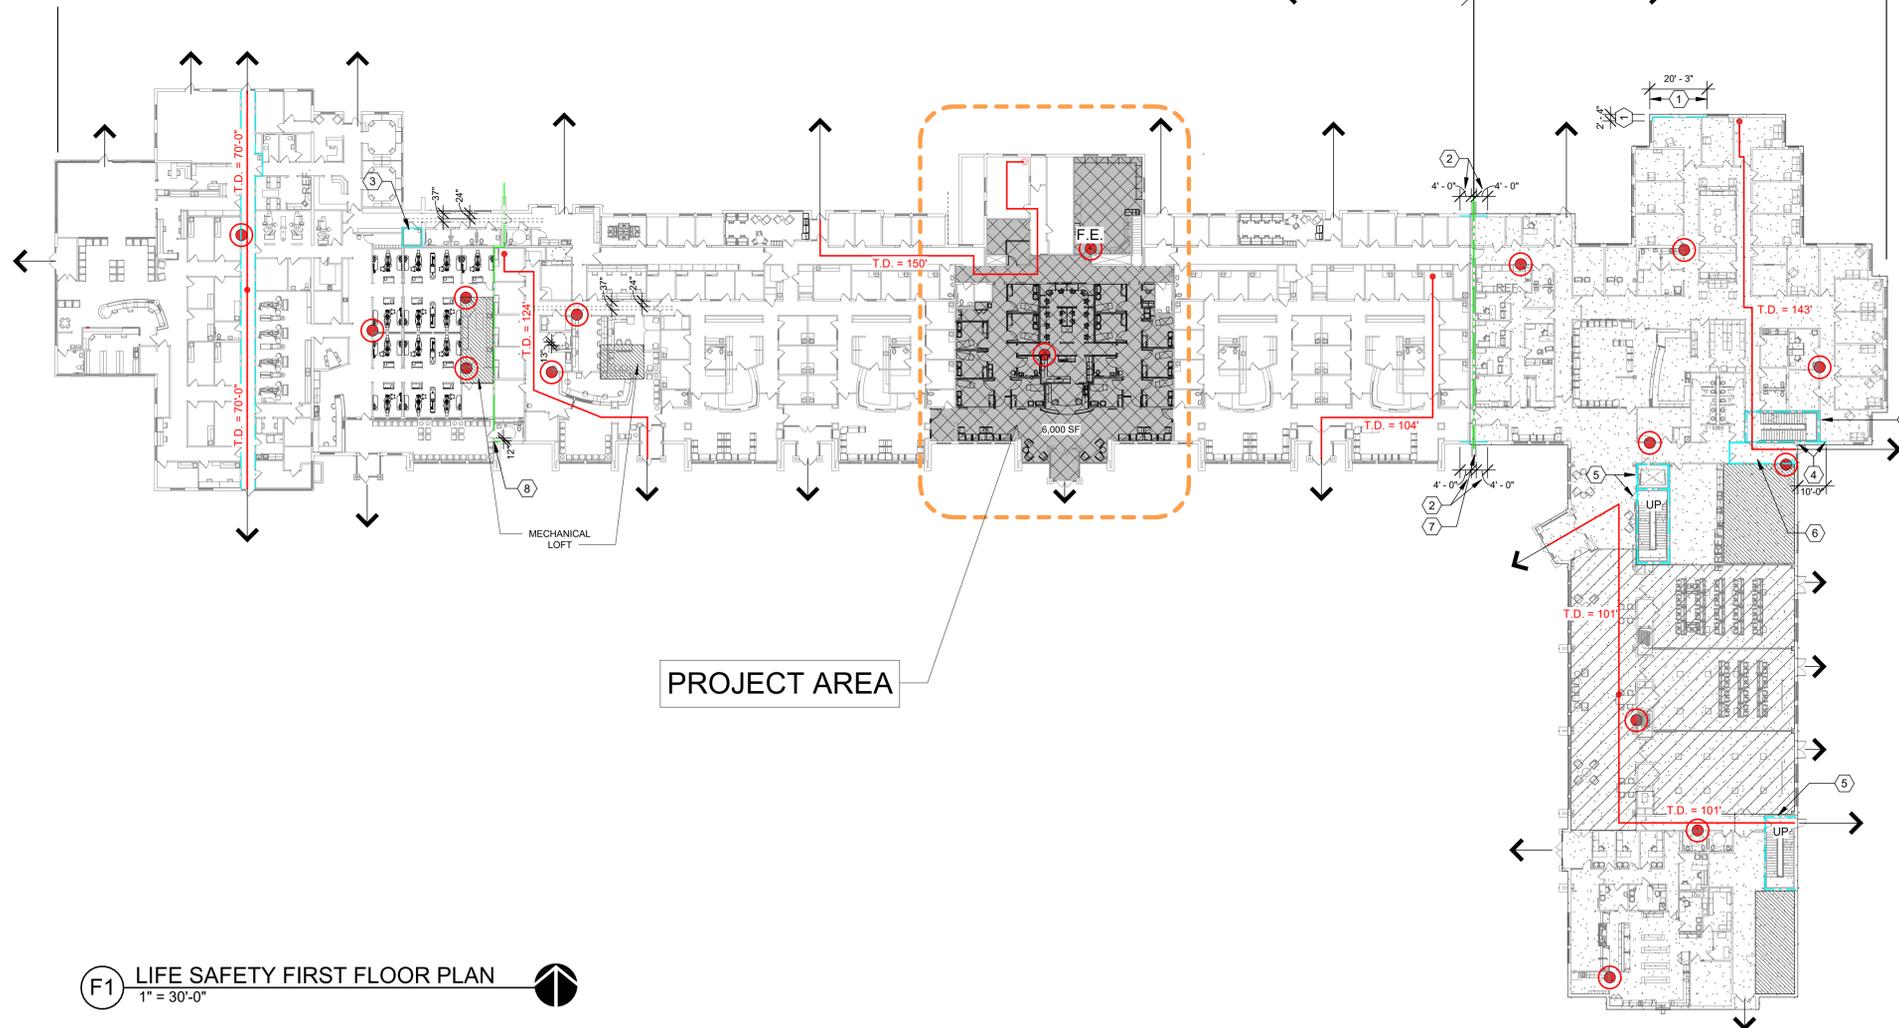

F1 LIFE SAFETY FIRST FLOOR PLAN
1" = 30'-0"

CONSTRUCTION NOTES

(00) INDICATES CONSTRUCTION NOTE.

- EXISTING 1-HOUR EXTERIOR WALL CONSTRUCTION PER OBC TABLE 602 FIRE SEPARATION DISTANCE.
- EXISTING 1-HOUR EXTERIOR WALL CONSTRUCTION PER OBC 706.5 HORIZONTAL CONTINUITY AT FIRE WALL.
- EXISTING 1 HOUR RATED WALL AND CEILING ASSEMBLIES AT NITROUS OXIDE CLOSET PER NFPA 99.
- EXISTING 1-HOUR EXTERIOR WALL CONSTRUCTION PER OBC TABLE 713.6 SHAFT EXTERIOR WALLS.
- EXISTING 1-HOUR RATED WALL CONSTRUCTION PER OBC 1023 INTERIOR EXIT STAIRWAY AND 3002 HOISTWAY ENCLOSURES WITH 1-HOUR RATED SHAFT ENCLOSURE AT TOP PER OBC 713.12.
- EXISTING 1-HOUR RATED WALL CONSTRUCTION PER OBC 1024 EXIT PASSAGEWAY WITH 1-HOUR RATED TOP ENCLOSURE PER OBC 713.12.
- EXISTING 2-HOUR RATED FIRE WALL CONSTRUCTION.
- EXISTING 2-HOUR RATED FIRE BARRIER CONSTRUCTION.
- SERVER ROOM L243 PROTECTED BY AN EXISTING CLEAN AGENT FIRE EXTINGUISHING SYSTEM PER OBC SECTION 903.1.1 ALTERNATIVE PROTECTION & SECTION 904.2 ALTERNATIVE AUTOMATIC FIRE EXTINGUISHING SYSTEM.

GENERAL NOTES

OCCUPANCY & EGRESS


- OWNER WILL OCCUPY PREMISES DURING ENTIRE CONSTRUCTION PERIOD AND CONDUCT BUSINESS OPERATIONS. WITH EXCEPTION OF AREAS UNDER CONSTRUCTION. CONSTRUCTION ACTIVITY SHALL NOT IMPEDE ACTIVITY IN AREAS OUTSIDE CONSTRUCTION LIMITS
- MAINTAIN EGRESS AT ALL TIMES DURING CONSTRUCTION, INCLUSIVE OF ADDITIONAL SIGNAGE AND EMERGENCY EGRESS LIGHTING.
- COORDINATE WITH THE AUTHORITY HAVING JURISDICTION FOR TEMPORARY ADJUSTMENTS TO THE MEANS OF EGRESS.

LEGEND

- 1 HR. FIRE RATING - - - - -
- 2 HR. FIRE RATING - - - - -
- EXIT ➔
- MECHANICAL
- ASSEMBLY
- WEST BUILDING (UNCHANGED)
- WEST BUILDING (AREA OF RENOVATION)
- EAST BUILDING (UNCHANGED)
- FIRE EXTINGUISHER ●

APP Architecture
creative focused design

615 Woodside Drive, Englewood, Ohio 45322
T 937.836.8898 F 937.832.3696
www.app-arch.com

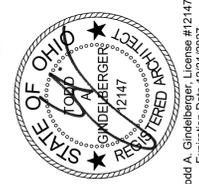

POD 3 INTERIOR RENOVATION
FAMILY HEALTH SERVICES OF DARKE COUNTY
5735 MEEKER ROAD, GREENVILLE, OH 45331

ISSUE	
NO.	DESCRIPTION
03.16.2026	FOR BID & PERMIT

DATE	3.16.26
JOB NO.	3853.04
DRAWN	RNL
CHECKED	MES/TAG
COPYRIGHT © 2026 - App Architecture, Inc.	
TITLE	LIFE SAFETY PLAN
SHEET NO.	GO.2

3/27/2026 11:05:40 AM



C3 OCCUPANT LOAD SECOND FLOOR PLAN
1" = 30'-0"

F1 OCCUPANT LOAD FIRST FLOOR PLAN
1" = 30'-0"

LEGEND

- X = OCCUPANT LOAD BASED ON OBC SECTION 1004 (TABLE 1004.5). SPACES WITHOUT A OCCUPANT LOAD ARE NON SIMULTANEOUS OCCUPANCY.
- X> = ANTICIPATED COLLECTIVE OCCUPANT LOAD PER EGRESS DOOR WITH DIRECTION OF TRAVEL ARROW.
NOTE: COLLECTIVE OCCUPANT LOAD USES THE HIGHER OCCUPANT LOADS BETWEEN ALLOWED/ACTUAL.
- = EXISTING DOORS WITH PANIC DEVICES OR PUSH PULL HARDWARE.
- = NEW DOORS WITH PANIC DEVICES OR PUSH PULL HARDWARE.
- *X(ACT) = ACTUAL OCCUPANT LOAD BASED ON OBC SECTION 1004 (TABLE 1004.5) USE AND FURNITURE LAYOUT.



POD 3 INTERIOR RENOVATION
FAMILY HEALTH SERVICES OF
DARKE COUNTY
5735 MEEKER ROAD, GREENVILLE, OH 45331

ISSUE		
NO.	DATE	DESCRIPTION

DATE	3.16.26
JOB NO.	3853.04
DRAWN	RNL
CHECKED	MES/TAG

COPYRIGHT © 2026 - App Architecture, Inc.
TITLE
OCCUPANT LOAD PLAN

ABBREVIATIONS

SYMBOL	
@	AT AND ANGLE
∅	DIAMETER
CL	CENTER LINE
CH	CHANNEL
O ₂	OXYGEN
PL	PLATE
A	AIR (MEDICAL)
ABV	ABOVE
AVC	AIR CONDITIONING
APC	ACOUSTICAL PANEL CEILING
ADJ	ADJACENT OR ADJUSTABLE
AF	ABOVE FINISHED FLOOR
AHU	AIR HANDLER UNIT
AL	ALUMINUM
ALT	ALTERNATE
ANOD	ANODIZED
ANCH	ANCHOR
AP	ACCESS PANEL
APPOX	APPROXIMATELY
ARCH	ARCHITECT OR ARCHITECTURAL
ATTEN	ATTENUATED
AUTO	AUTOMATIC
AUX	AUXILIARY
AVG	AVERAGE
BC	BASE CABINETS
BLDG	BUILDING
BD	BOARD
BLK	BLOCK
BLCKG	BLOCKING
BM	BEAM
BOT	BOTTOM
BRG	BEARING
BSMT	BASEMENT
BUR	BUILT-UP ROOF
C	CARPET
CAB	CABINET
CB	CATCH BASIN
C/C	CENTER TO CENTER
CEM	CEMENT
CF	CUBIC FOOT
CG	CORNER GUARD
CHR	CIRCLE
CJ	CONTROL JOINT
CLG	CEILING
CLOS	CLOSET
CLR	CLEAR
CMT	CERAMIC MOSAIC TILE
CMU	CONCRETE MASONRY UNIT
CO	CLEAN OUT
COL	COLUMN
CONC	CONCRETE
CONST	CONSTRUCTION
CONT	CONTINUOUS OR CONTINUE
CRU	CENTRAL PROCESSING UNIT (COMPUTER)
CRS	COURSE OR COURSING
CY	CUBIC YARD
DBL	DOUBLE
DEMO	DEMOLISH, DEMOLITION
DEV	DEVELOPMENT
DF	DRINKING FOUNTAIN
DIA	DIAMETER
DNM	DIMENSION
DISP	DISPENSER
DIV	DIVISION
DS	DOWNSPOUT
DR	DOOR
DRWG	DRAWING
DET	DETAIL
E	EAST
EA	EACH
EC	ELECTRICAL CONTRACTOR
EJFS	EXTERIOR INSULATION AND FINISH SYSTEM
EJ	EXPANSION JOINT
ELEC	ELECTRIC OR ELECTRICAL
ELEV	ELEVATION OR ELEVATOR
EMERG	EMERGENCY
EP	ELECTRICAL PANEL
EPT	EPOXY PAINT
EQ	EQUAL
EQUIP	EQUIPMENT
EWC	ELECTRIC WATER COOLER
EXIST OR EX	EXISTING
EXP	EXPANSION
EXT	EXTERIOR
FAB	FABRICATED OR FABRICATING
FD	FLOOR DRAIN
FE	FIRE EXTINGUISHER
FEC	FIRE EXTINGUISHER CABINET
FF	FINISH FLOOR
FIN	FINISH OR FINISHED
FLR	FLOOR
FND	FOUNDATION
FTG	FOOT OR FEET OR FULLY TEMPERED
FTW OR FRT	FIRE TREATED WOOD
FUR	FURRING
FV	FIELD VERIFY
FOW	FACE OF WALL

G	
GA	GUAGE OR GAGE
GALV	GALVANIZED
GB	GRAB BAR
GC	GENERAL CONTRACTOR
GD	GRADE OR GRADING
GEN	GENERAL
GL	GLASS OR GLAZING
GRD	GROUND
GYP	GYPSUM
GWB	GYPSUM WALLBOARD
GWT	GLAZED WALL TILE
H	
HB	HOSE BIBB
HD	HEAD
HDW	HARDWARE
HM	HOLLOW METAL
HORIZ	HORIZONTAL
HPDL	HIGH PRESSURE DECORATIVE LAMINATE
HR	HOUR
HT	HEIGHT
HVAC	HEATING, VENTILATING & AIR CONDITION
HWD	HARDWARE
I	
ID	INSIDE DIAMETER
IG	INSULATED GLASS
IN	INCH
INCL	INCLUDE (D) (ING)
INT	INTERIOR
INV	INVERT
IV	INTRAVENOUS
J	
JB	JUNCTION BOX
JC	JANITOR CLOSET
K	
K	KIPS
KT	KITCHEN
L	
LAV	LAVATORY
LCD	LIQUID CRYSTAL DISPLAY (MONITOR)
LH	LEFT HAND
LN	LINEAR
LL	LIVE LOAD
LLH	LONG LEG HORIZONTAL
LLV	LONG LEG VERTICAL
LT	LIGHT
LT	LIGHT
LTVL	LOUVER
M	
M	MEN OR METER
MAS	MASONRY
MAT	MATERIAL OR WALKOFF MAT
MAX	MAXIMUM
MC	MECHANICAL CONTRACTOR
MECH	MECHANICAL
MED	MEDICINE
MFR	MANUFACTURER
MH	MOUNTING HEIGHT, MANHOLE
ML	THOUSANDTHS OF AN INCH
MM	MILLIMETER
MIN	MINIMUM
MISC	MISCELLANEOUS
MO	MASONRY OPENING
MTD	MOUNTED
MTG	MOUNTING
MTL	METAL
N	
N	NORTH OR NITROGEN
NAT	NATURAL
NC	NURSE CALL
NO	NOT IN CONTRACT
NO	NUMBER OR NITROUS OXIDE
NOM	NOMINAL
NRC	NOISE REDUCTION COEFFICIENT
NTS	NOT TO SCALE
O	
OD	OUTSIDE DIAMETER
OFCI	OWNER FURNISHED, CONTRACTOR INSTALLED
OFDI	OWNER FURNISHED, OWNER INSTALLED
OH	OVERHEAD
OHD	OVERHEAD DOOR
OPNG	OPENING
OPP	OPPOSITE
OX	OXYGEN
P	
PAR	PARALLEL
PC	PLUMBING CONTRACTOR
PCF	POUNDS PER CUBIC FOOT
PL	PLATE OR PROPERTY LINE
PLAS	PLASTER
PLAM	PLASTIC LAMINATE
PLBG	PLUMBING
PLWD	PLYWOOD
PME	PLUMBING, MECHANICAL & ELECTRICAL
PNL	PANEL
PR	PAIR
PSF	POUNDS PER SQUARE FOOT
PSI	POUNDS PER SQUARE INCH
P	PAINT
PVC	POLYVINYL CHLORIDE

Q	
QT	QUARRY QUANTITY
R	
RA	RADIUS OR RISER
RB	RETURN AIR
RD	RUBBER BASE
RD	ROOF DRAIN
RECEPT	RECEPTACLE
REF	REFRIGERATOR
REFRIG	REFRIGERATOR
REG	REGISTRATION
REINFC	REINFORCE
REINFC	REINFORCE
REMO	REMOVE
REQD	REQUIRED
RET	RETURN
REV	REVISION
RH	RIGHT HAND
RM	ROOM
RO	ROUGH OPENING
ROW	RIGHT OF WAY
S	
S	SOUTH
SA	SUPPLY AIR
SAN	SANITARY
SB	SINK BASE
SC	SOLID CORE
SCHED	SCHEDULE
SEAL	SEALANT
SECT	SECTION
SF	SQUARE FEET
SFS	SAFETY GLASS
SH	SPRINKLER HEAD OR SHOWER HEAD
SHT	SHEET
SHTG	SHEDDING
SIM	SIMILAR
SPEC	SPECIFICATION(S)
SPK	SPEAKER
SQ	SQUARE
SRV	SERVICE
SS	STAINLESS STEEL
SSM	SOLID SURFACING MATERIAL
ST	STREET
STC	SOUND TRANSMISSION CLASSIFICATION
STD	STANDARD
STL	STEEL
STOR	STORAGE
STR	STRUCTURAL
SUSP	SUSPENDED
SV	SHEET VINYL
SWD	SOFTWOOD
SYM	SYMMETRICAL
SYS	SYSTEM
T & G	TREAD TONGUE & GROOVE
TB	TOWEL BAR OR TACKBOARD
TAB	TOP AND BOTTOM
TEL	TELEPHONE
THK	THICK
TBDO	TACKBOARD
TCC	TOP OF CONCRETE
TOS	TOP OF STEEL
TOM	TOP OF MASONRY
TOW	TOP OF WALL
TPD	TOILET PAPER DISPENSER
TRANS	TRANSFORMER
TV	TELEVISION
TYP	TYPICAL
U	
UC	UNDER CABINET OR COUNTER
UCR	UNDER COUNTER REFRIGERATOR
UH	UNIT HEATER
UL	UNDERWRITERS LABORATORY
UNO	UNLESS NOTED OTHERWISE
UTIL	UTILITY
URN	URNAL
V	
V	VACUUM
VB	VARNISH
VBT	VAPOR BARRIER
VERT	VERTICAL
VJ	V-JOINT (ED)
VS	VACUUM SLIDE
VWB	VINYL WALL BORDER
VWC	VINYL WALL COVERING
VVL	VINYL
W	
W	WIDE OR WEST OR WOMEN
W	WITH
W	WITHOUT
WB	WOOD BASE
WC	WATER CLOSET OR WALL CABINET
WD	WOOD
WF	WIDE FLANGE
WG	WIRE GLASS
WH	WALL HUNG OR WATER HEATER
WIN	WINDOW
WP	WEATHERPROOF
WPT	WOOD PRESERVATIVE TREATMENT
WRB	WATER RESISTANT GYPSUM BACKING BOARD
WT	WEIGHT
WTF	WELDED WIRE FABRIC

REFERENCE SYMBOLS

DRAWING TITLE

1 FIRST FLOOR PLAN

DRAWING TITLE

SCALE OF DRAWING

DRAWING REFERENCE NUMBER

DRAWING REFERENCE NUMBER

DRAWING SHEET NUMBER

INTERIOR ELEVATIONS

1

4 A1.1 2

DRAWING REFERENCE NUMBER

DRAWING SHEET NUMBER

BUILDING/DETAIL SECTION

B1

A1.1

DRAWING REFERENCE NUMBER

DRAWING SHEET NUMBER

ENLARGED DETAIL

B1

A1.1

DRAWING REFERENCE NUMBER

DRAWING SHEET NUMBER

EXTERIOR ELEVATIONS

1

4 A1.1 2

DRAWING REFERENCE NUMBER

DRAWING SHEET NUMBER

MATCH LINE

A1


A1.1

DRAWING REFERENCE NUMBER

DRAWING SHEET NUMBER

MATERIAL SYMBOLS IN SECTION AND PLAN

EARTH	LOOSE OR BATT INSULATION	BRICK	STONE
GRANULAR FILL	RIGID INSULATION	STEEL	
CONCRETE	PLASTER	SOLID BRG. C.M.U.	
CONCRETE BLOCK	PLYWOOD	WOOD, FINISHED	
GYPSUM	BLOCKING / SHIM	WOOD, DIMENSIONAL	

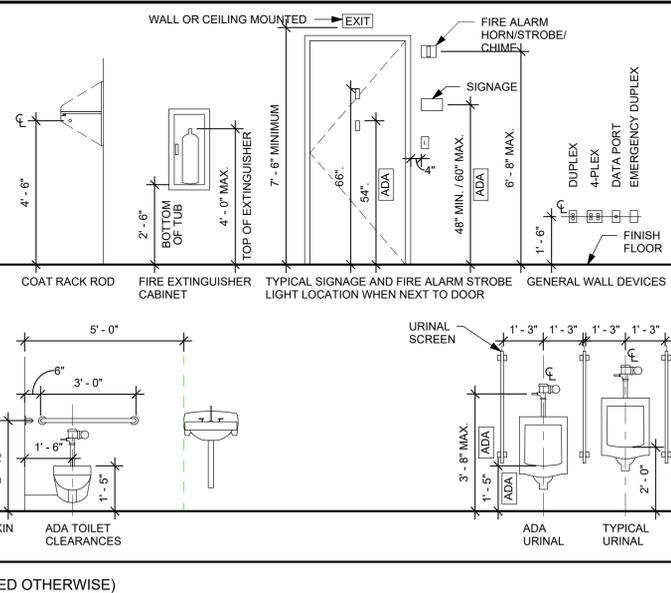

DRAWING SYMBOLS

COLUMN CENTER LINES

1 A

ROOM SYMBOL

ROOM NAME

ROOM NAME

ROOM NUMBER

ROOM NUMBER

PLAN SYMBOLS

00 CONSTRUCTION NOTES

00 DEMOLITION NOTES

00 ACCESSORIES (LETTERS)

101 DOOR NUMBER SYMBOL

101 WINDOW SYMBOL

A1 WALL TYPE

REVISION / CHANGE

F.D. FLOOR DRAIN

R.D. ROOF DRAIN

PROTECTIVE CORNER GUARD (PLAN VIEW)

C.G.

E.W.P.

END WALL PROTECTOR

●●●●● LIMIT OF CONSTRUCTION AREA

FEC FIRE EXTINGUISHER CABINET MOUNT @ 56" A.F.F. TO TOP OF UNIT

ELEVATION SYMBOLS

CHANGE IN ELEVATION

ELEVATION

TYPICAL WALL CONVENTIONS

EXISTING CONSTRUCTION TO BE REMOVED

EXISTING CONSTRUCTION TO REMAIN

NEW CONSTRUCTION (REMODELING)

FIRE RATED WALLS

X SMOKE-TIGHT BARRIER

1S SMOKE BARRIER

1 1 HOUR FIRE PARTITION

2 2 HOUR FIRE PARTITION

3 3 HOUR FIRE PARTITION

1F 1 HOUR FIRE WALL

2F 2 HOUR FIRE WALL

3F 3 HOUR FIRE WALL

REFLECTED CEILING SYMBOLS

○ SURFACE MOUNTED LIGHT FIXTURES

□ RECESSED LIGHT FIXTURES

○ CALL LIGHT

□ EXIT LIGHT

□ EMERGENCY EGRESS LIGHT WITH 90 MINUTE BATTERY

□ SUPPLY DIFFUSER

□ RETURN

□ SMOKE DETECTOR

□ SPEAKER

○ SPRINKLER HEAD

○ CURTAIN OR IV TRACK

○ CEILING HEIGHT

MOUNTING & CLEARANCE STANDARDS N.T.S.


(FOLLOW THESE UNLESS NOTED OTHERWISE)



ISSUE		
NO.	DATE	DESCRIPTION
	03.16.2026	FOR BID & PERMIT

DATE 3.16.26
JOB NO. 3853.04
DRAWN RNL
CHECKED MES/TAG
COPYRIGHT © 2026 - App Architecture, Inc.
TITLE ABBREVIATIONS AND SYMBOLS
SHEET NO.

A
B
C
D
E
F

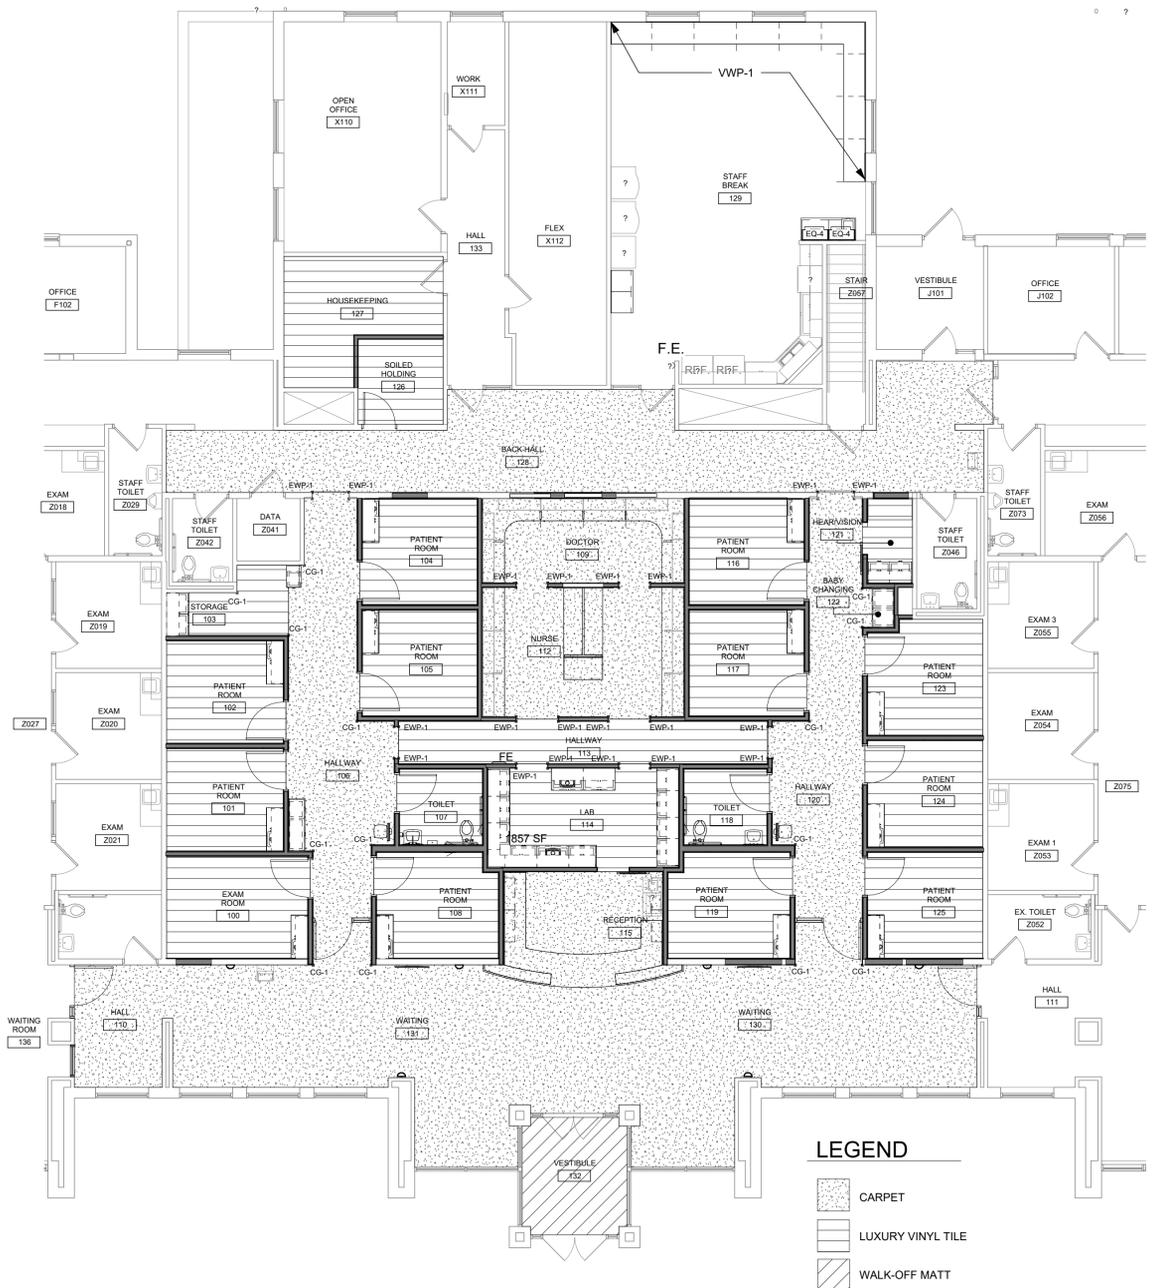

E1 NEW WORK FINISH PLAN
1/8" = 1'-0"

ROOM FINISH SCHEDULE											
ROOM No.	ROOM NAME	FLOOR	BASE	WAINSCOT		WALLS				CEILING	REMARKS
				MAT.	HT.	N	S	E	W		
100	EXAM ROOM	LVT-1	RB-3	VWP-1	SEE REMARKS	PW-1	PW-2	PW-1	PW-2	ACP-2	3
101	PATIENT ROOM	LVT-1	RB-3	VWP-1	SEE REMARKS	PW-1	PW-2	PW-1	PW-2	ACP-2	3
102	PATIENT ROOM	LVT-1	RB-3	VWP-1	SEE REMARKS	PW-2	PW-1	PW-1	PW-2	ACP-2	3
103	STORAGE	LVT-1	RB-3	VWP-1	SEE REMARKS	PW-1	PW-1	PW-1	PW-1	ACP-2	3
104	PATIENT ROOM	LVT-1	RB-3	VWP-1	SEE REMARKS	PW-3	PW-1	PW-3	PW-1	ACP-2	3
105	PATIENT ROOM	LVT-1	RB-3	VWP-1	SEE REMARKS	PW-3	PW-1	PW-3	PW-1	ACP-2	3
106	HALLWAY	C-1	RB-3			PW-1	PW-1	PW-1	PW-1	ACP-2	
107	TOILET	LVT-1	RB-2			PW-4	PW-4	PW-4	PW-4	ACP-2	
108	PATIENT ROOM	LVT-1	RB-3	VWP-1	SEE REMARKS	PW-1	PW-2	PW-2	PW-1	ACP-2	3, 10
109	DOCTOR	C-1	RB-3			PW-1	PW-1	PW-1	PW-1	ACP-2	
110	HALL	C-1	RB-3			PW-5	PW-5	PW-5	PW-5	ACP-2	
111	HALL	EX (C-1)	EX (RB-1)			PW-MATCH	EX	EX	PW-MATCH	EX	1, 4, 5, 6, 7
112	NURSE	C-1	RB-3			PW-1	PW-1	PW-1	PW-1	ACP-2	
113	HALLWAY	LVT-1	RB-3			PW-1	PW-1	PW-1	PW-1	ACP-2	
114	LAB	LVT-1	RB-3			PW-1	PW-1	PW-1	PW-1	ACP-2	
115	RECEPTION	C-1	RB-3			PW-2	PW-1	PW-1	PW-1	ACP-2	
116	PATIENT ROOM	LVT-1	RB-3	VWP-1	SEE REMARKS	PW-3	PW-1	PW-1	PW-3	ACP-2	3
117	PATIENT ROOM	LVT-1	RB-3	VWP-1	SEE REMARKS	PW-3	PW-1	PW-1	PW-3	ACP-2	3
118	TOILET	LVT-1	RB-2			PW-4	PW-4	PW-4	PW-4	ACP-2	
119	PATIENT ROOM	LVT-1	RB-3	VWP-1	SEE REMARKS	PW-1	PW-4	PW-1	PW-4	ACP-2	3, 10
120	HALLWAY	C-1	RB-3			PW-1	PW-1	PW-1	PW-1	ACP-2	
121	HEAR/VISION	LVT-1	RB-3			PW-1	PW-1	PW-1	PW-1	ACP-2	
122	BABY CHANGING	C-1	RB-3			PW-1	PW-1	PW-1	PW-1	ACP-2	
123	PATIENT ROOM	LVT-1	RB-3	VWP-1	SEE REMARKS	PW-1	PW-4	PW-4	PW-1	ACP-2	3
124	PATIENT ROOM	LVT-1	RB-3	VWP-1	SEE REMARKS	PW-1	PW-4	PW-4	PW-1	ACP-2	3
125	PATIENT ROOM	LVT-1	RB-3	VWP-1	SEE REMARKS	PW-1	PW-4	PW-4	PW-1	ACP-2	3
126	SOILED HOLDING	LVT-1	RB-1			PW-6	PW-6	PW-6	PW-6	ACP-2	6
127	HOUSEKEEPING	LVT-1	RB-1			PW-6	PW-6	PW-6	PW-6	ACP-2	6
128	BACK HALL	C-1	RB-1			PW-1	PW-1	PW-1	PW-1	ACP-1	1, 2
129	STAFF BREAK	EX	EX	VWP-2	SEE REMARKS	PW-2	PW-3	PW-2	PW-3	ACP-1	2, 3
130	WAITING	C-1	RB-3			PW-5	PW-5	PW-5	PW-5	ACP-2 / EXPS-1	1, 2, 8, 9
131	WAITING	C-1	RB-3			PW-5	PW-5	PW-5	PW-5	ACP-2 / EXPS-1	1, 2, 8, 9
132	VESTIBULE	MATT-1	RB-3			PW-5	PW-5	PW-5	PW-5	ACP-2	2
133	HALL	EX	EX			EX	EX	EX	EX	EX	
136	WAITING ROOM	EX (C-1)	EX (RB-1)			PW-MATCH	PW-MATCH	PW-MATCH	EX	EX	1, 4, 5, 6, 7

ROOM FINISH SCHEDULE REMARKS	
No.	REMARK
1	PATCH AND REPAIR OF EXISTING SURFACES REQUIRED. SEE FINISH PLANS FOR ADDITIONAL INFORMATION.
2	REPLACE ACOUSTIC CEILING TILE, EXISTING GRID TO REMAIN.
3	SEE INTERIOR ELEVATIONS FOR WALL PROTECTION EXTENTS
4	FIELD VERIFY EXISTING PAINT COLORS AND MATCH. COLOR AND FINISH. PROVIDE SAMPLE IN FIELD FOR ARCHITECT'S VERIFICATION
5	EXISTING FLOORING TO REMAIN. PATCH IN NEW CARPETING AT NEW DOOR AS REQUIRED.
6	EXISTING BASE TO REMAIN. PATCH IN NEW RUBBER BASE AT NEW DOOR/WALL. MATCH EXISTING RUBBER BASE COLOR, HEIGHT AND PROFILE IN ROOM.
7	IN EXISTING AREAS PAINT WALLS AS SCHEDULED CORNER TO CORNER
8	EXPOSED TO STRUCTURE CEILING TO REMAIN STAINED. WIPE ALL EXPOSED SURFACES WITH ENDUST (OR EQUAL)
9	PAINT GWB SOFFITS IN AREA
10	STOP PAINT ACCENT AT WALL PROTRUSION

MATERIAL LEGEND							
SORT MATERIAL	ITEM	MATERIAL	MANUFACTURER	MATERIAL MODEL NO.	COLOR	FLAME / SMOKE	CONTACT INFO
	XSSK-1	SOLID SURFACE INTERGRAL SINK					
BASE							
BASE	RB-1	RUBBER BASE	TARKETT	4" RUBBER COVE BASE	167 FUDGE		
BASE	RB-2	RUBBER BASE	TARKETT	REVEAL MW-XX-F6 (6" RUBBER MILLWORK BASE)	167 FUDGE		CUT DOWN TO FIT INTO TOE KICK SPACE
BASE	RB-3	RUBBER BASE	TARKETT	REVEAL MW-XX-F (4 1/4" RUBBER MILLWORK BASE)	167 FUDGE		CUT DOWN TO FIT INTO TOE KICK SPACE
CABINETS							
CABINETS	PL-1	PLASTIC LAMINATE	FORMICA	5904-58 (CASEGOODS LAMINATE)	WILD CHERRY		JANN GARVIN 513-786-3018
CABINETS	PL-2	PLASTIC LAMINATE	FORMICA	7012-58 (ACCENT LAMINATE)	AMBER MAPLE		JANN GARVIN 513-786-3018
CABINETS	PL-3	PLASTIC LAMINATE	WILSONART	4845-56 (WORKSURFACE/COUNTER TOPS)	TWILIGHT ZEPHYR		JANN GARVIN 513-786-3018
CABINETS	SSM-1	SOLID SURFACE	FORMICA	766 (RECEPTION DESK)	PORTOFINO MINERAL		
CEILING							
CEILING	ACP-1	ACOUSTIC CEILING PANELS	ARMSTRONG	DESIGNER ANGLED TEGULAR #737 (24" x 24")	WHITE		PROVIDE ARMSTRONG PRELUDE XL 15/16 GRID
CEILING	ACP-2	ACOUSTIC CEILING PANELS	ARMSTRONG	BEVELED TEGULAR #1752B (24" x 24")	WHITE		PROVIDE ARMSTRONG PRELUDE XL 15/16 GRID
CEILING	EXPS-1	EXPOSED STRUCTURE, EXISTING STAINED					
CEILING	GYPBD-1	GYPSTUM BOARD, PAINTED PW-7	SHERWIN WILLIAMS	CEILING WHITE (FLAT)	WHITE		MATCH EXISTING CEILING COLOR
DOOR							
DOOR	DEP-1	EPOXY PAINT	SHERWIN WILLIAMS	SW2856 (SEMI-GLOSS ENAMEL)	FAIRFAX BROWN		FOR HOLLOW METAL FRAMES AND DOORS
FLOOR							
FLOOR	C-1	CARPET	INTERFACE FLOORING	BERLIN, THE POND 1242202500	6704 PEAT		QUARTER TURN
FLOOR	LVT-1	LUXURY VINYL TILE	INTERFACE FLOORING	IN THE MIX	A03902 DUNE		50 CM X 50 CM MONOLITHIC INSTALLATION
FLOOR	MATT-1	WALK-OFF MATT	SHAW CONTRACT	STEPPING OUT COLLECTION WELCOME II TILE (24" x 24")	BLACK CHOCOLATE		QUARTER TURN
FLOOR	TS-1	TRANSITION STRIPS	JOHNSONITE	T-MOULDING TRANSITION FOR REQD. THICKNESSES	167 FUDGE		
SPECIALTY							
SPECIALTY	CG-1	CORNER GUARD	INPRO	160 HIGH IMPACT CORNER GUARD	EGGSHELL 0111		INSTALL 4'-0" HIGH
SPECIALTY	EW-1	END WALL PROTECTION	INPRO		EGGSHELL 0111		VWP TO MATCH CORNER GUARD COLOR
SPECIALTY	G-1	PETG	3 FORM	FOSSIL LEAF RANDOM (PATENT F03 FRONT & BACK (CLEAR) FINISH)	FOSSIL LEAF		SUSAN STUDER 859-653-4068 1/4" THICK
WALL							
WALL	AWC-1	ACOUSTICAL WALL COVERING	CARNEGIE	XOREL METEOR	705		TACK SURFACES
WALL	EX	EXISTING					
WALL	PW-1	PAINT	SHERWIN WILLIAMS	SW6133	MUSLIN		
WALL	PW-2	PAINT	SHERWIN WILLIAMS	SW6192	COASTAL PLAINS		
WALL	PW-3	PAINT	SHERWIN WILLIAMS	SW6121	WHOLE WHEAT		
WALL	PW-4	PAINT	SHERWIN WILLIAMS	SW6478	WATERY		
WALL	PW-5	PAINT	SHERWIN WILLIAMS	SW6408	WHEAT GRASS		
WALL	PW-6	PAINT	SHERWIN WILLIAMS	SW0035	WARM BEIGE		
WALL	PW-7	PAINT	SHERWIN WILLIAMS	SW7007	CEILING BRIGHT WHITE		
WALL	VWP-1	VINYL WALL PROTECTION	INPRO	ASPEX PATTERNS	LEGACY 2402		
WALL	VWP-2	VINYL WALL PROTECTION	INPRO	PALLADIUM .040" RIGID SHEET	ANTIQUE WHITE		
WALL	XEP-W	EPOXY PAINT	SHERWIN WILLIAMS	(SATIN SEMI-GLOSS EPOXY)			

GENERAL NOTES

A. PATCH AND REPAIR OF EXISTING SURFACES AS REQUIRED BY ENGINEERING WORK AND NOTED IN ENGINEERING GENERAL NOTES ARE INCLUDED IN THE SCOPE OF THIS PROJECT. CONTRACTOR TO FIELD VERIFY EXISTING CONDITIONS AND MATCH ADJACENT SURFACES AND FINISHES.


B. PATCH AND REPAIR OF EXISTING DRYWALL SURFACES AS NOTED IN THE ARCHITECTURAL GENERAL NOTES ARE INCLUDED IN THE SCOPE OF THIS PROJECT. CONTRACTOR TO FIELD VERIFY EXISTING CONDITIONS AND MATCH ADJACENT SURFACES AND FINISHES.

C. SCHEDULED BASE SHALL EXTEND AT CASEWORK BASE UNITS, INTO OPEN / KNEE SPACES AND AT EQUIPMENT BASES.

D. TRANSITION STRIPS ARE REQUIRED AT FLOORING MATERIAL CHANGES.

E. PAINT SOFFITS AND BULKHEADS IN AREA OF WORK. SEE FINISH SCHEDULE FOR COLOR.

F. PAINT HOLLOW METAL DOORS AND FRAMES IN AREA OF WORK. SEE FINISH SCHEDULE FOR COLOR.

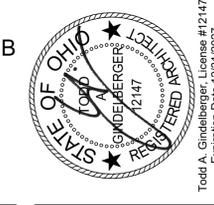

APP Architecture
creative focused design

615 Woodside Drive, Englewood, Ohio 45322
T 937.836.8898 F 937.832.3696
www.app-arch.com

APP Architecture
creative focused design

615 Woodside Drive, Englewood, Ohio 45322
T 937.836.8898 F 937.832.3696
www.app-arch.com

APP Architecture
creative focused design

615 Woodside Drive, Englewood, Ohio 45322
T 937.836.8898 F 937.832.3696
www.app-arch.com


ISSUE

NO.	DATE	DESCRIPTION
	03.16.2026	FOR BID & PERMIT


DATE 3.16.26
JOB NO. 3853.04
DRAWN RNL
CHECKED MES/TAG
COPYRIGHT © 2026 - App Architecture, Inc.
TITLE ROOM FINISH SCHEDULE

SHEET NO. **A0.2**


3/27/2026 11:05:48 AM

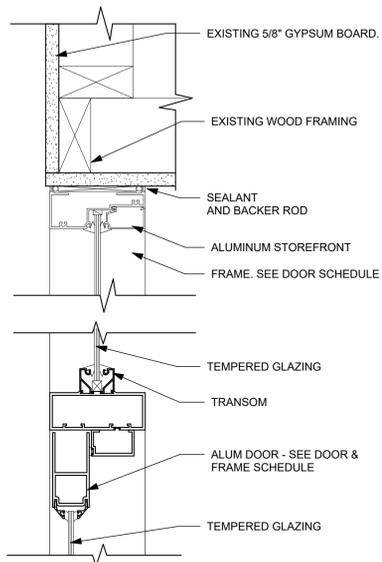


C1 HEAD DETAIL - INTERIOR STOREFRONT
3" = 1'-0"

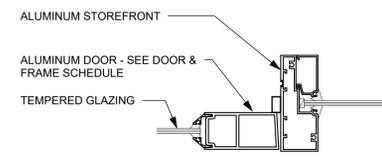

D1 JAMB DETAIL - INTERIOR STOREFRONT
3" = 1'-0"

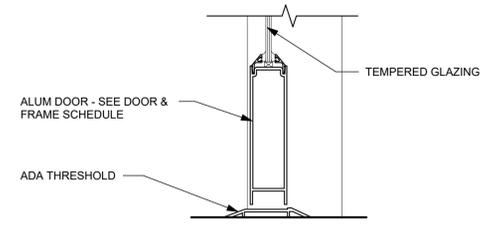

E1 SILL DETAIL - INTERIOR STOREFRONT
3" = 1'-0"


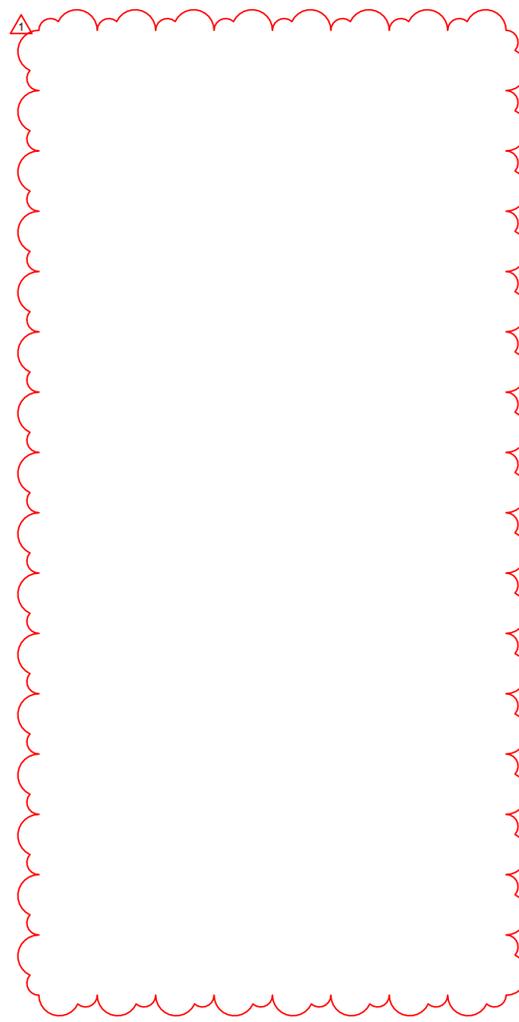


DOOR, WINDOW AND FRAME SCHEDULE


DOOR No.	ROOM NAME	DOOR			FRAME			DETAILS			FIRE RTG.	HDW. SET	REMARKS			
		W	H	T	MAT.	TYPE	FIN.	MAT.	TYPE	FIN.				JAMB	HEAD	SILL
100	EXAM ROOM	3'-6"	7'-0"	1 3/4"	WD	F1	STAIN	HM	1	PAINT	F5/A0.3	F6/A0.3			1	1,6
101	PATIENT ROOM	3'-6"	7'-0"	1 3/4"	WD	F1	STAIN	HM	1	PAINT	F5/A0.3	F6/A0.3			1	1,6
102	PATIENT ROOM	3'-6"	7'-0"	1 3/4"	WD	F1	STAIN	HM	1	PAINT	F5/A0.3	F6/A0.3			1	1,6
104	PATIENT ROOM	3'-6"	7'-0"	1 3/4"	WD	F1	STAIN	HM	1	PAINT	F5/A0.3	F6/A0.3			1	1,6
105	PATIENT ROOM	3'-6"	7'-0"	1 3/4"	WD	F1	STAIN	HM	1	PAINT	F5/A0.3	F6/A0.3			1	1,6
106	HALLWAY	3'-6"	7'-0"	1 3/4"	WD	FG1	STAIN	HM	2	PAINT	F5/A0.3	F6/A0.3			3	1,8
107	TOILET	3'-6"	7'-0"	1 3/4"	WD	F1	STAIN	HM	1	PAINT	F5/A0.3	F6/A0.3			2	1,9
108	PATIENT ROOM	3'-6"	7'-0"	1 3/4"	WD	F1	STAIN	HM	1	PAINT	F5/A0.3	F6/A0.3			1	1,6
110	HALL	3'-8"	8'-0"	1 3/4"	ALUM	AL2	ANOD.	ALUM	3	ANOD.	D1/A0.3	C1/A0.3	E1/A0.3		4	11
115	RECEPTION	3'-0"	7'-0"	2"	WD	FG1	STAIN	-	-	-	-	-	-	-	6	1,2,5
116	PATIENT ROOM	3'-6"	7'-0"	1 3/4"	WD	F1	STAIN	HM	1	PAINT	F5/A0.3	F6/A0.3			1	1,6
117	PATIENT ROOM	3'-6"	7'-0"	1 3/4"	WD	F1	STAIN	HM	1	PAINT	F5/A0.3	F6/A0.3			1	1,6
118	TOILET	3'-6"	7'-0"	1 3/4"	WD	F1	STAIN	HM	1	PAINT	F5/A0.3	F6/A0.3			2	1,9
119	PATIENT ROOM	3'-6"	7'-0"	1 3/4"	WD	F1	STAIN	HM	1	PAINT	F5/A0.3	F6/A0.3			1	1,6
120	HALLWAY	3'-6"	7'-0"	1 3/4"	WD	F1	STAIN	HM	2	PAINT	F5/A0.3	F6/A0.3			3	1,8
121	HEAR/VISION	3'-0"	7'-0"	2"	WD	FG1	STAIN	-	-	-	-	-	-	-	6	1,2,5
123	PATIENT ROOM	3'-6"	7'-0"	1 3/4"	WD	F1	STAIN	HM	1	PAINT	F5/A0.3	F6/A0.3			1	1,6
124	PATIENT ROOM	3'-6"	7'-0"	1 3/4"	WD	F1	STAIN	HM	1	PAINT	F5/A0.3	F6/A0.3			1	1,6
125	PATIENT ROOM	3'-6"	7'-0"	1 3/4"	WD	F1	STAIN	HM	1	PAINT	F5/A0.3	F6/A0.3			1	1,6
126	SOILED HOLDING	3'-0"	7'-0"	1 3/4"	WD	F1	STAIN	HM	1	PAINT	F5/A0.3	F6/A0.3			5	1,8
127	HOUSEKEEPING	3'-0"	6'-8"	1 3/4"	WD	EX	EX	EX	EX	EX	EX	EX	-	-	7	3,10
129	STAFF BREAK	3'-0"	7'-0"	1 3/4"	WD	EX	EX	EX	EX	EX	EX	EX	-	-	EX	4
130	WAITING	3'-8"	8'-0"	1 3/4"	ALUM	AL2	ANOD.	ALUM	3	ANOD.	D1/A0.3	C1/A0.3	E1/A0.3		4	11
W129	DOCTOR	3'-10"	1'-6"	-	-	-	PAINT	HM/EX	4	PAINT	E6/A0.3	E6/A0.3	E6/A0.3		-	13
W130	DOCTOR	3'-6"	1'-6"	-	-	-	PAINT	HM/EX	4	PAINT	E6/A0.3	E6/A0.3	E6/A0.3		-	13
W131	DOCTOR	3'-10"	1'-6"	-	-	-	PAINT	HM/EX	4	PAINT	E6/A0.3	E6/A0.3	E6/A0.3		-	13
W138	NURSE	3'-10"	1'-6"	-	-	-	PAINT	HM/EX	4	PAINT	E6/A0.3	E6/A0.3	E6/A0.3		-	13
W110	HALL	3'-0"	8'-0"	-	-	-	ANOD.	ALUM	6	ALUM	C1/A0.3	C1/A0.3	-		-	13

DOOR REMARKS


- NEW DOOR SHALL BE SELECT WHITE BIRCH AND SHALL MATCH EXISTING DOORS GRAIN, FINISH AND COLOR.
- SLIDING BARN DOOR AND TRACK LOCKABLE.
- EXISTING DOOR AND FRAME.
- EXISTING DOOR AND FRAME TO REMAIN, ADD 3FORM LEAF ACRYLIC TO LITE AND TRANSOM.
- REUSE EXISTING 3FORM LEAF ACRYLIC PANEL WITHIN DOOR, FIELD VERIFY SIZE OF EXISTING 3FORM PANEL.
- (1) COAT HOOK THIS DOOR CENTER ON ROOM SIDE OF DOOR AT 54" A.F.F.
- PASSAGE SETS FROM ORIGINAL OFFICES
- OFFICE LOCKETS FROM CURRENT ADMIN OR STORAGE AREAS.
- PRIVACY LOCKSETS FROM CURRENT TOILET ROOMS
- CARD READER ADDED TO EXISTING DOOR AND FRAME, SEE HARDWARE SET
- DOOR INCLUDES MAGNETIC HOLD OPEN AND CARD READER
- CUT DOWN AND USE EXISTING 3FORM LEAF ACRYLIC PANEL WITHIN WINDOW, FIELD VERIFY SIZES OF EXISTING 3FORM PANELS.
- SALVAGED HOLLOW METAL BORROWED LITE FRAME WITH EXISTING 3FORM PANEL, PAINT FRAME.

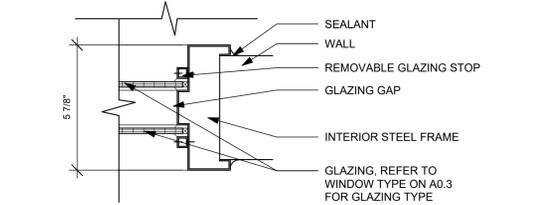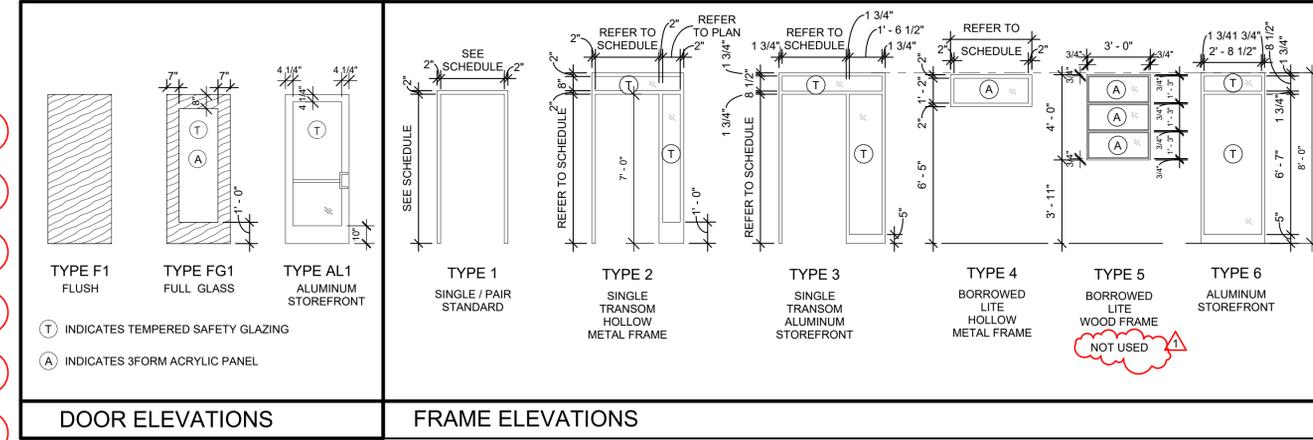


E5 HM WINDOW JAMB DETAIL - DOUBLE PANE
3" = 1'-0"

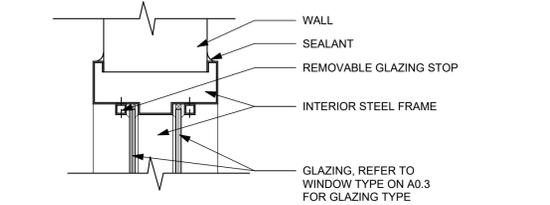

E6 HM WINDOW HEAD DETAIL - DOUBLE PANE
3" = 1'-0"

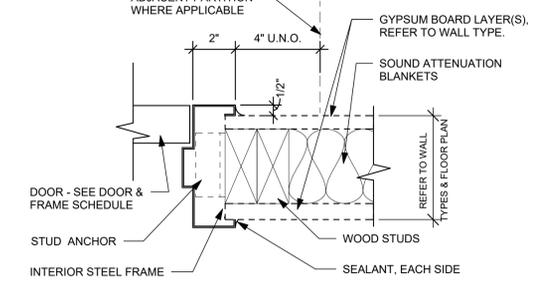


F5 TYP. JAMB DETAIL @ INT. GYP.
3" = 1'-0"

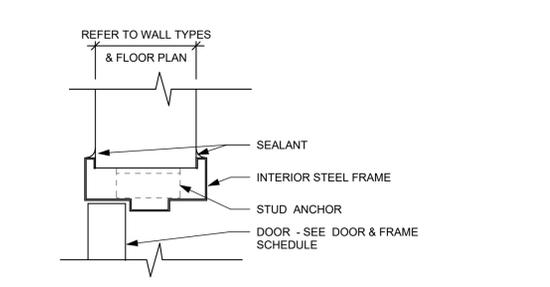

F6 TYP. HEAD DETAIL @ INT. GYP.
3" = 1'-0"

APP Architecture
creative focused design
615 Woodside Drive, Englewood, Ohio 45322
T 937.836.8898 F 937.832.3696
www.app-arch.com

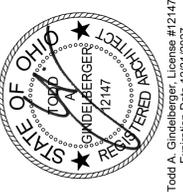

POD 3 INTERIOR RENOVATION
FAMILY HEALTH SERVICES OF
DARKE COUNTY
5735 MEEKER ROAD, GREENVILLE, OH 45331

ISSUE

NO.	DATE	DESCRIPTION
1	03.16.2026	FOR BID & PERMIT
1	03.20.2026	ADDENDUM #1

DATE	3.16.26
JOB NO.	3853.04
DRAWN	RNL
CHECKED	MES/TAG
COPYRIGHT © 2026 - App Architecture, Inc.	
TITLE	DOOR, FRAME, AND WINDOW SCHEDULE

SHEET NO.
A0.3

1

2

3

4

5

6

7

TYPICAL WALL TYPE

GENERAL NOTES

TYPE	BASE WALL WIDTH	FIRE RATING TESTING AGENCY, ASSEMBLY NO.	DETAILS & NOTES
W1	3 1/2"	-	<p>DECK OR TRUSS 4 3/4"</p> <p>5/8" TYPE "X" GYPSUM BOARD</p> <p>2" X 4" WOOD FRAMING @ 16" o.c.</p> <p>3 1/2" SOUND ATTENUATION</p> <p>5/8" TYPE "X" GYPSUM BOARD</p> <p>CEILING (WHERE APPLICABLE)</p> <p>FLOOR</p> <p>NOTES: ACOUSTICAL PARTITION</p>
W2	3 1/2"	-	<p>DECK OR TRUSS 5 7/8"</p> <p>5/8" TYPE "X" GYPSUM BOARD</p> <p>2" X 4" WOOD FRAMING @ 16" O.C.</p> <p>(2) LAYERS 5/8" TYPE "X" GYPSUM BOARD AT TOILET ROOM OR PATIENT ROOM SIDE</p> <p>HORIZONTAL 1/2" RESILIENT SOUND CHANNEL @ 24" O.C.</p> <p>3 1/2" SOUND ATTENUATION</p> <p>CEILING (WHERE APPLICABLE)</p> <p>FLOOR</p> <p>NOTES: DOUBLE LAYER OF GYPSUM BOARD TOILET ROOM / ROOM SIDE. ACOUSTICAL PARTITION</p>
W3	5 1/2"	-	<p>DECK OR TRUSS 7 7/8"</p> <p>5/8" TYPE "X" GYPSUM BOARD</p> <p>2" X 6" WOOD FRAMING @ 16" O.C.</p> <p>(2) LAYERS 5/8" TYPE "X" GYPSUM BOARD AT TOILET ROOM OR PATIENT ROOM SIDE</p> <p>HORIZONTAL 1/2" RESILIENT SOUND CHANNEL @ 24" O.C.</p> <p>3 1/2" SOUND ATTENUATION</p> <p>CEILING (WHERE APPLICABLE)</p> <p>FLOOR</p> <p>NOTES: DOUBLE LAYER OF GYPSUM BOARD TOILET ROOM / ROOM SIDE. ACOUSTICAL PARTITION</p>
W4	3 1/2"	--	<p>DECK OR TRUSS 4 1/8"</p> <p>5/8" TYPE "X" GYPSUM BOARD</p> <p>2" X 4" WOOD FRAMING @ 16" O.C.</p> <p>3 1/2" SOUND ATTENUATION</p> <p>CEILING (WHERE APPLICABLE)</p> <p>FLOOR</p>
W5	3 1/2"	-	<p>DECK OR TRUSS 4 3/4"</p> <p>2" X 4" WOOD FRAMING @ 16" o.c.</p> <p>(2) LAYERS 5/8" TYPE "X" GYPSUM BOARD</p> <p>3 1/2" SOUND ATTENUATION</p> <p>CEILING (WHERE APPLICABLE)</p> <p>FLOOR</p>

- A. MOISTURE/MOLD RESISTANT GYPSUM BOARD SHALL BE USED BEHIND ALL SINKS, SERVICE SINKS AND SHOWER AREAS. EXTEND MINIMUM 24" BEYOND PLUMBING FIXTURES.
- B. REFER TO FLOOR PLANS FOR LOCATIONS OF INTERIOR PARTITION TYPES.
- C. ALL PENETRATIONS IN FIRE RATED PARTITIONS SHALL BE FIRESTOPPED, WHETHER THEY ARE NEW OR EXISTING, INCLUDING THOSE CREATED BY THE REMOVAL OF AN EXISTING PENETRATING ITEM. FIRESTOPPING SYSTEMS SHALL BE FM OR U.L. LABORATORY APPROVED PRODUCTS.
- D. AT ALL STC-RATED ACOUSTICAL / SOUND CONTROL TYPE PARTITIONS APPLY ACOUSTICAL SEALANT AT PERIMETER OF PARTITION AND AROUND ELECTRICAL RECEPTACLES, PIPES & DUCT PENETRATIONS. ACOUSTICAL SEALANT SHALL BE APPLIED TO BOTH FACES OF PARTITION.
- E. ACOUSTICAL PARTITION REQUIREMENTS: AT ALL PATIENT, PROCEDURE, HEAR/VISION, AND TOILET ROOMS APPLY ACOUSTICAL SEALANT AT PERIMETER OF PARTITION, PIPES & DUCT PENETRATIONS. ACOUSTICAL SEALANT SHALL BE APPLIED TO ROOM SIDE FACE OF PARTITION.
- F. EXISTING BUILDING FLOOR TO FLOOR HEIGHTS FOR AREA OF WORK:
 - BASEMENT TO FIRST FLOOR: 12'-0" +/-
 - FIRST FLOOR TO TRUSS BEARING: 10'-8" +/-



POD 3 INTERIOR RENOVATION
FAMILY HEALTH SERVICES OF DARKE COUNTY
 5735 MEEKER ROAD, GREENVILLE, OH 45331


ISSUE		
NO.	DATE	DESCRIPTION
03.16.2026	FOR BID & PERMIT	

DATE	3.16.26
JOB NO.	3853.04
DRAWN	RNL
CHECKED	MES/TAG

COPYRIGHT © 2026 - App Architecture, Inc.
 TITLE
WALL TYPES

SHEET NO.
A0.4


3/27/2026 11:05:52 AM

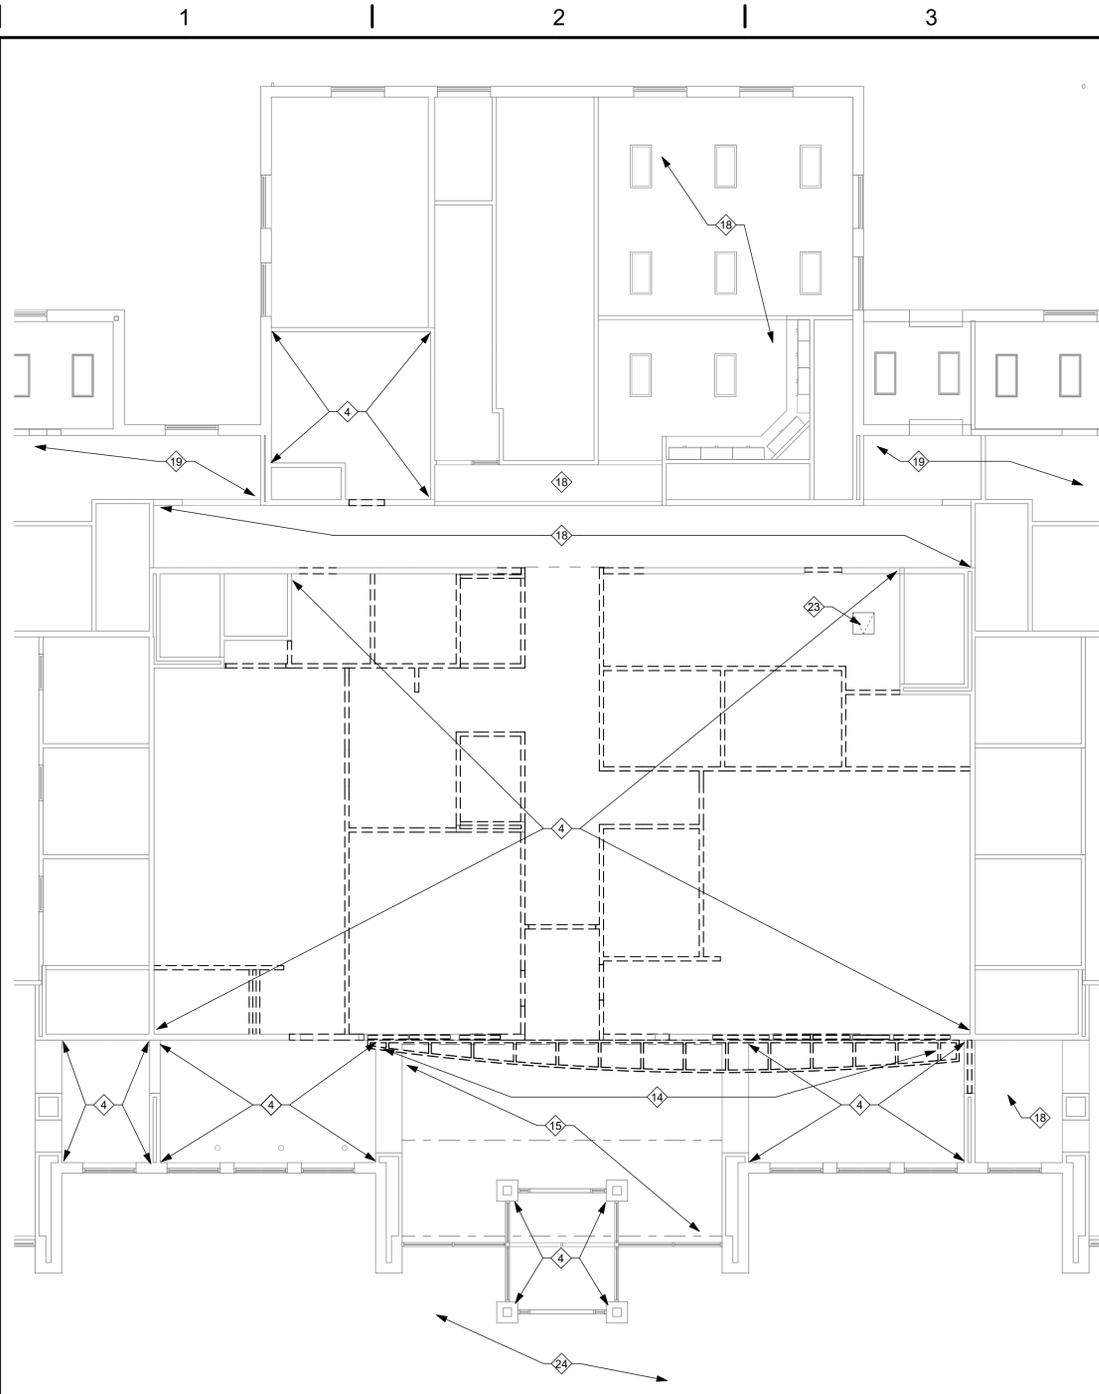

E1 DEMOLITION REFLECTED CEILING PLAN
1/8" = 1'-0"



E4 DEMOLITION FLOOR PLAN POD 3
1/8" = 1'-0"

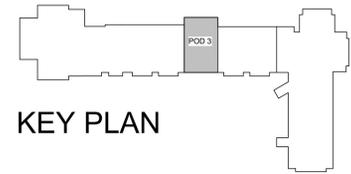

DEMOLITION NOTES

- ◇ INDICATES DEMOLITION NOTE.
- 1 REMOVE AND DISPOSE OF EXISTING WALL, TYPICAL
- 2 REMOVE AND DISPOSE OF EXISTING DOOR AND FRAME. SALVAGE DOOR HARDWARE FOR POSSIBLE REUSE. DISPOSE OF UNUSED HARDWARE AT CLOSE OF PROJECT. SEE DOOR SCHEDULE, SHEET A0.3.
- 3 REMOVE AND DISPOSE OF EXISTING FLOOR FINISH AND WALL BASE THROUGHOUT ROOM.
- 4 REMOVE AND DISPOSE OF EXISTING CEILINGS THROUGHOUT, INCLUSIVE OF ACOUSTIC PANEL CEILING AND DRYWALL CEILINGS. SEE ELECTRICAL DRAWINGS FOR ADDITIONAL INFORMATION.
- 5 REMOVE PLUMBING FIXTURE. SEE PLUMBING DRAWINGS.
- 6 SALVAGE EXISTING TOILET ACCESSORIES, INCLUSIVE OF GRAB BARS, SOAP DISPENSER, HAND DRYER, BABY CHANGING STATION, TOILET PAPER DISPENSER, ETC. SEE NEW WORK PLAN FOR REINSTALLATION INFORMATION.
- 7 REMOVE AND DISPOSE OF EXISTING CASEWORK AND/OR COUNTERTOPS.
- 8 REMOVE PASS THRU WINDOW, COUNTER, AND OVERHEAD COILING DOOR, SALVAGE 3 FORM TRANSOM PANEL FOR POSSIBLE REINSTALLATION. TURN OVER TO OWNER FOR STORAGE IF NOT UTILIZED.
- 9 SALVAGE TRANSOM WINDOW SEE NEW WORK PLAN AND DOOR SCHEDULE FOR REINSTALLATION LOCATION, PROTECT DURING CONSTRUCTION.
- 11 REMOVE EXISTING SHELVING AND BRACKETS AND STANDARDS, TURN OVER TO OWNER AND COORDINATE STORAGE LOCATION
- 12 REMOVE AND DISPOSE OF EXISTING COAT RACK.
- 13 CUT NEW OPENING IN PARTITION. SEE NEW WORK DIMENSION PLAN FOR LOCATION AND EXTENTS OF OPENINGS. SEE STRUCTURAL PLAN FOR FRAMING INFORMATION.
- 14 REMOVE WOOD TRELLIS, SEE NEW WORK REFLECTED CEILING PLAN FOR NEW TRELLIS
- 15 EXISTING OPEN WOOD TRUSSES AND WOOD PLANK CEILING TO REMAIN. PROTECT.
- 16 REMOVE AND DISPOSE OF EXISTING DOOR AND FRAME. SALVAGE DOOR HARDWARE FOR POSSIBLE REUSE. DISPOSE OF UNUSED HARDWARE AT CLOSE OF PROJECT. SALVAGE 3FORM PANEL FOR REUSE. SEE DOOR SCHEDULE, SHEET A0.3.
- 17 COORDINATE LOCATION OF RELOCATED BORROWED LITES AND TRANSOMS. CUT IN NEW OPENINGS AND HEADERS.
- 18 EXISTING CEILING GRID TO REMAIN IN THIS ROOM. REMOVE AND DISPOSE OF EXISTING ACOUSTIC TILE PANELS.
- 19 SEE ALTERNATE #1 FOR WORK IN THIS AREA
- 20 REMOVE CARPET, RUBBER BASE TO REMAIN, PREP FOR NEW FLOORING.
- 21 STOP CARPET REMOVAL HERE, REMOVE FULL PADS ONLY
- 22 EXISTING FLOORING AND BASE TO REMAIN, UNLESS NOTED OTHERWISE
- 23 REMOVE AND SALVAGE EXISTING ATTIC ACCESS PANEL. SEE NEW WORK RCP FOR REINSTALLATION LOCATION.
- 24 SEE ELECTRICAL DRAWINGS FOR LIGHT FIXTURE WORK AT PORTE COCHERE

GENERAL NOTES

- A. RETAIN EXISTING TOILET ACCESSORIES FOR POSSIBLE REUSE. TURN REMAINING UNUSED ITEMS OVER TO OWNER OR DISPOSE OF AT THE OWNER'S DIRECTION.
- B. COORDINATE DEMOLITION WITH PME DRAWINGS.
- C. PRIOR TO CONSTRUCTION, FIELD INVESTIGATE EXISTING CONDITIONS AND NOTIFY ARCHITECT (OWNER) OF ANY DISCREPANCIES.
- D. PRIOR TO CONSTRUCTION, FIELD VERIFY EXISTING DIMENSIONS AND FLOOR ELEVATIONS AND NOTIFY ARCHITECT (OWNER) OF ANY DISCREPANCIES.
- E. REPAIR, LEVEL, AND PREPARE EXISTING CONCRETE FLOOR SLABS TO RECEIVE NEW FLOOR FINISH INCLUDING AREAS WHERE OLD WALLS ARE REMOVED.
- F. EXISTING WALL SURFACES TO RECEIVE NEW SCHEDULED FINISHES SHALL BE PREPARED IN A MANNER ACCEPTABLE TO THE FINISH MANUFACTURER.
- G. PRIOR TO DEMOLITION, VERIFY THAT EXISTING UTILITIES HAVE BEEN DISCONNECTED AND CAPPED, AND TEMPORARY SHORING IS IN PLACE TO PREVENT MOVEMENT, SETTLEMENT, OR COLLAPSE OF CONSTRUCTION.
- H. BEFORE PROCEEDING WITH ANY WORK IN THE EXISTING STRUCTURE, THE CONTRACTOR SHALL FAMILIARIZE HIMSELF WITH EXISTING STRUCTURAL CONDITIONS. IT SHALL BE THE CONTRACTOR'S RESPONSIBILITY TO PROVIDE ALL NECESSARY BRACING, SHORING, AND OTHER SAFEGUARDS TO MAINTAIN ALL PARTS OF THE EXISTING WORK IN A SAFE CONDITION DURING THE PROCESS OF DEMOLITION AND CONSTRUCTION AND TO PROTECT FROM DAMAGE THOSE PORTIONS OF THE EXISTING WORK WHICH ARE TO REMAIN.
- I. THE CONTRACTOR SHALL FIELD VERIFY THE DIMENSIONS, ELEVATIONS, ETC. NECESSARY FOR THE PROPER CONSTRUCTION AND ALIGNMENT OF THE NEW PORTIONS OF THE WORK TO THE EXISTING WORK. THE CONTRACTOR SHALL MAKE ALL MEASUREMENTS NECESSARY FOR FABRICATION AND ERECTION OF STRUCTURAL MEMBERS. ANY DISCREPANCY SHALL BE IMMEDIATELY BROUGHT TO THE ATTENTION OF THE ARCHITECT/ENGINEER.
- J. NEATLY CUT OPENINGS AND HOLES PLUMB, SQUARE, AND TRUE TO DIMENSIONS REQUIRED. USE CUTTING METHODS LEAST LIKELY TO DAMAGE CONSTRUCTION TO REMAIN OR ADJOINING CONSTRUCTION. USE HAND TOOLS OR SMALL POWER TOOLS DESIGNED FOR SAWING OR GRINDING, NOT HAMMERING AND CHOPPING, TO MINIMIZE DISTURBANCE OF ADJACENT SURFACES. TEMPORARILY COVER OPENINGS TO REMAIN.

APP Architecture
creative focused design

615 Woodside Drive, Englewood, Ohio 45322
T 937.836.8898 F 937.832.3696
www.app-arch.com

STATE OF OHIO
ARCHITECT
TODD A. GINDLBERGER
12147
REGISTERED
Expiration Date 12/31/2027

POD 3 INTERIOR RENOVATION
FAMILY HEALTH SERVICES OF
DARKE COUNTY

5735 MEEKER ROAD, GREENVILLE, OH 45331

ISSUE		
NO.	DATE	DESCRIPTION
1	03.16.2026	FOR BID & PERMIT
	03.20.2026	ADDENDUM #1

E

DATE	3.16.26
JOB NO.	3853.04
DRAWN	RNL
CHECKED	MES/TAG

COPYRIGHT © 2026 - App Architecture, Inc.

TITLE
DEMOLITION FLOOR PLAN

SHEET NO.
A1.1

3/27/2026 11:05:54 AM

1 | 2 | 3 | 4 | 5 | 6 | 7

A


B

C


D

E

F

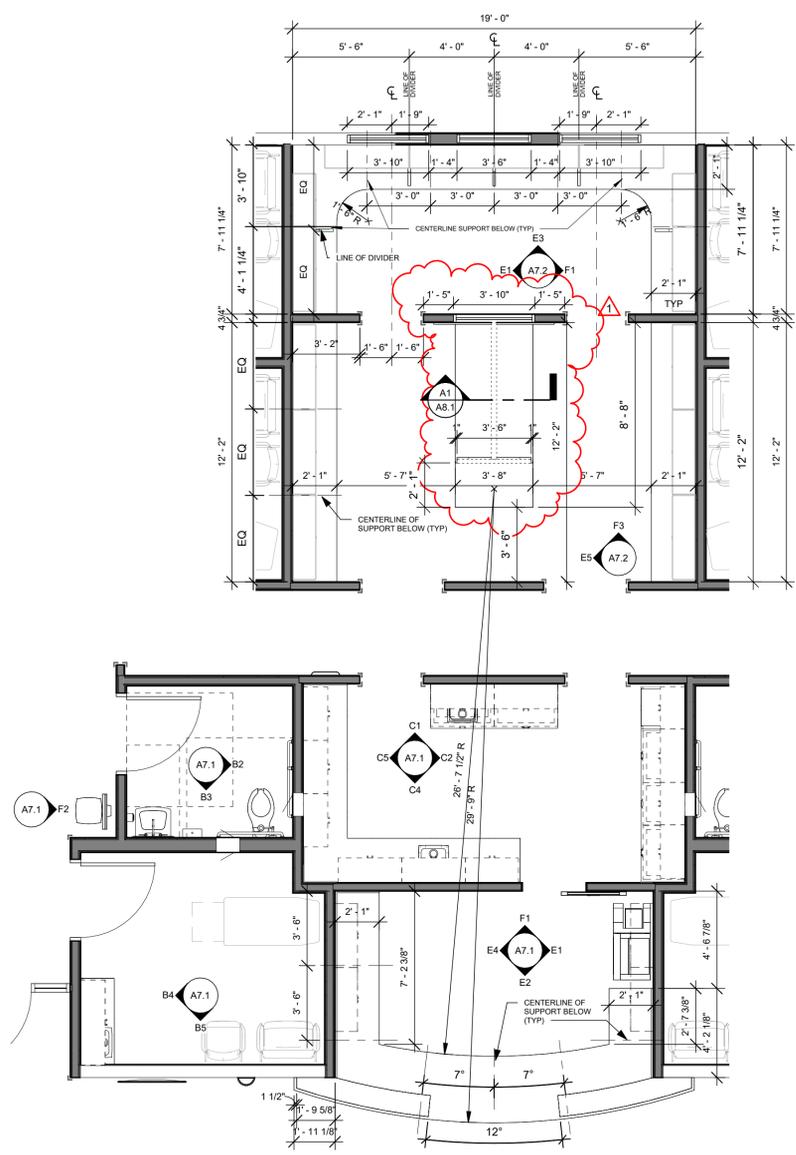

E1 ENLARGED NEW WORK PLAN
1/4" = 1'-0"

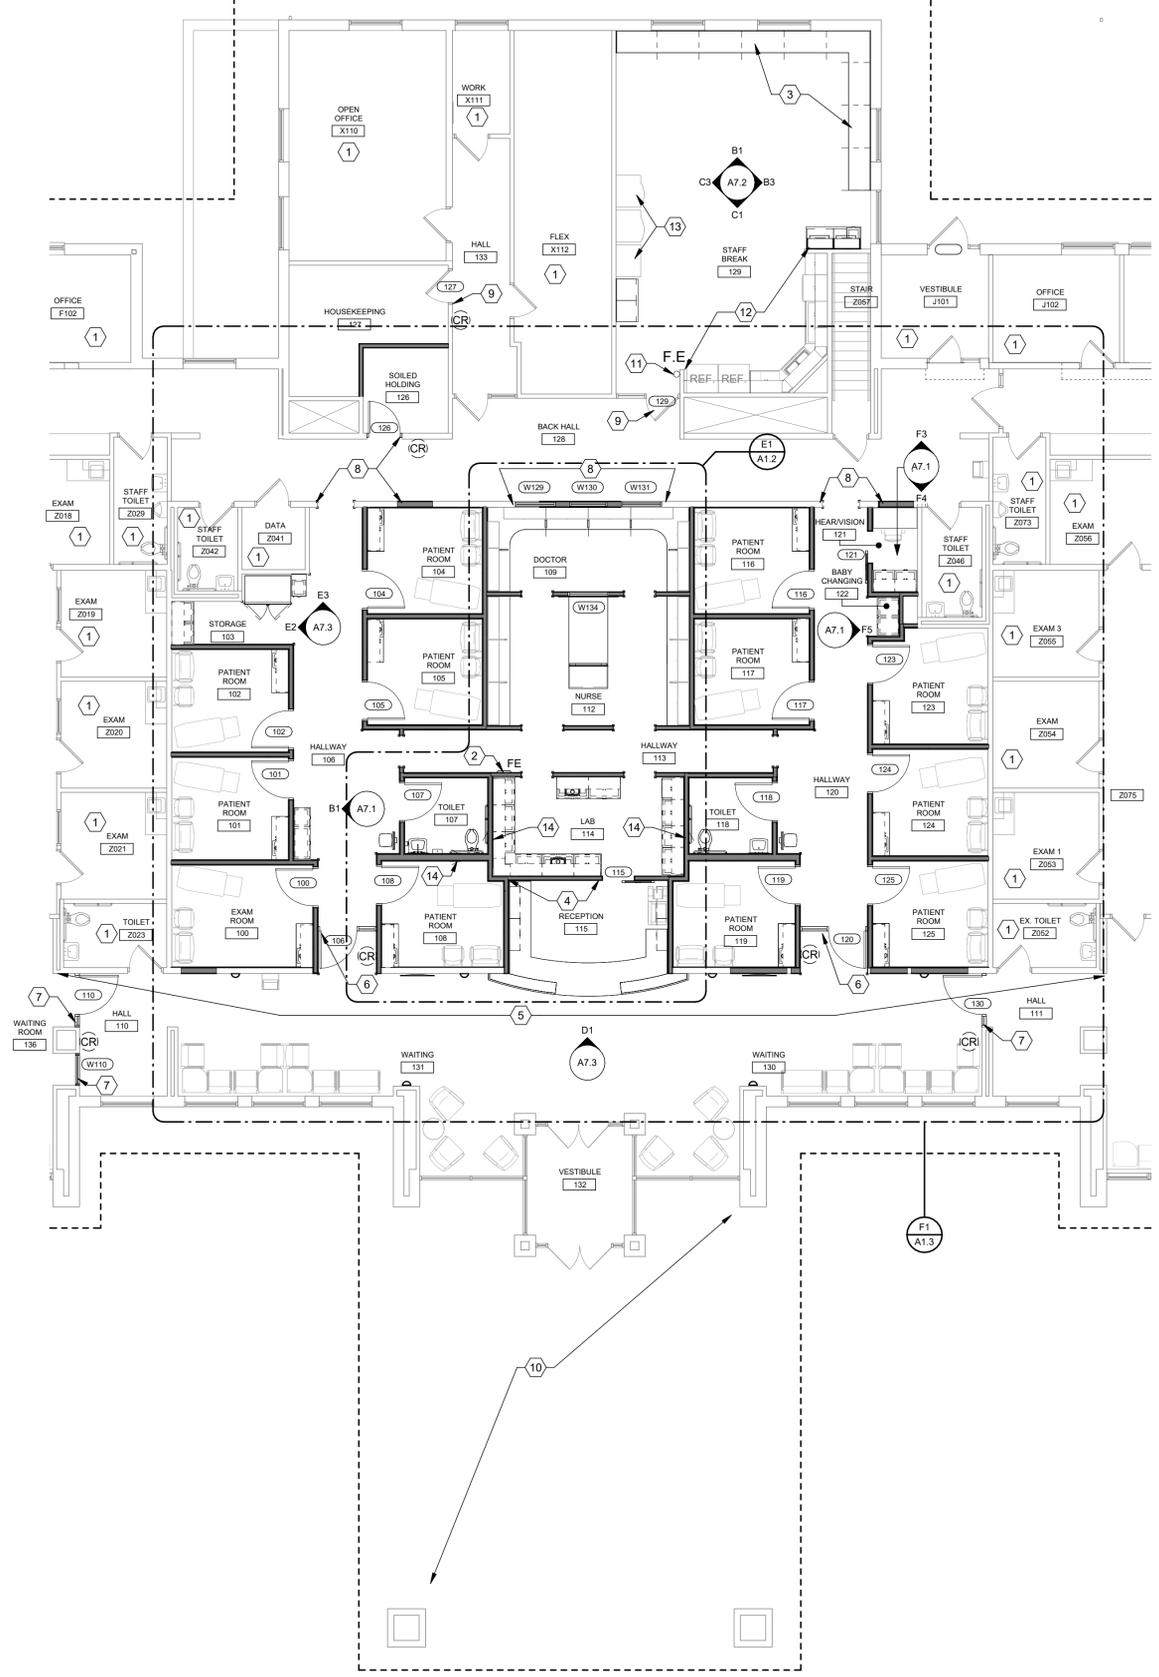

F4 NEW WORK REFERENCE PLAN
1/8" = 1'-0"

CONSTRUCTION NOTES


- 00 INDICATES CONSTRUCTION NOTE.
- 1 NO WORK IN THIS AREA
- 2 PROVIDE AND INSTALL SEMI-RECESSED FIRE EXTINGUISHER CABINET. SEE A0 1 FOR MOUNTING HEIGHTS. MAXIMUM 4" PROJECTION.
- 3 PROVIDE AND INSTALL SOLID SURFACE COUNTERTOP WITH SIDE AND BACK SPLASH SUPPORTED WITH METAL BRACKET, SECURED INTO STUDS, SPACED MAX. 4'-0" O.C.
- 4 PROVIDE LEVEL 5 DRYWALL FINISH FOR VINYL WALL SIGN
- 5 PATCH AND REPAIR DRYWALL FINISH FULL LENGTH OF WALL. PROVIDE SEAMLESS FINISH END TO END. COORDINATE CONTROL JOINT LOCATIONS WITH ARCHITECT IN FIELD.
- 6 HOLLOW METAL FRAME TO FILL DRYWALL OPENING. AT JAMBS AND HEAD, PROVIDE BLOCKING AND ANCHORING AS REQUIRED TO SECURE FRAME.
- 7 FIT STOREFRONT INTO EXISTING OPENING. PROVIDE BLOCKING IN EXISTING WALL AS REQUIRED.
- 8 PATCH AND REPAIR DRYWALL AT INFILLED OPENING, AND CUT IN DOOR/OPENING LOCATIONS.
- 9 EXISTING DOOR AND FRAME TO REMAIN SEE DOOR SCHEDULE FOR EXTENT OF WORK
- 10 CONTRACTOR TO TOUCH UP PAINT AT PORTE COCHERE, AS REQUIRED, AFTER LIGHT FIXTURE REPLACEMENTS AND REMOVALS. LIGHT FIXTURE BOXES, AT REMOVED LIGHTS, WILL REMAIN WITH A NEW COVER PLATE. COVER PLATE TO BE PAINTED TO MATCH WOOD TRIM COLOR.
- 11 EXISTING FIRE EXTINGUISHER TO REMAIN
- 12 EXISTING KITCHEN APPLIANCES, FIXTURES AND CASEWORK TO REMAIN.
- 13 EXISTING VENDING MACHINES TO REMAIN ACCESSIBLE DURING CONSTRUCTION. COORDINATE RELOCATION WITH OWNER FOR NEW CASEWORK INSTALLATION.
- 14 SPECIMEN PASS BOX.

LEGEND

- CR = CARD READER
- A = AUTOMATIC DOOR OPERATOR
- PA = PUSH ACTUATOR

GENERAL NOTES

- A. PROTECT EXISTING TO REMAIN CONSTRUCTION FROM DAMAGE DURING NEW CONSTRUCTION WORK.
- B. OCCUPIED AREAS SHALL REMAIN OPERATIONAL DURING CONSTRUCTION. CONTRACTOR TO MAINTAIN AREAS INTACT, ACCESSIBLE AND SAFE DURING ALL PHASES OF WORK.
- C. CONTRACTOR TO PATCH AND REPAIR EXISTING WALLS TO REMAIN IN A MANNER ACCEPTABLE AND REQUIRED FOR NEW FINISHES.
- D. CONTRACTOR TO PATCH AND REPAIR EXISTING WALLS TO REMAIN WHERE PME DEVICES AND/OR WALL MOUNTED ACCESSORIES HAVE BEEN REMOVED. PATCH SHALL BE IN A MANNER ACCEPTABLE AND REQUIRED FOR NEW FINISHES.
- E. CONTRACTOR TO PATCH AND REPAIR EXISTING WALLS TO REMAIN WHERE PME DEVICES AND/OR WALL MOUNTED ACCESSORIES ARE INSTALLED. PATCH SHALL BE IN A MANNER ACCEPTABLE AND REQUIRED FOR NEW FINISHES.
- F. INSTALL SOLID WOOD BLOCKING IN WALLS BEHIND WALL MOUNTED ITEMS INCLUDING CASEWORK, TOILET ACCESSORIES, WALL PROTECTION, ETC.
- G. CONTRACTOR TO PATCH AND LEVEL FLOOR WHERE SANITARY LINES HAVE BEEN REMOVED. SEE PLUMBING DRAWINGS.
- H. CONTRACTOR TO FIELD VERIFY REQUIRED JAMB THROAT.
- I. REFER TO DIMENSION PLAN AND INTERIOR ELEVATIONS FOR ADDITIONAL INFORMATION.

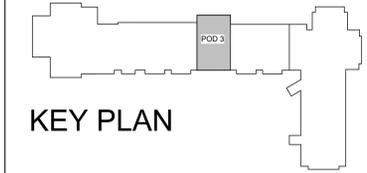

KEY PLAN

APP Architecture
creative focused design

615 Woodside Drive, Englewood, Ohio 45322
T 937.832.3696 F 937.832.3696
www.app-arch.com

STATE OF OHIO
ARCHITECT
TODD A. GINDLBERGER
LICENSE #12147
EXPIRES 12/31/2027

POD 3 INTERIOR RENOVATION
FAMILY HEALTH SERVICES OF
DARKE COUNTY


5735 MEEKER ROAD, GREENVILLE, OH 45331

ISSUE	
NO.	DESCRIPTION
1	03.16.2026 FOR BID & PERMIT
1	03.20.2026 ADDENDUM #1

DATE	3.16.26
JOB NO.	3853.04
DRAWN	RNL
CHECKED	MES/TAG
COPYRIGHT © 2026 - App Architecture, Inc.	
TITLE	REFERENCE PLAN

SHEET NO.
A1.2

3/27/2026 11:05:56 AM

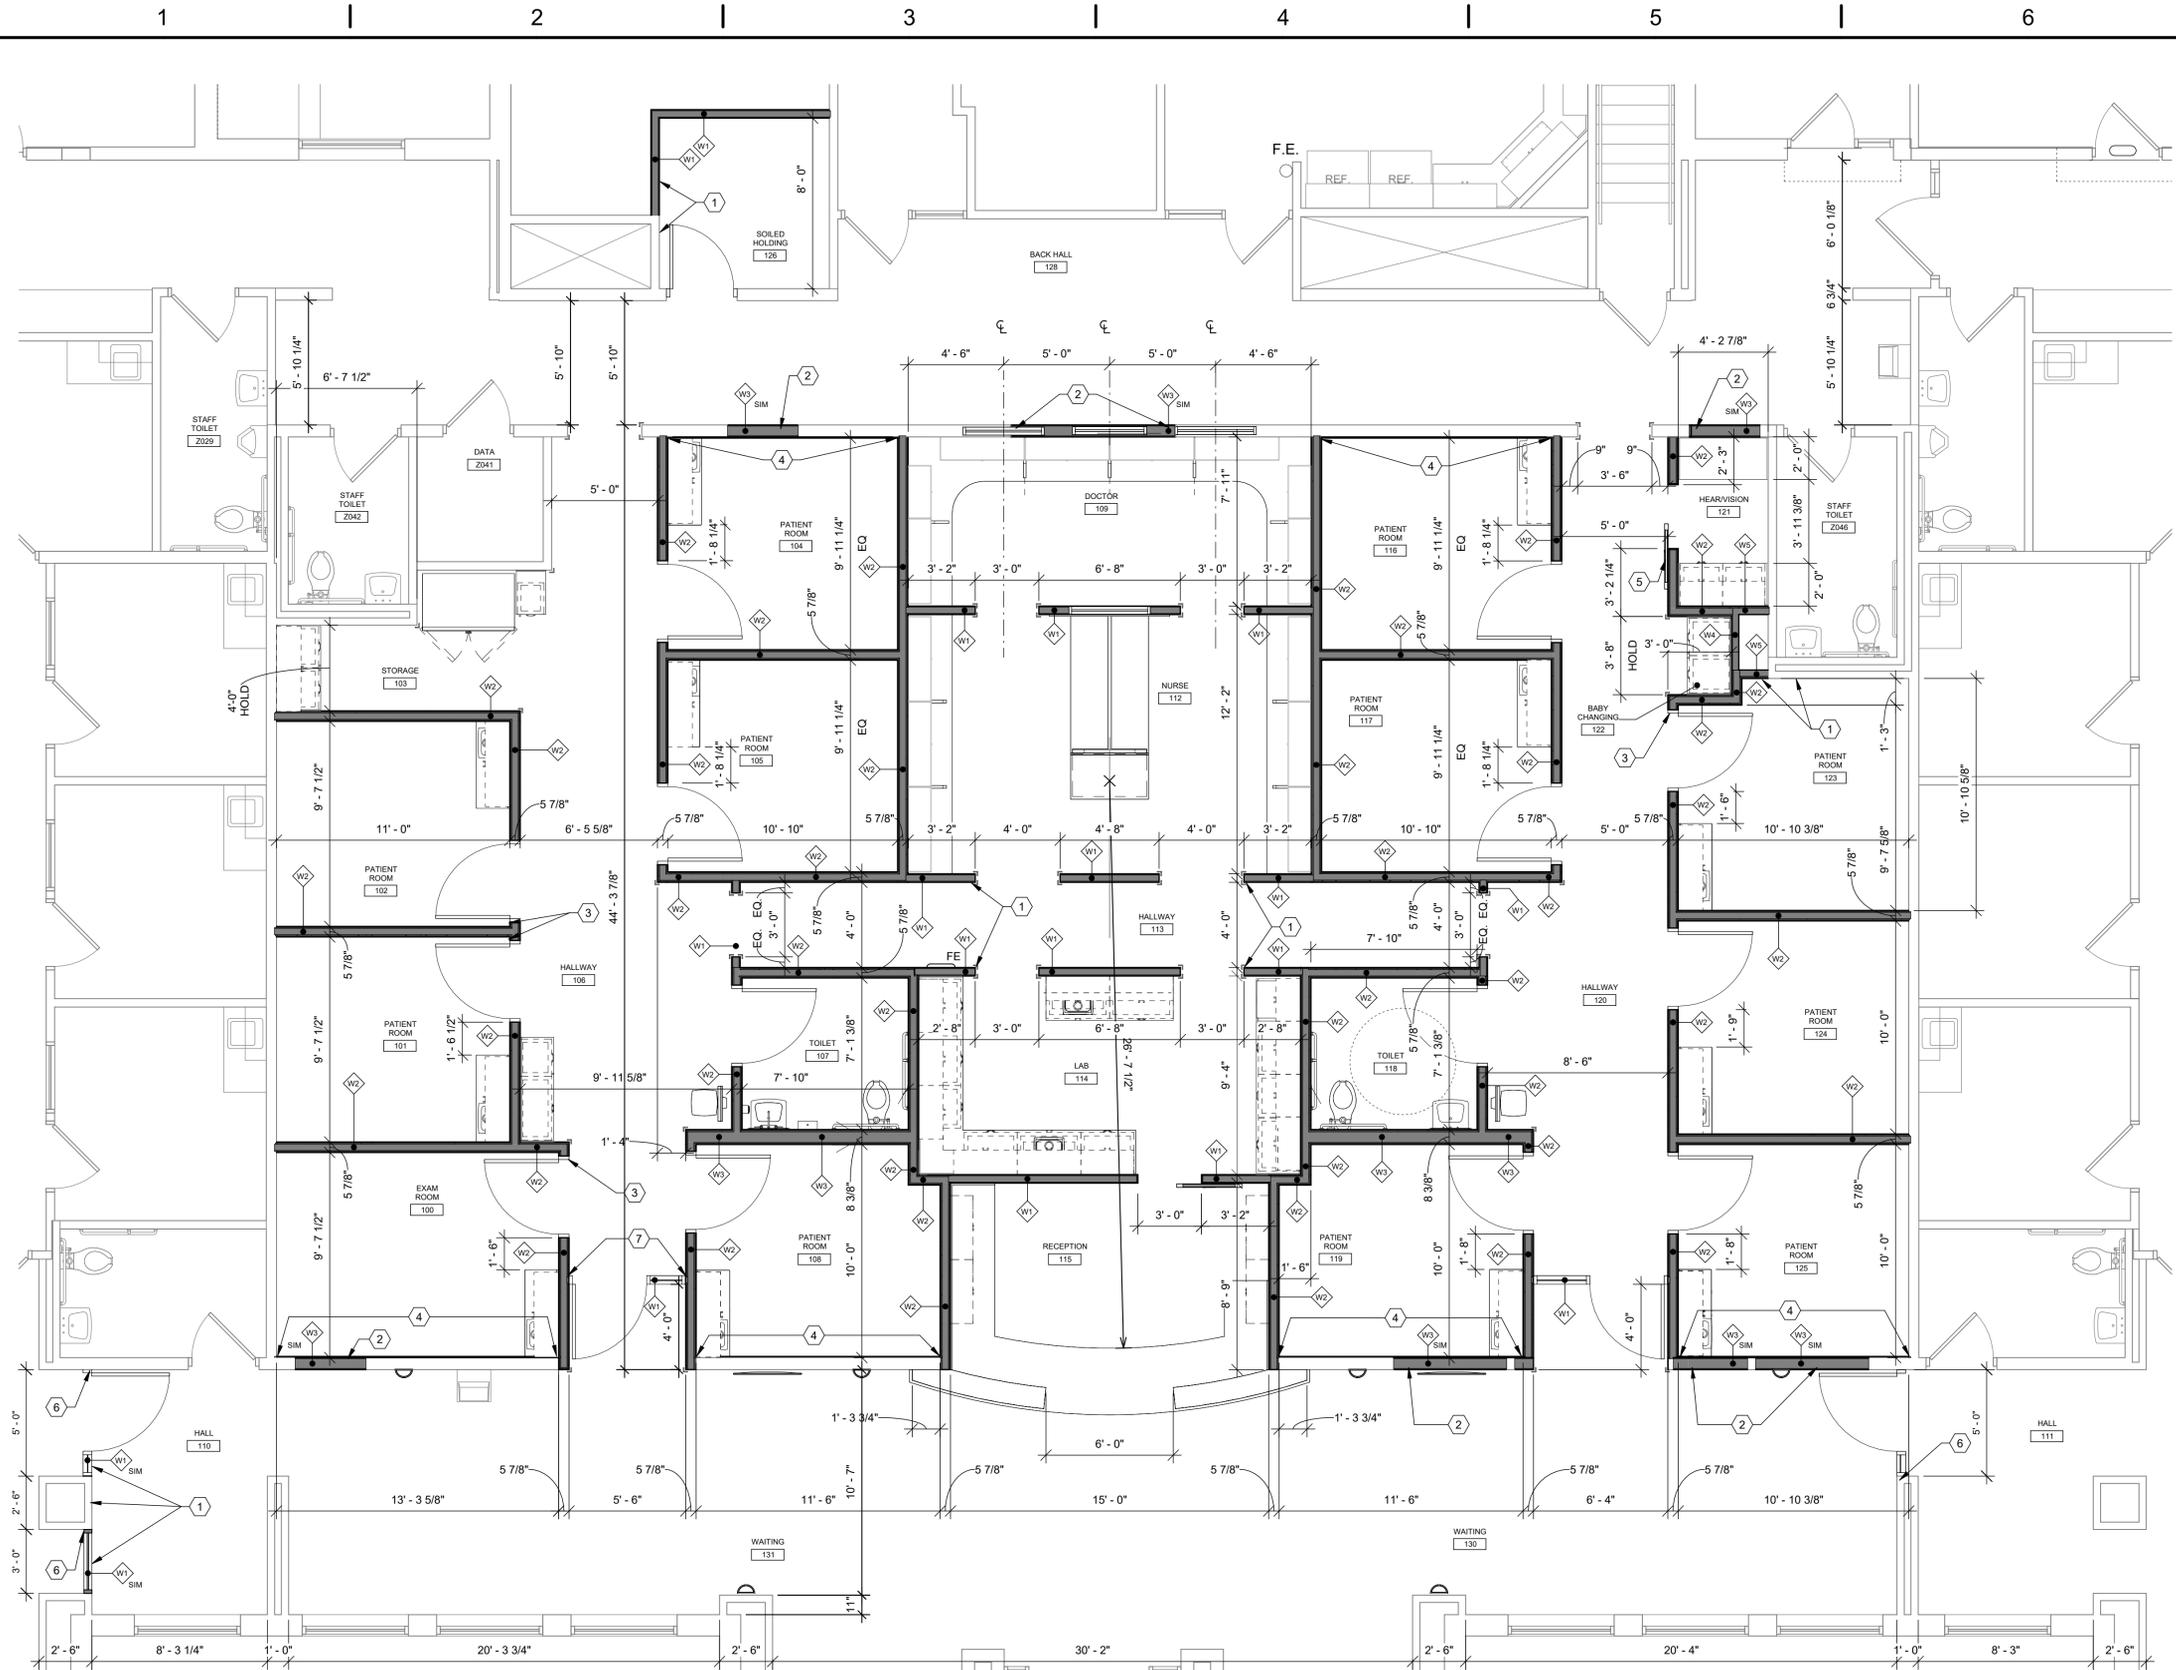


F1 NEW WORK DIMENSION PLAN
1/4" = 1'-0"

CONSTRUCTION NOTES


- (00) INDICATES CONSTRUCTION NOTE.
- 1 ALIGN
- 2 INFILL AT DOOR OPENING, MATCH EXISTING WALL CONSTRUCTION.
- 3 EDGE OF DOOR FRAME SPACED 0'-2" AWAY FROM CORNER.
- 4 ADD ONE ADDITIONAL LAYER OF 5/8" GYPSUM WALL BOARD TO EXISTING WALL FINISH ON PATIENT ROOM SIDE.
- 5 VERIFY DOOR SWINGS CLEAR OF 3'-0" OPENING INTO ROOM.
- 6 FIT EXISTING STOREFRONT INTO EXISTING OPENING. PROVIDE BLOCKING IN EXISTING WALL AS REQUIRED.
- 7 FRAME TIGHT TO WALL FACE.

GENERAL NOTES

- A. OUTER EDGE OF DOOR FRAMES SPACED 0'-4" AWAY FROM INSIDE CORNERS UNLESS OTHERWISE NOTED. SEE F59A0.3
- B. PROTECT ANY EXISTING TO REMAIN CONSTRUCTION FROM DAMAGE DURING NEW CONSTRUCTION WORK.
- C. OCCUPIED AREAS SHALL REMAIN INTACT, ACCESSIBLE, AND SAFE DURING ALL PHASES OF WORK.
- D. GO TO PATCH AND REPAIR EXISTING WALLS TO REMAIN WHERE PINE DEVICES AND/OR WALL MOUNTED ACCESSORIES HAVE BEEN REMOVED.
- E. INSTALL SOLID WOOD BLOCKING IN WALLS BEHIND WALL-MOUNTED ITEMS INCLUDING CASEWORK, RAILINGS, TOILET ACCESSORIES, ETC. SEE CHART FOR REQUIRED LOCATION OF FIRE RETARDANT TREATED WOOD.
- F. REFER TO REFERENCE PLAN FOR ROOM NAMES AND DOOR NUMBERS.
- G. WHERE NEW WALL CONSTRUCTION MEETS OR IS ADJACENT TO EXISTING WALL CONSTRUCTION, ALIGN FINISH SURFACES. FURR OR ADJUST FRAMING SIZE IF REQUIRED.
- H. WALL DIMENSIONS ARE FROM FINISH FACE TO FINISH FACE UNLESS NOTED OTHERWISE.
- I. THE STRUCTURAL DRAWINGS HEREIN REPRESENT THE FINISHED STRUCTURE. THE CONTRACTOR SHALL PROVIDE ALL TEMPORARY GUYING AND BRACING REQUIRED TO ERECT AND HOLD THE STRUCTURE IN PROPER ALIGNMENT UNTIL ALL STRUCTURAL WORK AND CONNECTIONS HAVE BEEN COMPLETED. THE INVESTIGATION, DESIGN, SAFETY, ADEQUACY AND INSPECTION OF ERECTION BRACING, SHORING, TEMPORARY SUPPORTS, ETC. IS THE SOLE RESPONSIBILITY OF THE CONTRACTOR.
- J. ALL NEW WALLS & INFILL TO BE WALL TYPE W1 U.N.O.
- K. WALL THICKNESSES ARE BASED ON WOOD STUDS. CONTRACTOR TO FIELD VERIFY STUD REQUIRED AT INFILL WALL LOCATIONS.

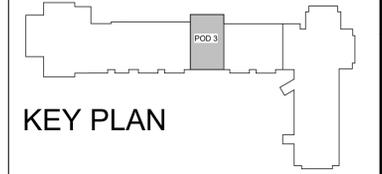


APP Architecture
creative focused design
615 Woodside Drive, Englewood, Ohio 45322
T 937.836.8898 F 937.832.3696
www.app-arch.com

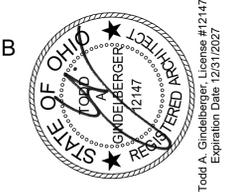

POD 3 INTERIOR RENOVATION
FAMILY HEALTH SERVICES OF
DARKE COUNTY
5735 MEEKER ROAD, GREENVILLE, OH 45331


ISSUE	
NO.	DESCRIPTION
03.16.2026	FOR BID & PERMIT

DATE	3.16.26
JOB NO.	3853.04
DRAWN	RNL
CHECKED	MES/TAG
COPYRIGHT © 2026 - App Architecture, Inc.	
TITLE	DIMENSION PLAN
SHEET NO.	A1.3

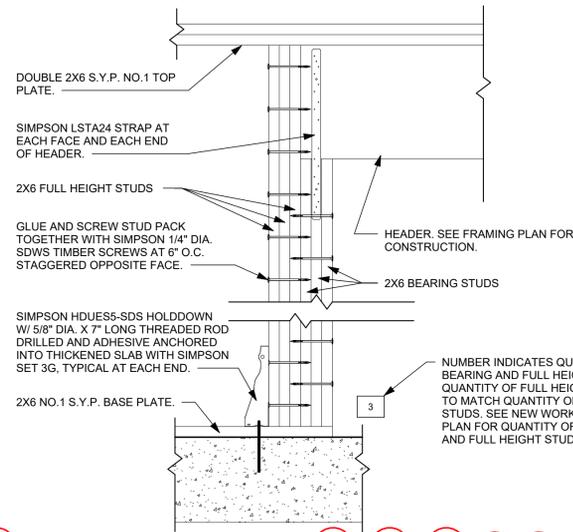

C2 HEADER ELEVATION
1" = 1'-0"

NOTE: LAMINATED VENEER LUMBER (LVL) SHALL HAVE THE FOLLOWING MINIMUM DESIGN VALUES: 2.0E-3000 (Fb = 3000 psi). ATTACH PLIES PER MANUFACTURER'S INSTALLATION INSTRUCTIONS.

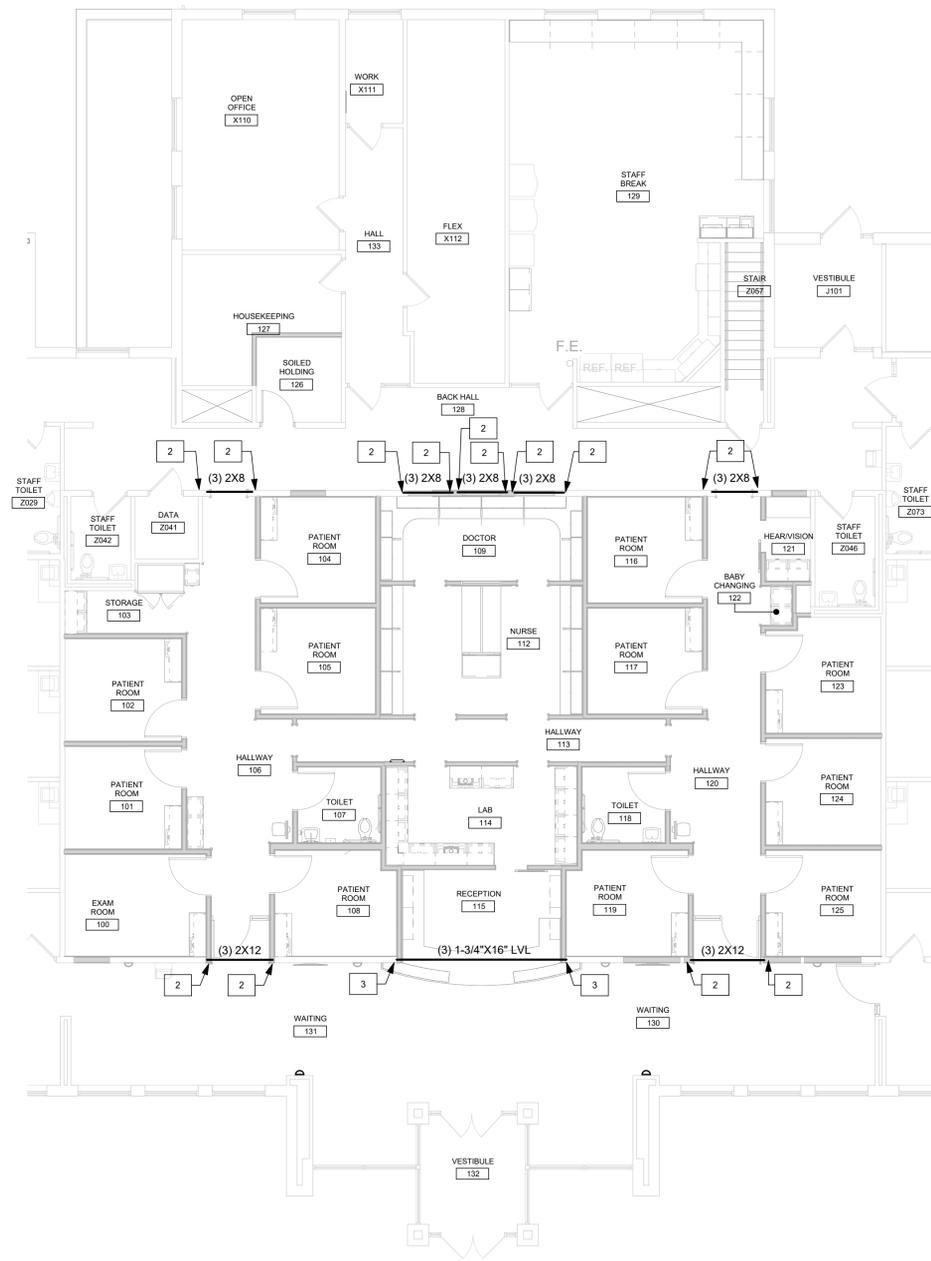


E4 NEW WORK FRAMING PLAN
1/8" = 1'-0"

FRAMING NOTES

0 NUMBER INDICATES QUANTITY OF BEARING AND FULL HEIGHT STUDS TO MATCH QUANTITY OF BEARING STUDS. SEE NEW WORK FRAMING PLAN FOR QUANTITY OF BEARING AND FULL HEIGHT STUDS.


GENERAL NOTES

- A. EDGE OF DOOR FRAMES SPACED 0'-4" AWAY FROM CORNERS UNLESS OTHERWISE NOTED.
- B. PROTECT ANY EXISTING TO REMAIN CONSTRUCTION FROM DAMAGE DURING NEW CONSTRUCTION WORK.
- C. OCCUPIED AREAS SHALL REMAIN INTACT, ACCESSIBLE, AND SAFE DURING ALL PHASES OF WORK.
- D. GC TO PATCH AND REPAIR EXISTING WALLS TO REMAIN WHERE PME DEVICES AND/OR WALL MOUNTED ACCESSORIES HAVE BEEN REMOVED.
- E. INSTALL SOLID WOOD BLOCKING IN WALLS BEHIND WALL-MOUNTED ITEMS INCLUDING CASEWORK, RAILINGS, TOILET ACCESSORIES, ETC. SEE CHART FOR REQUIRED LOCATION OF FIRE RETARDANT TREATED WOOD.
- F. REFER TO REFERENCE PLAN FOR ROOM NAMES AND DOOR NUMBERS.
- G. WHERE NEW WALL CONSTRUCTION MEETS OR IS ADJACENT TO EXISTING WALL CONSTRUCTION, ALIGN FINISH SURFACES.
- H. WALL DIMENSIONS ARE FROM FINISH FACE TO FINISH FACE UNLESS NOTED OTHERWISE.
- I. THE STRUCTURAL DRAWINGS HEREIN REPRESENT THE FINISHED STRUCTURE. THE CONTRACTOR SHALL PROVIDE ALL TEMPORARY GUYING AND BRACING REQUIRED TO ERECT AND HOLD THE STRUCTURE IN PROPER ALIGNMENT UNTIL ALL STRUCTURAL WORK AND CONNECTIONS HAVE BEEN COMPLETED. THE INVESTIGATION, DESIGN, SAFETY, ADEQUACY AND INSPECTION OF ERECTION BRACING, SHORING, TEMPORARY SUPPORTS, ETC. IS THE SOLE RESPONSIBILITY OF THE CONTRACTOR.

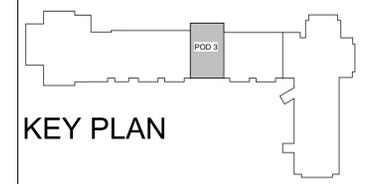

APP Architecture
creative focused design

615 Woodside Drive, Englewood, Ohio 45322
T 937.836.8898 F 937.832.3696
www.app-arch.com

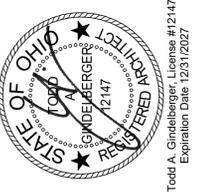



POD 3 INTERIOR RENOVATION
FAMILY HEALTH SERVICES OF DARKE COUNTY

5735 MEEKER ROAD, GREENVILLE, OH 45331

ISSUE		
NO.	DATE	DESCRIPTION
1	03.16.2026	FOR BID & PERMIT
	03.20.2026	ADDENDUM #1



DATE 3.16.26
JOB NO. 3853.04
DRAWN RNL
CHECKED MES/TAG
COPYRIGHT © 2026 - App Architecture, Inc.
TITLE **STRUCTURAL PLAN AND DETAILS**

SHEET NO. **A1.4**

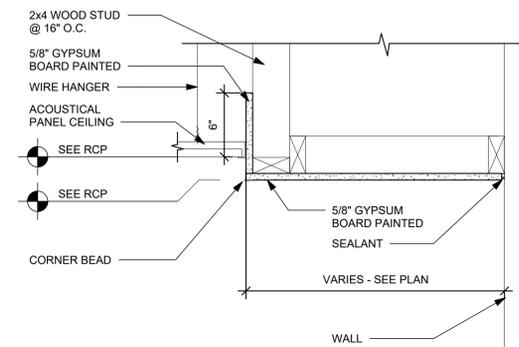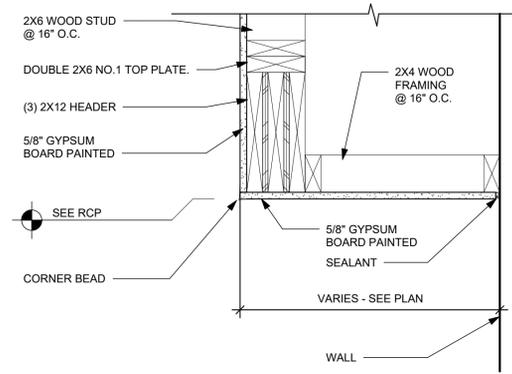


B1 SOFFIT @ WALL
1 1/2" = 1'-0"

B2 SOFFIT @ WALL - WAITING
1 1/2" = 1'-0"

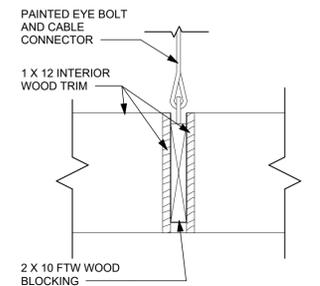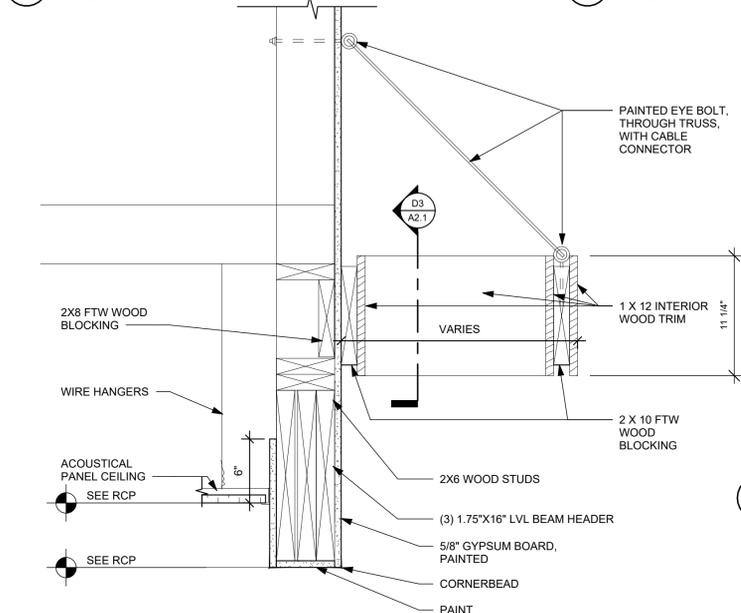

D1 BULKHEAD AND TRELLIS DETAIL
1 1/2" = 1'-0"


D3 TRELLIS SUPPORT DETAIL
1 1/2" = 1'-0"

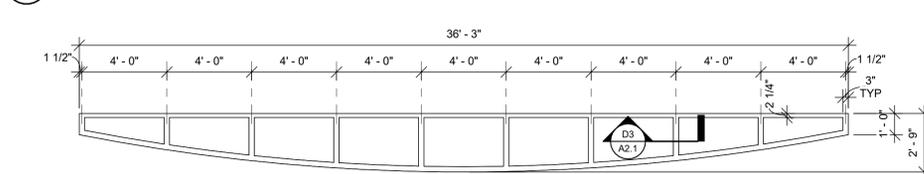


E1 TRELLIS PLAN
1/4" = 1'-0"

ALTERNATE 1:

PROVIDE AND INSTALL NEW ACP-2 TILES IN SHADED REGIONS. RETAIN CEILING GRID. CONTRACTOR RESPONSIBLE TO FIELD VERIFY LENGTH AND WIDTH OF HALLWAY AND ALL SOFFITS AND BULKHEADS TO REMAIN.

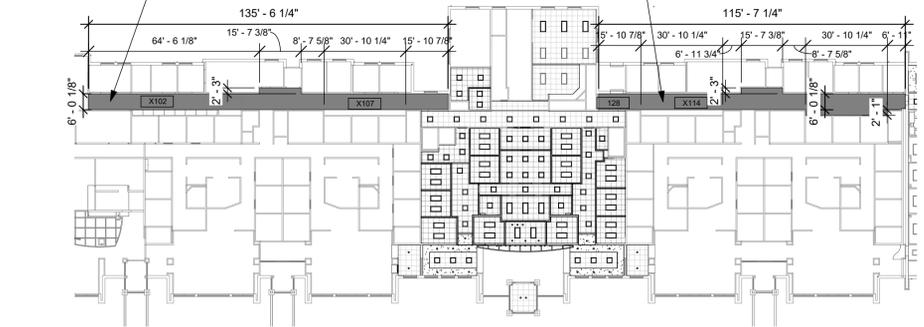

F1 NEW WORK REFLECTED CEILING FLOOR PLAN - ALTERNATE #1
1/32" = 1'-0"

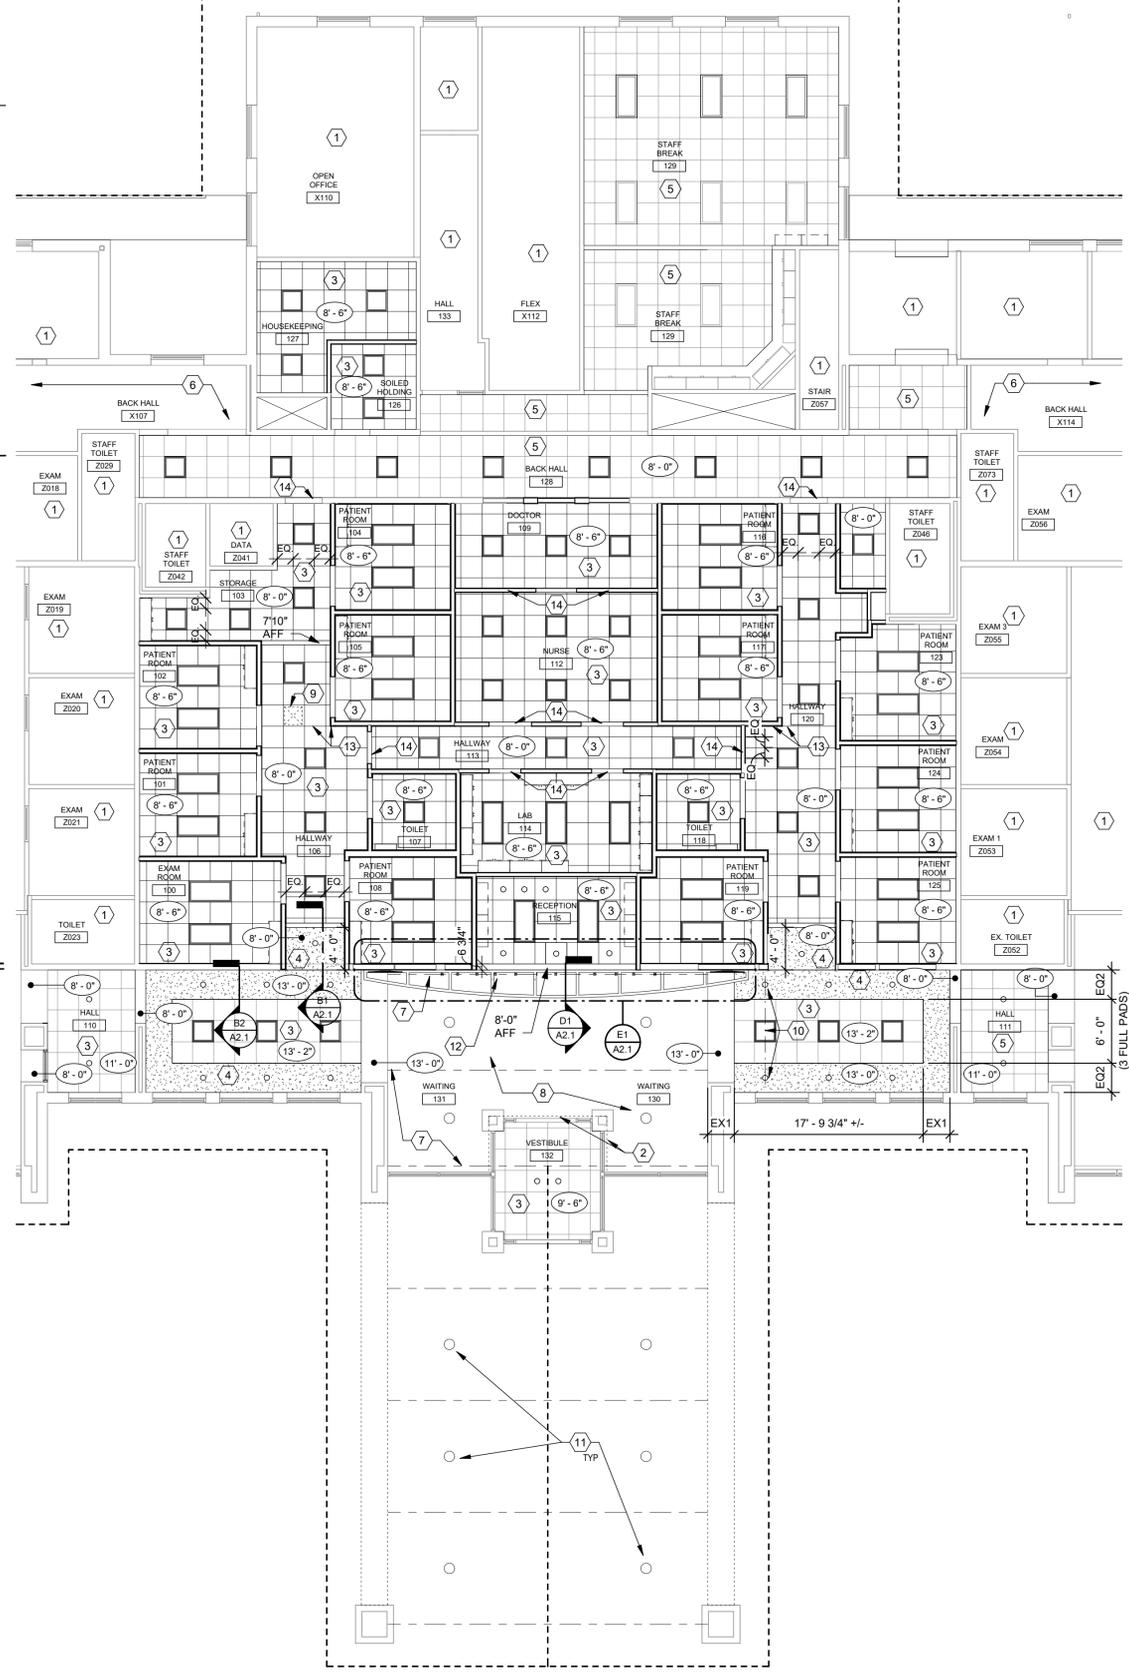


E4 NEW WORK REFLECTED CEILING FLOOR PLAN AREA C
1/8" = 1'-0"

CONSTRUCTION NOTES

- INDICATES CONSTRUCTION NOTE.
- 1 NO WORK IN THIS AREA
- 2 LINE OF LOW VESTIBULE LID WITH WOOD TRIM
- 3 NEW APC GRID AND ACOUSTIC TILE IN THIS ROOM.
- 4 NEW DRYWALL CEILING SOFFIT.
- 5 EXISTING ACCOUSTICAL TILE CEILING, REPLACE CEILING TILES.
- 6 SEE ALTERNATE #1, SHEET A2.1.
- 7 LINE OF OPEN WOOD TRUSS ABOVE
- 8 WOOD PLANK SLOPED CEILING ABOVE
- 9 INSTALL SALVAGED ATTIC ACCESS PANEL THIS LOCATION. COORDINATE LOCATION WITH EXISTING ATTIC DUCTWORK HEAD CLEARANCE AND CEILING GRID LAYOUT LEAVE 4'x4' AREA OF LOOSE GRID MEMBERS BELOW TO ACCESS.
- 10 ALIGN CAN LIGHTS WITH 2X2 LAY-IN CEILING LIGHTS (TYP)
- 11 SEE ELECTRICAL DRAWINGS FOR EXTERIOR LIGHT WORK AT PORTE COCHERE
- 12 INSTALL TRACK LIGHTING TIGHT TO UPPER SIDE OF TRELLIS. ORIENT HEADS UP TO LIGHT THE PLANK CEILING. SEE ELECTRICAL DRAWINGS FOR ADDITIONAL INFORMATION
- 13 ALIGN GRID TO CORNER.
- 14 DRYWALL BULKHEAD @ 7'-0" A.F.F.


GENERAL NOTES

- A. CENTER CEILINGS IN SPACE UNLESS NOTED OTHERWISE.
- B. SEE MECHANICAL, ELECTRICAL, PLUMBING DRAWINGS FOR DEVICE LOCATIONS AND TYPES (SOME DEVICES MAY NOT BE SHOWN IN THIS CEILING PLAN)
- C. GENERAL CONTRACTOR TO REDISTRIBUTE ATTIC INSULATION (BOTH DISTURBED BY PROJECT AND PRIOR) TO ASSURE EVEN COVERAGE.
- D. NEW CEILING @ 8'-0" U.O.
- E. ALL NEW SUSPENDED CEILING AREAS SHALL BE APC-1 U.O.
- F. SEE DEMOLITION PLANS FOR REMOVED CEILING OR PARTIALLY REMOVED CEILING LOCATIONS.
- G. CENTER DEVICES AND SPRINKLER HEADS IN PADS U.O.
- H. SEE FP DRAWING FOR NEW AND ADDED SPRINKLER LOCATIONS.
- I. ALL CONTINUOUS SOFFIT VENTS TO HAVE CONTINUOUS INSULATION.
- J. BOTTOM OF ALL DRYWALL BULKHEADS 7'-0" U.O.

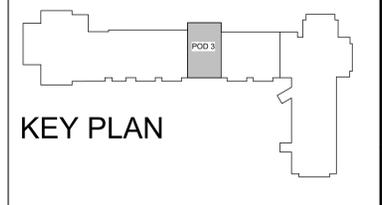

KEY PLAN

APP Architecture
creative focused design
615 Woodside Drive, Englewood, Ohio 45322
T 937.836.8898 F 937.832.3696
www.app-arch.com

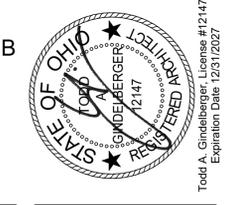


POD 3 INTERIOR RENOVATION
FAMILY HEALTH SERVICES OF DARKE COUNTY
5735 MEEKER ROAD, GREENVILLE, OH 45331

ISSUE		
NO.	DATE	DESCRIPTION
03.16.2026	FOR BID & PERMIT	

DATE	3.16.26
JOB NO.	3853.04
DRAWN	RNL
CHECKED	MES/TAG
COPYRIGHT © 2026 - App Architecture, Inc.	
TITLE NEW WORK REFLECTED CEILING PLAN	
SHEET NO.	
A2.1	

CONSTRUCTION NOTES

- 00 INDICATES CONSTRUCTION NOTE.
- 1 BASE, SEE INTERIOR FINISH SCHEDULE.
- 2 MIDMARK SYNTHESIS, 18 GA. BASE CABINET (FLAX), PROVIDED AND INSTALLED BY OWNER'S CONTRACTOR; GENERAL CONTRACTOR TO PROVIDE BLOCKING IN WALL.
- 3 SOLID SURFACE MIDMARK COUNTERTOP (ANTARCTICA), PROVIDED AND INSTALLED BY OWNER'S CONTRACTOR.
- 4 MIDMARK SYNTHESIS, 18 GA. SCRIBE (FLAX), PROVIDED AND INSTALLED BY OWNER'S CONTRACTOR; GENERAL CONTRACTOR TO PROVIDE BLOCKING IN WALL.
- 5 MIDMARK SYNTHESIS, 18 GA. WALL CABINET (FLAX), PROVIDED AND INSTALLED BY OWNER'S CONTRACTOR; GENERAL CONTRACTOR TO PROVIDE BLOCKING IN WALL.
- 6 4'-0" HIGH CORNER GUARD SNAP ON WITH METAL RETAINER.
- 7 SPECIMEN PASS BOX.
- 8 TOILET PAPER HOLDER, SALVAGED/CONTRACTOR INSTALLED OR OFCI.
- 9 GRAB BARS - SEE ALSO A0.1.
- 10 STAINLESS STEEL FRAMED MIRROR.
- 11 SOAP DISPENSER OFCI.
- 12 PAPER TOWEL HOLDER CFCL.
- 13 PLUMBING FIXTURE. SEE PLUMBING DRAWINGS.
- 15 EQUIPMENT - BY OWNER
- 16 SOLID SURFACE COUNTERTOP AND BACKSPLASH (SSM-1) REFER TO INTERIOR ELEVATION FOR LOCATION AND CASEWORK SECTIONS SHEET A8.1.
- 17 PLASTIC LAMINATE ACCESS PANEL - PL-1
- 18 TACKBOARD WITH 2" WOOD STAINED FRAME, SEE SPECIFICATIONS.
- 19 SOLID SURFACE TRANSACTION TOP (SS-1)
- 20 VINYL DECAL OF FAMILY HEALTH LOGO
- 21 PLASTIC LAMINATE BASE / WALL CABINETS SEE CASEWORK SECTIONS SHEET A8.1
- 22 METAL BRACKETS, PROVIDE BLOCKING IN WALL, SPACED 4'-0" o.c. (MAX)
- 23 PLASTIC LAMINATE MIDMARK BASE CABINET - 18" DEEP (FLAX), PROVIDED AND INSTALLED BY OWNER'S CONTRACTOR; GENERAL CONTRACTOR TO PROVIDE BLOCKING IN WALL.
- 24 SOLID SURFACE COUNTERTOP - 19" DEEP (SS-1).
- 25 OWNER PROVIDED, OWNER'S CONTRACTOR INSTALLED: FLIPPER DOOR CABINET, WALL HUNG, GENERAL CONTRACTOR TO PROVIDE BLOCKING IN WALL.
- 26 WALL SCONCE, (TOTAL OF 6) SEE ELECTRICAL DRAWINGS
- 27 TRELLIS.
- 28 PLASTIC LAMINATE SUPPORT END WALL, FINISH ALL EXPOSED SIDES
- 29 SALVAGED REINSTALLED BORROWED LITE WINDOW, PAINT HOLLOW METAL FRAME
- 30 DESKTOP DIVIDER, SEE DETAILS
- 31 6" ROUND STAINLESS STEEL GROMMET OPENING, CENTERED OVER BASE TRASH BIN CABINET.
- 32 WALL PROTECTION
- 33 OWNER PROVIDED, OWNER'S CONTRACTOR INSTALLED: TACK PANEL, WALL HUNG, GENERAL CONTRACTOR TO PROVIDE BLOCKING IN WALL.
- 34 TACKBOARD BY OWNER'S FURNITURE SUIPLIER, GC TO PROVIDE BLOCKING
- 36 EXISTING DRINKING FOUNTAIN TO REMAIN
- 37 SOLID SURFACE WATERFALL COUNTERTOP WITH WALL SPLASH (1 1/2" & 4" EXPOSED EDGES) (SSM-1) REFER TO INTERIOR ELEVATION FOR LOCATION AND CASEWORK SECTIONS SHEET A8.1.

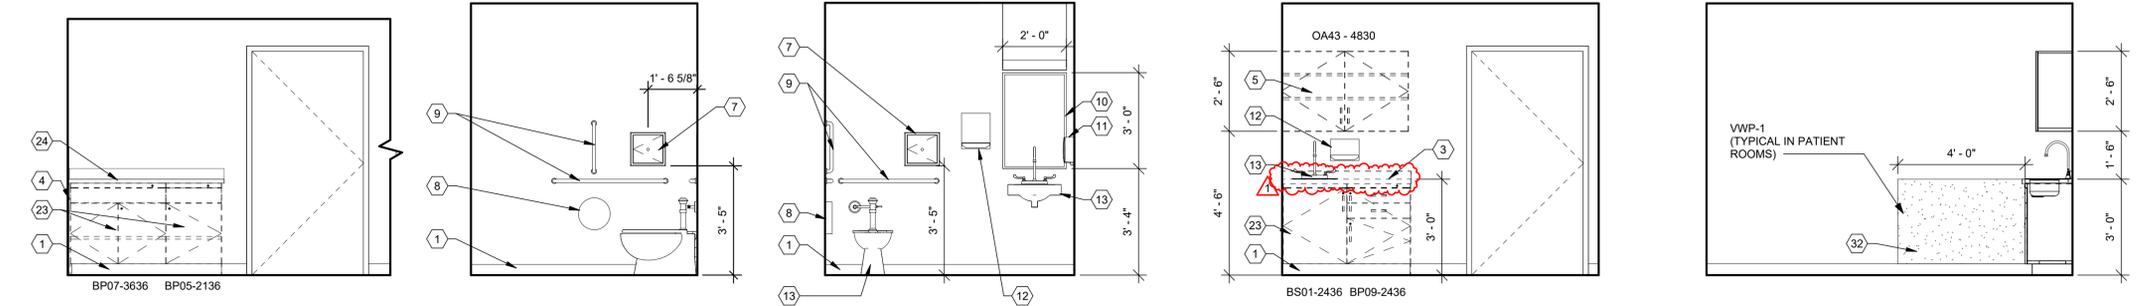


B1 106 HALLWAY, ELEV 1
3/8" = 1'-0"

B2 107 TOILET, ELEV 1
3/8" = 1'-0" NOTE: 118 TOILET SIMILAR

B3 107 TOILET, ELEV 2
3/8" = 1'-0" NOTE: 118 TOILET SIMILAR. SPECIMEN PASS THRU BOX SHOWN IN THIS ELEVATION ONLY TO BE INSTALLED IN 107 TOILET.

B4 TYP PATIENT ROOM WET WALL
3/8" = 1'-0" NOTE: TYP PATIENT ROOM ELEVATION APPLIES TO ALL PATIENT/EXAM/PROCEDURE ROOMS: 100, 101, 102, 104, 105, 106, 116, 117, 119, 123, 124, 125

B5 TYP PATIENT ROOM SIDE WALL
3/8" = 1'-0" NOTE: TYP PATIENT ROOM ELEVATION APPLIES TO ALL PATIENT/EXAM/PROCEDURE ROOMS: 100, 101, 102, 104, 105, 106, 116, 117, 119, 123, 124, 125

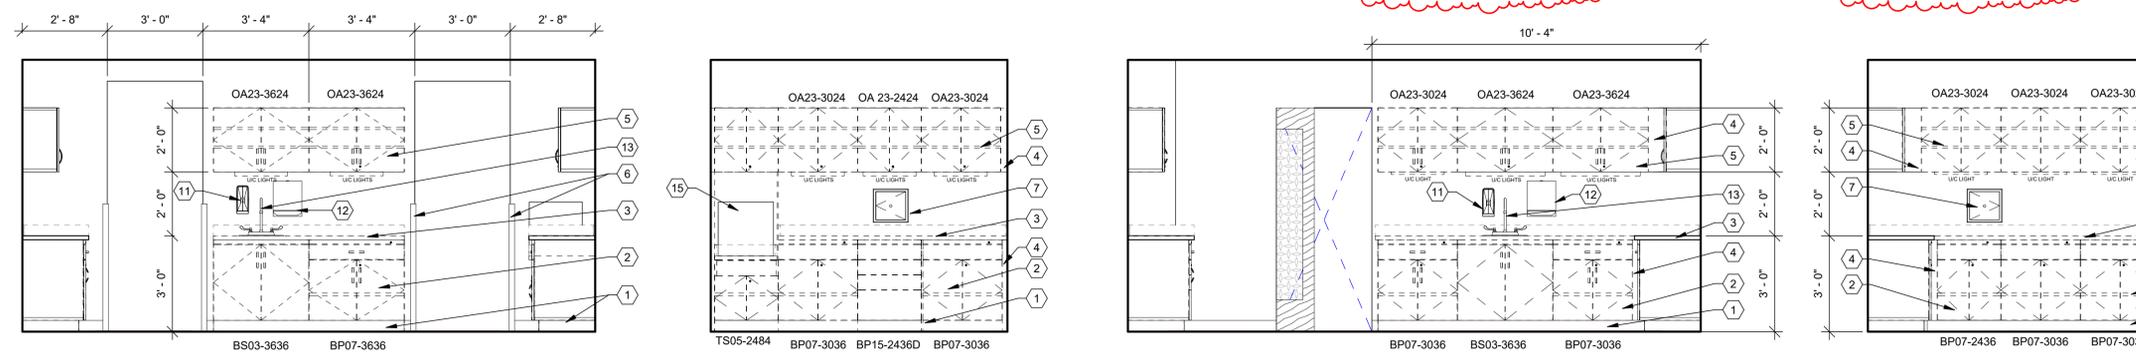


C1 114 LAB, ELEV 1
3/8" = 1'-0"

C2 114 LAB, ELEV 2
3/8" = 1'-0"

C4 114 LAB, ELEV 3
3/8" = 1'-0"

C5 114 LAB, ELEV 4
3/8" = 1'-0"

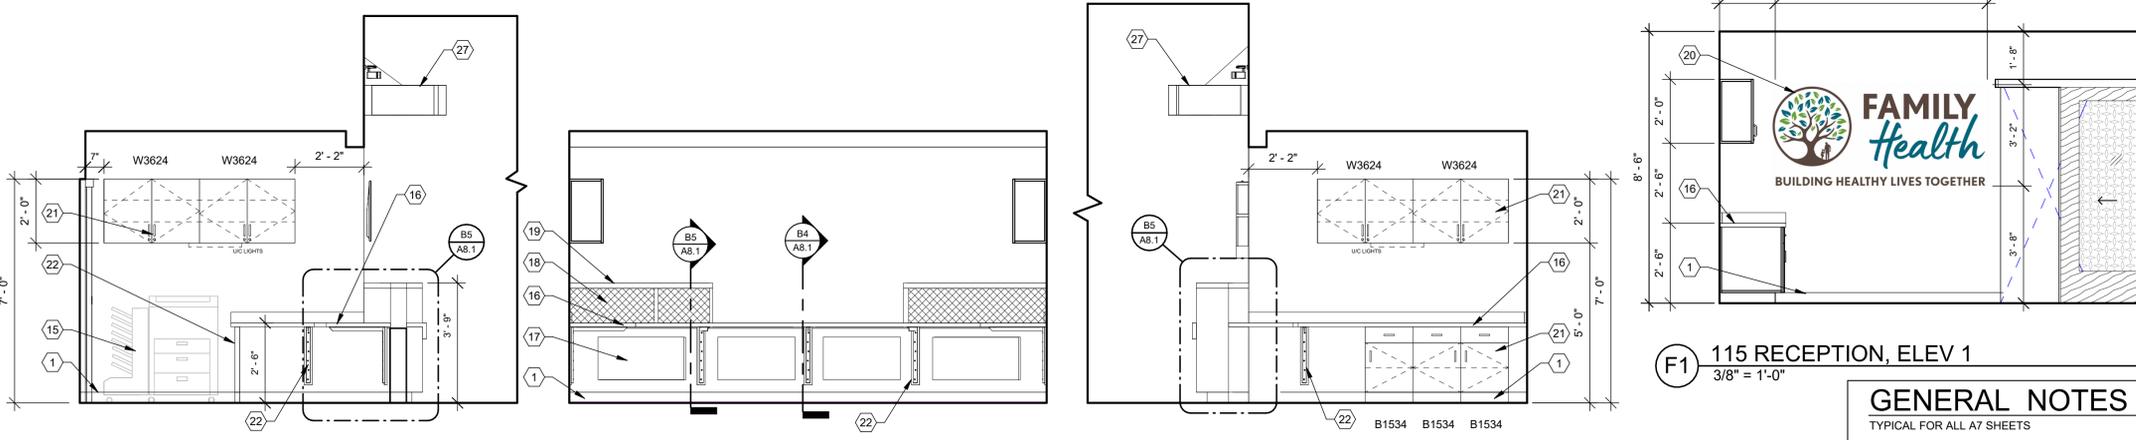

D1 115 RECEPTION, ELEV 2
3/8" = 1'-0"

D2 115 RECEPTION, ELEV 3
3/8" = 1'-0"


D3 115 RECEPTION, ELEV 4
3/8" = 1'-0"

D4 115 RECEPTION, ELEV 4
3/8" = 1'-0"

F1 115 RECEPTION, ELEV 1
3/8" = 1'-0"

GENERAL NOTES

- TYPICAL FOR ALL A7 SHEETS
- A. EXAMPLE OF CASEWORK DIMENSIONS (2436) INDICATES 24" WIDTH X 36" HEIGHT. FOR DEPTH REFER TO TYPICAL CASEWORK DETAILS U.N.O.
 - B. OWNER'S CONTRACTOR (MIDMARK) WILL PROVIDE AND INSTALL MIDMARK CABINETS AND COUNTERTOPS SEE CASEWORK TYPES PREFIX FOR IDENTIFICATION. GENERAL CONTRACTOR TO CUT SINK OPENINGS FOR NEW PLUMBING FIXTURES.
 - C. PROVIDE MIN. 3/4" PLASTIC LAMINATE SCRIBE AGAINST FINISHED WALLS AT BASE, WALL AND TALL CABINETS.
 - D. ALL BASE & WALL CABINET (PL-1), UNLESS NOTED OTHERWISE.
 - E. INSTALL SOLID WOOD (FIRE TREATED) (CONTRACTOR OPTION SHEET STEEL) BLOCKING IN WALLS BEHIND WALL-MOUNTED ITEMS INCLUDING CASEWORK, RAILINGS, TOILET ACCESSORIES, ETC.
 - F. REFER TO ELECTRICAL DRAWINGS FOR ELECTRICAL RECEPTACLE LOCATIONS.
 - G. SEE SHEET A8.1 FOR TYPICAL CABINET SECTIONS AND DETAILS.
 - H. ALL OUTSIDE CORNERS OF PLAM COUNTERTOPS SHALL PROJECT 1" PAST CABINET/SUPPORT AND SHALL HAVE 1/2" RADIUS CORNER EXCEPT AT REFRIGERATORS AND EQUIPMENT, WHERE SQUARE CORNERS AND 1/4" PROJECTION SHALL BE USED.
 - I. COORDINATE LOCATION OF GROMMETS FOR ALL WORK COUNTER TOPS WITH OWNER.
 - J. ALL COUNTERTOPS 25" DEEP U.N.O.
 - K. DESIGNATION (XX-X) REFER TO FINISHES. REFER TO SHEET A0.2 FOR FINISHES DESCRIPTION AND ABBREVIATIONS.
 - K. CASEWORK TYPES (PREFIX) ABBREVIATION
 - OA MIDMARK WALL CABINET
 - BP MIDMARK BASE CABINET
 - BS MIDMARK SINK BASE CABINET
 - TS MIDMARK TALL CABINET
 - B BASE CABINET WITH TOP DRAWER(S)
 - W WALL CABINET
 - WM WALL MICROWAVE CABINET
 - BT BASE TRASH CABINET
 - B2B BASE PRINTER CABINET
 - B1 BASE TRASH CABINET #2

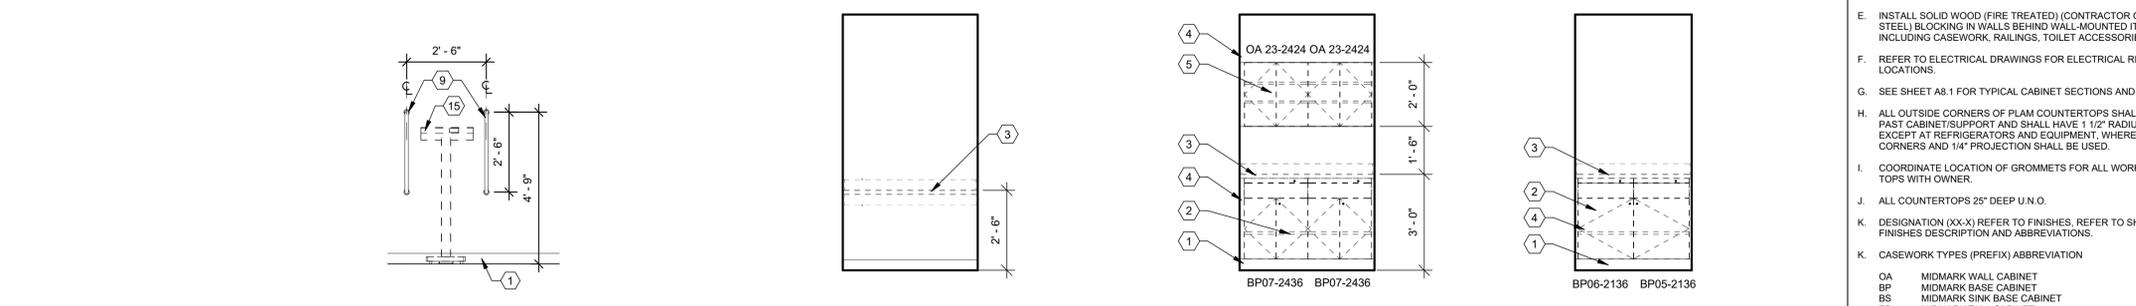

F2 TYP. SCALE GRAB BARS
3/8" = 1'-0"

F3 121 HEAR/VISION NORTH
3/8" = 1'-0"

F4 121 HEAR/VISION ELEV
3/8" = 1'-0"

F5 122 BABY CHANGING ELEV
3/8" = 1'-0"

APP Architecture
creative focused design


615 Woodside Drive, Englewood, Ohio 45322
T 937.836.8898 F 937.832.3696
www.app-arch.com

Todd A. Gindlberger, License #12147
Expiration Date 12/31/2027


POD 3 INTERIOR RENOVATION
FAMILY HEALTH SERVICES OF DARKE COUNTY
5735 MEEKER ROAD, GREENVILLE, OH 45331

ISSUE		
NO.	DATE	DESCRIPTION
1	03.16.2026	FOR BID & PERMIT
1	03.20.2026	ADDENDUM #1


DATE	3.16.26
JOB NO.	3853.04
DRAWN	RNL
CHECKED	MES/TAG
COPYRIGHT © 2026 - App Architecture, Inc.	
TITLE INTERIOR ELEVATIONS	
SHEET NO. A7.1	

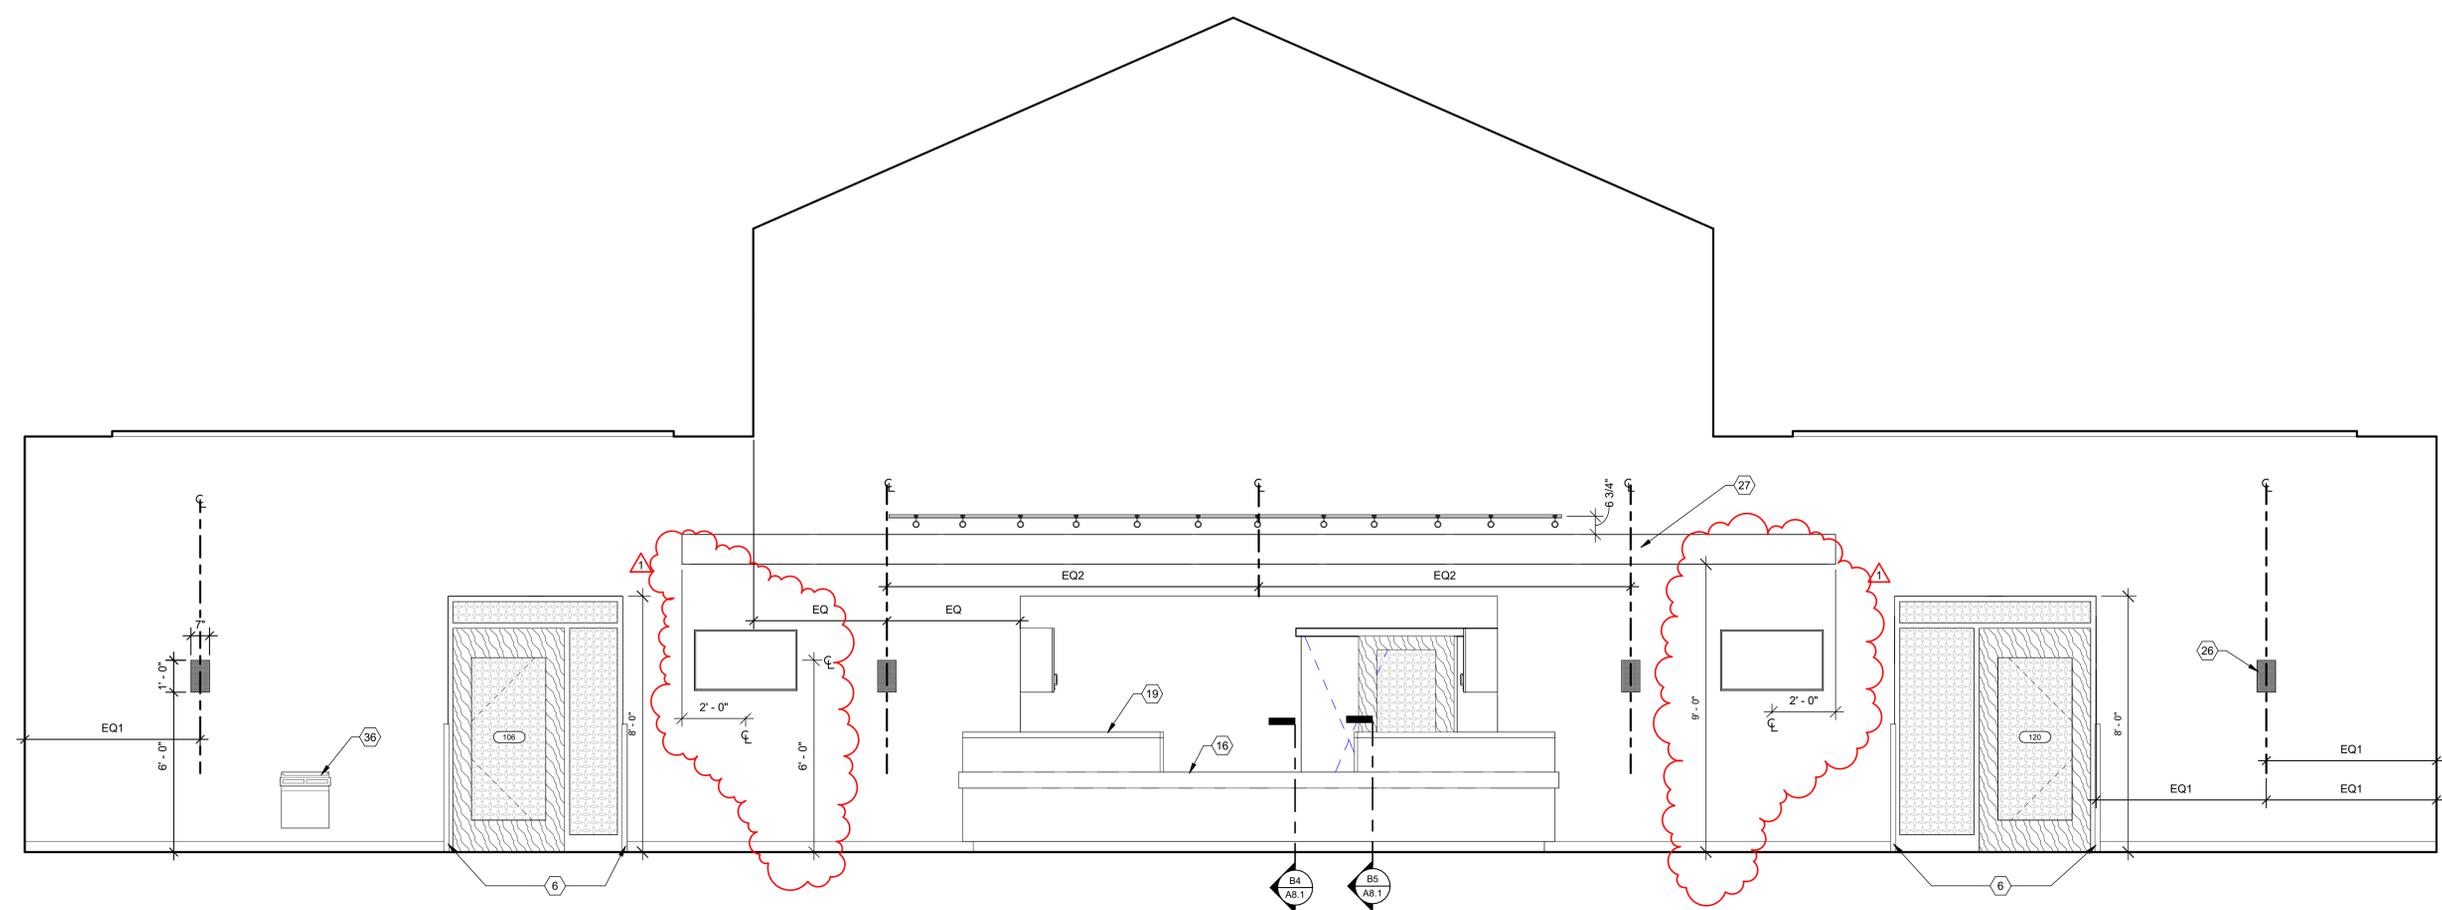

D1 115 RECEPTION, ELEV 5
3/8" = 1'-0"

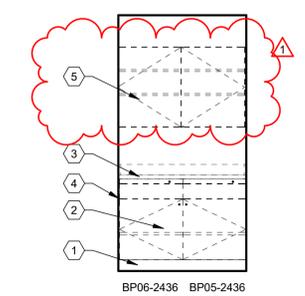

E2 103 STORAGE, ELEV 1
3/8" = 1'-0"

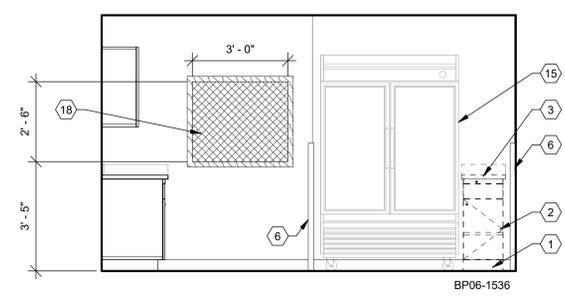

E3 103 STORAGE, ELEV 2
3/8" = 1'-0"

CONSTRUCTION NOTES

- 00 INDICATES CONSTRUCTION NOTE.
- BASE. SEE INTERIOR FINISH SCHEDULE.
 - MIDMARK SYNTHESIS, 18 GA. BASE CABINET (FLAX). PROVIDED AND INSTALLED BY OWNER'S CONTRACTOR; GENERAL CONTRACTOR TO PROVIDE BLOCKING IN WALL.
 - SOLID SURFACE MIDMARK COUNTERTOP (ANTARCTICA). PROVIDED AND INSTALLED BY OWNER'S CONTRACTOR
 - MIDMARK SYNTHESIS, 18 GA. SCRIBE (FLAX). PROVIDED AND INSTALLED BY OWNER'S CONTRACTOR; GENERAL CONTRACTOR TO PROVIDE BLOCKING IN WALL.
 - MIDMARK SYNTHESIS, 18 GA. WALL CABINET (FLAX). PROVIDED AND INSTALLED BY OWNER'S CONTRACTOR; GENERAL CONTRACTOR TO PROVIDE BLOCKING IN WALL.
 - 4'-0" HIGH CORNER GUARD SNAP ON WITH METAL RETAINER.
 - SPECIMEN PASS BOX.
 - TOILET PAPER HOLDER. SALVAGED/CONTRACTOR INSTALLED OR OFCI.
 - GRAB BARS - SEE ALSO A0.1.
 - STAINLESS STEEL FRAMED MIRROR.
 - SOAP DISPENSER OFCI.
 - PAPER TOWEL HOLDER OFCI.
 - PLUMBING FIXTURE. SEE PLUMBING DRAWINGS.
 - EQUIPMENT - BY OWNER
 - SOLID SURFACE COUNTERTOP AND BACKSPLASH (SSM-1). REFER TO INTERIOR ELEVATION FOR LOCATION AND CASEWORK SECTIONS SHEET A8.1.
 - PLASTIC LAMINATE ACCESS PANEL - PL-1
 - TACKBOARD WITH 2" WOOD STAINED FRAME. SEE SPECIFICATIONS.
 - SOLID SURFACE TRANSACTION TOP (SS-1)
 - VINYL DECAL OF FAMILY HEALTH LOGO
 - PLASTIC LAMINATE BASE / WALL CABINETS SEE CASEWORK SECTIONS SHEET A8.1
 - METAL BRACKETS. PROVIDE BLOCKING IN WALL. SPACED 4'-0" o.c. (MAX)
 - PLASTIC LAMINATE MIDMARK BASE CABINET - 18" DEEP (FLAX). PROVIDED AND INSTALLED BY OWNER'S CONTRACTOR; GENERAL CONTRACTOR TO PROVIDE BLOCKING IN WALL.
 - SOLID SURFACE COUNTERTOP - 19" DEEP (SS-1).
 - OWNER PROVIDED. OWNER'S CONTRACTOR INSTALLED: FLIPPER DOOR CABINET. WALL HUNG. GENERAL CONTRACTOR TO PROVIDE BLOCKING IN WALL.
 - WALL SCONCE. (TOTAL OF 6) SEE ELECTRICAL DRAWINGS
 - TRELLIS.
 - PLASTIC LAMINATE SUPPORT END WALL, FINISH ALL EXPOSED SIDES
 - SALVAGED REINSTALLED BORROWED LITE WINDOW, PAINT HOLLOW METAL FRAME
 - DESKTOP DIVIDER. SEE DETAILS
 - 6" ROUND STAINLESS STEEL GROMMET OPENING. CENTERED OVER BASE TRASH BIN CABINET.
 - WALL PROTECTION
 - OWNER PROVIDED. OWNER'S CONTRACTOR INSTALLED: TACK PANEL, WALL HUNG. GENERAL CONTRACTOR TO PROVIDE BLOCKING IN WALL.
 - TACKBOARD BY OWNER'S FURNITURE SUPPLIER, GC TO PROVIDE BLOCKING.
 - EXISTING DRINKING FOUNTAIN TO REMAIN
 - SOLID SURFACE WATERFALL COUNTERTOP WITH WALL SPLASH (1 1/2" & 4" EXPOSED EDGES) (SSM-1). REFER TO INTERIOR ELEVATION FOR LOCATION AND CASEWORK SECTIONS SHEET A8.1.

GENERAL NOTES

- TYPICAL FOR ALL A7 SHEETS
- EXAMPLE OF CASEWORK DIMENSIONS (2436) INDICATES 24" WIDTH X 36" HEIGHT. FOR DEPTH REFER TO TYPICAL CASEWORK DETAILS U.N.O.
 - OWNER'S CONTRACTOR (MIDMARK) WILL PROVIDE AND INSTALL MIDMARK CABINETS AND COUNTERTOPS SEE CASEWORK TYPES PREFIX FOR IDENTIFICATION. GENERAL CONTRACTOR TO CUT SINK OPENINGS FOR NEW PLUMBING FIXTURES.
 - PROVIDE MIN. 3/4" PLASTIC LAMINATE SCRIBE AGAINST FINISHED WALLS AT BASE, WALL AND TALL CABINETS.
 - ALL BASE & WALL CABINET (PL-1). UNLESS NOTED OTHERWISE.
 - INSTALL SOLID WOOD (FIRE TREATED) (CONTRACTOR OPTION SHEET STEEL) BLOCKING IN WALLS BEHIND WALL-MOUNTED ITEMS INCLUDING CASEWORK, RAILINGS, TOILET ACCESSORIES, ETC.
 - REFER TO ELECTRICAL DRAWINGS FOR ELECTRICAL RECEPTACLE LOCATIONS.
 - SEE SHEET A8.1 FOR TYPICAL CABINET SECTIONS AND DETAILS.
 - ALL OUTSIDE CORNERS OF PLAM COUNTERTOPS SHALL PROJECT 1" PAST CABINET SUPPORT AND SHALL HAVE 1/2" RADIUS CORNER EXCEPT AT REFRIGERATORS AND EQUIPMENT, WHERE SQUARE CORNERS AND 1/4" PROJECTION SHALL BE USED.
 - COORDINATE LOCATION OF GROMMETS FOR ALL WORK COUNTER TOPS WITH OWNER.
 - ALL COUNTERTOPS 25" DEEP U.N.O.
 - DESIGNATION (XX-X) REFER TO FINISHES. REFER TO SHEET A0.2 FOR FINISHES DESCRIPTION AND ABBREVIATIONS.
 - CASEWORK TYPES (PREFIX) ABBREVIATION


OA	MIDMARK WALL CABINET
BP	MIDMARK BASE CABINET
BS	MIDMARK SINK BASE CABINET
TS	MIDMARK TALL CABINET
B	BASE CABINET WITH TOP DRAWER(S)
W	WALL CABINET
WM	WALL MICROWAVE CABINET
BT	BASE TRASH CABINET
B2B	BASE PRINTER CABINET
BT1	BASE TRASH CABINET #2

ISSUE	
NO.	DESCRIPTION
1	03.16.2026 FOR BID & PERMIT 03.20.2026 ADDENDUM #1


DATE	3.16.26
JOB NO.	3853.04
DRAWN	RNL
CHECKED	MES/TAG
COPYRIGHT © 2026 - App Architecture, Inc.	
TITLE INTERIOR ELEVATIONS	

SHEET NO.
A7.3


1 | 2 | 3 | 4 | 5 | 6 | 7

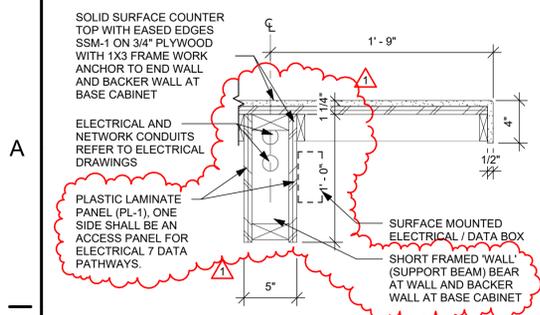


A1 DESK TOP SUPPORT DETAIL
1 1/2" = 1'-0"

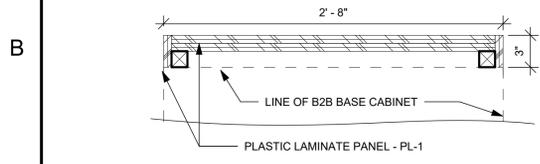


B1 DESK SUPPORT PLAN DETAIL
1 1/2" = 1'-0"

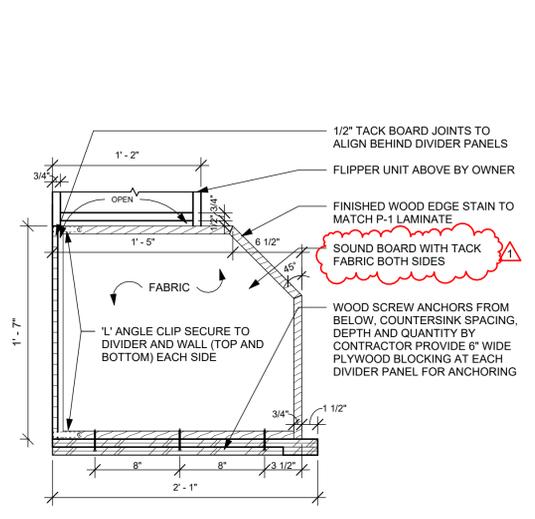


B2 DIVIDER PANEL DETAIL
1 1/2" = 1'-0"

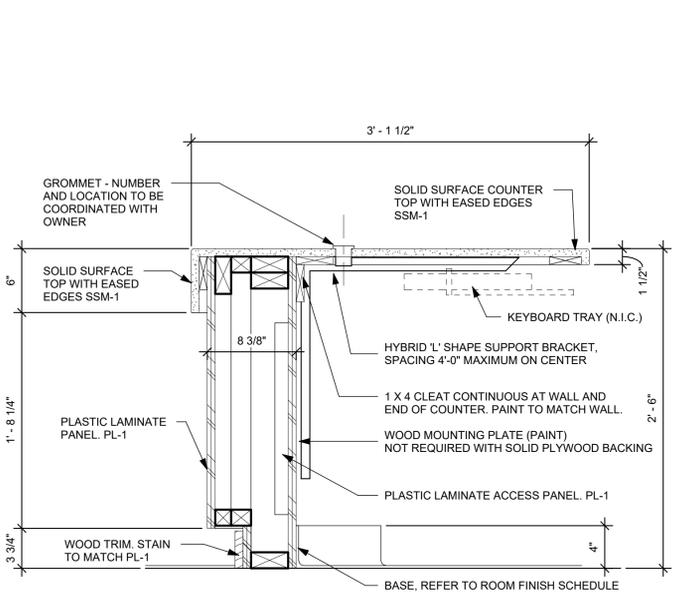


B4 RECEPTION DESK DETAIL
1 1/2" = 1'-0"

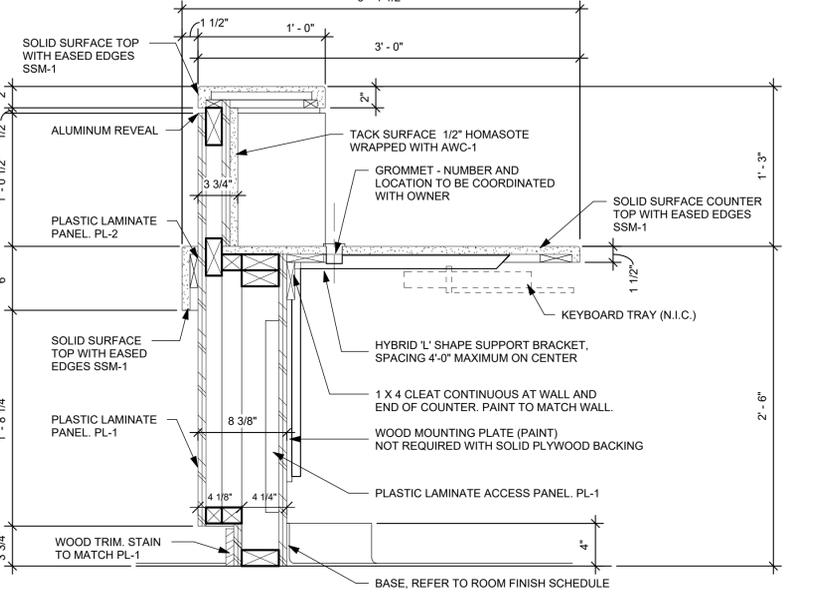


B5 RECEPTION DESK DETAIL
1 1/2" = 1'-0"

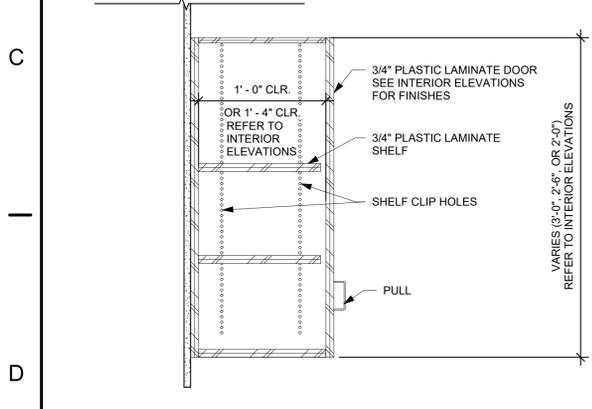


D1 TYP. "W" CABINET DETAIL
1 1/2" = 1'-0"

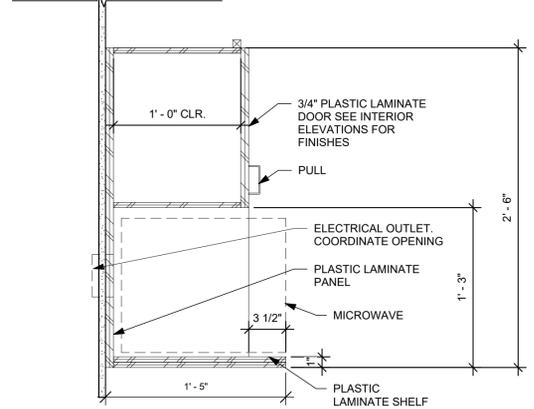


D2 TYP. "WM" CABINET DETAIL
1 1/2" = 1'-0"

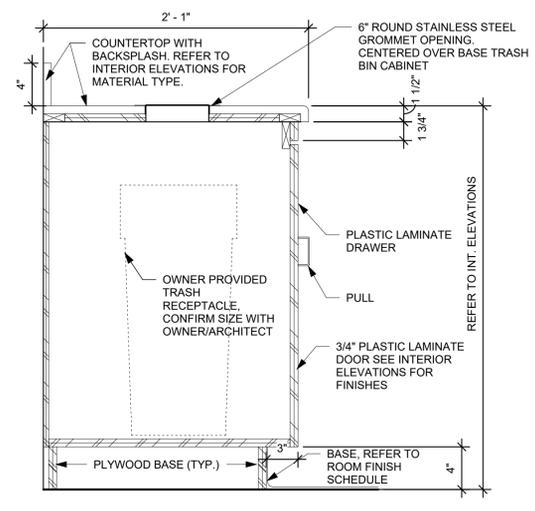


D4 TYP. "BT" CABINET DETAIL
1 1/2" = 1'-0"

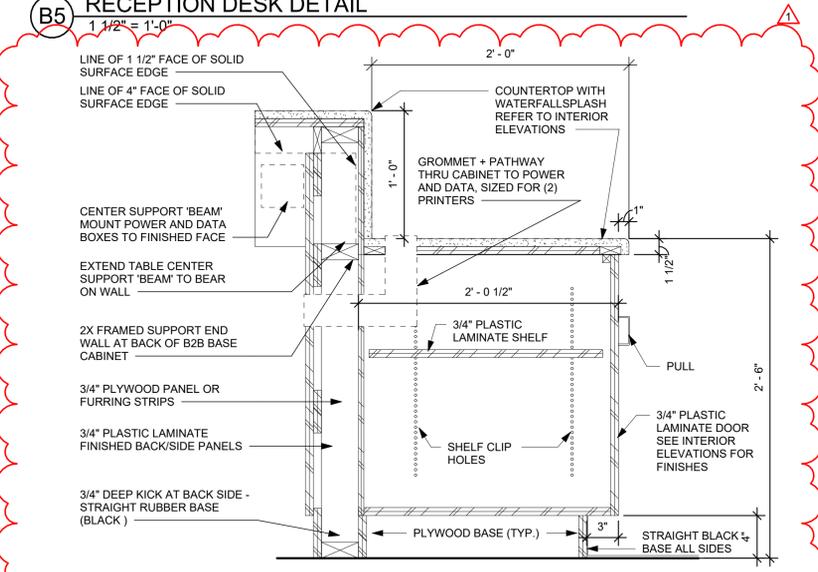


D6 TYP. "B1" CABINET DETAIL
1 1/2" = 1'-0"

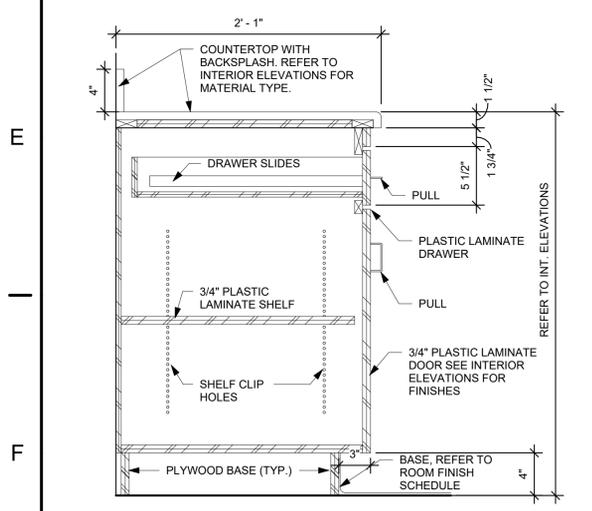


F1 TYP. "B" CABINET DETAIL
1 1/2" = 1'-0"

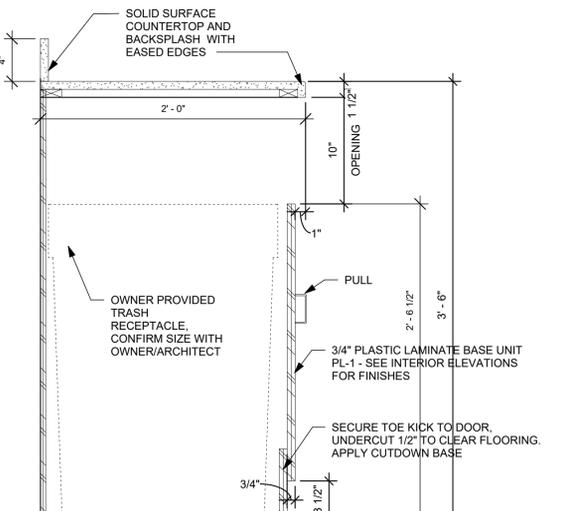

F3 TYP. "B2T" CABINET DETAIL
1 1/2" = 1'-0"

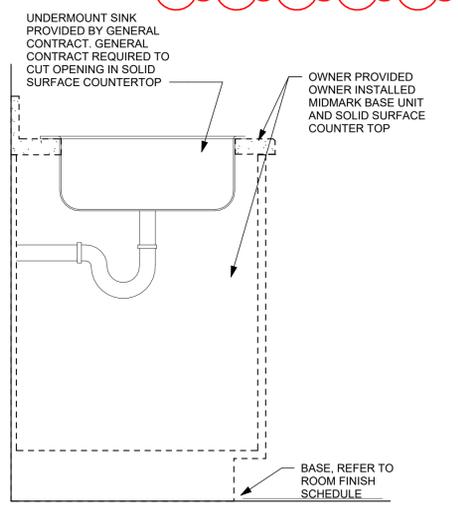

F5 "BS" MIDMARK SINK BASE CABINET
1 1/2" = 1'-0"

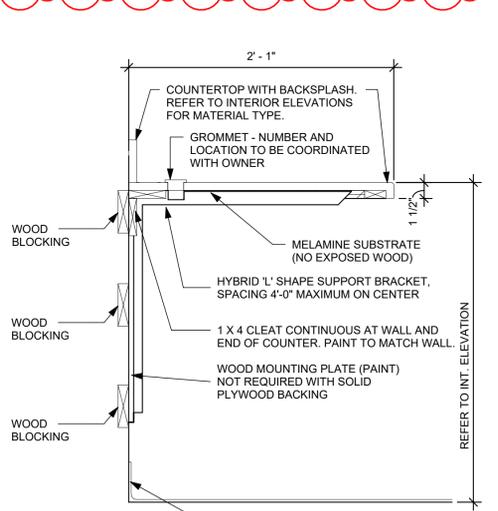

F6 TYP. WORKING SURFACE DETAIL
1 1/2" = 1'-0"

APP Architecture
creative focused design

615 Woodside Drive, Englewood, Ohio 45322
T 937.836.8898 F 937.832.3696
www.app-arch.com

Todd A. Gindalberger, License #12147
Expiration Date 12/31/2027

POD 3 INTERIOR RENOVATION
FAMILY HEALTH SERVICES OF DARKE COUNTY
5735 MEEKER ROAD, GREENVILLE, OH 45331

ISSUE		
NO.	DATE	DESCRIPTION
1	03.16.2026	FOR BID & PERMIT
	03.20.2026	ADDENDUM #1

DATE	3.16.26
JOB NO.	3853.04
DRAWN	RNL
CHECKED	MES/TAG
COPYRIGHT © 2026 - App Architecture, Inc.	
TITLE CASEWORK DETAILS	
SHEET NO. A8.1	

3/27/2026 11:06:22 AM

1 | 2 | 3 | 4 | 5 | 6 | 7